


GRW Record Drawings

BID SET

FALL CREEK REGIONAL WASTE DISTRICT SANITARY SEWER REHABILITATION PROJECT PHASE I

PENDLETON, INDIANA

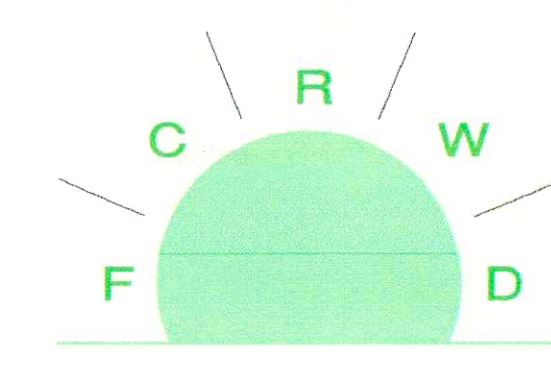

Jack Hutton


FCRWD MEMBERS

MARK A. JABLONSKI	- PRESIDENT
MICHELLE W. PATISHALL	- VICE PRESIDENT
GREGORY L. VALENTINE	- TREASURER
DAVID K. PADGETT	- SECRETARY
STEPHEN J. BILL	- DEPUTY SECRETARY/TREASURER
TIMOTHY E. GREEN	- BOARD MEMBER
KURT L. KAHL	- BOARD MEMBER
JACK C. WEIST	- BOARD MEMBER
ALBERT B. STEWART	- BOARD MEMBER
TERESA HUTTON	- GENERAL MANAGER
STEVE UNGER	- ATTORNEY



engineering | architecture | geospatial


www.grwinc.com

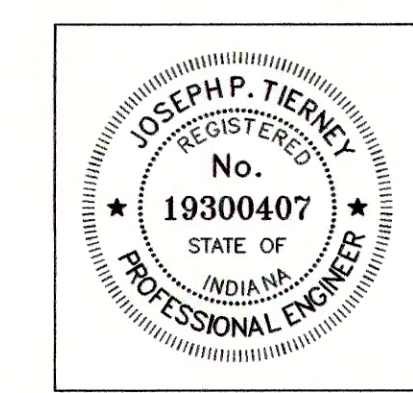

JOSEPH P. TIERNEY, P.E.
INDIANA REG. NO. 19300407

DATE: 4-22-2016

APRIL 2016

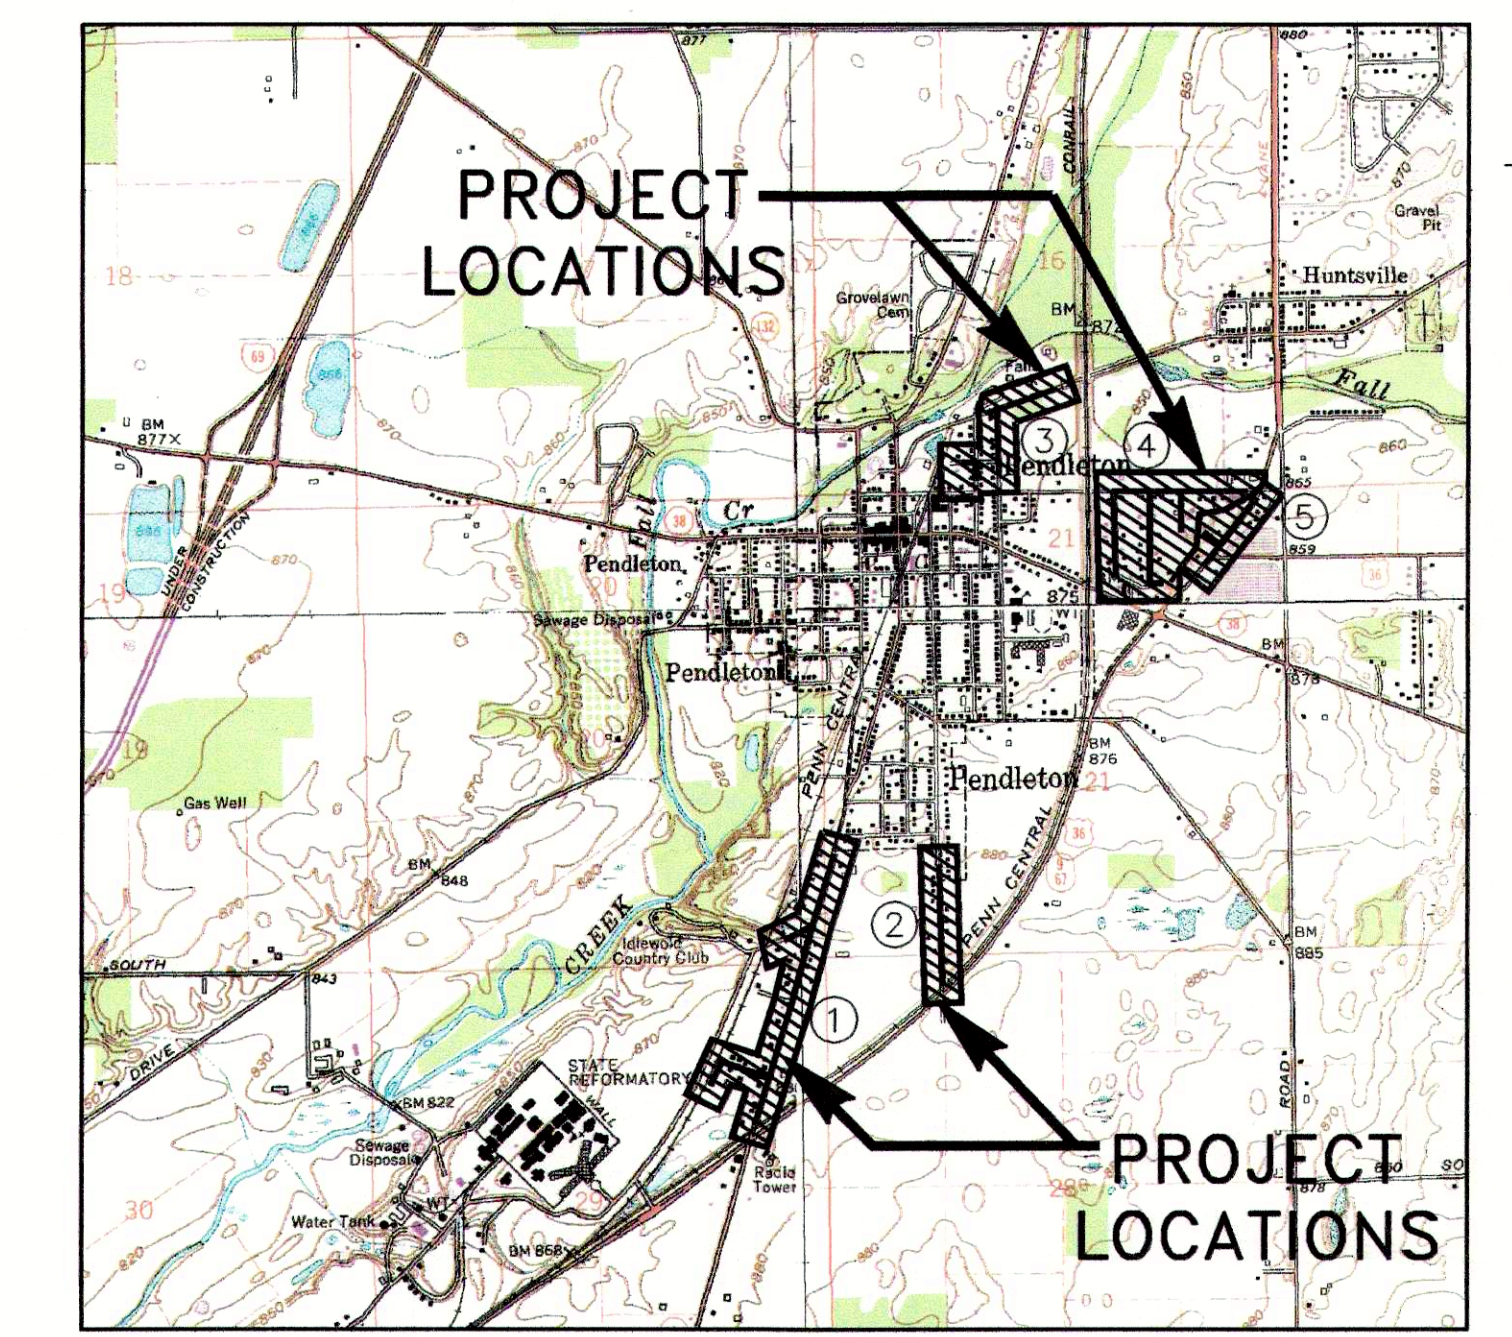

SCALE: 1" = 2000'

PROJECT AREAS:

- ① SOUTH PENDLETON
- ② SOUTH BROADWAY
- ③ FALLS PARK
- ④ EAST WATER STREET
- ⑤ STATE ROAD 67

PLAN SET IS FULL SCALE ON 24"x36"
AND HALF SCALE ON 12"x18"

*Pendleton
Phase I
As-built*

SRF NO. WW16074803
GRW PROJECT NO. 4447-14

PRINTED: 6/24/2016 @ 11:54AM
FILE NAME: G:\4447-FCRWD-2015\Working Drawings\AutoCAD\REHABILITATION PHASE I\4447-14-G-00.dwg

PRINTED: 6/24/2016 @ 11:55AM

FILE NAME: G:\447-FCR\VD-2015\Working Drawings\AutoCAD\REHABILITATION PHASE 1\447-14-G-01.dwg

GENERAL NOTES:

1. THE FOLLOWING GENERAL NOTES ARE APPLICABLE TO THE ENTIRE SET OF PLANS, AND ARE NOT SHOWN ON EACH INDIVIDUAL SHEET. HOWEVER, THIS DOES TO RELIEVE THE CONTRACTOR OF ANY RESPONSIBILITY TO PROVIDE THESE ITEMS FOR ALL AREAS.

2. PROPERTY LINES AND RIGHTS-OF-WAY SHOWN ARE BASED ON DEED RESEARCH AND THE RECORD DRAWINGS FOR THE SANITARY SEWER AND SHALL BE CONSIDERED APPROXIMATE.

3. THE DISTRICT ASSUMES NO RESPONSIBILITY FOR THE LACK OF LOCATION OR MISSED LOCATION OF EXISTING UTILITIES.

4. THE CONTRACTOR SHOULD VERIFY THE EXISTING CONDITIONS TO HIS SATISFACTION PRIOR TO BEGINNING ANY EXCAVATION. INDIANA UNDERGROUND UTILITIES PROTECTION SERVICE SHALL BE NOTIFIED AT LEAST 72 HOURS PRIOR TO BEGINNING ANY WORK. INDIANA UNDERGROUND UTILITIES PROTECTION SERVICE TELEPHONE IS 811.

5. ALL DISTURBED AREAS, INCLUDING BUT NOT LIMITED TO STREETS, DRIVES, WALKS, FENCES, LAWNS, ETC. SHALL BE RESTORED TO CONDITIONS EQUAL TO OR BETTER THAN THOSE PRIOR TO CONSTRUCTION.

6. BASELINE STATIONING IS ALONG THE CENTERLINE OF PROPOSED SEWER.

7. ALL EXISTING SIZES AND LOCATIONS OF EXISTING UTILITIES ARE BASED ON BEST INFORMATION AVAILABLE. HOWEVER, THE ENGINEER DOES NOT GUARANTEE OR ASSURE THAT SUCH INFORMATION IS TRUE OR APPROXIMATE. THE CONTRACTOR SHALL DETERMINE WHICH UTILITIES MAY CONFLICT WITH HIS WORK AND VERIFY THEIR LOCATIONS, SIZES, AND INVERTS, ETC. ADJUST HIS WORK ACCORDINGLY, AND NOTIFY THE ENGINEER OF ANY SUCH CONFLICT. THE CONTRACTOR SHALL REFER TO SPECIFICATIONS RELATIVE TO THE ABOVE.

8. ALL INFORMATION REGARDING HORIZONTAL AND VERTICAL LOCATIONS OF THE EXISTING SEWERS ARE BASED ON THE BEST INFORMATION AVAILABLE UTILIZING RECORD DRAWINGS. THE ENGINEER DOES NOT GUARANTEE OR ASSURE THAT SUCH INFORMATION IS TRUE OR ACCURATE. THE CONTRACTOR SHALL FIELD VERIFY THOSE ELEVATIONS, ETC. AND ADJUST HIS WORK ACCORDINGLY TO MAINTAIN POSITIVE DOWN HILL SLOPE ON THE NEW SEWERS TO AT LEAST MATCH THE EXISTING SLOPE RELATIVE TO THE VERIFIED ELEVATIONS, AND NOTIFY THE ENGINEER OF ANY SUCH CHANGE FOR APPROVAL.

9. THE CONTRACTOR IS RESPONSIBLE FOR RELOCATING, ADJUSTING, AND/OR HOLDING ANY UTILITY LINE AND/OR ASSOCIATED SERVICE POLE, OR DOWN GUY AT HIS OWN EXPENSE. HE SHALL ALSO BE RESPONSIBLE TO CONTACT ANY UTILITY OWNER AS NECESSARY TO RESOLVE ALL UTILITY CONFLICTS INCURRED DURING THE COMPLETION OF HIS CONSTRUCTION OPERATIONS.

10. CONTRACTOR SHALL USE CAUTION DURING THEIR WORK SO AS TO NOT DAMAGE EXISTING UTILITIES, ETC. CONTRACTOR IS RESPONSIBLE FOR REPAIR AND/OR REPLACEMENT OF ANY UTILITIES DAMAGED AS A RESULT OF CONTRACTOR'S CONSTRUCTION OPERATIONS AND PRACTICES.

11. CONNECTIONS OF ROOF DRAINS, FOUNDATION DRAINS AND ANY OTHER CLEAN WATER CONNECTIONS TO THE SANITARY SEWER SYSTEMS ARE PROHIBITED.

12. LIMITS OF CONSTRUCTION SHALL BE MAINTAINED WITHIN PERMANENT, TEMPORARY EASEMENTS, AND RIGHT OF WAY AS SHOWN ON PLANS.

13. ALL INFORMATION REGARDING INVERTS, TOP OF CASTING, AND SLOPES OF THE SANITARY SEWER MAIN AND ALL INFORMATION REGARDING LOCATION, DEPTHS AND LENGTH OF SANITARY SEWER LATERALS ARE BASED ON THE BEST INFORMATION AVAILABLE UTILIZING RECORD DRAWINGS OF THE SANITARY SEWER SYSTEM. THE ENGINEER DOES NOT ASSURE THIS INFORMATION IS TRUE OR APPROXIMATE AND SHOULD BE VERIFIED BY THE CONTRACTOR. NOTIFY THE ENGINEER OF ANY CHANGE FOR APPROVAL.

14. THE CONTRACTOR IS RESPONSIBLE FOR TRAFFIC CONTROL. TRAFFIC CONTROL SHALL CONFORM TO APPLICABLE LOCAL/STATE STANDARDS.

15. CONTRACTOR SHALL NOTIFY RESIDENTS 48 HOURS PRIOR TO TEMPORARILY CLOSING PRIVATE DRIVEWAYS. CONTRACTOR SHALL BE RESPONSIBLE FOR CONTACTING AFFECTED UTILITIES, TRASH PICK-UP SERVICES, SCHOOL DISTRICT, AND EMERGENCY & LAW ENFORCEMENT AUTHORITIES REGARDING SAID CLOSURES. AFFECTED PRIVATE DRIVEWAYS SHALL NOT BE SHUT DOWN LONGER THAN 8 HOURS. TRAFFIC SHALL BE BARRICADED FROM DRIVEWAY OR DRIVEWAY SHALL BE STEEL PLATE SPANNED TO MINIMIZE CLOSURES.

16. CONTRACTOR SHALL REMOVE AND REPLACE ALL DRIVEWAY CULVERTS AFFECTED BY CONSTRUCTION WITH NEW DRIVEWAY CULVERT PIPING OF IN-KIND MATERIALS PER TOWN OF PENDLETON STANDARDS. CONTRACTOR SHALL ALSO PROVIDE TOWN APPROVED END SECTIONS ON EACH REPLACED CULVERT. THE CONTRACTOR SHALL OBTAIN THE ACTUAL INVERT ELEVATIONS OF EACH CULVERT TO BE REMOVED AND SUPPLY ELEVATIONS TO THE R.P.R. THE CONTRACTOR SHALL THEN PLACE THE NEW DRIVEWAY CULVERT AS CLOSE AS POSSIBLE TO THE FORMER INVERT ELEVATIONS AND PROVIDE POSITIVE DRAINAGE OF THE RECONSTRUCTED DITCH LINE.

17. CONTRACTOR SHALL CLEAN STREETS OF CONSTRUCTION DEBRIS DAILY TO THE SATISFACTION OF THE OWNER AND ENGINEER. CONTRACTOR SHALL FURTHER ENSURE THAT AT LEAST ONE LANE OF TRAFFIC IS OPEN AT ALL TIMES DURING CONSTRUCTION ALONG ROADWAYS UNLESS THE CONTRACTOR HAS WRITTEN APPROVAL AND AN APPROVED TRAFFIC MAINTENANCE PLAN FROM THE TOWN.

18. CONTRACTOR SHALL BE RESPONSIBLE FOR MONITORING SANITARY FLOW AND PROVIDING BYPASS PUMPING AND/OR SUPPLEMENTAL STORAGE AS REQUIRED DURING CONSTRUCTION OPERATIONS. SUCH FLOW SHALL BE MONITORED SO AS NOT TO ALLOW SEWAGE BACK-UP WHICH MAY CAUSE PROPERTY DAMAGE. THE CONTRACTOR IS FULLY RESPONSIBLE FOR ANY DAMAGE INCURRED AND MUST MAKE RESTITUTION WITH ANY AFFECTED PROPERTY OWNER(S). CONTRACTOR SHALL PROVIDE CONTINUOUS ON-SITE SUPERVISION OF ANY BYPASS PUMPING OPERATIONS THAT OCCUR DURING CONSTRUCTION & NON-CONSTRUCTION HOURS. PROPOSED BYPASS SYSTEM SHALL INCLUDE EMERGENCY STANDBY/BACK-UP PROVISIONS AND SHALL BE APPROVED BY THE OWNER AT LEAST TWO (2) FULL WORKING DAYS IN ADVANCE OF INITIATING ANY BYPASS OPERATIONS. CONTRACTOR SHALL COORDINATE BYPASS PUMPING EFFORTS WITH FALL CREEK REGIONAL WASTE DISTRICT.

19. THE GRAVITY SEWER PIPE LENGTHS SHOWN ON THE DRAWING ARE MEASURED FROM CENTER OF MANHOLE TO CENTER OF CONSECUTIVE MANHOLES.

20. BID SCHEDULE A INCLUDES DIG AND REPLACEMENT OF THE OLD VITRIFIED CLAY GRAVITY SEWER SEGMENTS WITH PVC SEWER AS SHOWN ON THESE DRAWINGS AND ALL ASSOCIATED WORK IDENTIFIED ON THESE PLANS AND IN THE SPECIFICATIONS.

21. BID SCHEDULE B INCLUDES CURED-IN-PLACE PIPE REHABILITATION OF THE SEWER SEGMENTS IDENTIFIED ON THESE DRAWINGS AND ALL ASSOCIATED WORK IDENTIFIED ON THESE PLANS AND IN THE SPECIFICATIONS.

22. ALL WORK SHALL CONFORM TO THE FALL CREEK WASTE DISTRICT STANDARDS FOR DESIGN AND CONSTRUCTION OF SANITARY SEWERS UNLESS OTHERWISE NOTED.

UTILITIES			
DESCRIPTION			
WATER, PUBLIC WORKS AND STREETS PENDLETON UTILITIES 100 WEST STATE STREET PENDLETON, IN 46064 765-208-0094 DONNIE MOYER 765-208-0093 ROY BAKER	GAS VECTREN ENERGY 2001 REV. J.T. MENIFEE STREET ANDERSON, IN 46016 765-620-0747 BRIAN HARGER	PHONE VERIZON 19845 NORTH U.S. 31 WESTFIELD, IN 46074 317-896-6005 STEVE COSTLOW	SEWER FALL CREEK REGIONAL WASTE DISTRICT 9378 S. COUNTY ROAD 650 WEST PENDLETON, IN 46064 765-778-7544 JOE ROWLETT
ELECTRIC PENDLETON UTILITIES 100 WEST STATE STREET PENDLETON, IN 46064 765-208-0104 CRAIG SWITZER	CABLE COMCAST CABLEVISION 9750 E. 105TH STREET, STE. 1600 NOBLESVILLE, IN, 46060 317-774-3384 MATT STRINGER	PHONE AT&T INDIANA 241 E. MARKET STREET HUNTINGTON, IN 46750 260-358-4507 CHRIS CARTWRIGHT	

EXISTING LEGEND

- EXISTING BENCHMARK

EXISTING CATCH BASIN

EXISTING CABLE BOX

EXISTING CONTROL POINT

EXISTING DECIDUOUS TREE

EXISTING ELECTRICAL BOX

EXISTING ELECTRIC METER

EXISTING ELECTRIC TRANSFORMER

EXISTING FIRE HYDRANT

EXISTING FLAG POLE

EXISTING FIBER OPTIC BOX

EXISTING GAS METER

EXISTING GAS MARKER

EXISTING GAS PRESSURE VALVE

EXISTING GAS STOP

EXISTING GAS VALVE

EXISTING GUY WIRE

EXISTING GRAVE STONE

EXISTING LIGHT POLE

EXISTING MAILBOX

EXISTING TELEPHONE MANHOLE

EXISTING PKNAIL FOUND

EXISTING PINE TREE

EXISTING POWER POLE

EXISTING SIGN

EXISTING SHRUB

EXISTING TEMP BENCHMARK

EXISTING TELEPHONE BOX

EXISTING TELEPHONE MARKER

EXISTING TRAFFIC POLE

EXISTING VALVE VAULT

EXISTING WATER METER

EXISTING WATER VALVE

EXISTING MANHOLE

EXISTING ELECTRIC MANHOLE

EXISTING FIBER OPTIC MANHOLE

EXISTING SANITARY MANHOLE

EXISTING STEAM MANHOLE

EXISTING STORM MANHOLE

DUCTILE IRON

RESTRAINED JOINT DUCTILE IRON
- ROAD

EXISTING DITCH

EXISTING POWER/ELECTRIC

EXISTING FENCE

EXISTING NATURAL GAS

EXISTING GUARDRAIL

EXISTING GRADE (PROFILE)

EXISTING PROPERTY LINE

EXISTING RAILROAD

EXISTING CABLE TV

EXISTING TELEPHONE LINE

EXISTING FIBER OPTIC LINE

EXISTING WATER SERVICE

EXISTING WATER'S EDGE

EXISTING RIGHT-OF-WAY

EXISTING SANITARY SEWER

EXISTING SANITARY SEWER LATERAL

EXISTING STORM SEWER

PROPOSED LEGEND

- PROPOSED SANITARY MANHOLE

PROPOSED CURB INLET

PROPOSED STORM MANHOLE

PROPOSED 11' BEND

PROPOSED 22' BEND

PROPOSED 45' BEND

PROPOSED 90' BEND

PROPOSED CAP

PROPOSED FIRE HYDRANT (2 ACCESS)

PROPOSED TEE

PROPOSED VERTICAL TEE

PROPOSED WATER VALVE

PROPOSED REDUCER

PROPOSED DITCH

PROPOSED RIGHT-OF-WAY

PROPOSED SANITARY SEWER

PROPOSED STORM SEWER

PROPOSED WATER SERVICE

PROPOSED FENCE

SURFACE RESTORATION AND BACKFILL

BORE AND JACK

DIRECTIONAL DRILL
- SANITARY LATERALS:

A

A= DISTANCE FROM DOWN STREAM MANHOLE

X

X= APPROX. DEPTH AT R/W

Y

Y= LENGTH FROM MAIN TO R/W

INDEX OF DRAWINGS

NO.	DRAWING TITLE
CIVIL/SITE WORK	
G-00	COVER SHEET
G-01	GENERAL NOTES
G-02	DRAWING INDEX & REHAB SCHEDULES
C-01	PLAN & PROFILE – STA. 24+34 TO STA. 10+50 LINE "A" – SOUTH PENDLETON AREA
C-02	PLAN & PROFILE – STA. 10+50 TO STA. 4+50 LINE "A" – SOUTH PENDLETON AREA
C-03	PLAN & PROFILE – STA. 4+50 TO STA. 9+34 LINE "A" – SOUTH PENDLETON AREA PLAN & PROFILE – STA. 0+00 TO STA. 8+12 LINE "B" – SOUTH PENDLETON AREA
C-04	PLAN & PROFILE – STA. 0+00 TO STA. 4+55 LINE "C" – SOUTH PENDLETON AREA PLAN & PROFILE – STA. 0+00 TO STA. 2+09 LINE "D" – FALLS PARK AREA PLAN & PROFILE – STA. 0+00 TO STA. 1+97 LINE "E" – FALLS PARK AREA
C-05	PLAN & PROFILE – STA. 4+96 TO STA. 4+40 LINE "F" – SOUTH BROADWAY AREA
C-06	PLAN & PROFILE – STA. 0+00 TO STA. 7+55 LINE "G" – FALLS PARK AREA PLAN & PROFILE – STA. 0+00 TO STA. 3+51 LINE "H" – EAST WATER STREET AREA
C-07	PLAN & PROFILE – STA. 0+00 TO STA. 7+33 LINE "J" – FALLS PARK AREA PLAN & PROFILE – STA. 0+00 TO STA. 4+50 LINE "J" – EAST WATER STREET AREA
C-08	PLAN & PROFILE – STA. 4+50 TO STA. 12+77 LINE "J" – EAST WATER STREET AREA PLAN & PROFILE – STA. 0+00 TO STA. 4+50 LINE "K" – EAST WATER STREET AREA
C-09	PLAN & PROFILE – STA. 4+50 TO STA. 10+92 LINE "K" – EAST WATER STREET AREA PLAN & PROFILE – STA. 0+00 TO STA. 6+50 LINE "L" – EAST WATER STREET AREA
C-10	PLAN & PROFILE – STA. 6+50 TO STA. 12+76 LINE "L" – EAST WATER STREET AREA PLAN & PROFILE – STA. 0+00 TO STA. 1+96 LINE "M" – STATE ROAD 67 AREA
C-11	PLAN & PROFILE – STA. 0+00 TO STA. 10+78 LINE "N" – STATE ROAD 67 AREA
C-12	PLAN & PROFILE – STA. 0+00 TO STA. 12+44 LINE "O" – EAST STREET ALLEY
C-13	PLAN & PROFILE – STA. 0+00 TO STA. 3+88 LINE "P" – EAST STREET PLAN & PROFILE – STA. 0+00 TO STA. 2+85 LINE "Q" – McLOY DRIVE
C-14	MANHOLE REHABILITATION SCHEDULE
C-15	C.I.P.P. REHABILITATION SCHEDULE
C-16	STANDARD DETAILS
C-17	FALL CREEK STANDARD DETAILS
C-18	EROSION CONTROL DETAILS
C-19	MAINTENANCE OF TRAFFIC
C-20	MAINTENANCE OF TRAFFIC



Indiana Underground Plant Protection Service
CALL TWO WORKING DAYS
BEFORE YOU DIG
IT'S THE LAW
811

GRW PROJECT NO. 4447-14

SRF NO. WW16074803

ALL RIGHTS RESERVED. PROPERTY OF GRW ENGINEERS, INC. AND SHALL NOT BE REPRODUCED OR TRANSMITTED IN ANY FORM OR BY ANY MEANS, ELECTRONIC OR MECHANICAL, INCLUDING PHOTOCOPYING, RECORDING, OR BY ANY INFORMATION STORAGE AND RETRIEVAL SYSTEM, WITHOUT WRITTEN PERMISSION.

engineering | architecture | geospatial

www.grwinc.com

GENERAL NOTES

SANITARY SEWER REHABILITATION

FALL CREEK REGIONAL WASTE DISTRICT

PENDLETON, INDIANA


DESIGNED	GWL	DRAWN	GCR	REVIEWED	JPT	APPROVED	JPT
DATE	BY	DATE	BY	DATE	BY	DATE	BY
DESCRIPTION		DESCRIPTION		DESCRIPTION		DESCRIPTION	
NO.		NO.		NO.		NO.	

SCALE CHECK: THIS MARK SHOULD MEASURE EXACTLY 1" WHEN PLOTTED

DATE: APRIL 2016

SCALE: N.T.S.

 SHEET NO. G-01



REF NO: WWH6074803



engineering | architecture | design

•

DRAWING INDEX
SANITARY SEWER REHABILITATION
FALL CREEK REGIONAL WASTE DISTRICT
PENDLETON, INDIANA

REVISIONS			DESIGNER		GWL	
NO.	DESCRIPTION	DATE	BY			
*****	*****	****	****			DRAWN
						GOR
						REVIEWED
						JPT
						APPROVED
						JPT


DATE:
APRIL 2016

SCALE:
N.T.S.

SHEET NO.


G-02

FILE NAME: G:\4447-FCRWD-2015\Working Drawings\AutoCAD\REHABILITATION PHASE I\4447-14-G-02.dwg

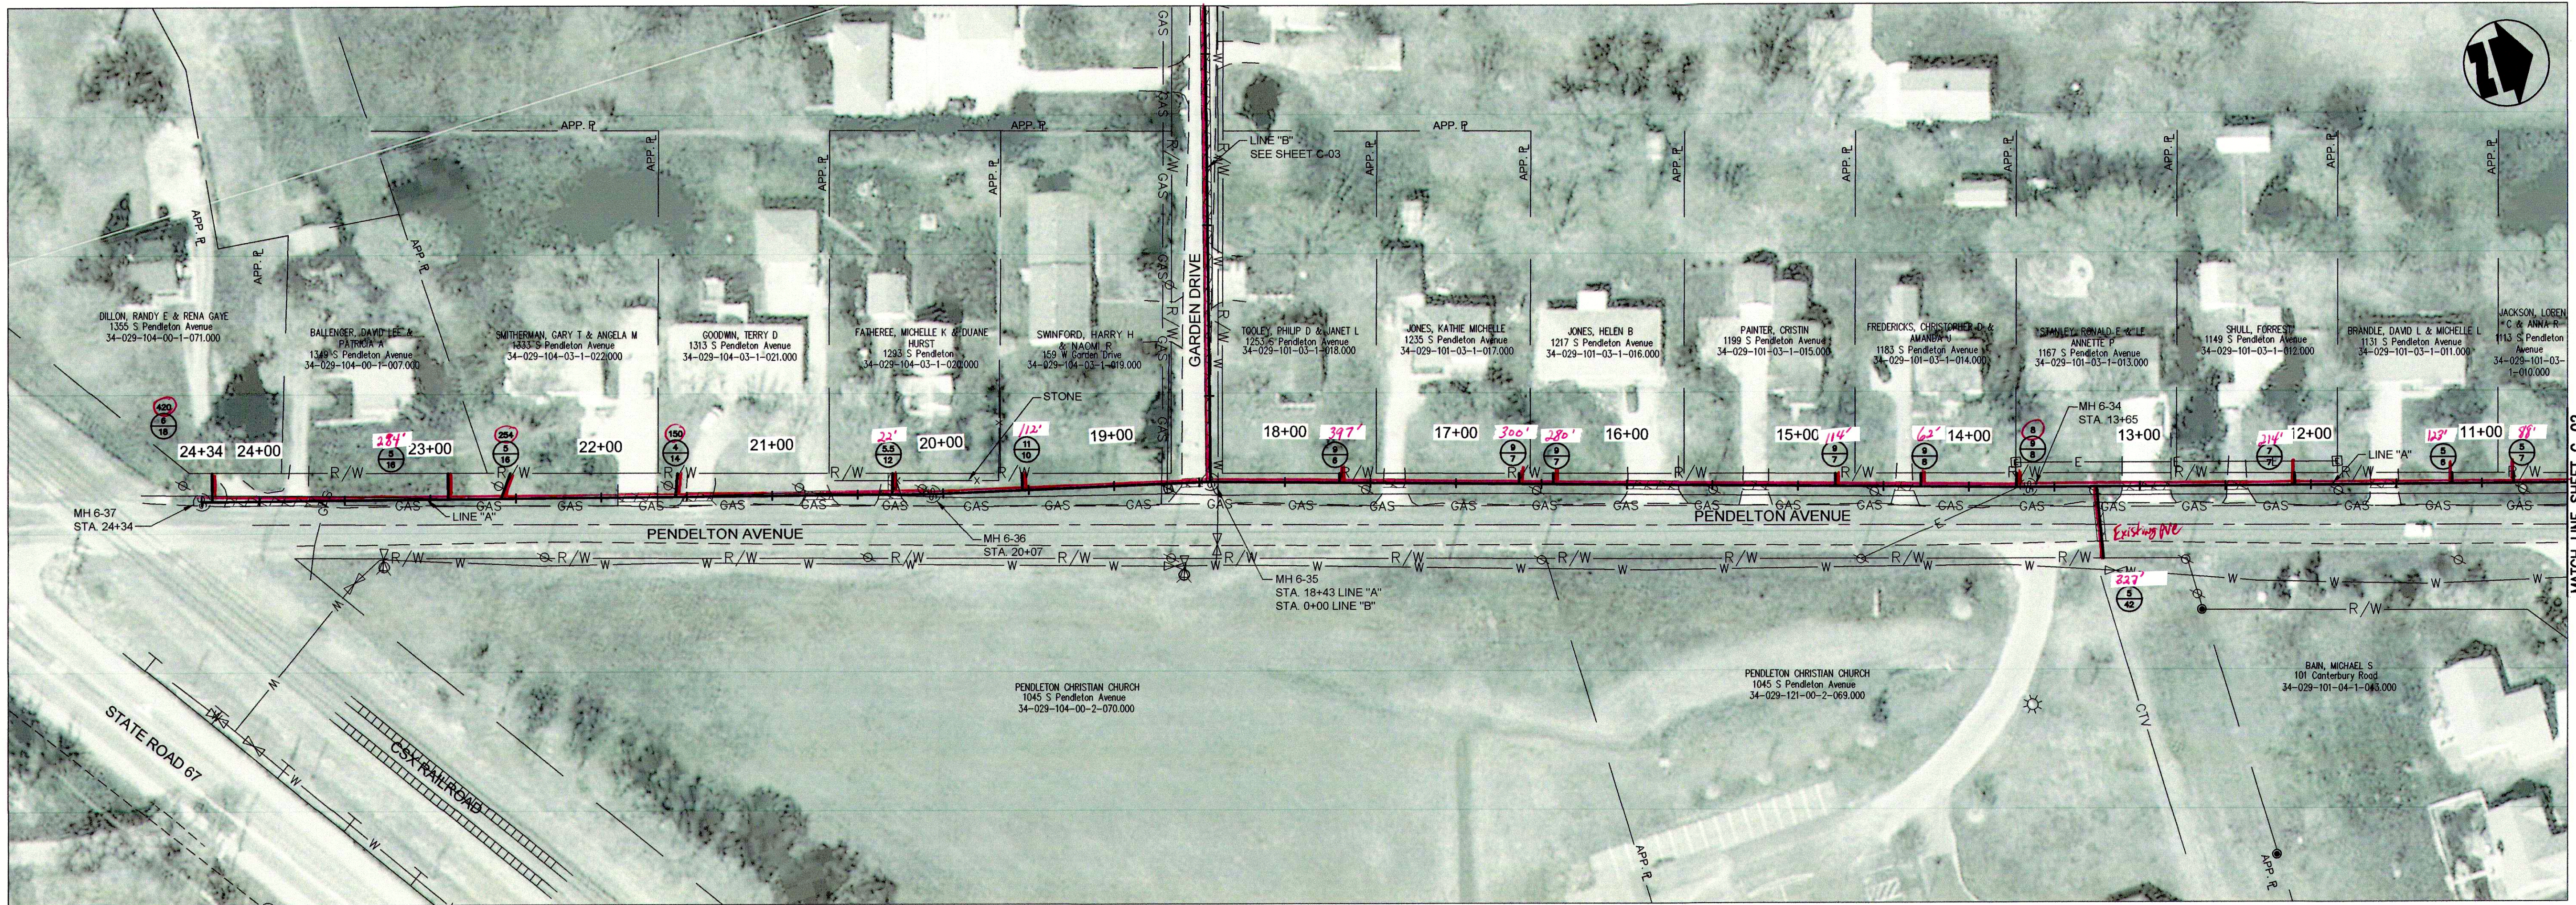

PLAN VIEW - STA. 24+34 TO STA. 10+50 LINE "A"

From MH# 6-37 to MH# 6-30 - CIPP

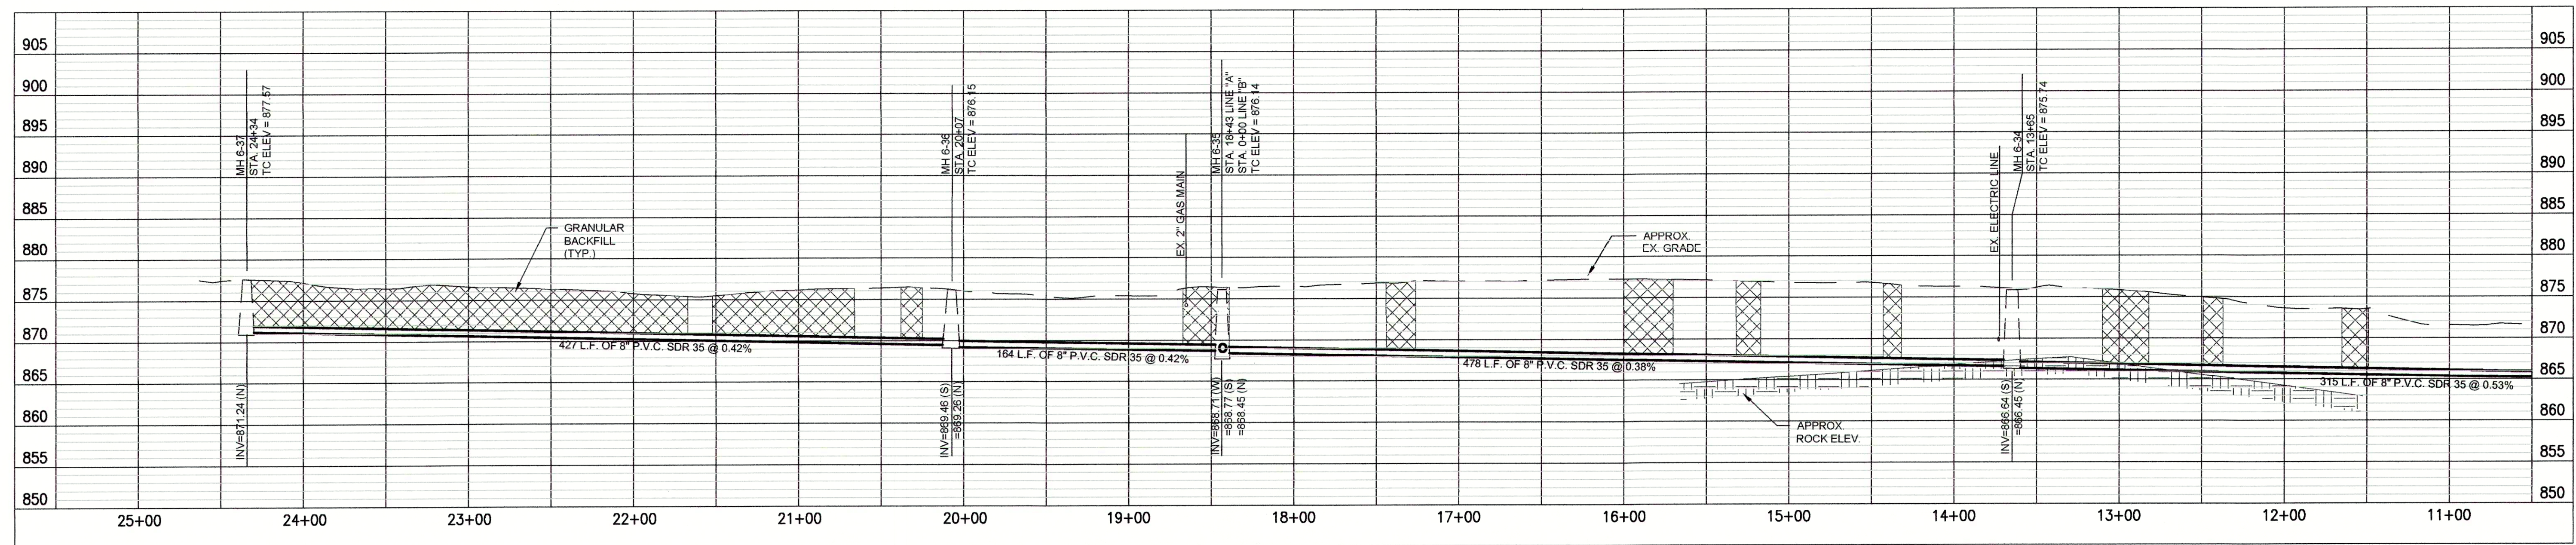

PROFILE - STA. 24+46 TO STA. 10+50 LINE "A"

"BID SCHEDULE A" (OPEN CUT) NOTES:

- LATERAL LOCATIONS SHOWN ARE BASED ON BEST AVAILABLE INFORMATION. CONTRACTOR TO FIELD VERIFY ALL EXISTING SANITARY LATERAL LOCATIONS AND DEPTHS. INSTALL 6" SDR 35 SEWER PIPE TO R/W LINE AND CONNECT TO EXISTING LATERAL.
- THE EXISTING MANHOLES ARE TO REMAIN IN PLACE WITH NEW SEWERS RECONNECTED. THE MANHOLES SHALL BE REHABILITATED PER THE MANHOLE REHABILITATION SCHEDULE.

BID SCHEDULES A & B NOTES:

- SANITARY LATERAL LEGEND:

A = DISTANCE FROM DOWN STREAM MANHOLE
X = APPROX. DEPTH AT R/W
Y = LENGTH FROM MAIN TO R/W

"BID SCHEDULE B" (CIPP) NOTES:

- LATERAL LOCATIONS SHOWN ARE BASED ON BEST AVAILABLE INFORMATION. CONTRACTOR TO FIELD VERIFY EXISTING SANITARY LATERAL LOCATIONS AND DEPTHS. FOR LATERAL REPLACEMENTS, MAKE CONNECTION DIRECTLY TO CIPP LINER AS SHOWN IN THE DETAILS AND ON SHEET C-16. INSTALL 6" SDR 35 SEWER PIPE FROM MAIN TO R/W LINE AND CONNECT TO EXISTING LATERAL.
- IF THE PLANS SHOW C.I.P.P. LATERAL REHABILITATION, COMPLETE PER THE DETAIL ON SHEET C-16.
- MANHOLE SHALL BE REHABILITATION PER THE MANHOLE REHABILITATION SCHEDULE.



GRW PROJECT NO. 4447-14
SRF NO. WY16074803
ALL RIGHTS RESERVED
THIS DRAWING IS THE PROPERTY OF
GRW ENGINEERS, INC. AND SHALL NOT
BE REPRODUCED OR TRANSMITTED IN ANY
FORM OR BY ANY MEANS, ELECTRONIC OR
MECHANICAL, WITHOUT WRITTEN PERMISSION.




PLAN & PROFILE
SANITARY SEWER REHABILITATION
FALL CREEK REGIONAL WASTE DISTRICT
PENDLETON, INDIANA


DESIGNED	BY	DATE	DESCRIPTION
GWL	BK	----	
DRAWN	BY	DATE	DESCRIPTION
GCR		----	
REVIEWED	BY	DATE	DESCRIPTION
JPT		----	
APPROVED	BY	DATE	DESCRIPTION
JPT		----	

DATE: APRIL 2016
SCALE: H: 1"=50' V: 1"=10'
SHEET NO.


C-01

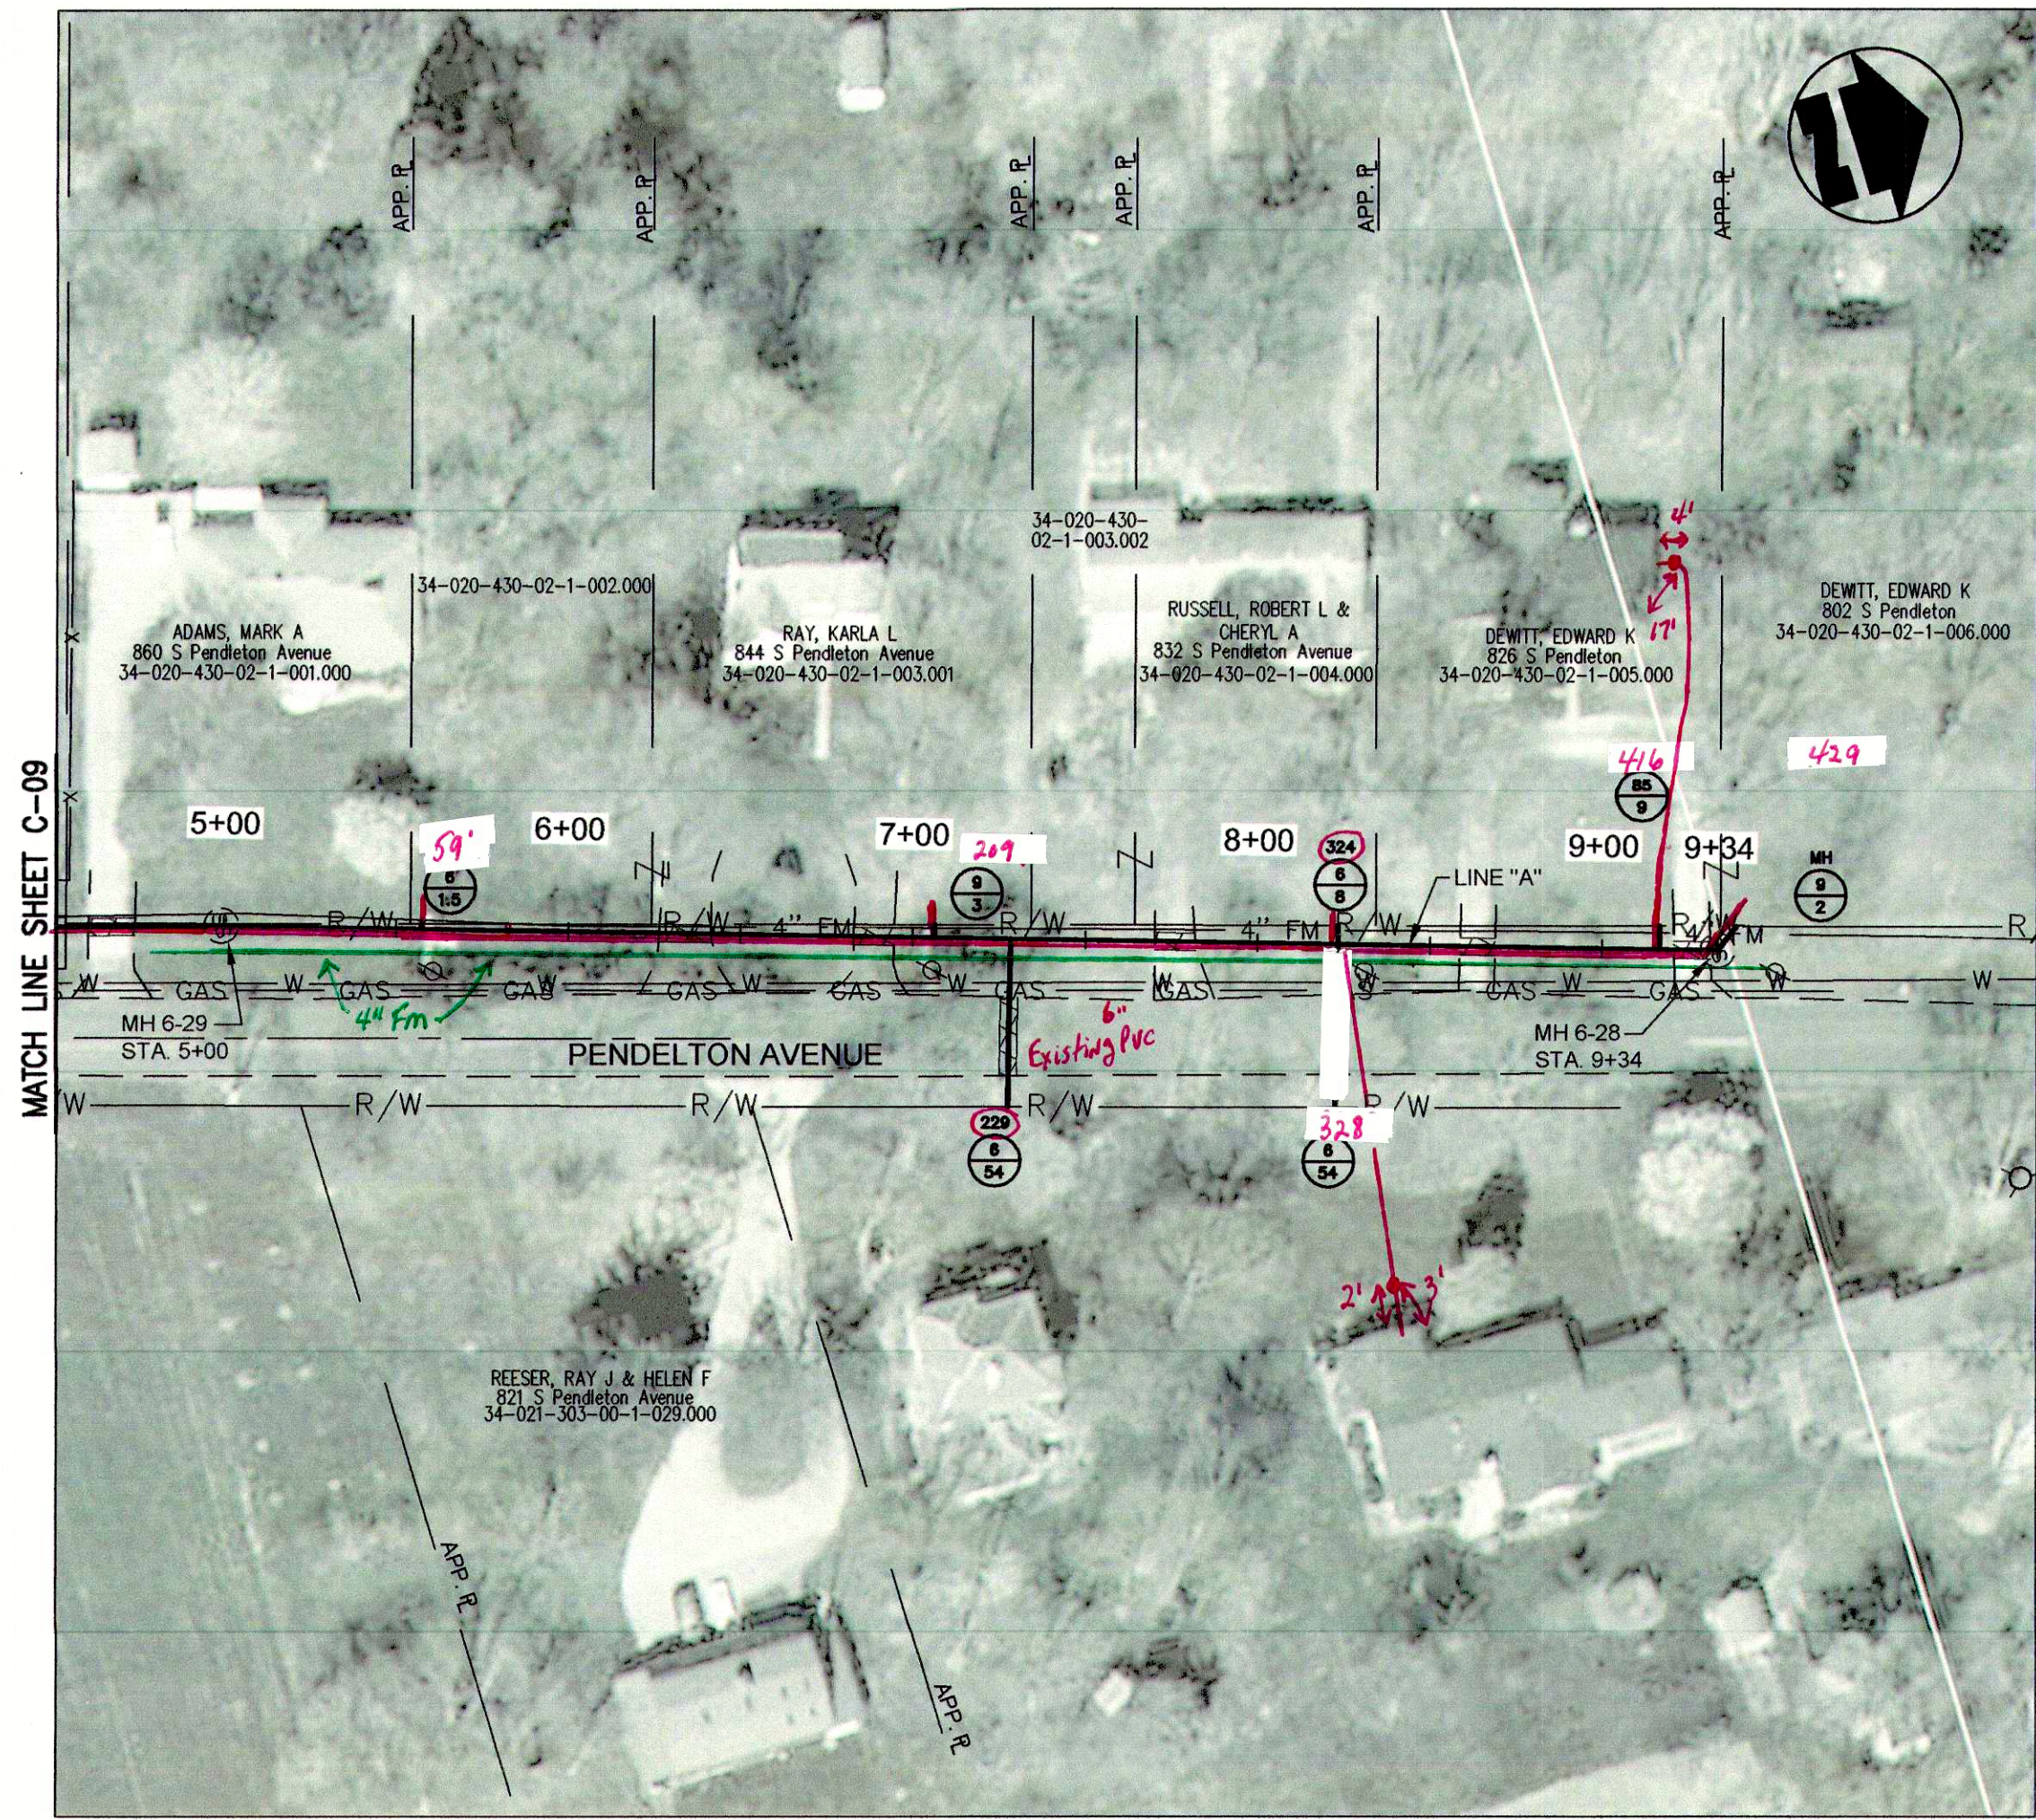

PLAN VIEW - STA. 4+50 TO E.O.P. STA. 9+34 LINE "A"

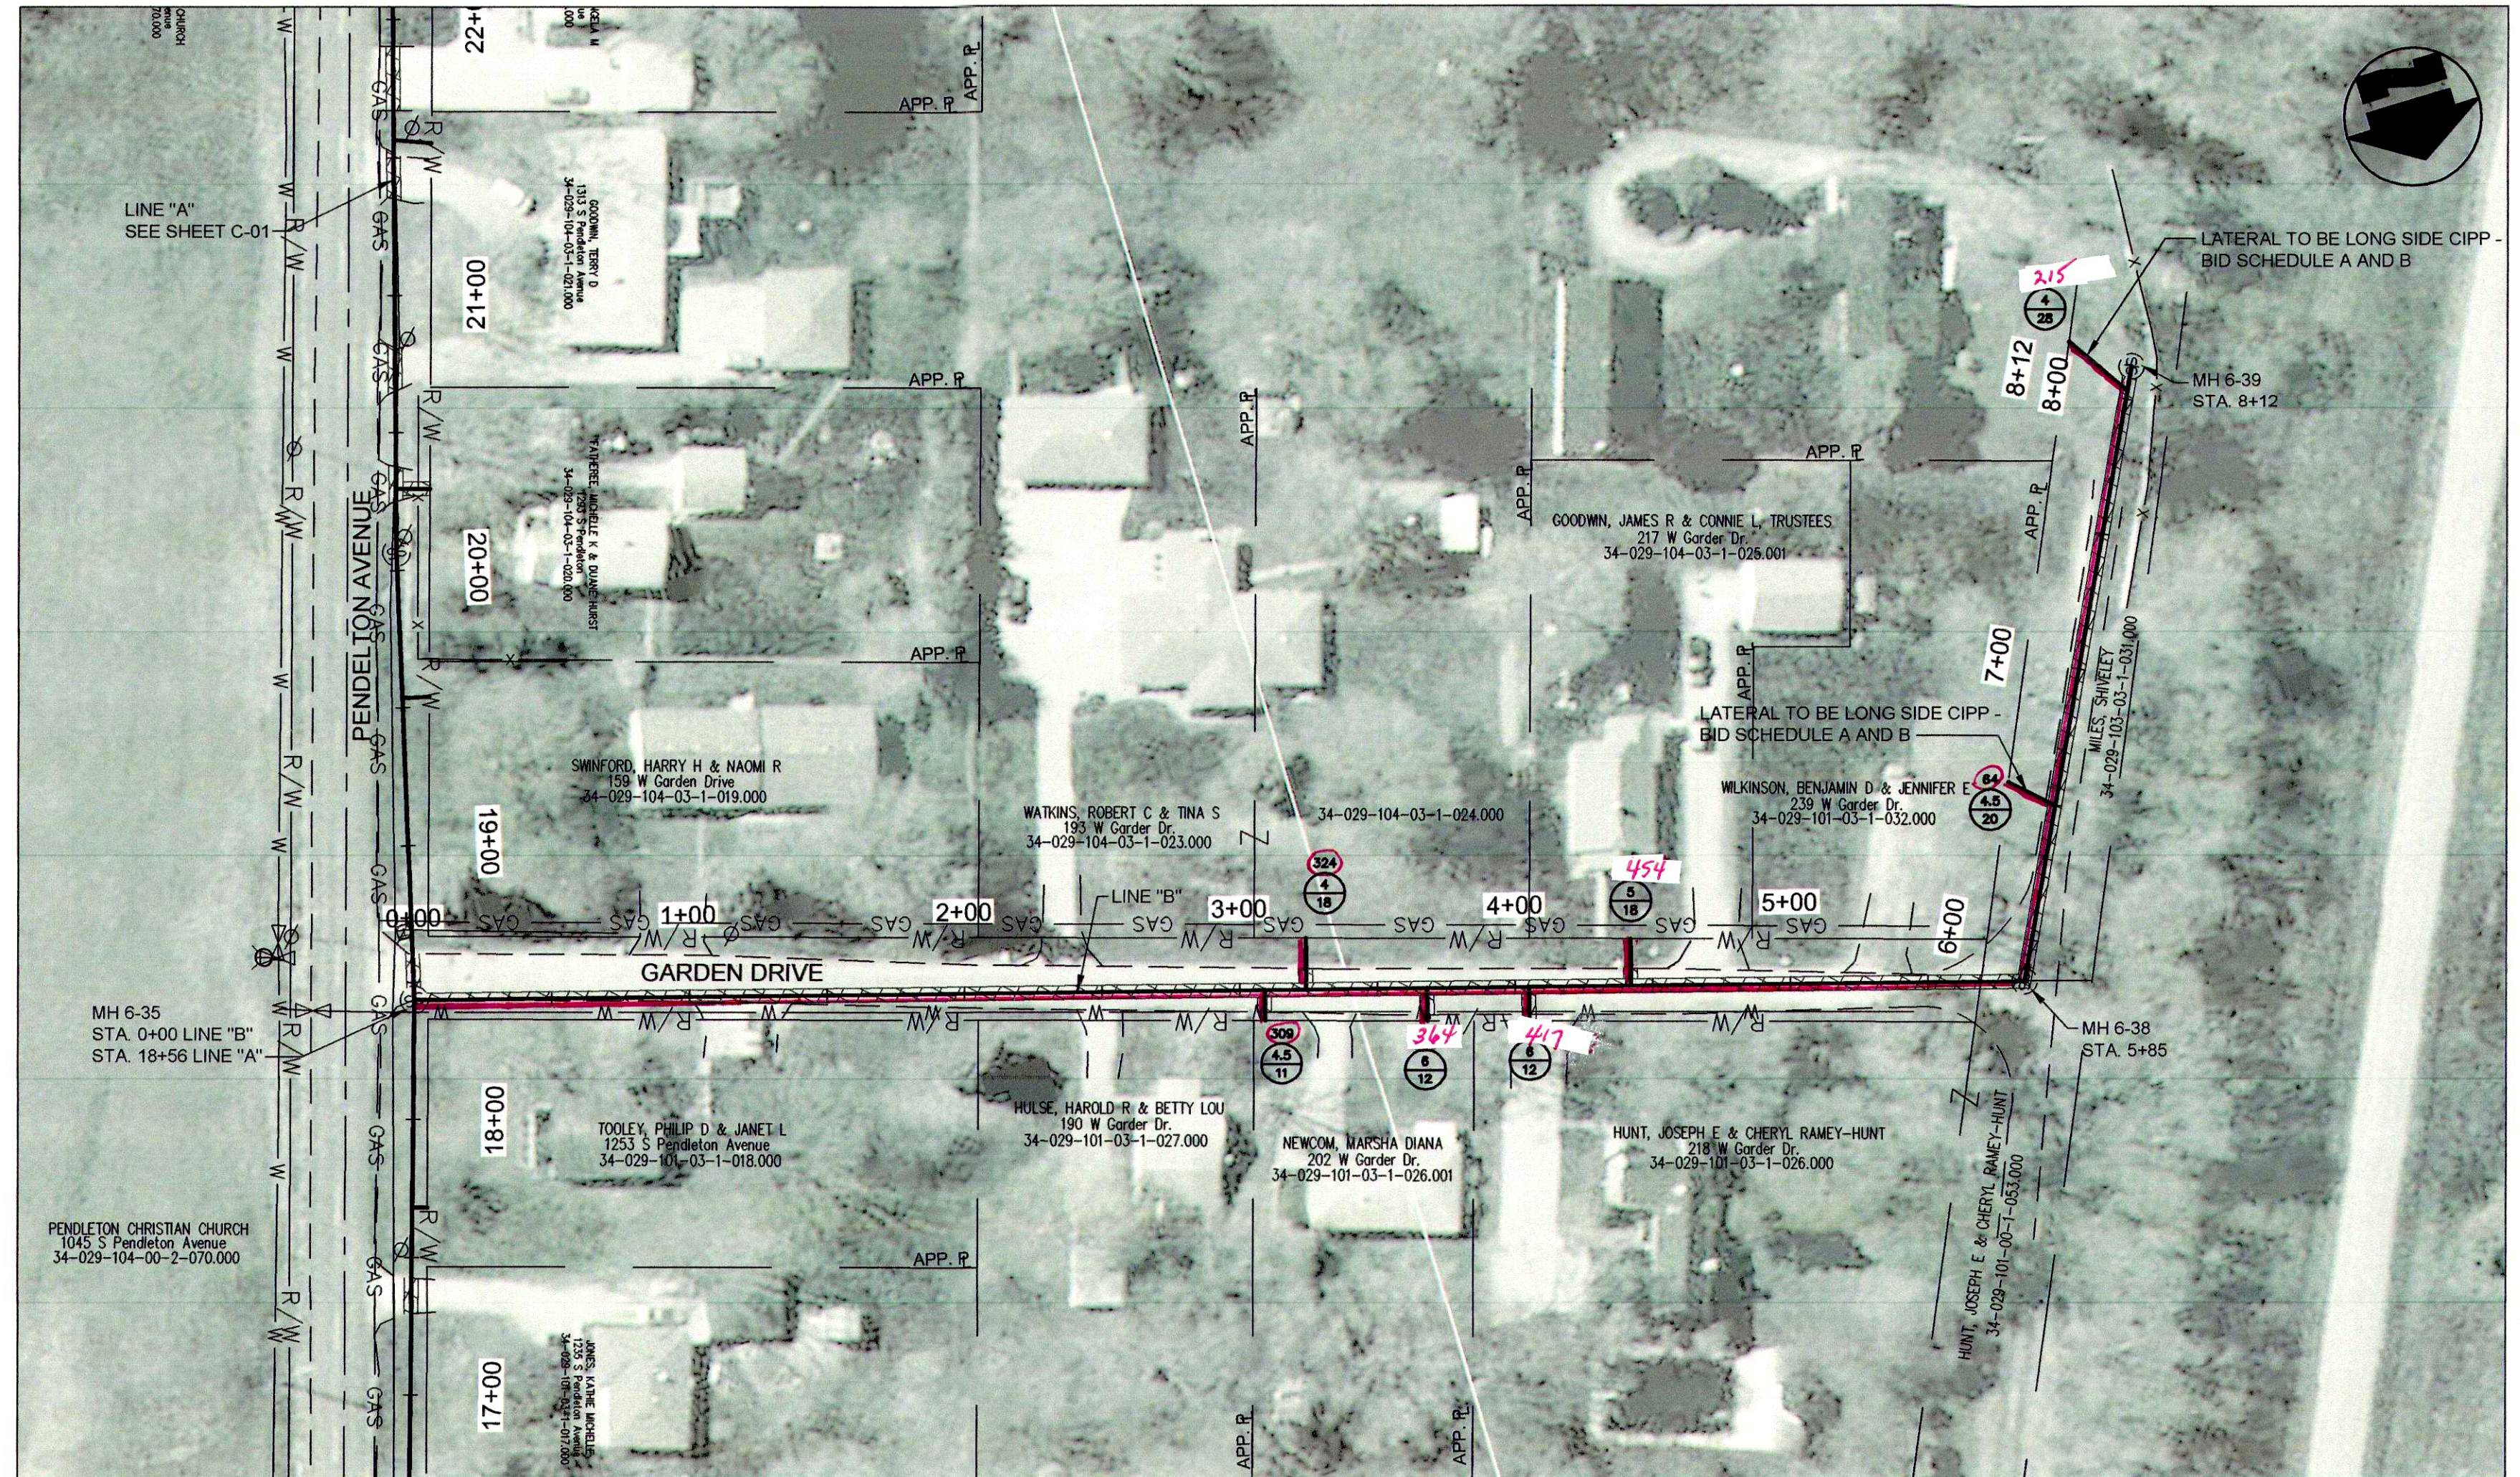


PLAN VIEW - STA. 0+00 TO STA. 8+12 LINE "B"

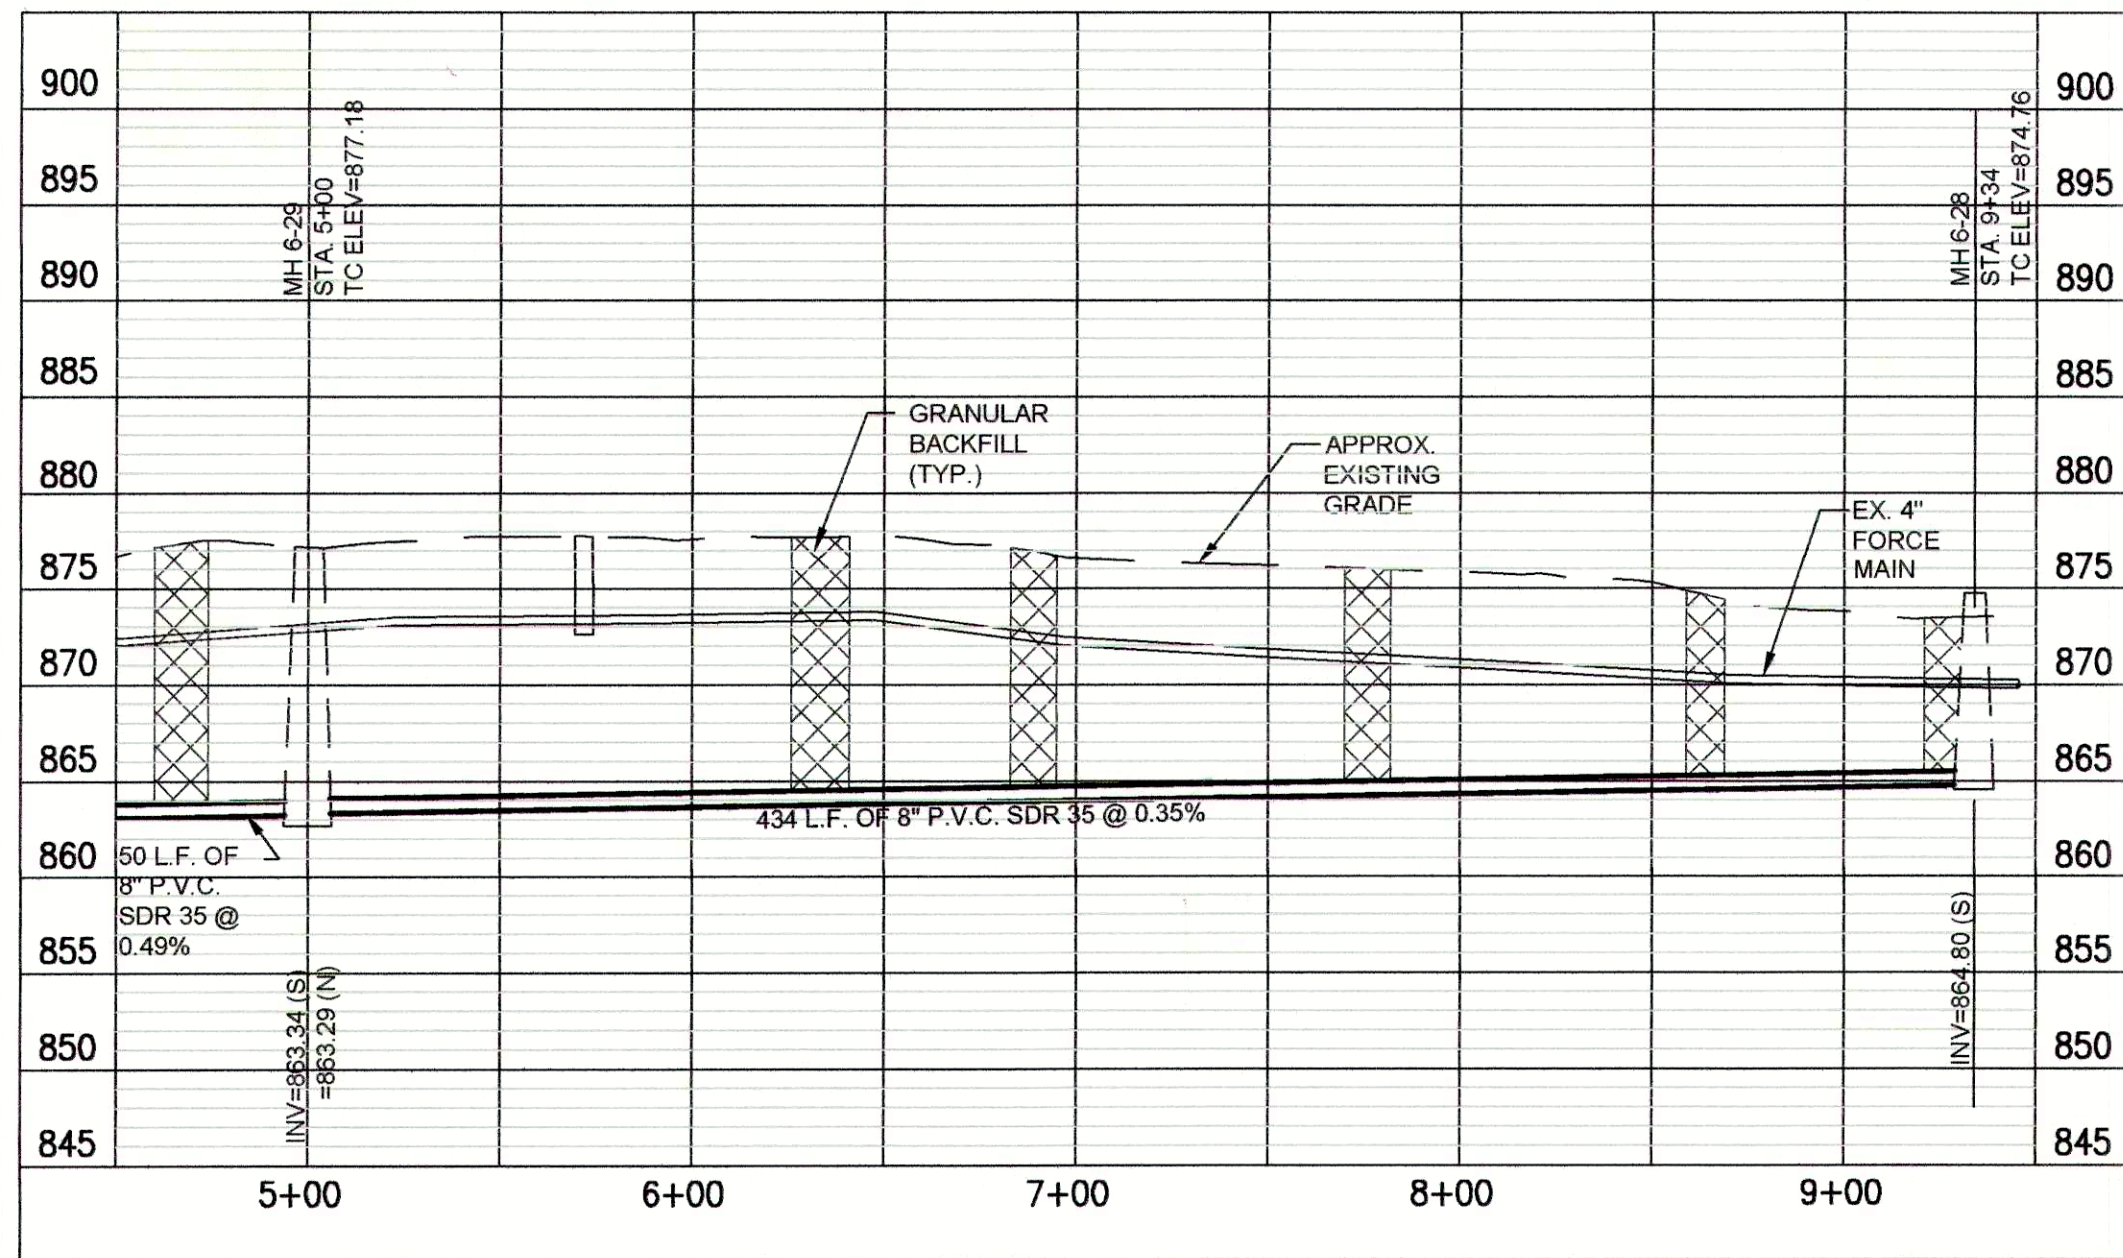

PROFILE - STA. 4+50 TO STA. 9+34 LINE "A"

"BID SCHEDULE A" (OPEN CUT) NOTES:


- LATERAL LOCATIONS SHOWN ARE BASED ON BEST AVAILABLE INFORMATION. CONTRACTOR TO FIELD VERIFY ALL EXISTING SANITARY LATERAL LOCATIONS AND DEPTHS. INSTALL 6" SDR 35 SEWER PIPE TO R/W LINE AND CONNECT TO EXISTING LATERAL.
- THE EXISTING MANHOLES ARE TO REMAIN IN PLACE WITH NEW SEWERS RECONNECTED. THE MANHOLES SHALL BE REHABILITATED PER THE MANHOLE REHABILITATION SCHEDULE.

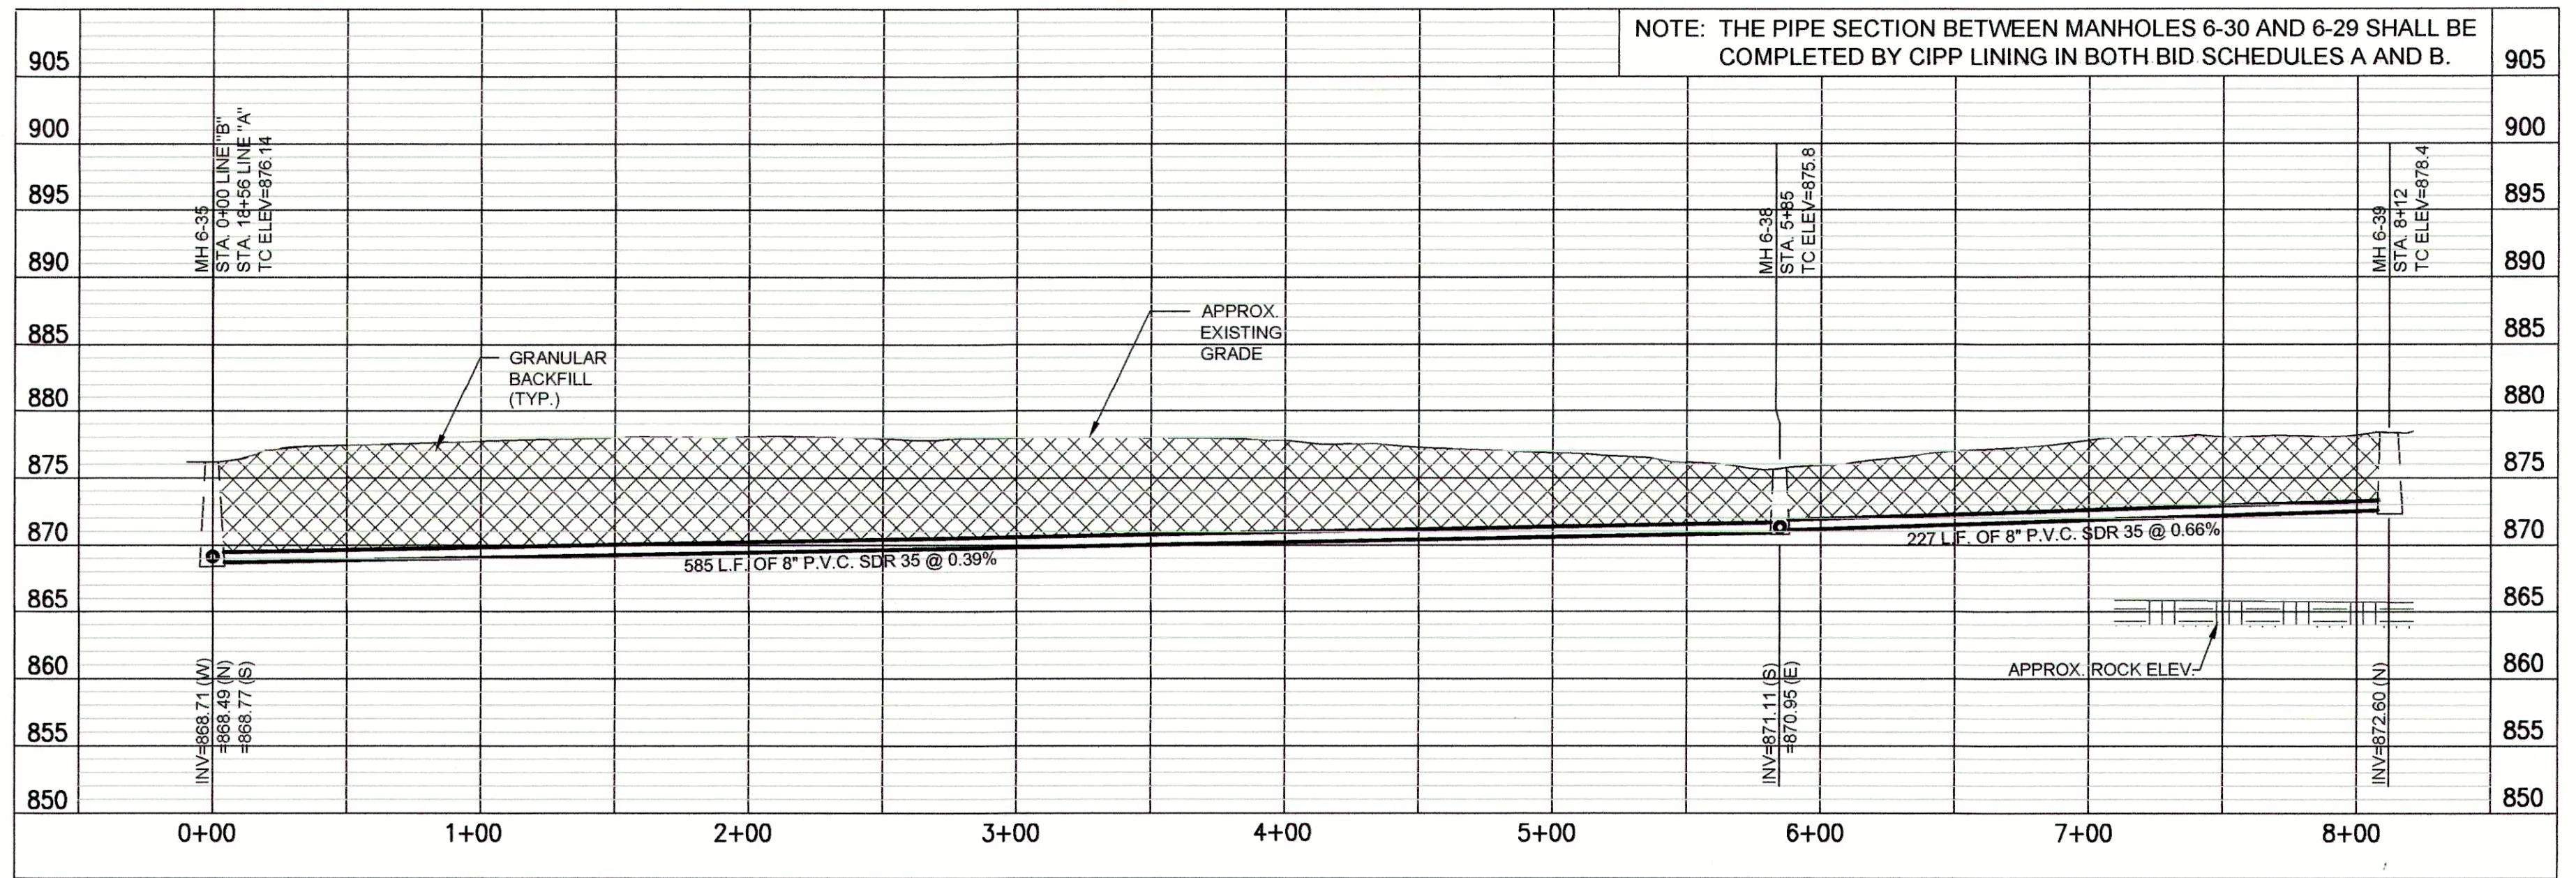

PROFILE - STA. 0+00 TO STA. 8+12 LINE "B"

BID SCHEDULES A & B NOTES:

- SANITARY LATERAL LEGEND:

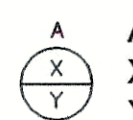

A= DISTANCE FROM DOWN STREAM MANHOLE
X= APPROX. DEPTH AT R/W
Y= LENGTH FROM MAIN TO R/W

"BID SCHEDULE B" (CIPP) NOTES:

- LATERAL LOCATIONS SHOWN ARE BASED ON BEST AVAILABLE INFORMATION. CONTRACTOR TO FIELD VERIFY EXISTING SANITARY LATERAL LOCATIONS AND DEPTHS. FOR LATERAL REPLACEMENTS, MAKE CONNECTION DIRECTLY TO CIPP LINER AS SHOWN IN THE DETAILS AND ON SHEET C-16. INSTALL 6" SDR 35 SEWER PIPE FROM MAIN TO R/W LINE AND CONNECT TO EXISTING LATERAL.
- IF THE PLANS SHOW C.I.P.P. LATERAL REHABILITATION, COMPLETE PER THE DETAIL ON SHEET C-16.
- MANHOLE SHALL BE REHABILITATION PER THE MANHOLE REHABILITATION SCHEDULE.



GRW PROJECT NO. 4447-14


SRF NO. WW16074803




PLAN & PROFILE
SANITARY SEWER REHABILITATION
FALL CREEK REGIONAL WASTE DISTRICT
PENDLETON, INDIANA

REVISIONS	DATE	BY	DESIGNED	GWL	GCR	JPT	JPT

DATE: APRIL 2016
SCALE: H: 1"=50' V: 1"=10'
SHEET NO: C-03

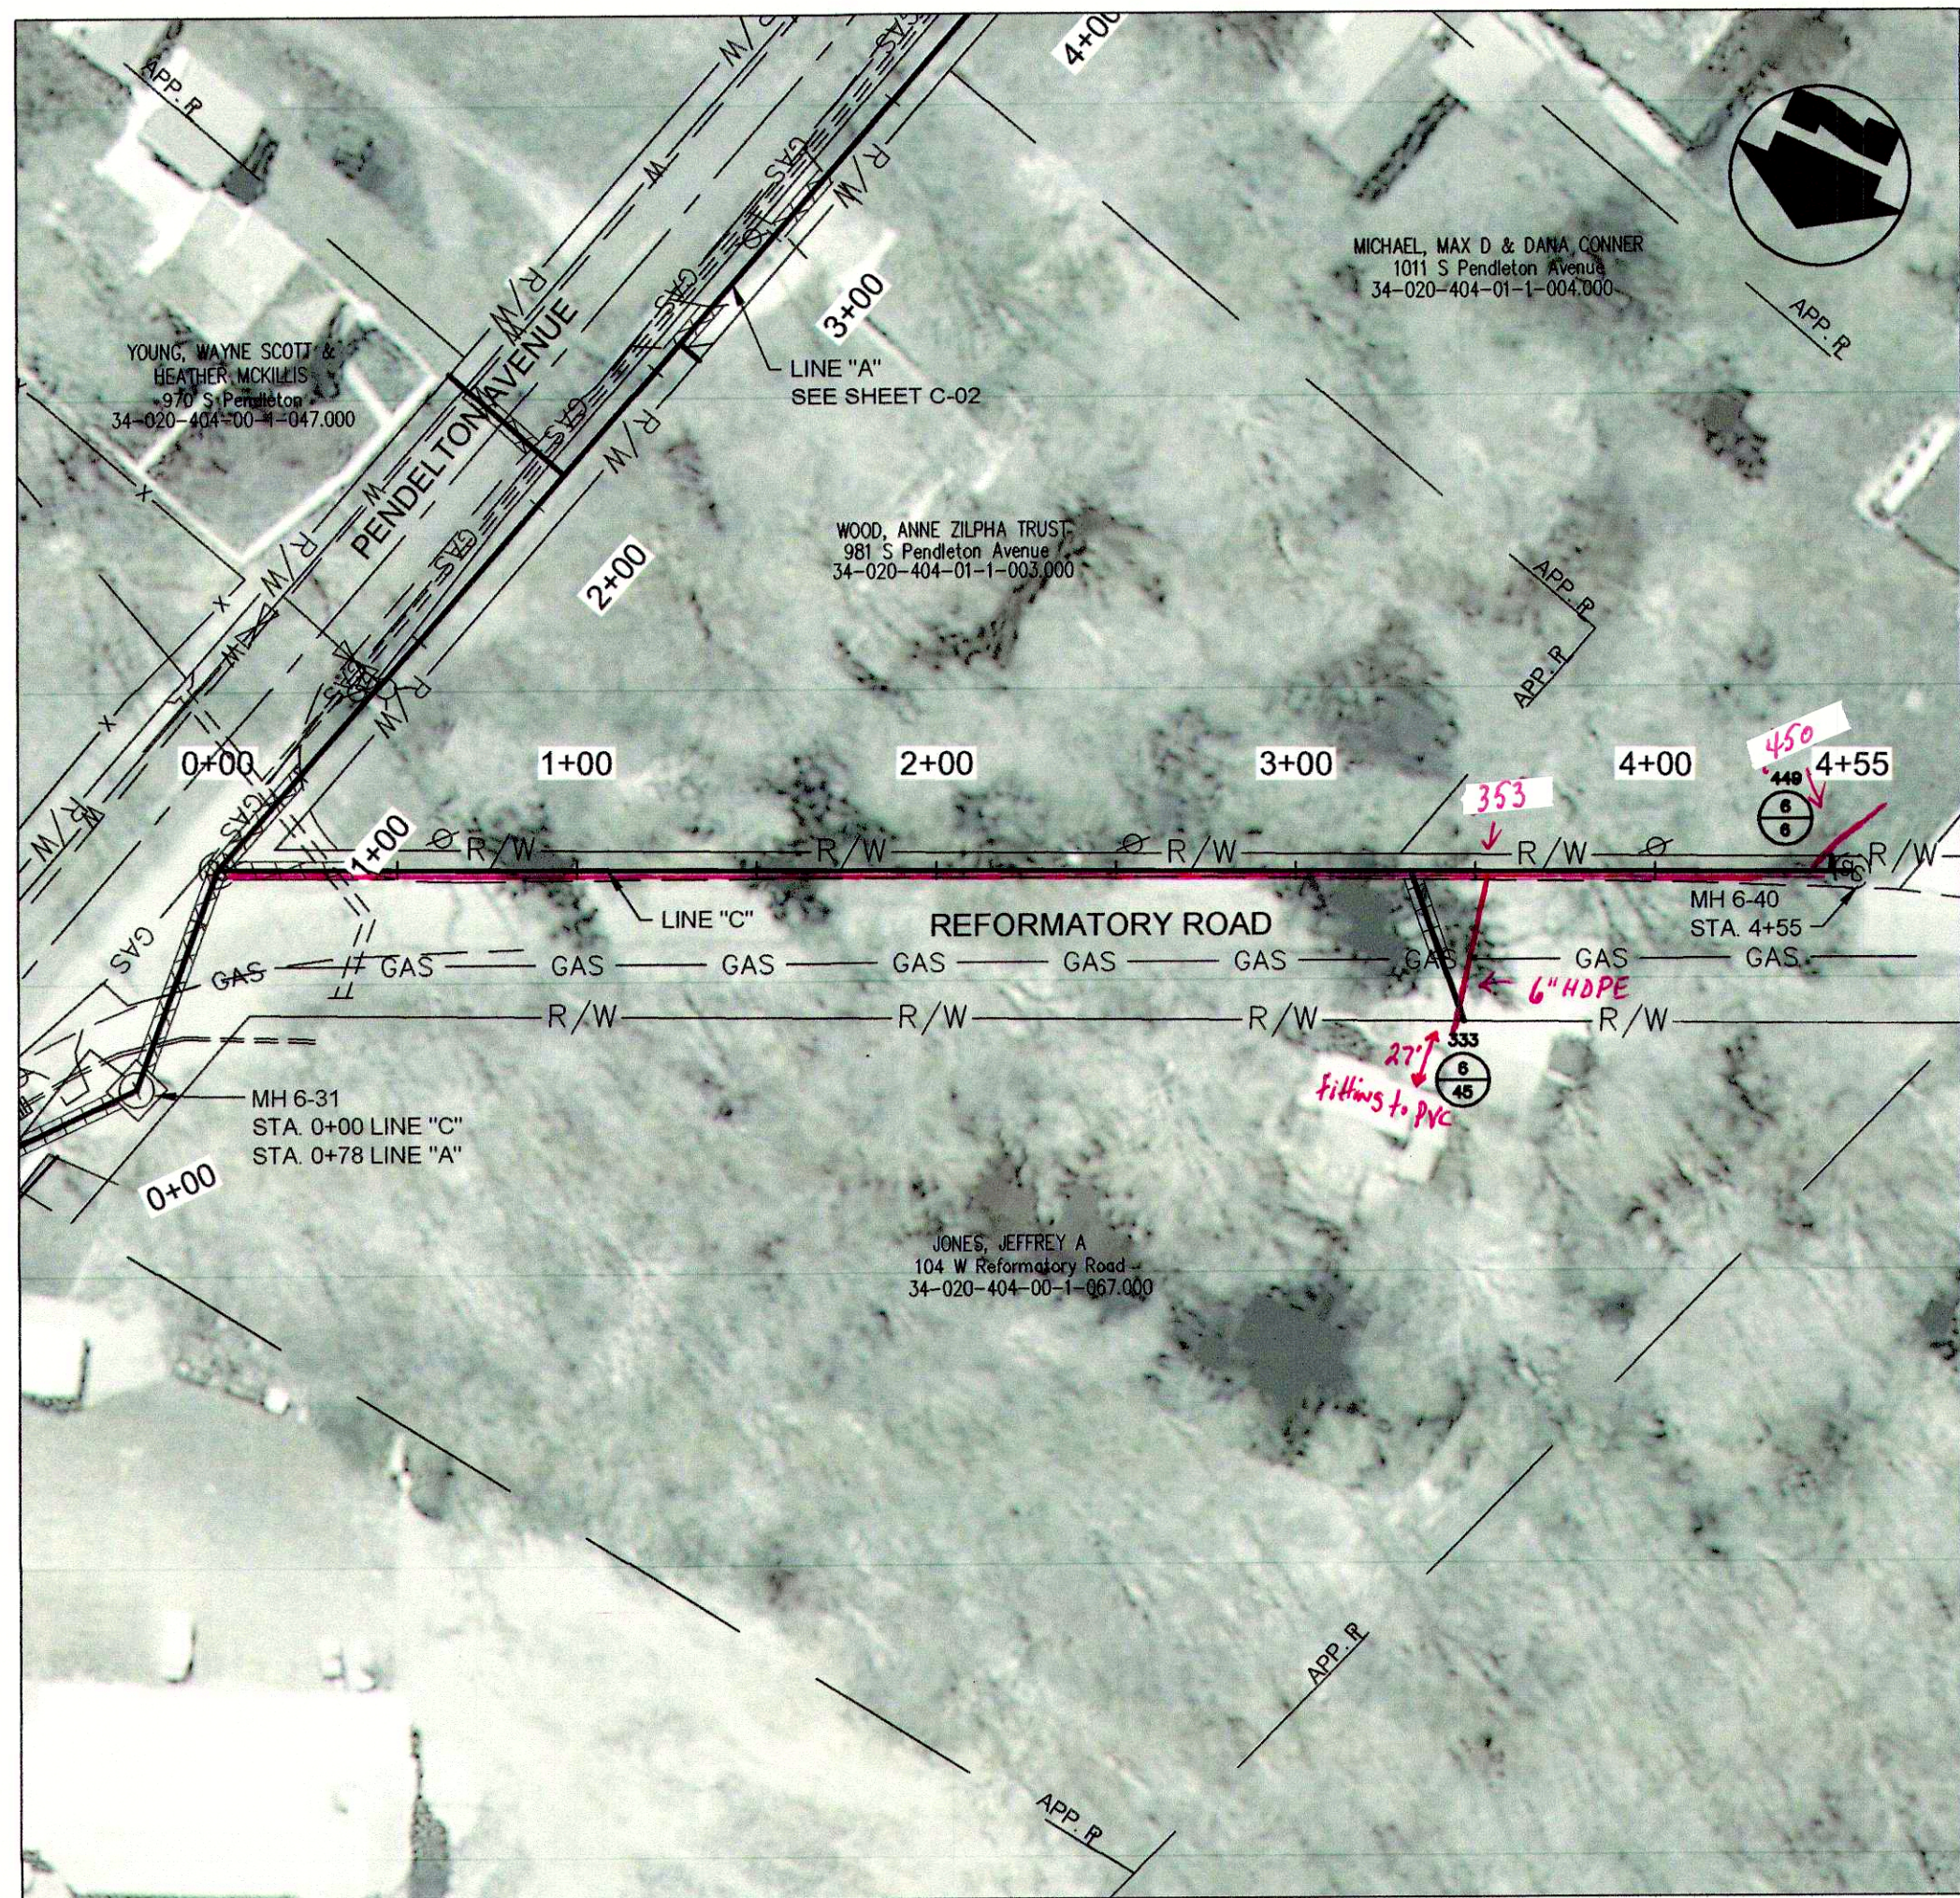


PLAN VIEW - STA. 0+00 TO STA. 4+55 LINE "C"

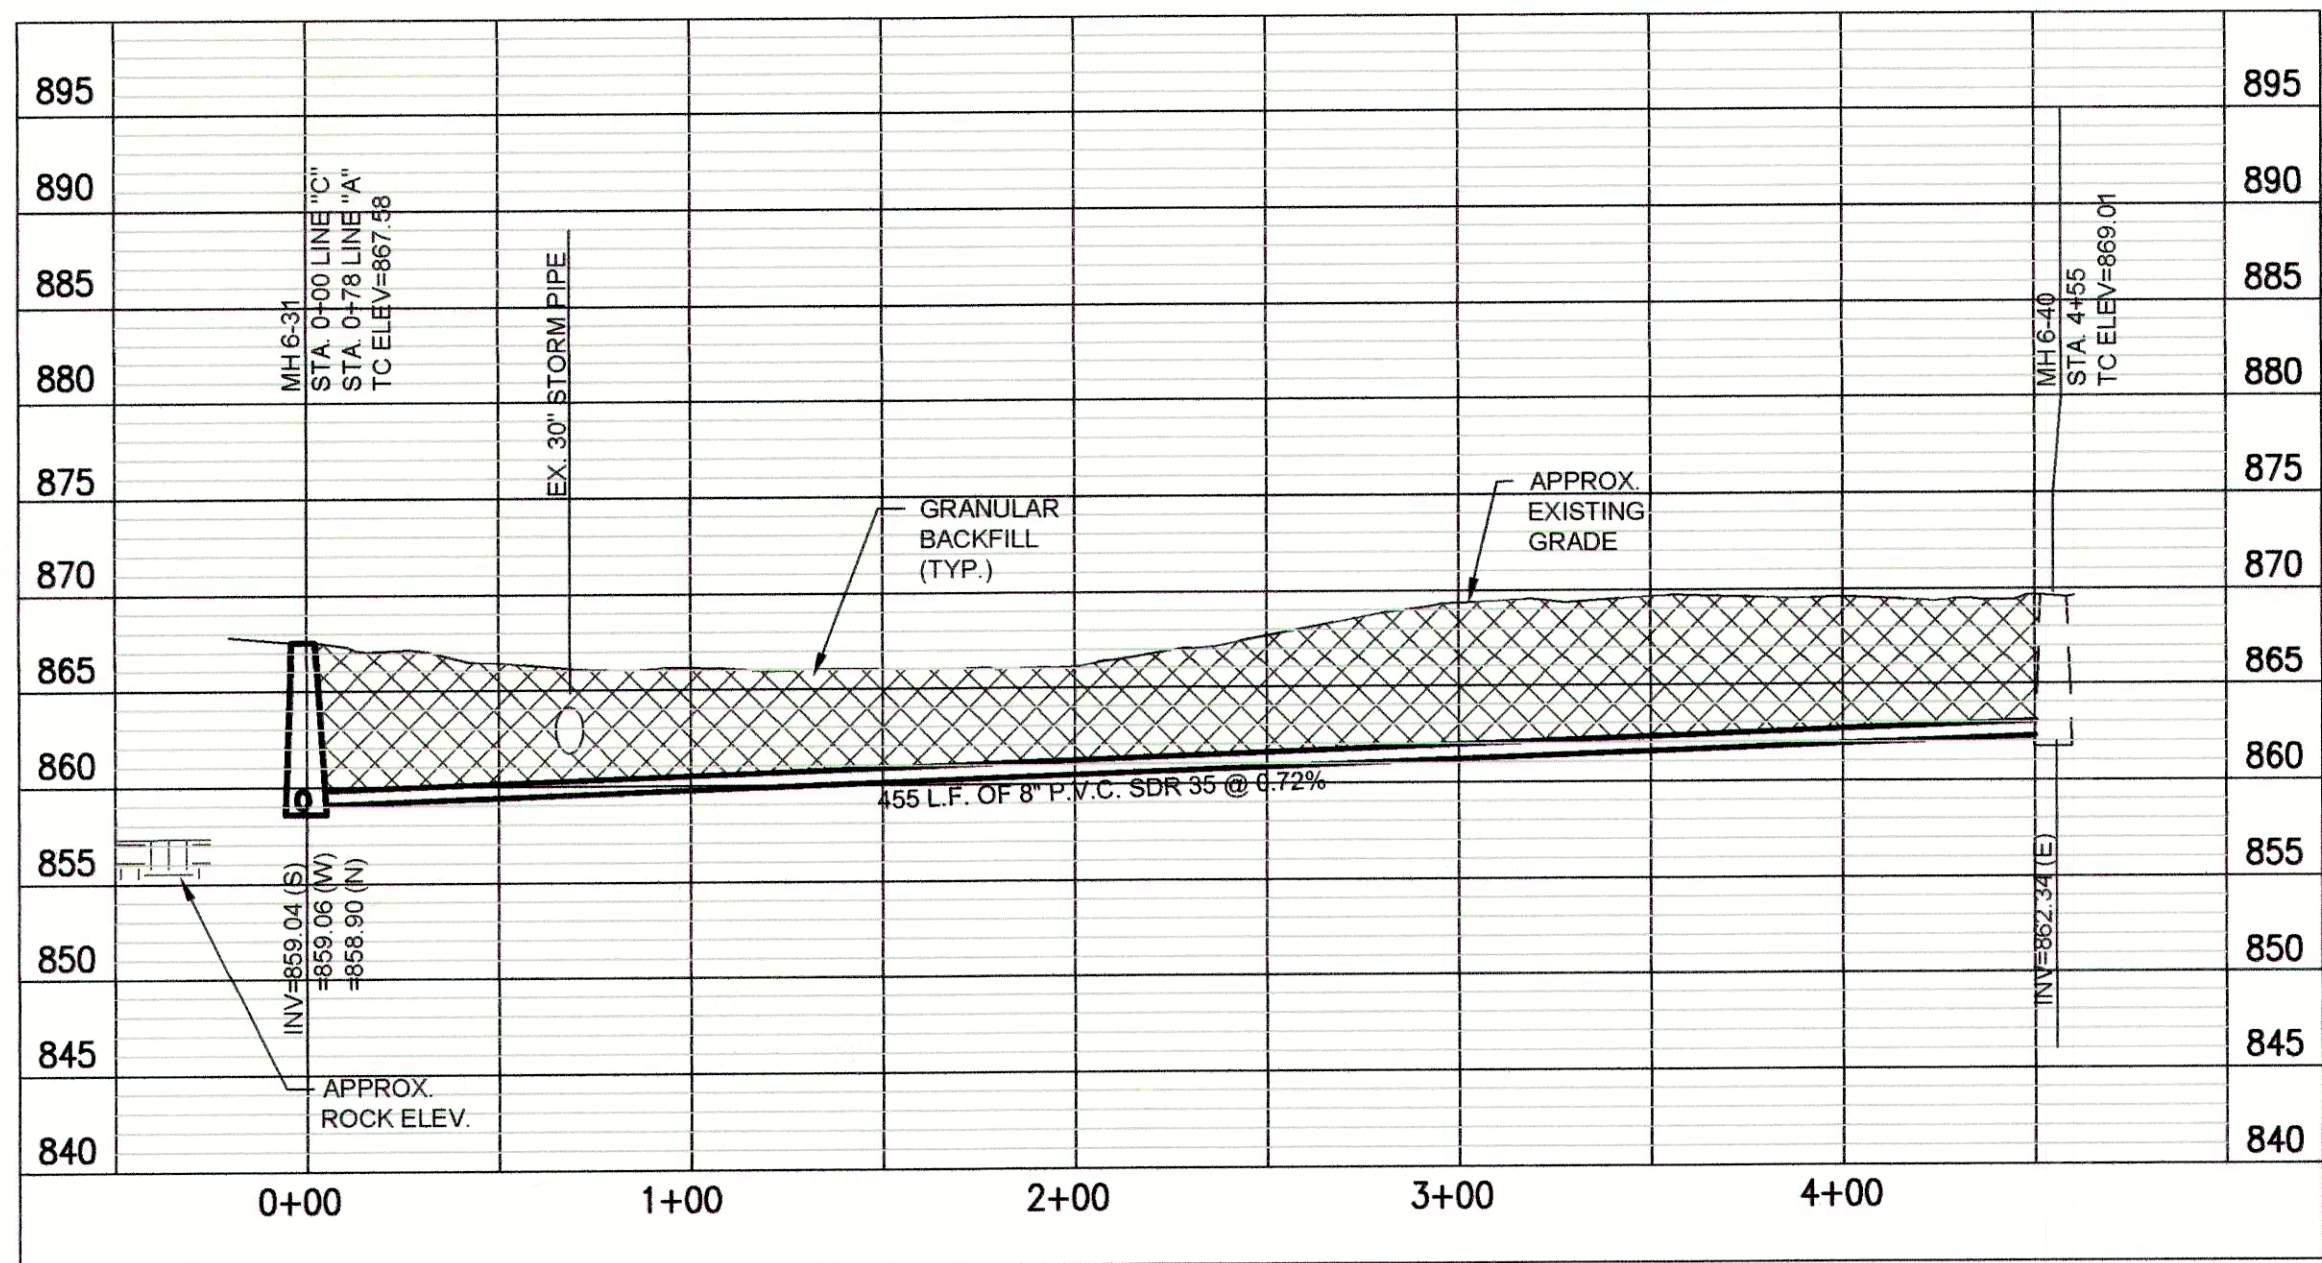


PROFILE - STA. 0+00 TO STA. 4+55 LINE "C"

"BID SCHEDULE A" (OPEN CUT) NOTES:

1. LATERAL LOCATIONS SHOWN ARE BASED ON BEST AVAILABLE INFORMATION. CONTRACTOR TO FIELD VERIFY ALL EXISTING SANITARY LATERAL LOCATIONS AND DEPTHS, INSTALL 6" SDR 35 SEWER PIPE TO R/W LINE AND CONNECT TO EXISTING LATERAL.
2. THE EXISTING MANHOLES ARE TO REMAIN IN PLACE WITH NEW SEWERS RECONNECTED. THE MANHOLES SHALL BE REHABILITATED PER THE MANHOLE REHABILITATION SCHEDULE.

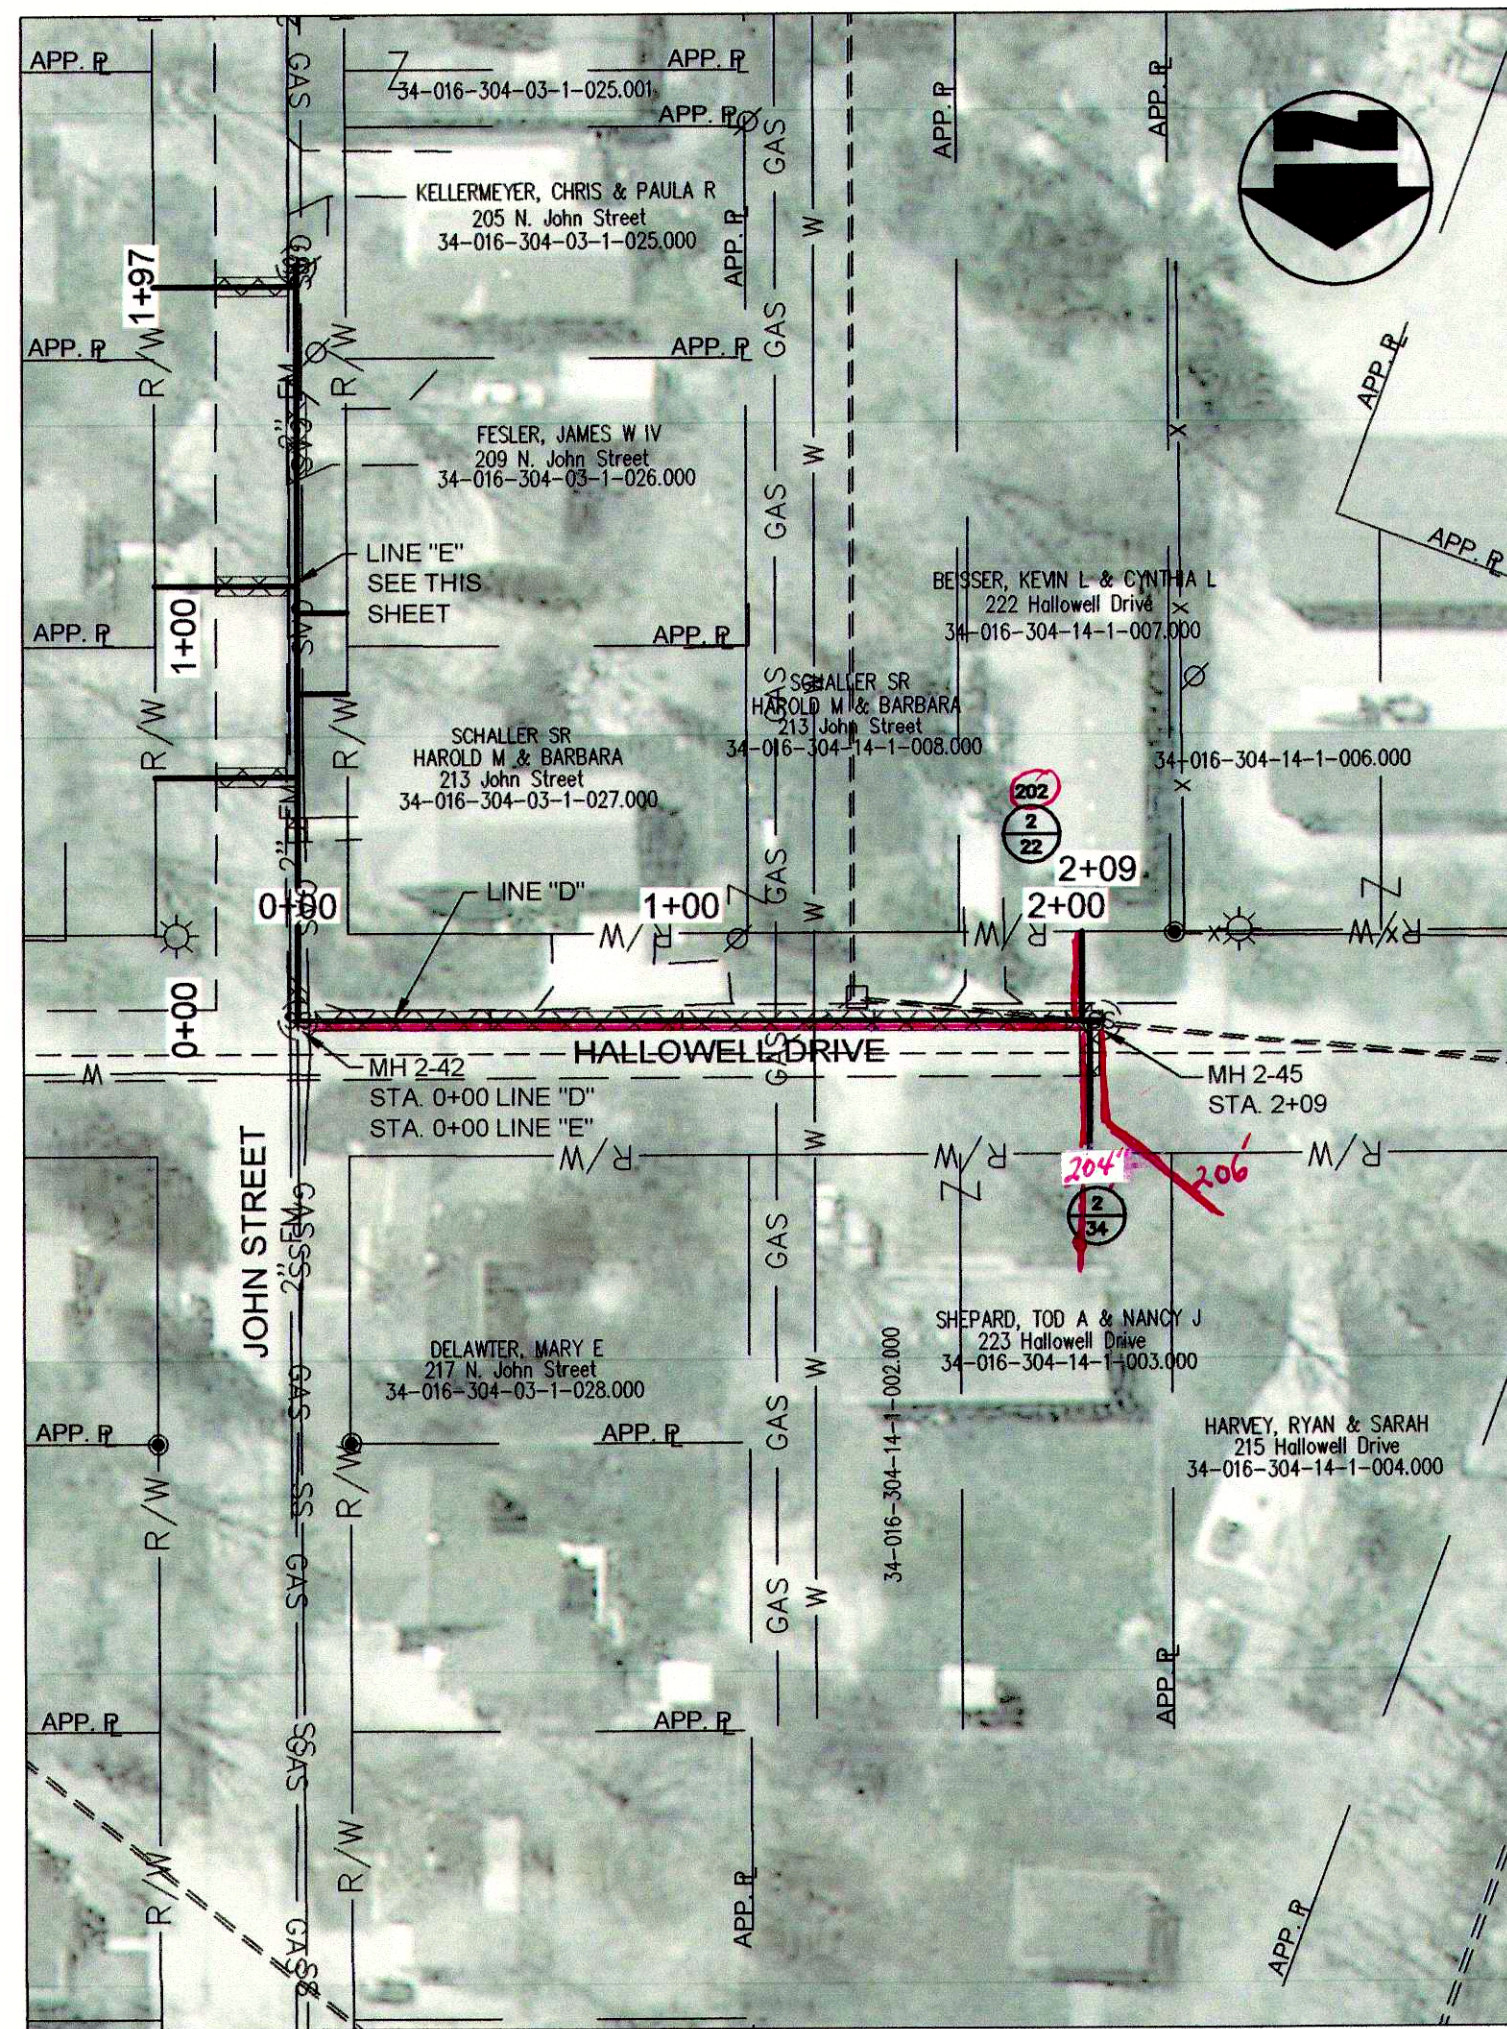


PLAN VIEW - STA. 0+00 TO STA. 2+09 LINE "D"

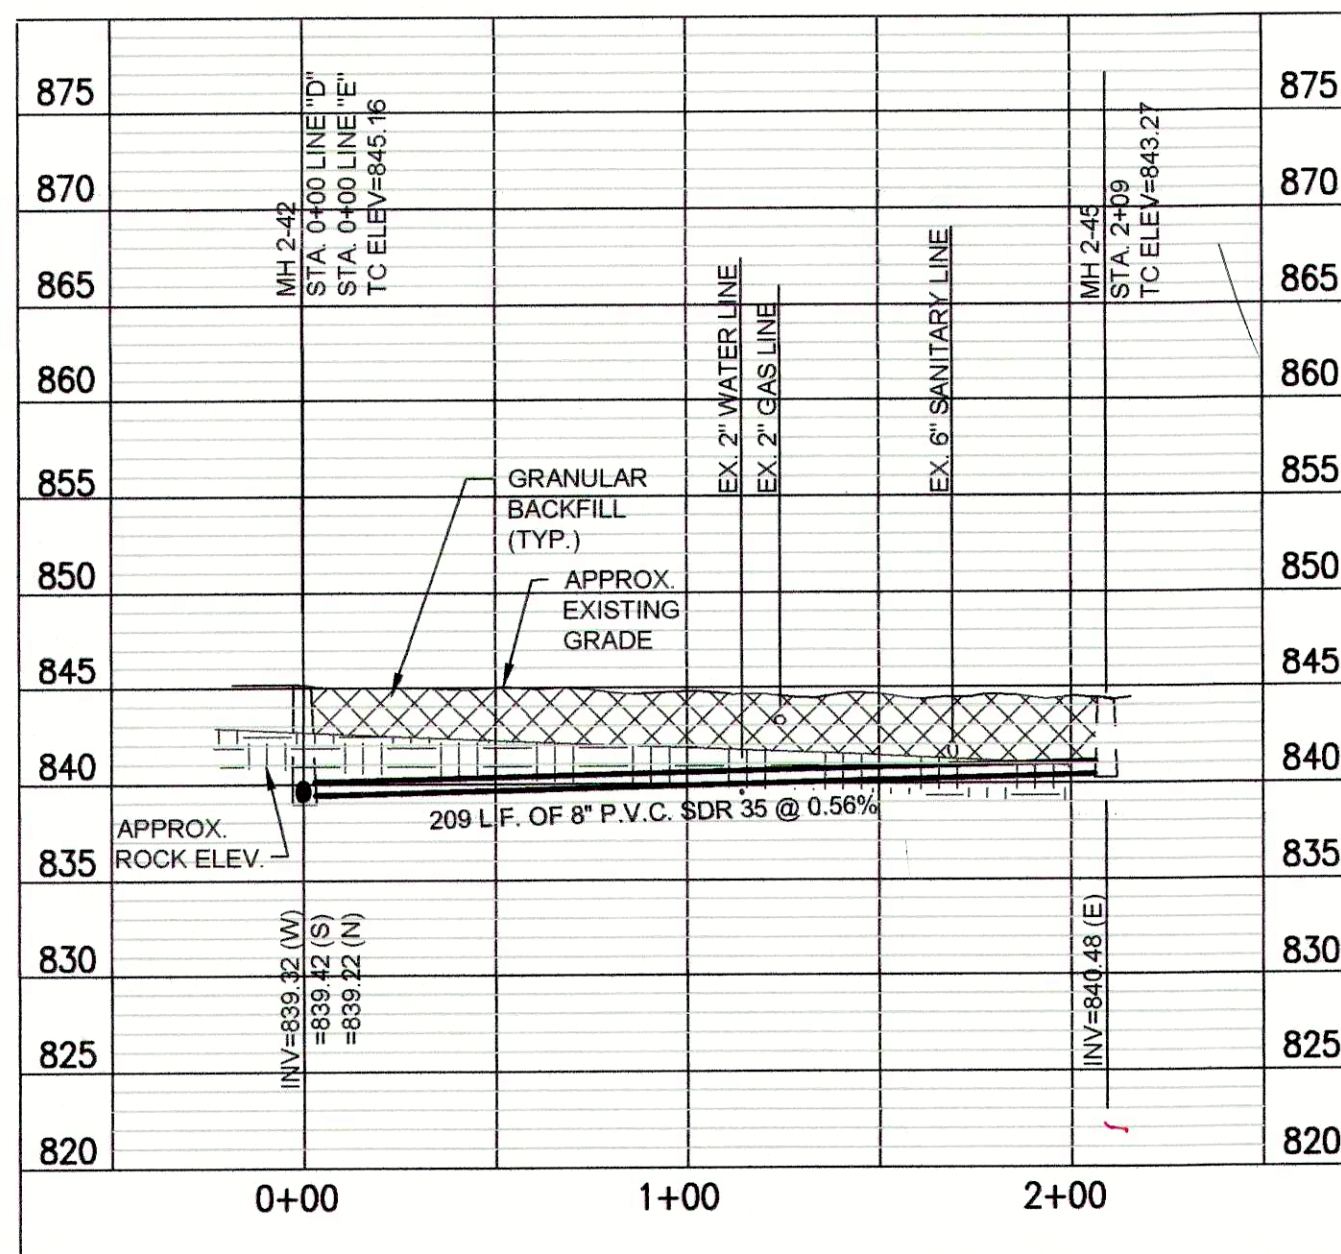


PROFILE - STA. 0+00 TO STA. 2+09 LINE "D"

BID SCHEDULES A & B NOTES:

 
1. SANITARY LATERAL LEGEND:



A= DISTANCE FROM DOWN STREAM MANHOLE
X= APPROX. DEPTH AT R/W
Y= LENGTH FROM MAIN TO R/W

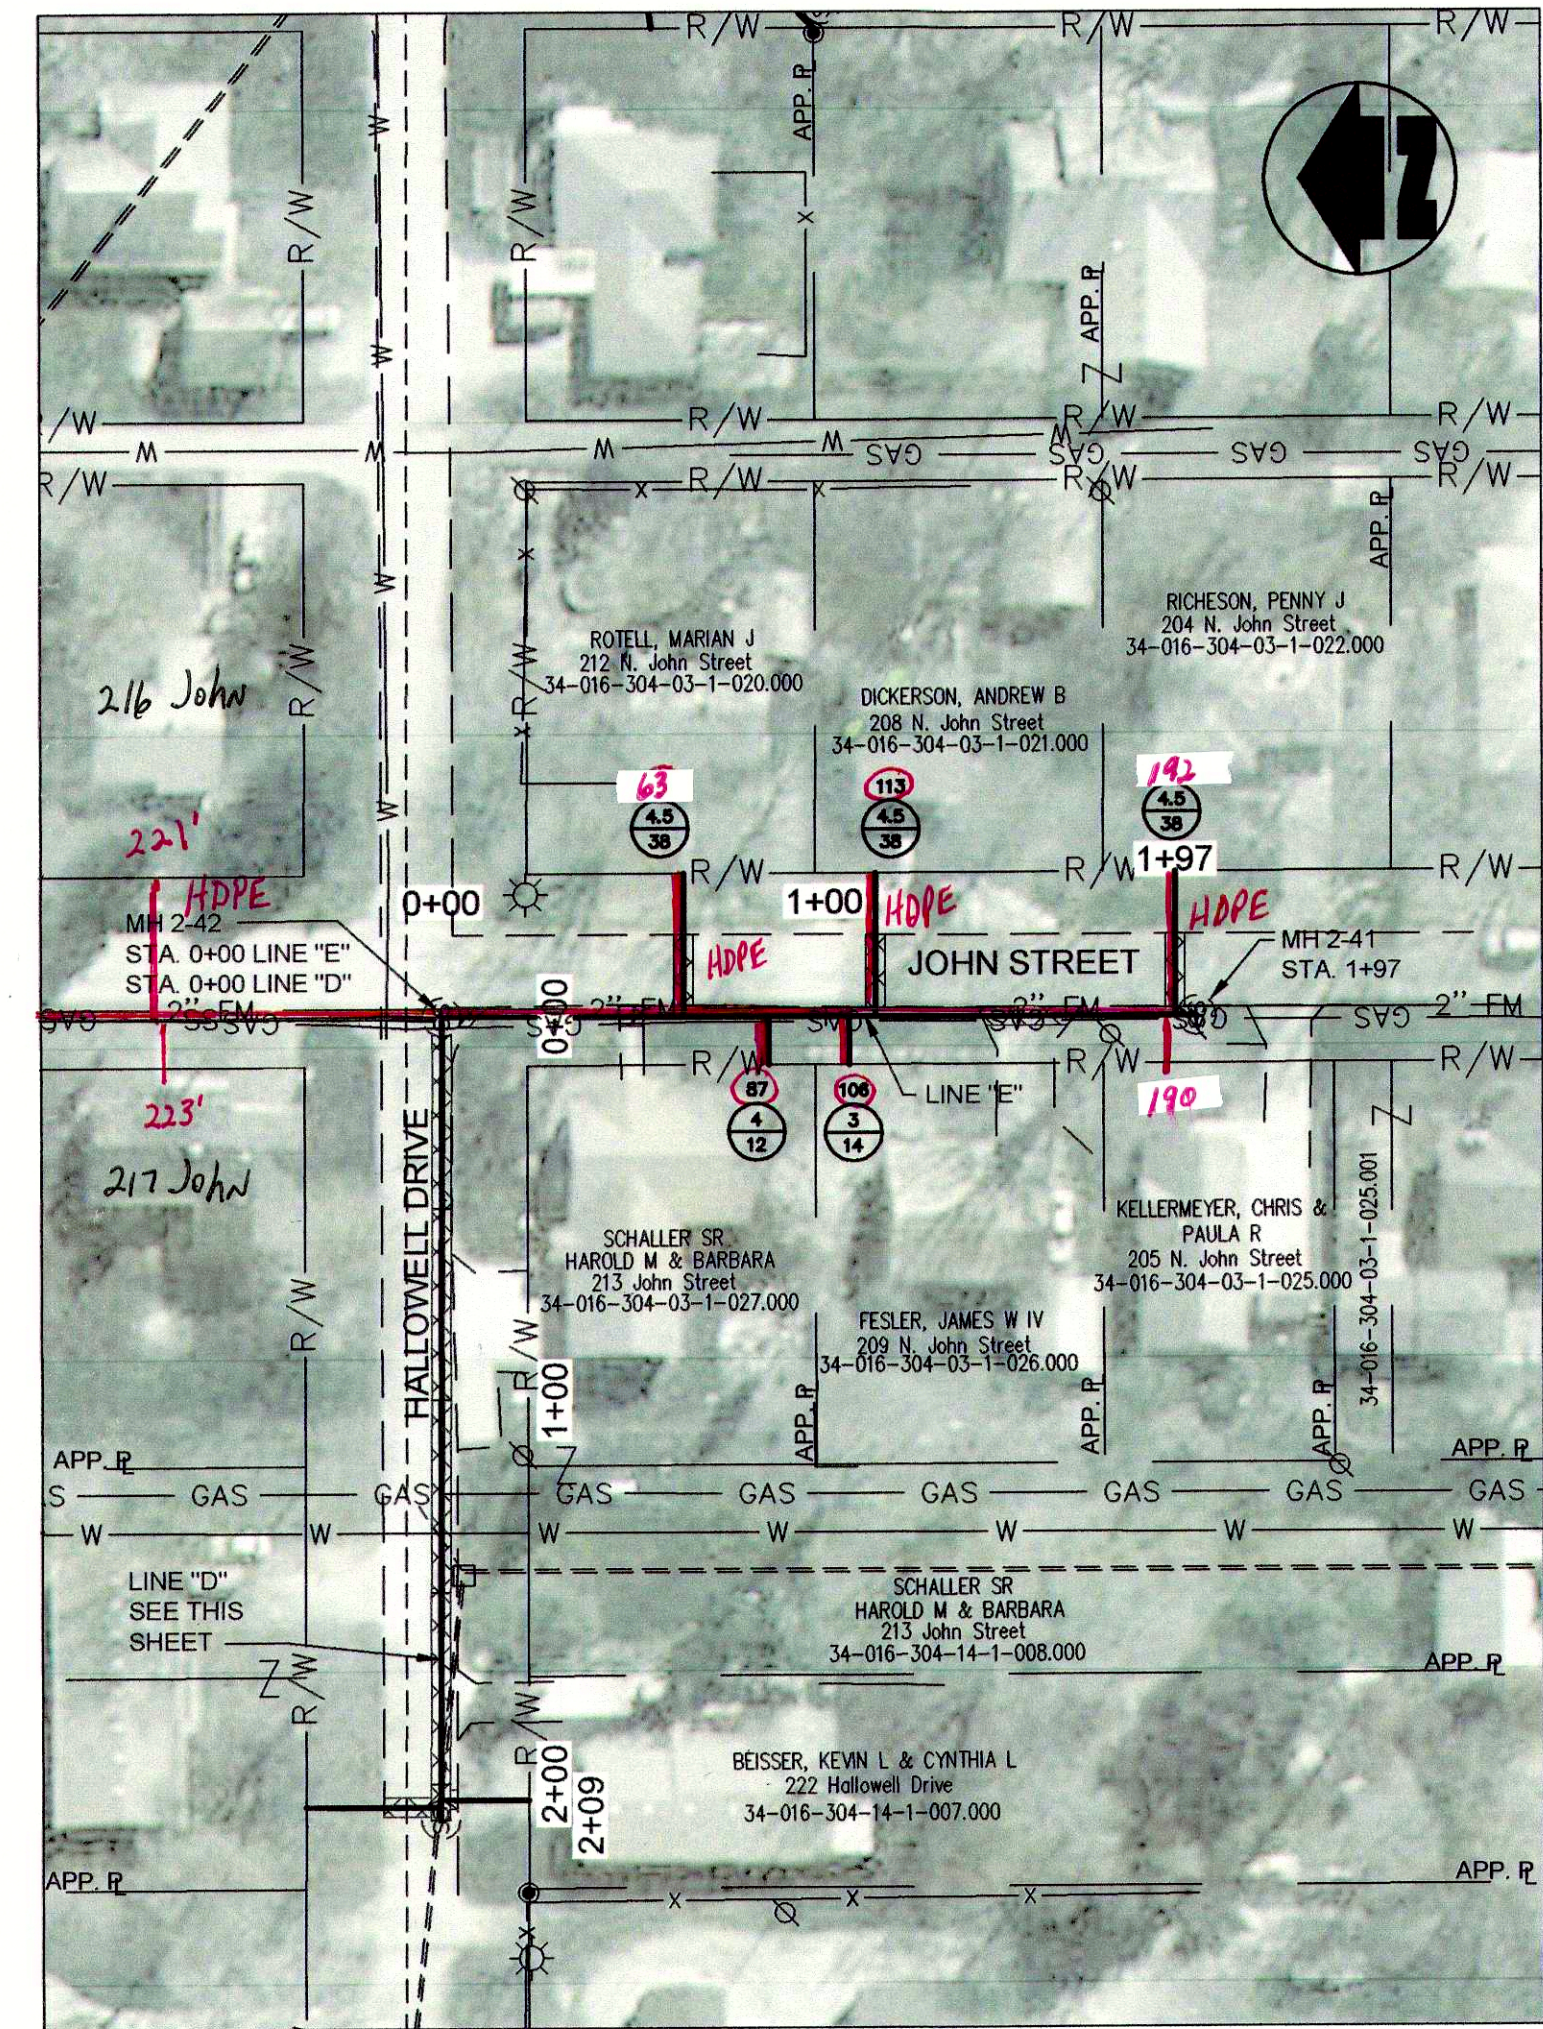

PLAN VIEW - STA. 0+00 TO STA. 1+97 LINE "E"

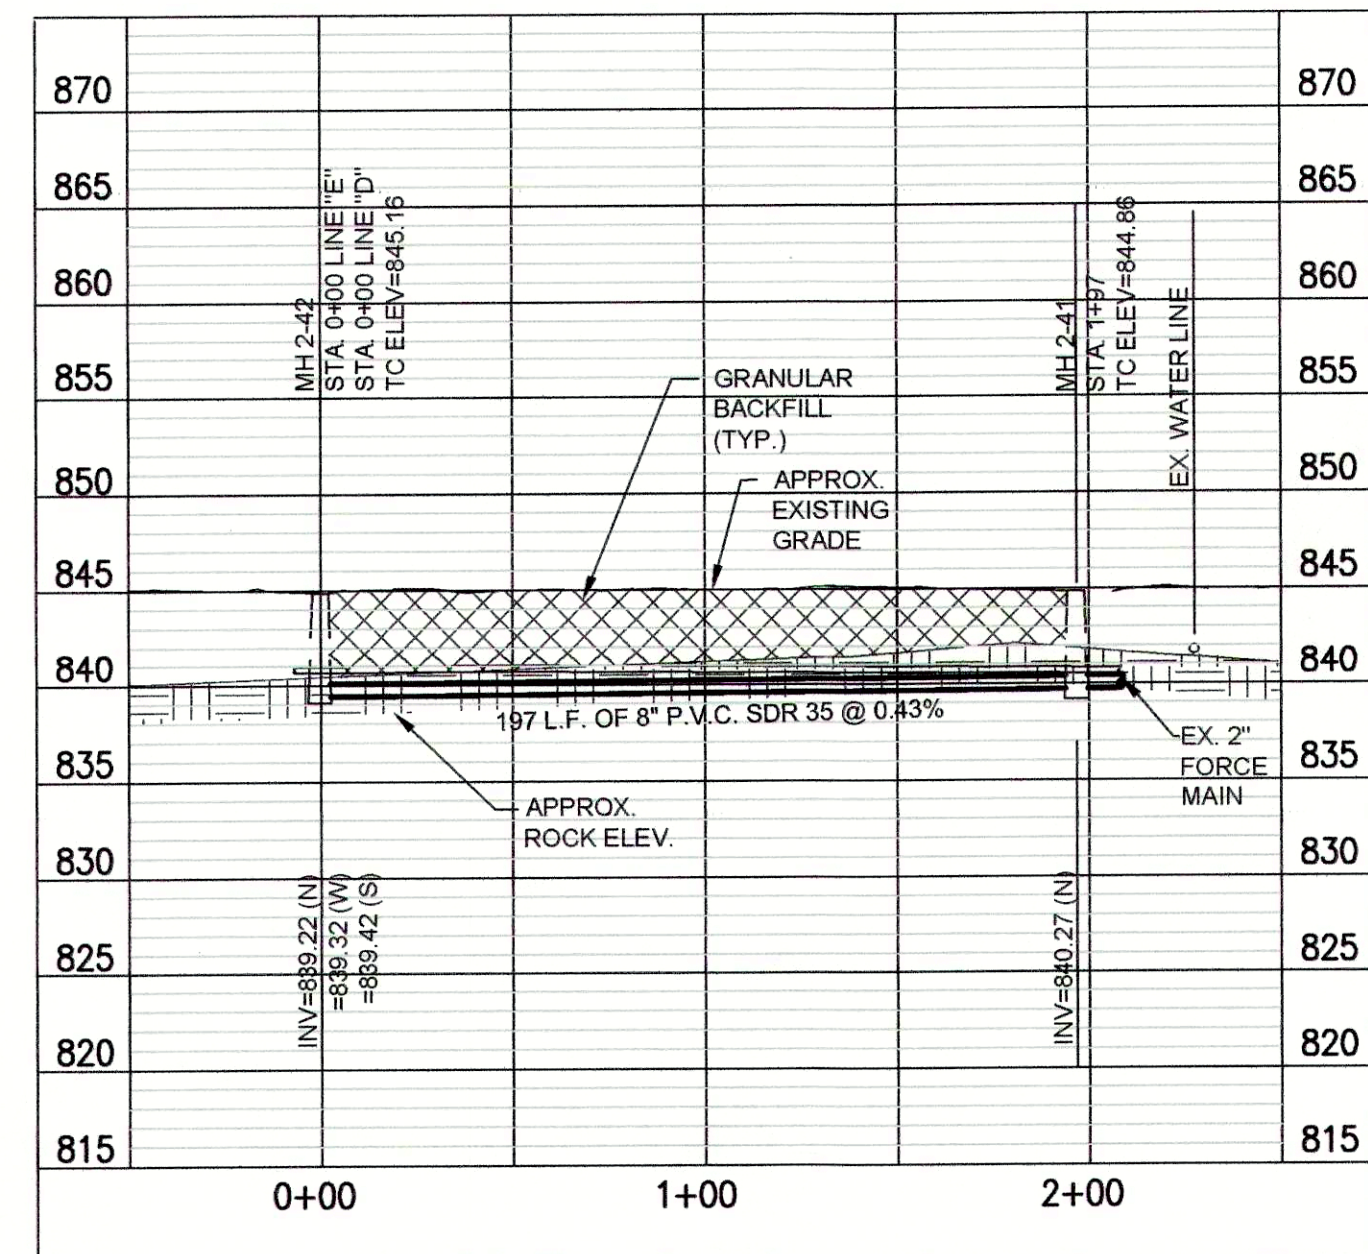

PROFILE - STA. 0+00 TO STA. 1+97 LINE "E"

"BID SCHEDULE B" (CIPP) NOTES:


1. LATERAL LOCATIONS SHOWN ARE BASED ON BEST AVAILABLE INFORMATION. CONTRACTOR TO FIELD VERIFY EXISTING SANITARY LATERAL LOCATIONS AND DEPTHS, FOR LATERAL REPLACEMENTS, MAKE CONNECTION DIRECTLY TO CIPP LINER AS SHOWN IN THE DETAILS AND ON SHEET C-16. INSTALL 6" SDR 35 SEWER PIPE FROM MAIN TO R/W LINE AND CONNECT TO EXISTING LATERAL.
2. IF THE PLANS SHOW C.I.P. LATERAL REHABILITATION, COMPLETE PER THE DETAIL ON SHEET C-16.
3. MANHOLE SHALL BE REHABILITATION PER THE MANHOLE REHABILITATION SCHEDULE.

REVISIONS	DESCRIPTION	DATE	BY	GWL	GCR	JPT	JPT

DATE: APRIL 2016

SCALE: H: 1"=50' V: 1"=10'

SHEET NO. C-04

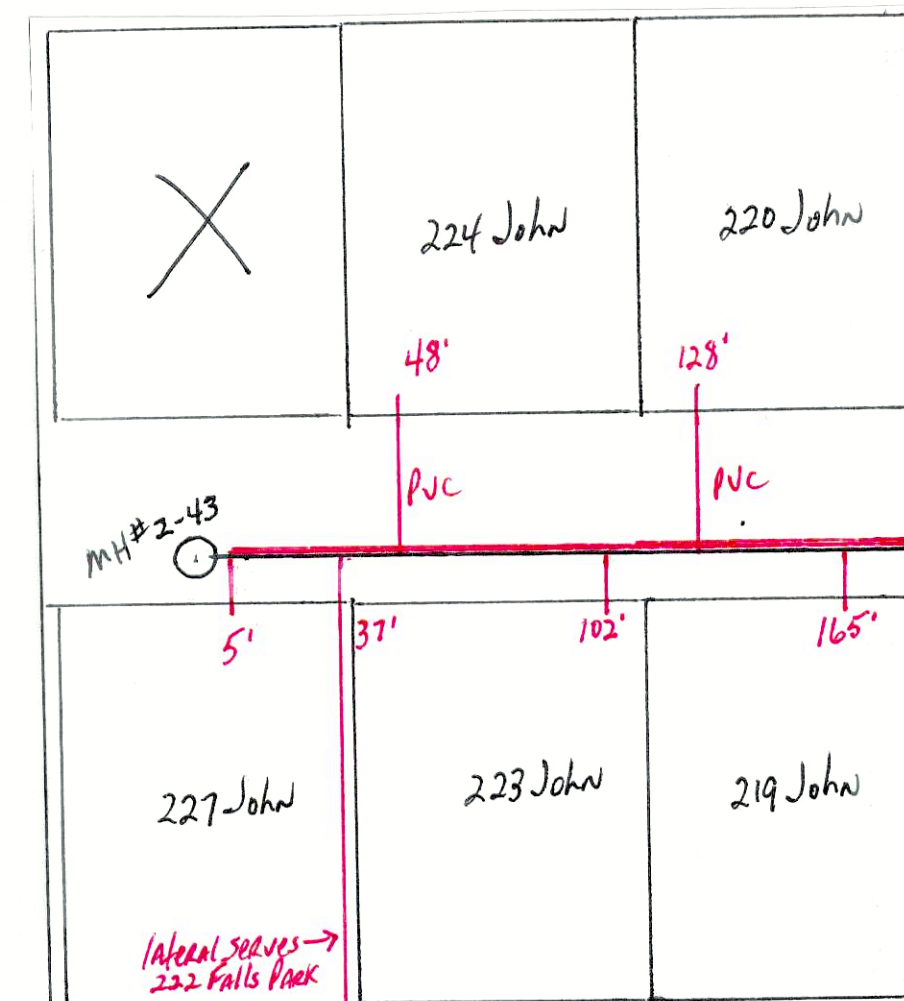[illegible]

DESIGNED:	GWL
DRAWN:	GCR
REVIEWED:	JPT
APPROVED:	JPT


**PLAN & PROFILE ADDITIONAL AREA
SANITARY SEWER REHABILITATION
FALL CREEK REGIONAL WASTE DISTRICT
PENDLETON, INDIANA**




GRW PROJECT NO. 4447-14


SRF NO. WW16074803 ----

ALL RIGHTS RESERVED.
THIS DOCUMENT IS THE PROPERTY OF
GRW ENGINEERS, INC. AND SHALL NOT
BE REPRODUCED IN WHOLE OR IN PART
OR USED FOR CONSTRUCTION OF
OTHER THAN THIS SPECIFIC PROJECT
WITHOUT WRITTEN PERMISSION

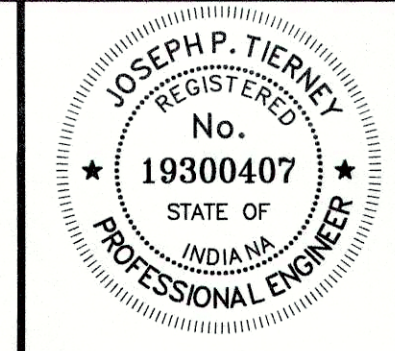

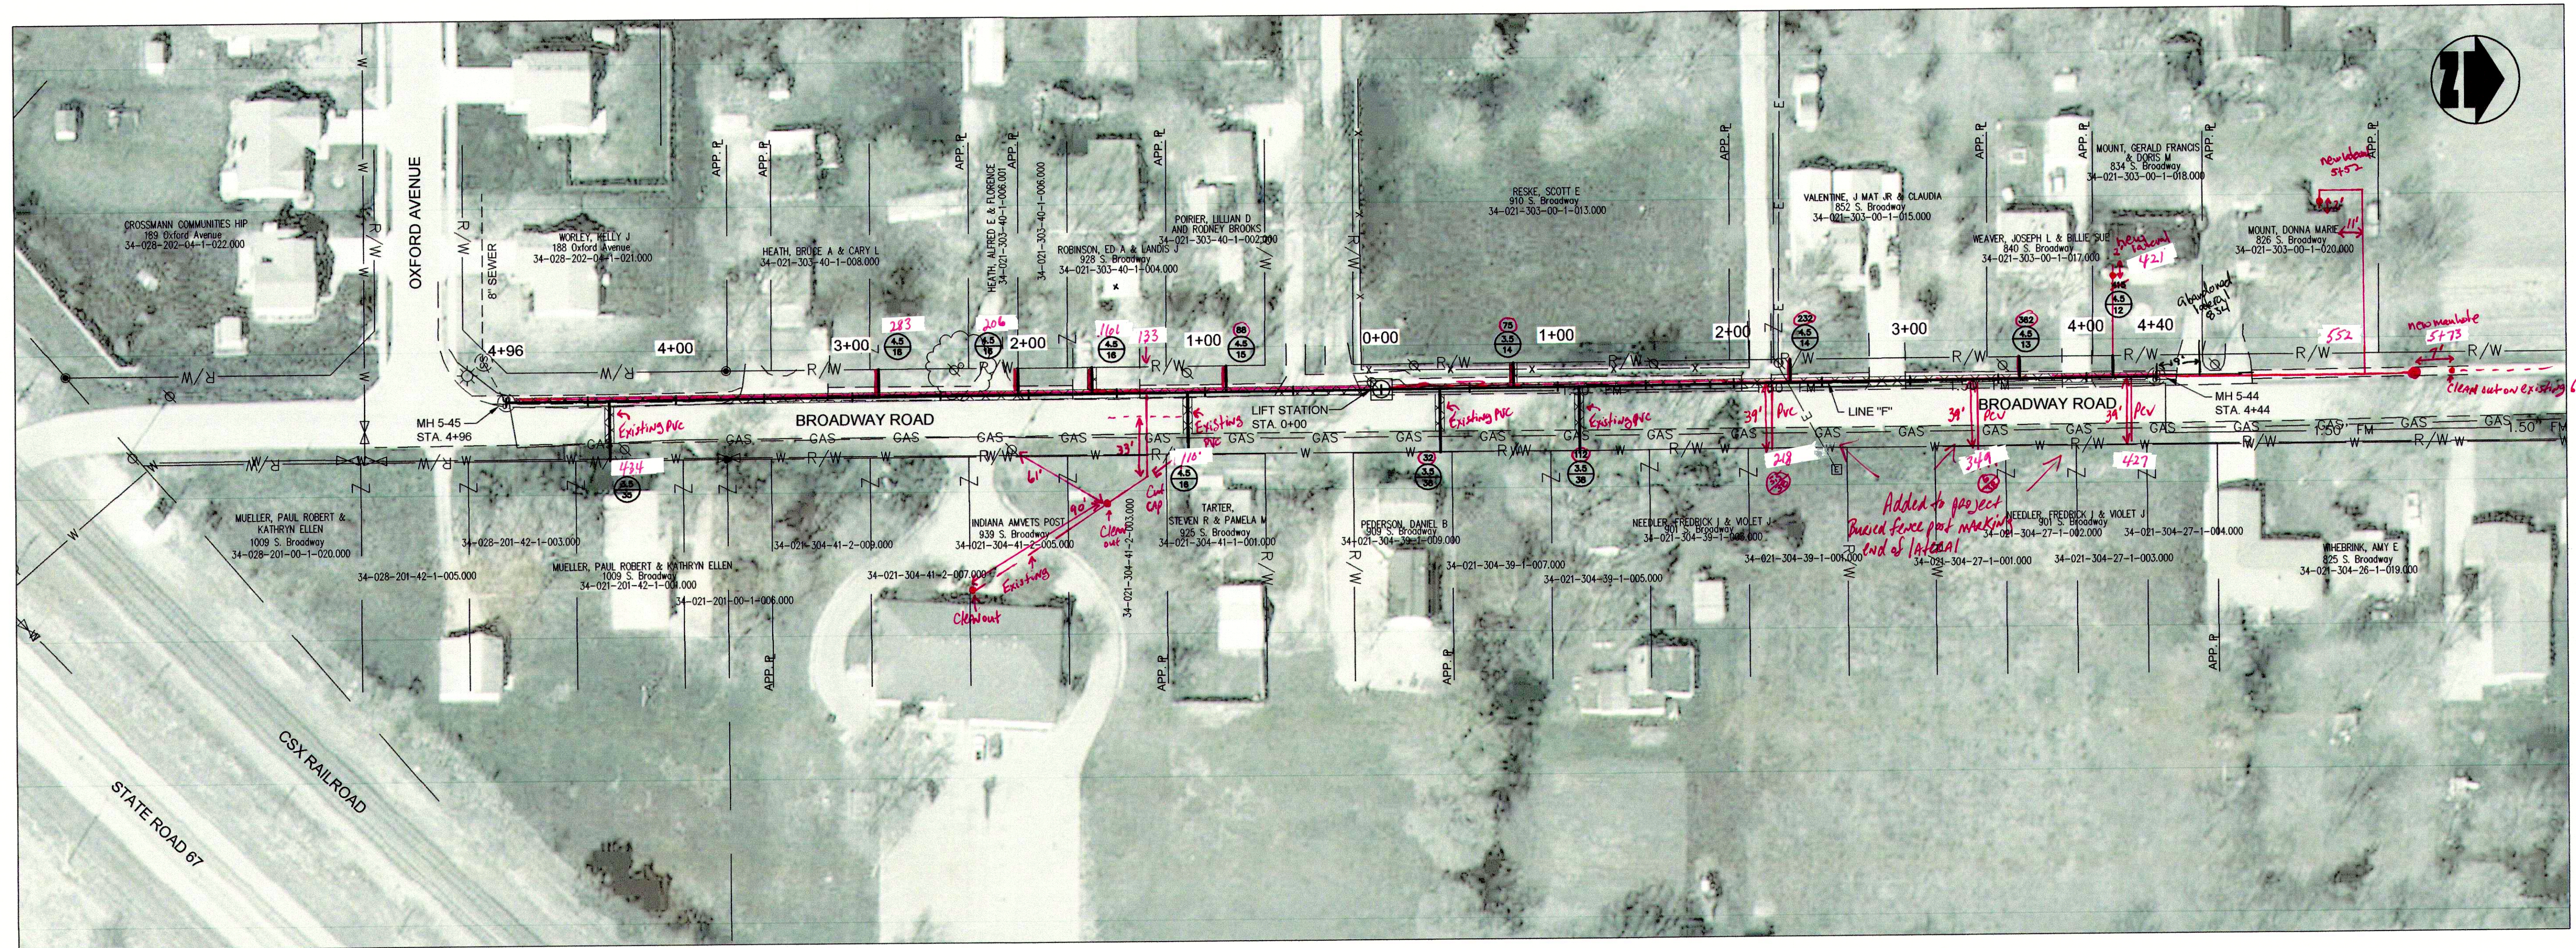

PLAN VIEW - STA. 4+96 TO STA. 4+40 LINE "F"

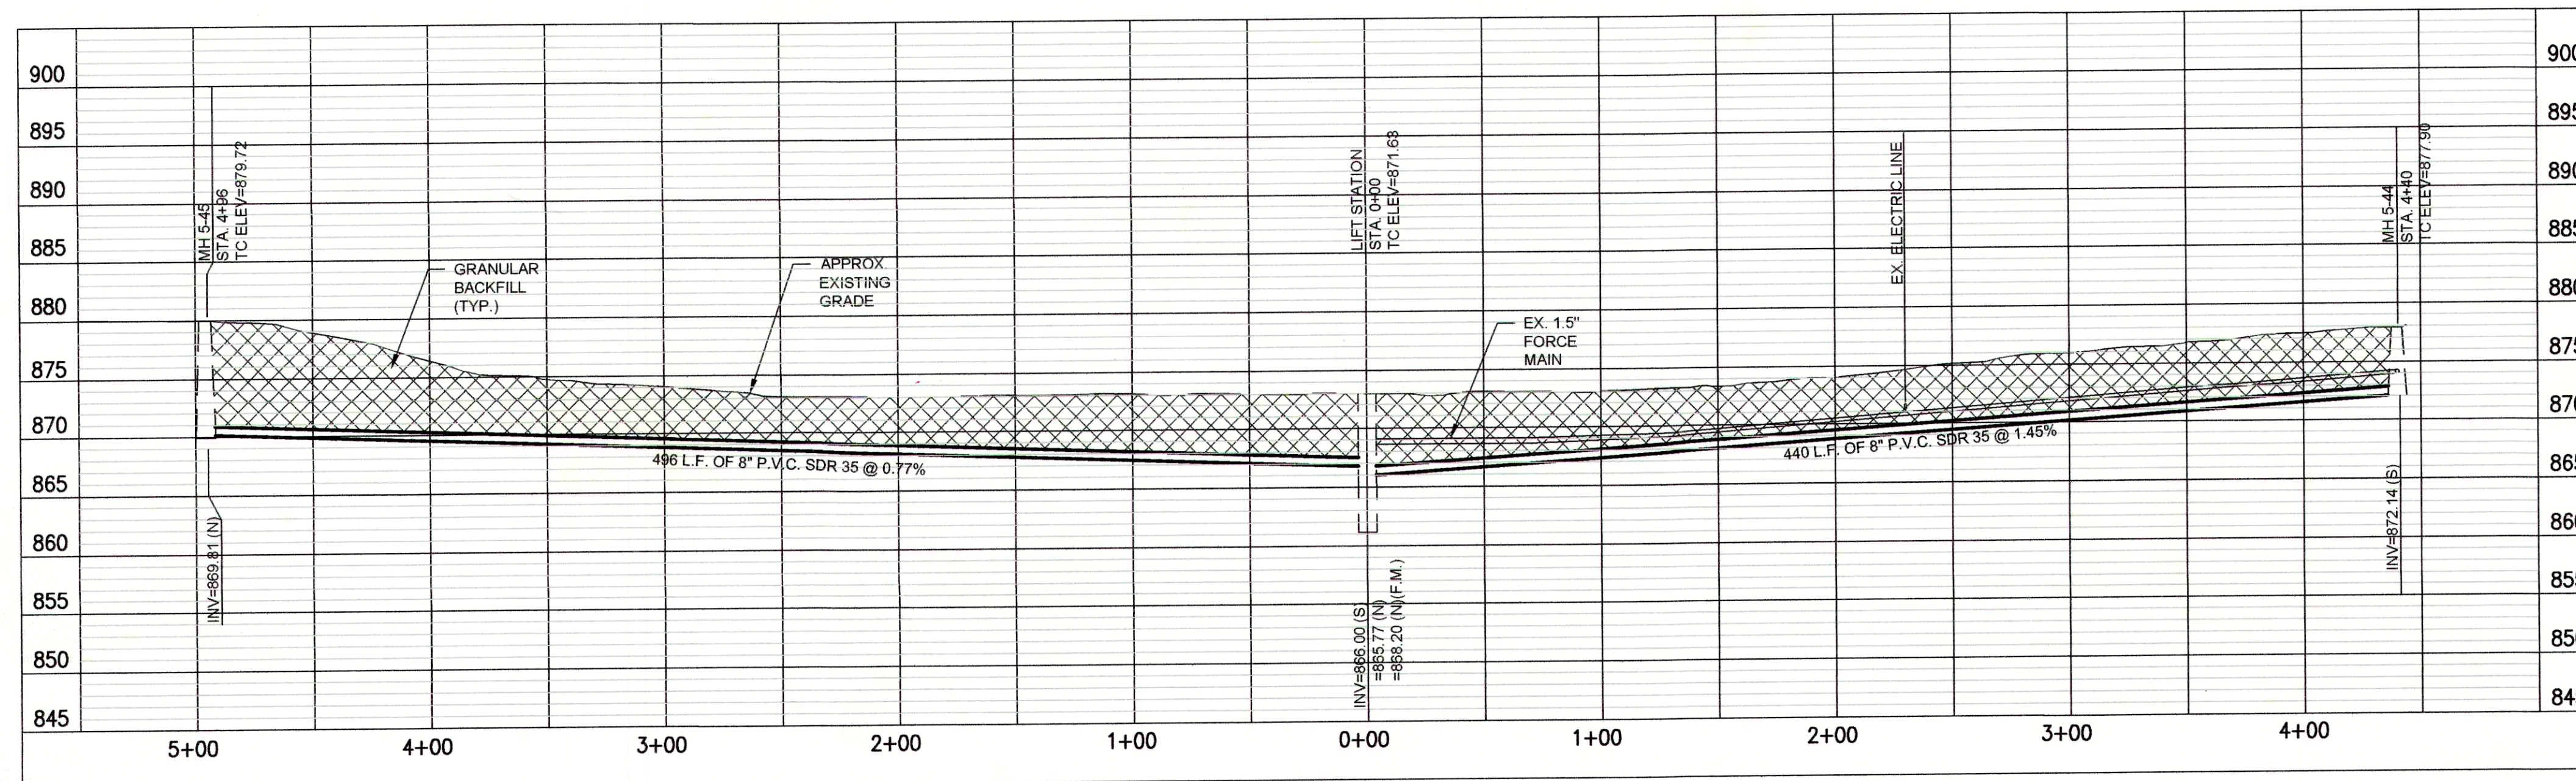


PROFILE - STA. 4+96 TO 4+40 LINE "F"

"BID SCHEDULE A" (OPEN CUT) NOTES:

1. LATERAL LOCATIONS SHOWN ARE BASED ON BEST AVAILABLE INFORMATION. CONTRACTOR TO FIELD VERIFY ALL EXISTING SANITARY LATERAL LOCATIONS AND DEPTHS, INSTALL 6" SDR 35 SEWER PIPE TO R/W LINE AND CONNECT TO EXISTING LATERAL.
2. THE EXISTING MANHOLES ARE TO REMAIN IN PLACE WITH NEW SEWERS RECONNECTED. THE MANHOLES SHALL BE REHABILITATED PER THE MANHOLE REHABILITATION SCHEDULE.

BID SCHEDULES A & B NOTES:

1. SANITARY LATERAL LEGEND:

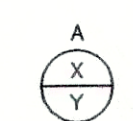

A= DISTANCE FROM DOWN STREAM MANHOLE
X= APPROX. DEPTH AT R/W
Y= LENGTH FROM MAIN TO R/W

"BID SCHEDULE B" (CIPP) NOTES:

1. LATERAL LOCATIONS SHOWN ARE BASED ON BEST AVAILABLE INFORMATION. CONTRACTOR TO FIELD VERIFY EXISTING SANITARY LATERAL LOCATIONS AND DEPTHS. FOR LATERAL REPLACEMENTS, MAKE CONNECTION DIRECTLY TO CIPP LINER AS SHOWN IN THE DETAILS AND ON SHEET C-16. INSTALL 6" SDR 35 SEWER PIPE FROM MAIN TO R/W LINE AND CONNECT TO EXISTING LATERAL.
2. IF THE PLANS SHOW C.I.P.P. LATERAL REHABILITATION, COMPLETE PER THE DETAIL ON SHEET C-16.
3. MANHOLE SHALL BE REHABILITATION PER THE MANHOLE REHABILITATION SCHEDULE.

270
120
390
46
430
190
560
1,0691

JOSEPH P. TIERNEY
REGISTERED
No.
19300407
STATE OF
INDIANA
PROFESSIONAL ENGINEER

BID SET

GRW PROJECT NO. 4447-14

SFV NO. WW16074803

GR3

engineering | architecture | geospatial

www.grwinc.com

ALL RIGHTS RESERVED
THIS DRAWING IS THE PROPERTY OF
GRW ENGINEERS, INC. AND SHALL NOT
BE REPRODUCED OR USED FOR CONSTRUCTION OF
ANY PROJECT WITHOUT WRITTEN PERMISSION.

PLAN & PROFILE

SANITARY SEWER REHABILITATION

FALL CREEK REGIONAL WASTE DISTRICT


PENDLETON, INDIANA

DESIGNED		GWL		GCR		JPT	
NO.	DATE	BY	DATE	BY	DATE	BY	DATE


DATE: APRIL 2016

SCALE: H: 1"=50' V: 1"=10'

SHEET NO. **C-05**

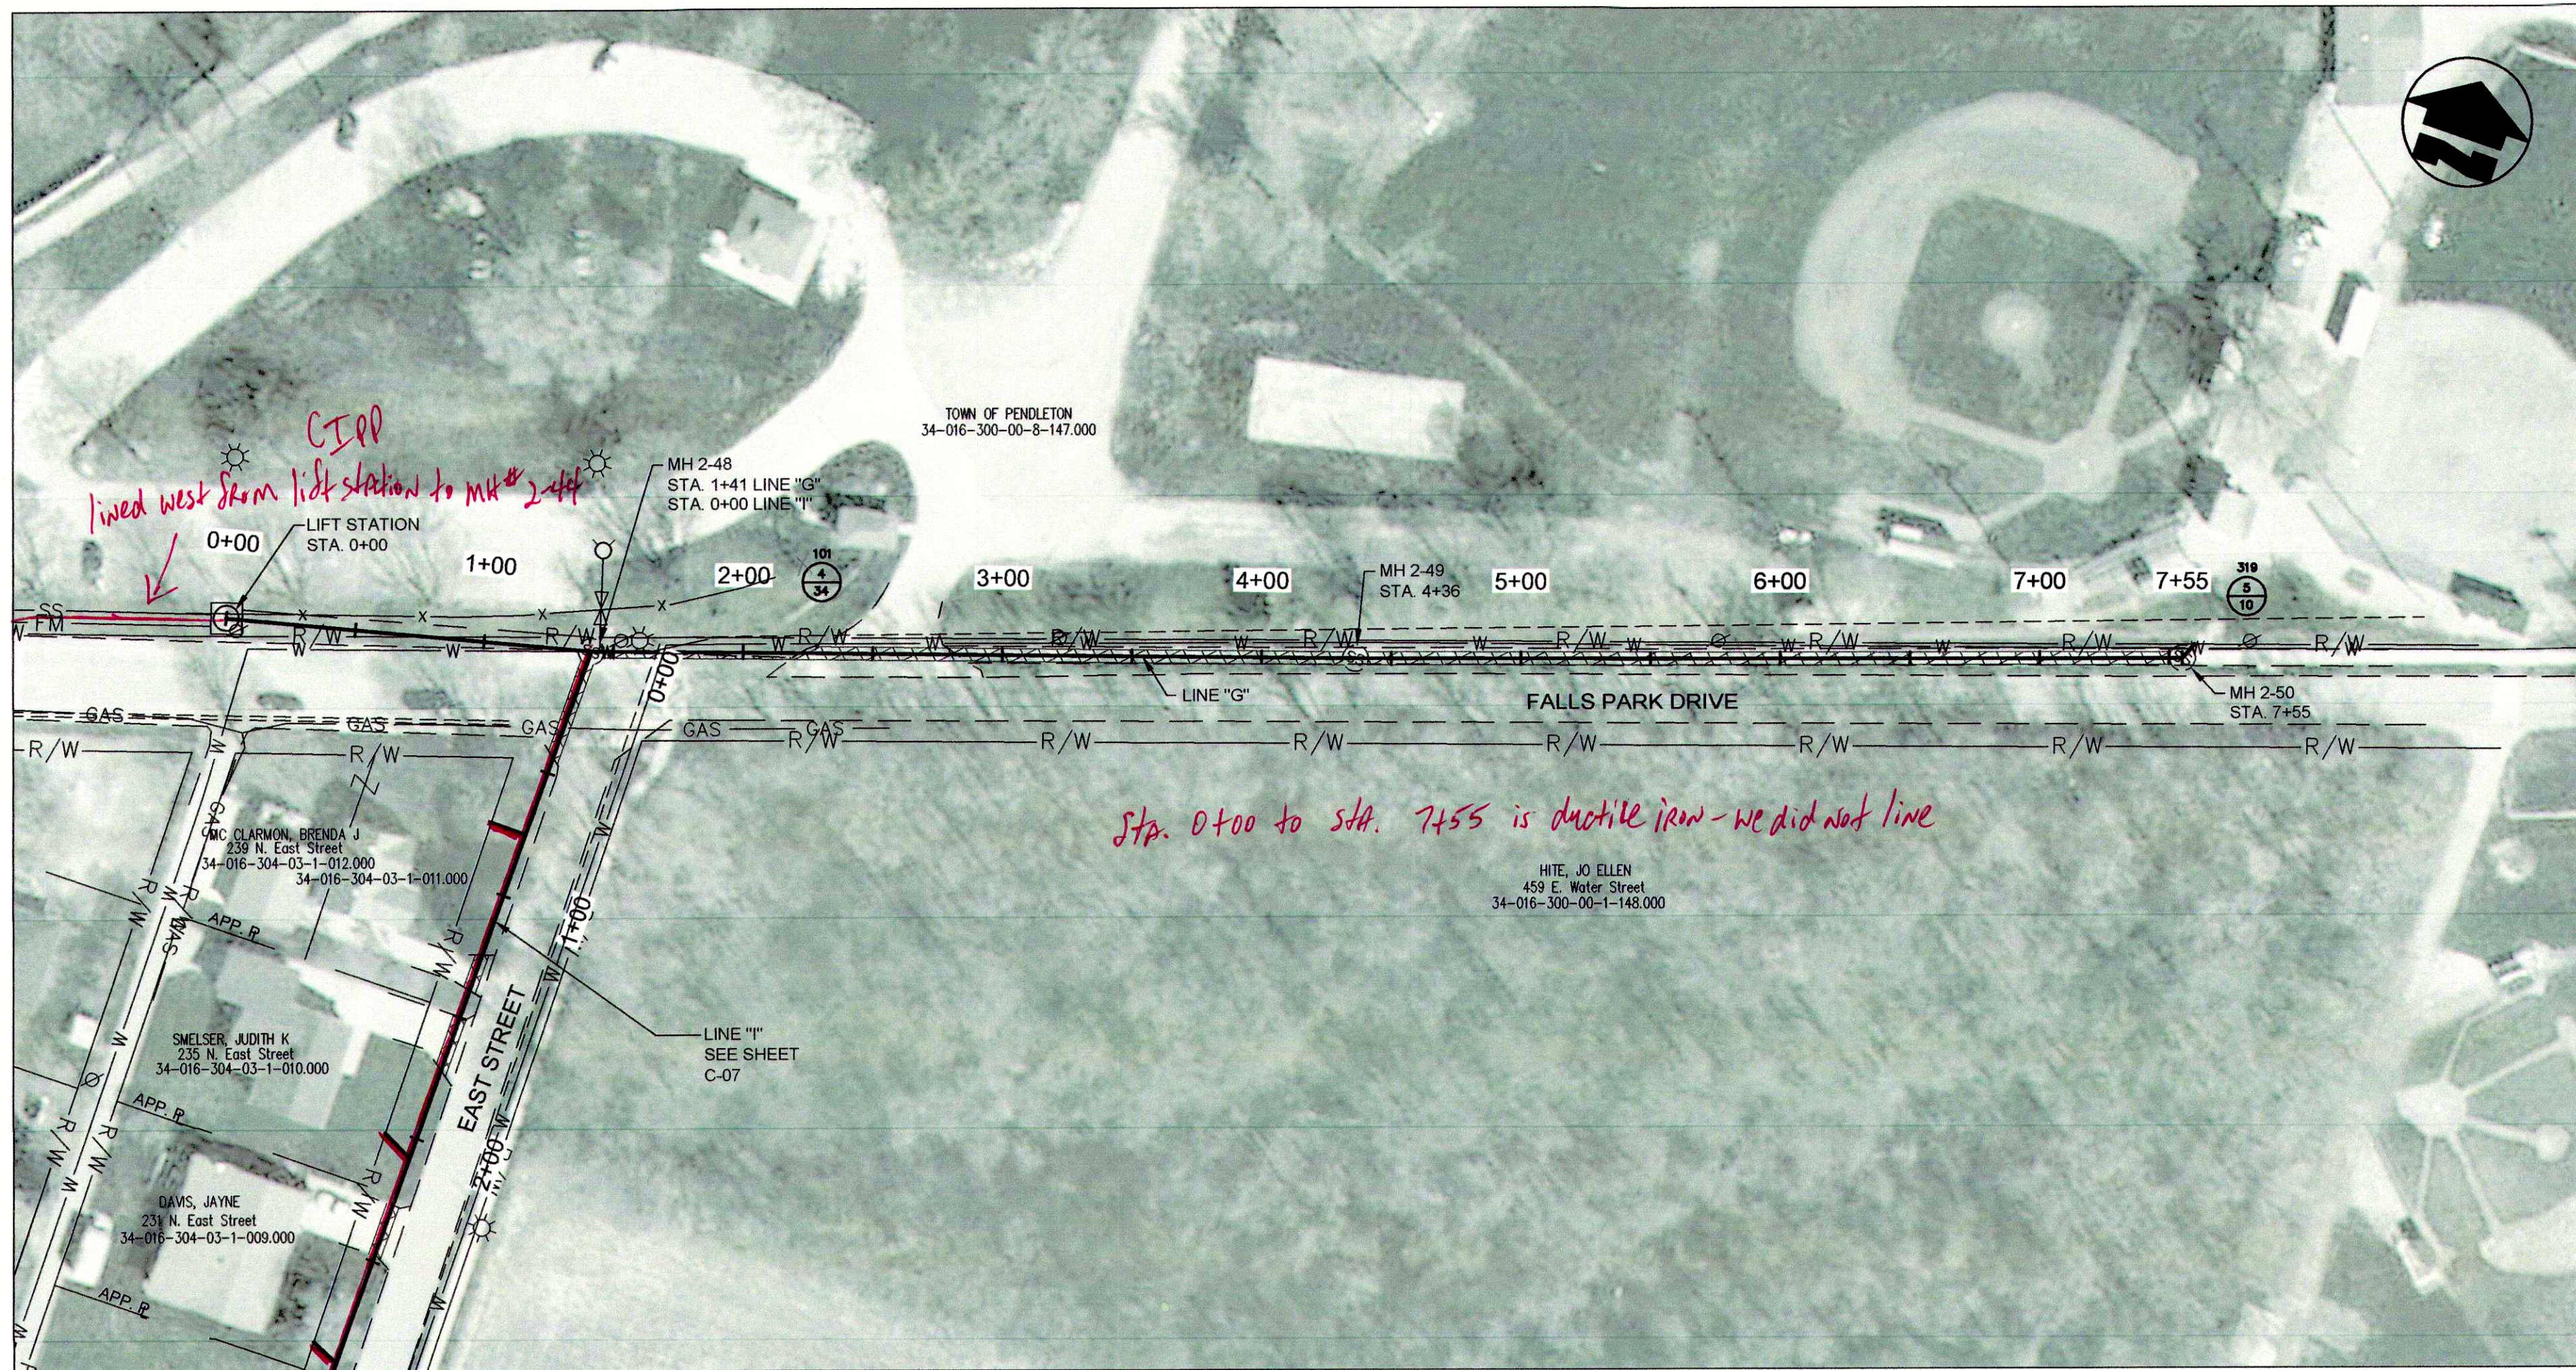

PLAN VIEW - STA. 0+00 TO STA. 7+55 LINE "G"

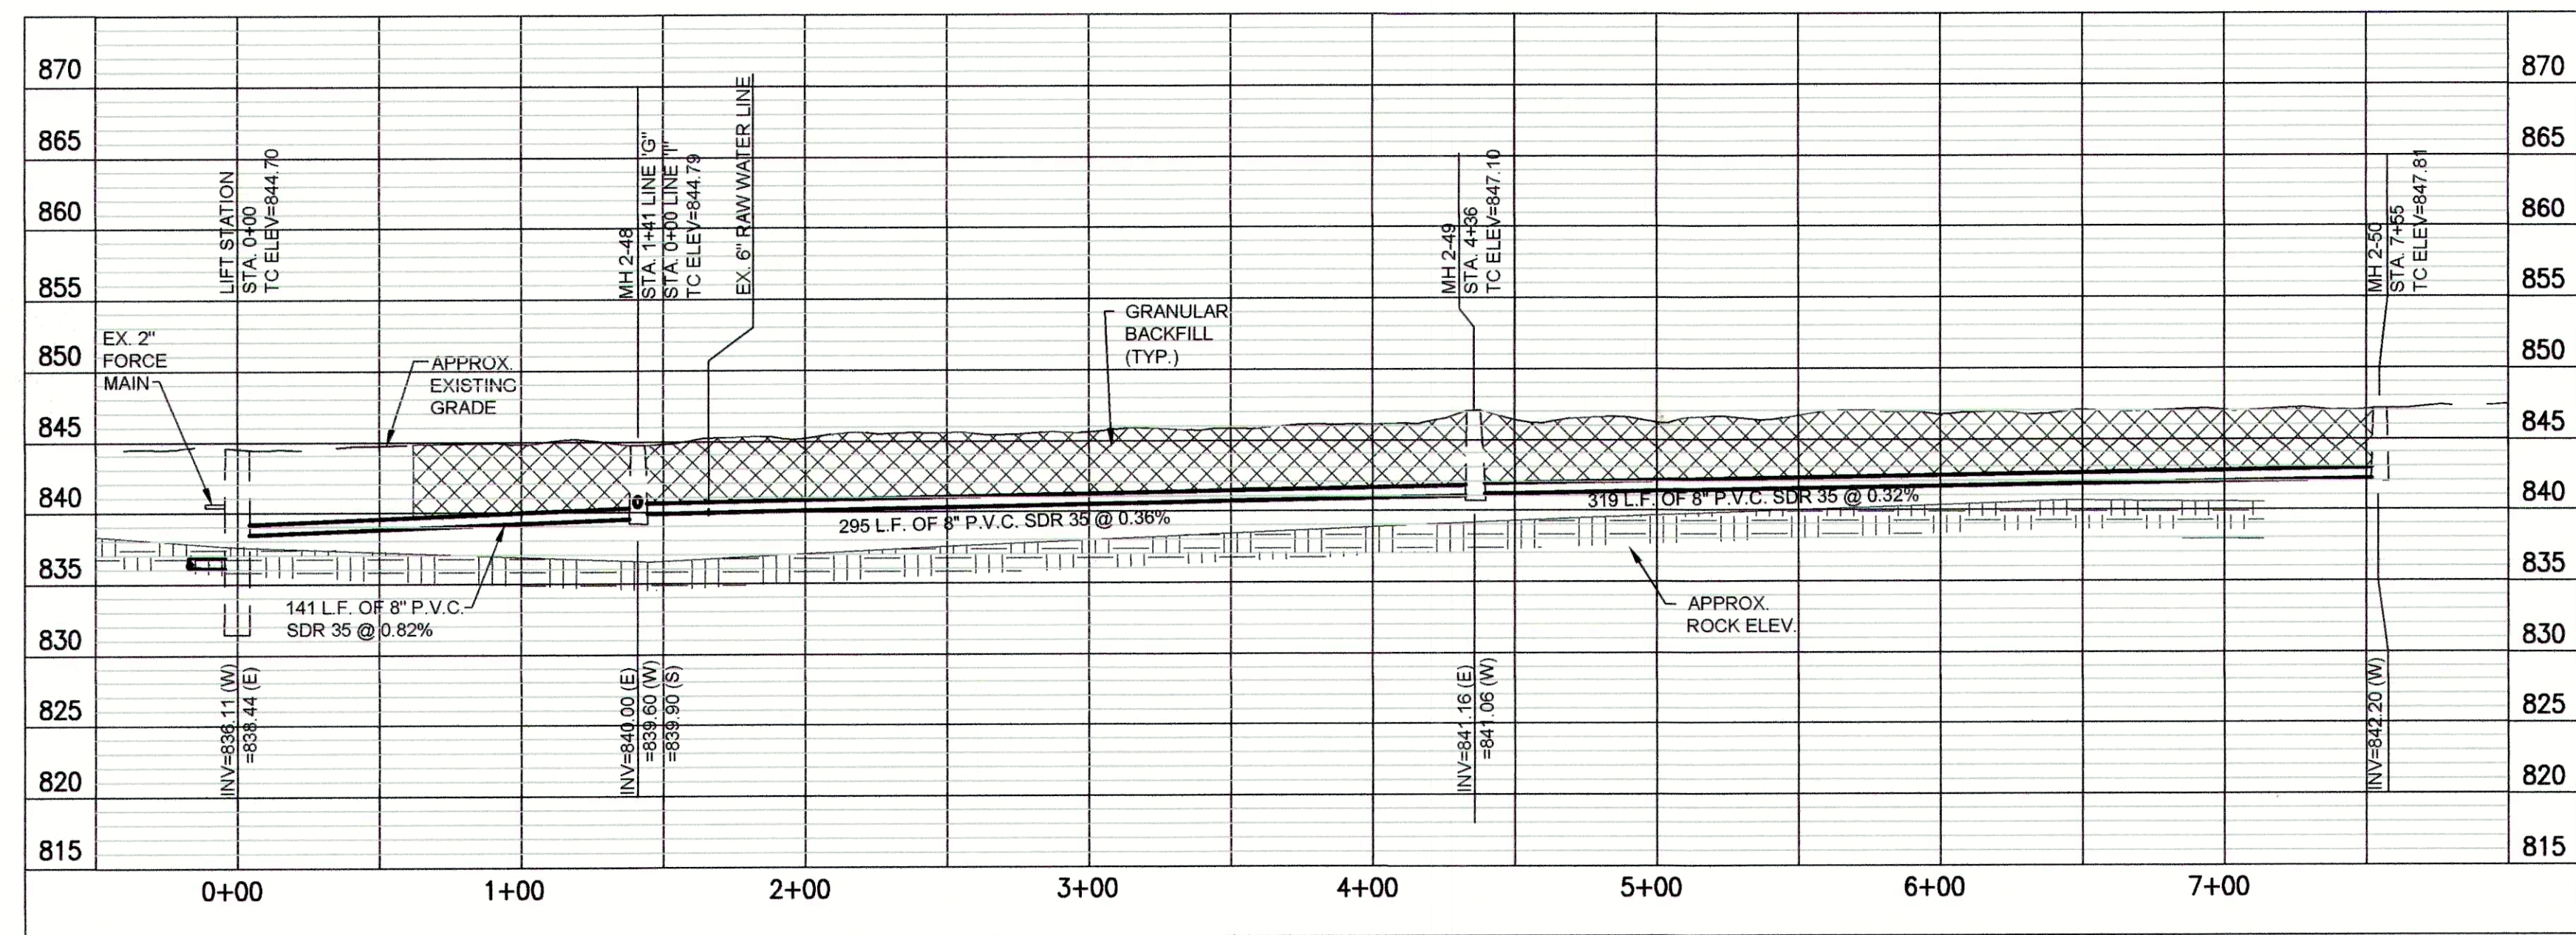


PROFILE - STA. 0+00 TO 7+55 LINE "G"

"BID SCHEDULE A" (OPEN CUT) NOTES:


- LATERAL LOCATIONS SHOWN ARE BASED ON BEST AVAILABLE INFORMATION. CONTRACTOR TO FIELD VERIFY ALL EXISTING SANITARY LATERAL LOCATIONS AND DEPTHS, INSTALL 6" SDR 35 SEWER PIPE TO R/W LINE AND CONNECT TO EXISTING LATERAL.
- THE EXISTING MANHOLES ARE TO REMAIN IN PLACE WITH NEW SEWERS RECONNECTED. THE MANHOLES SHALL BE REHABILITATED PER THE MANHOLE REHABILITATION SCHEDULE.

BID SCHEDULES A & B NOTES:

 
- SANITARY LATERAL LEGEND:



A= DISTANCE FROM DOWN STREAM MANHOLE
X= APPROX. DEPTH AT R/W
Y= LENGTH FROM MAIN TO R/W

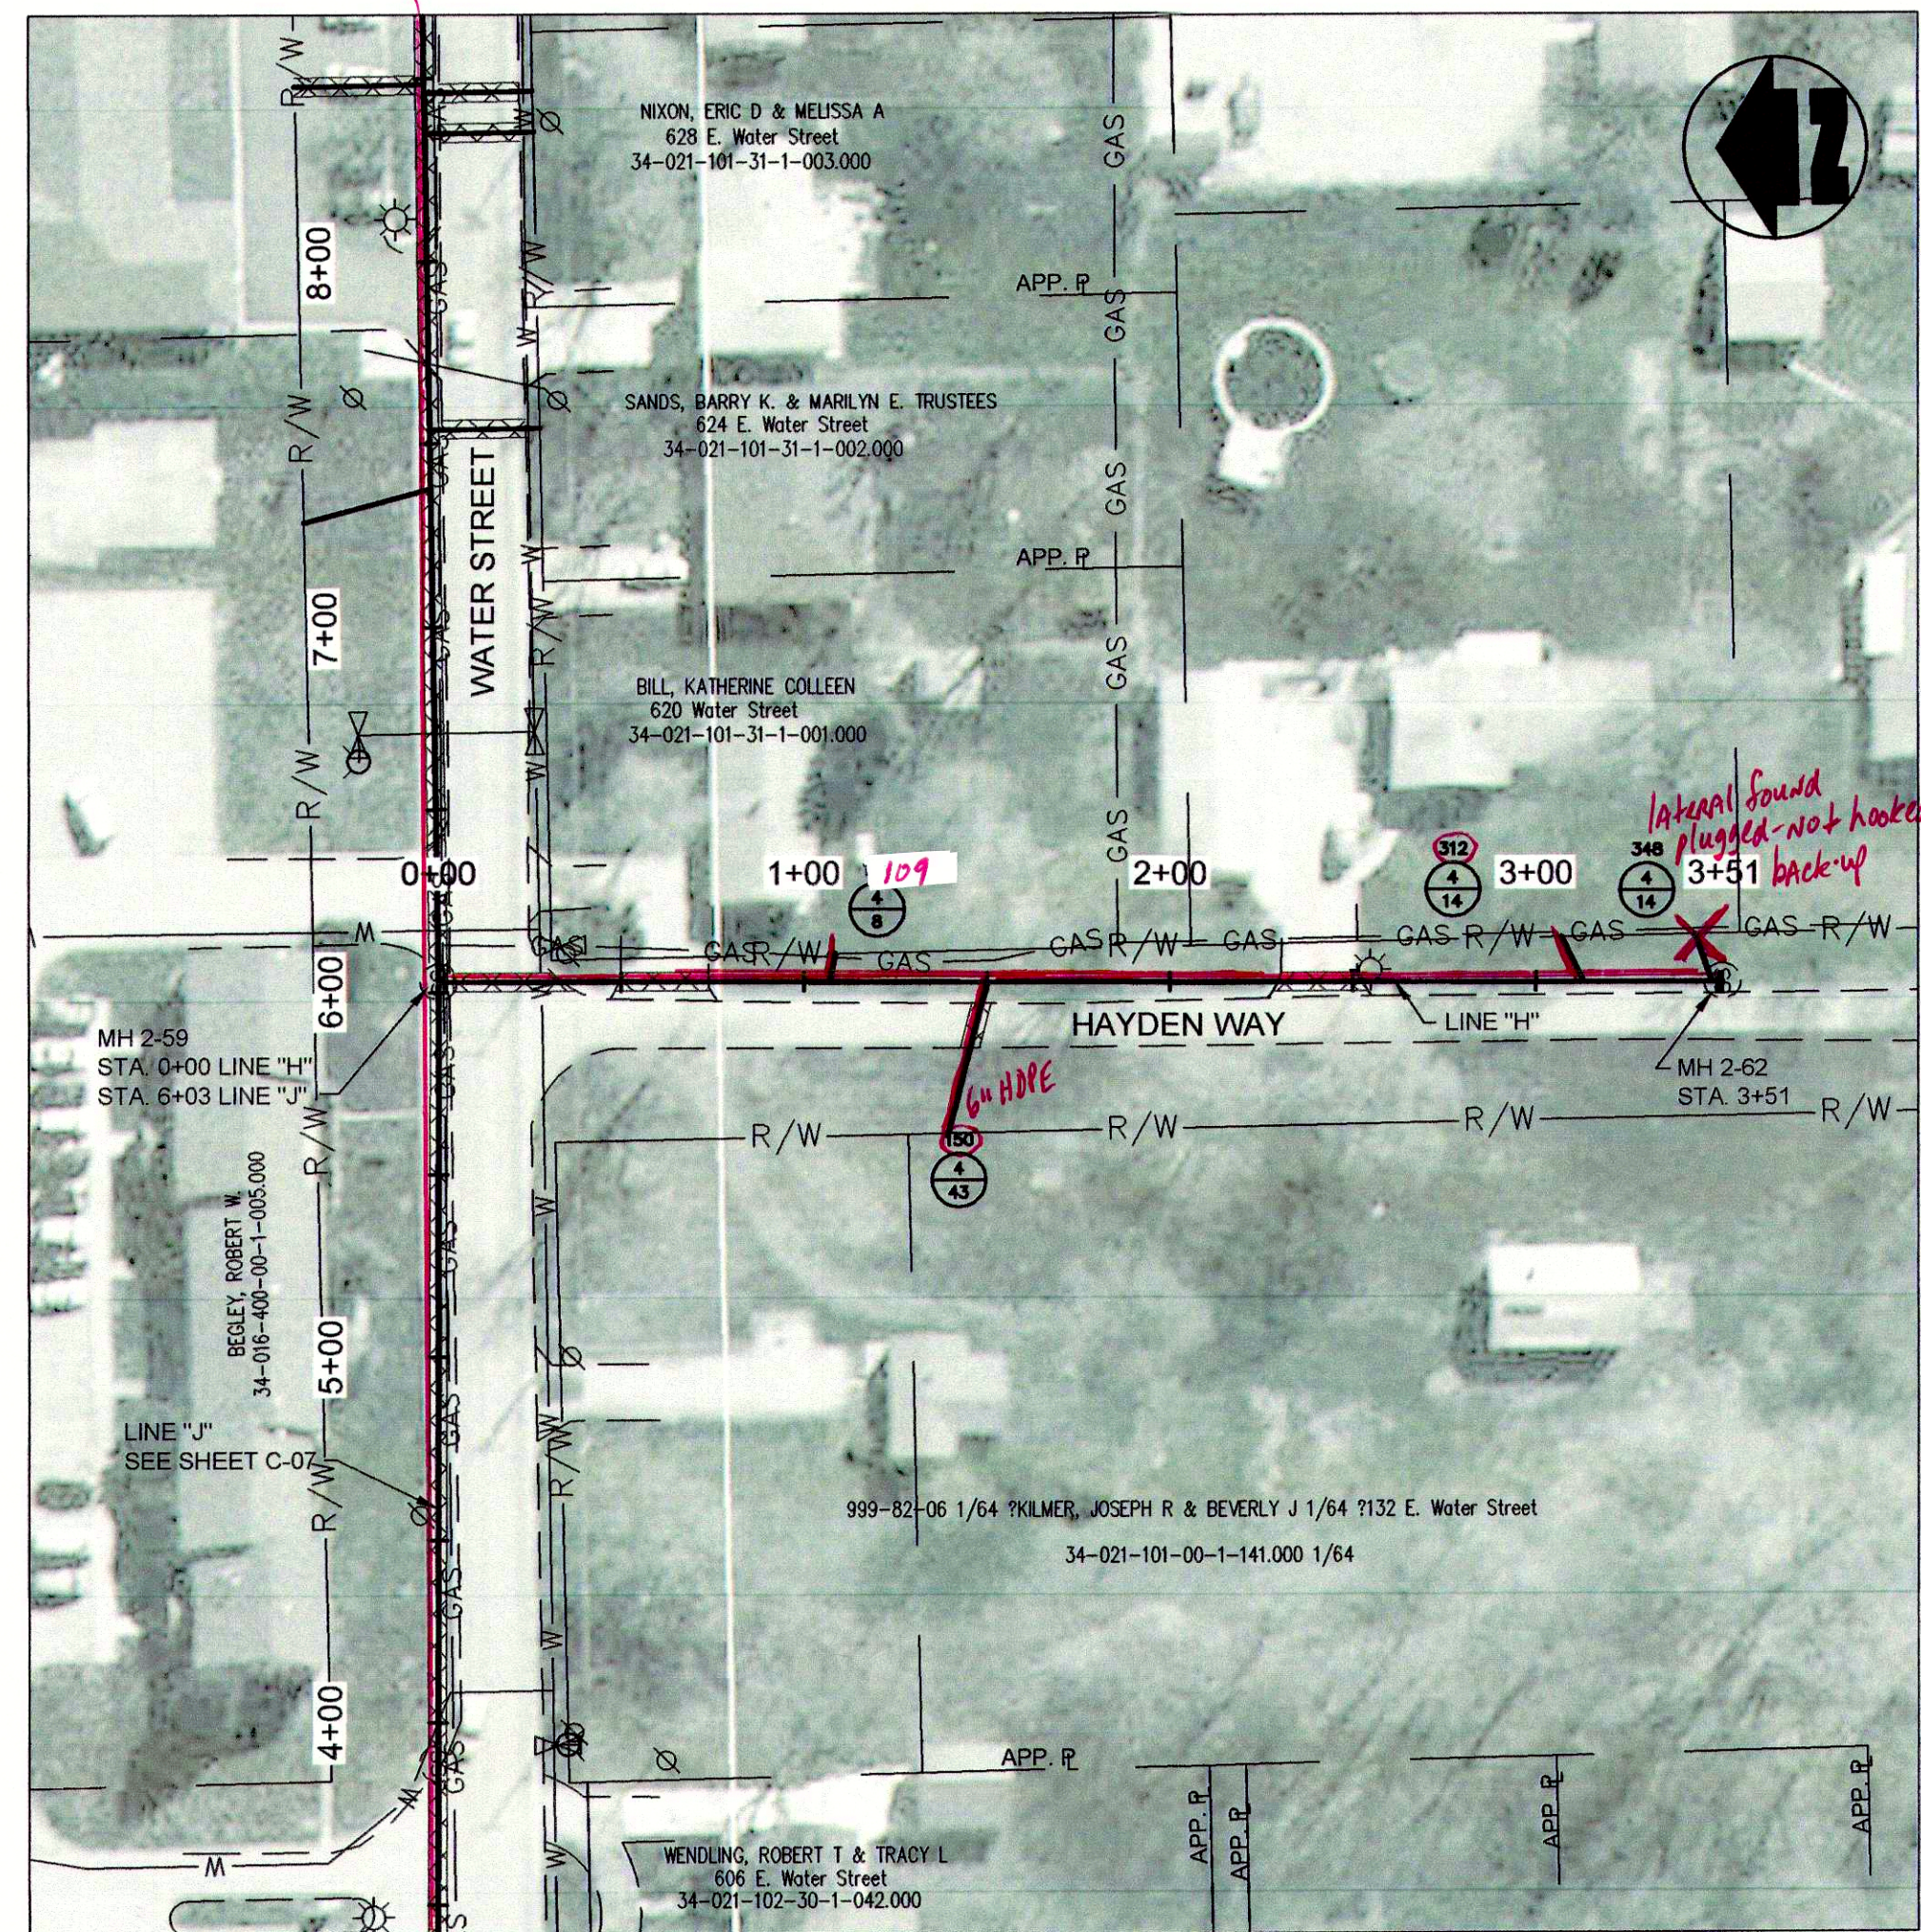


PLAN VIEW - STA. 0+00 TO STA. 3+51 LINE "H"

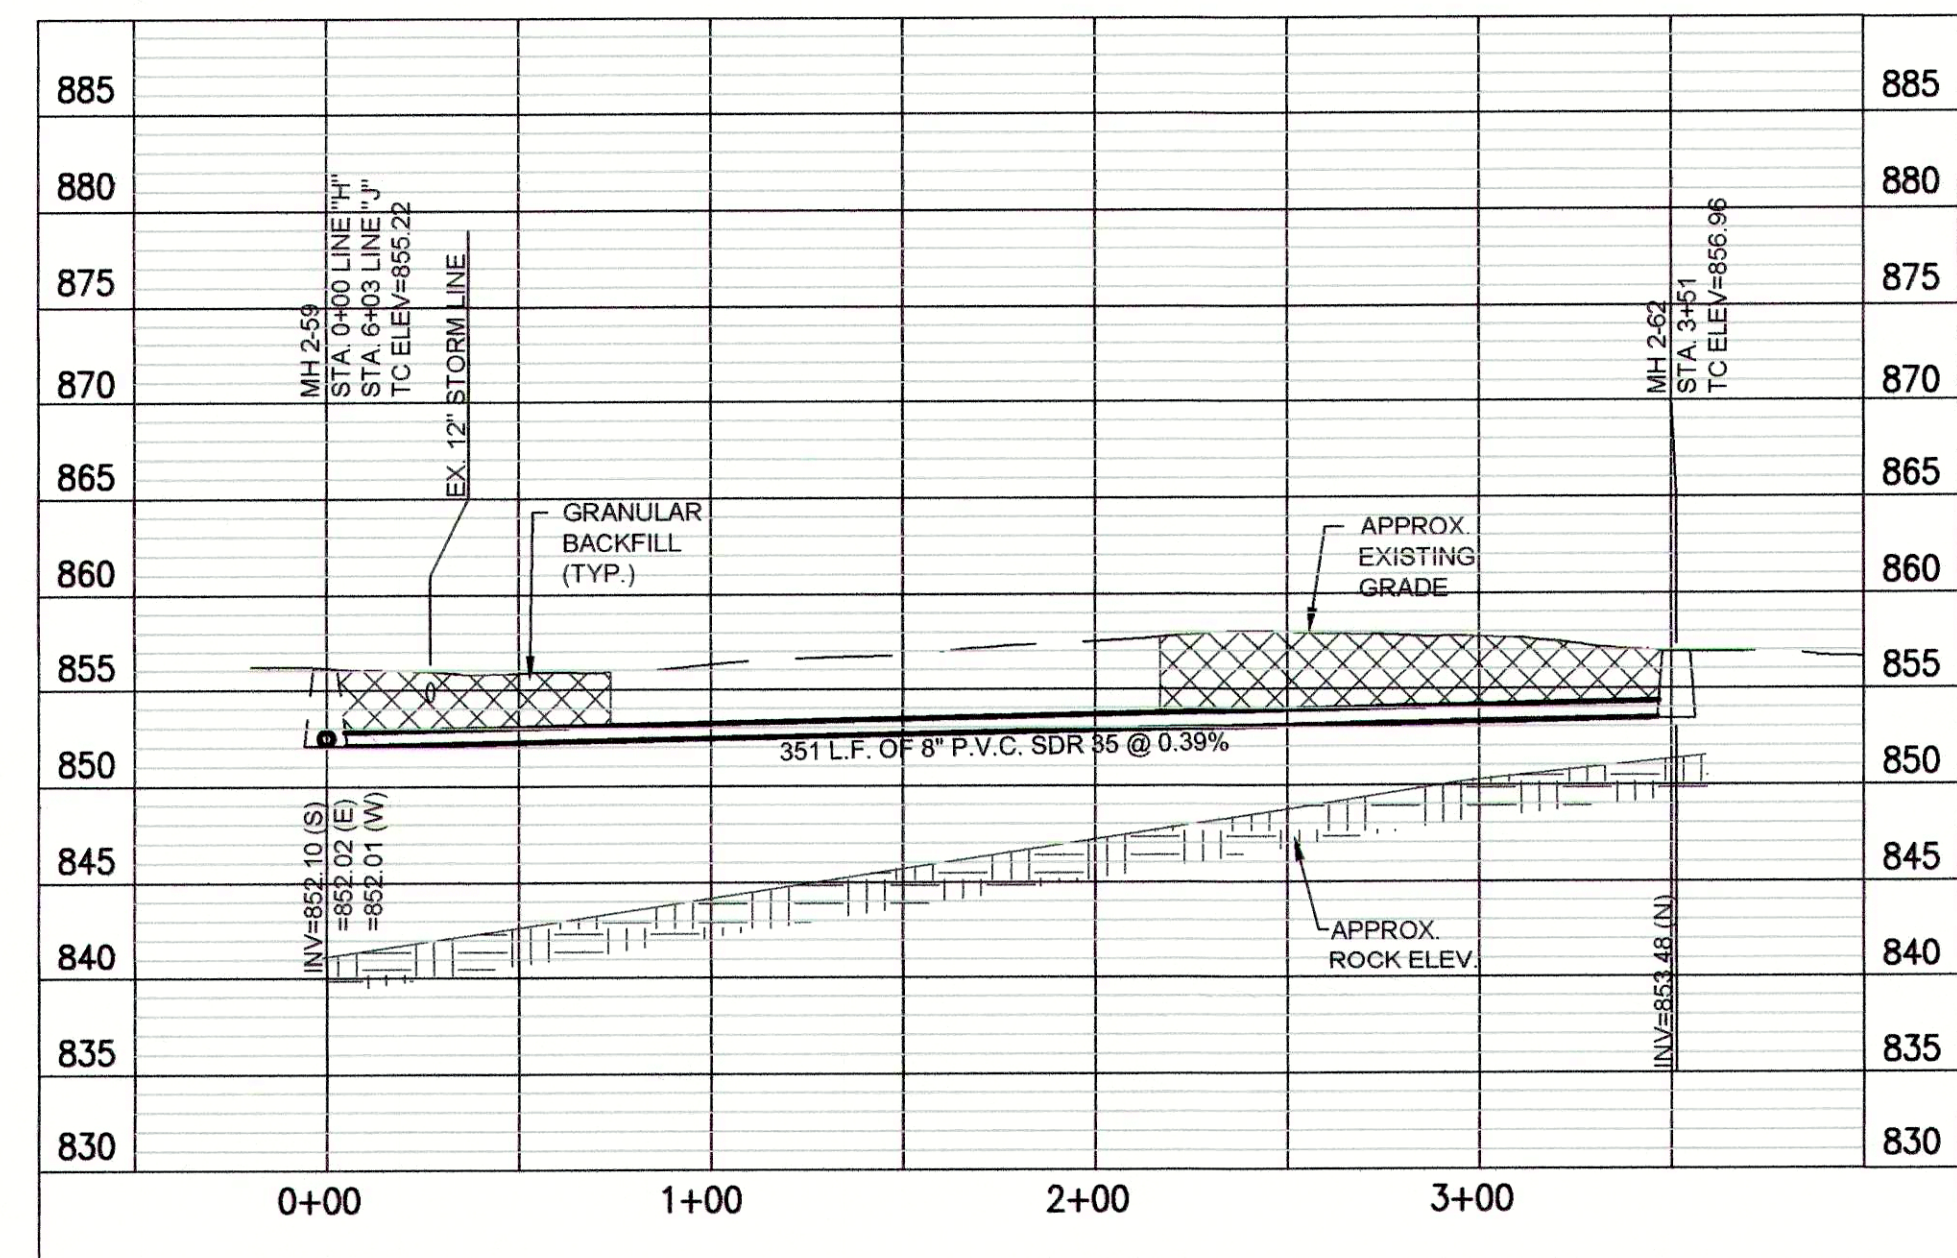


PROFILE - STA. 0+00 TO STA. 3+51 LINE "H"

"BID SCHEDULE B" (CIPP) NOTES:

- LATERAL LOCATIONS SHOWN ARE BASED ON BEST AVAILABLE INFORMATION. CONTRACTOR TO FIELD VERIFY EXISTING SANITARY LATERAL LOCATIONS AND DEPTHS, FOR LATERAL REPLACEMENTS, MAKE CONNECTION DIRECTLY TO CIPP LINER AS SHOWN IN THE DETAILS AND ON SHEET C-16. INSTALL 6" SDR 35 SEWER PIPE FROM MAIN TO R/W LINE AND CONNECT TO EXISTING LATERAL.
- IF THE PLANS SHOW C.I.P.P. LATERAL REHABILITATION, COMPLETE PER THE DETAIL ON SHEET C-16.
- MANHOLE SHALL BE REHABILITATION PER THE MANHOLE REHABILITATION SCHEDULE.

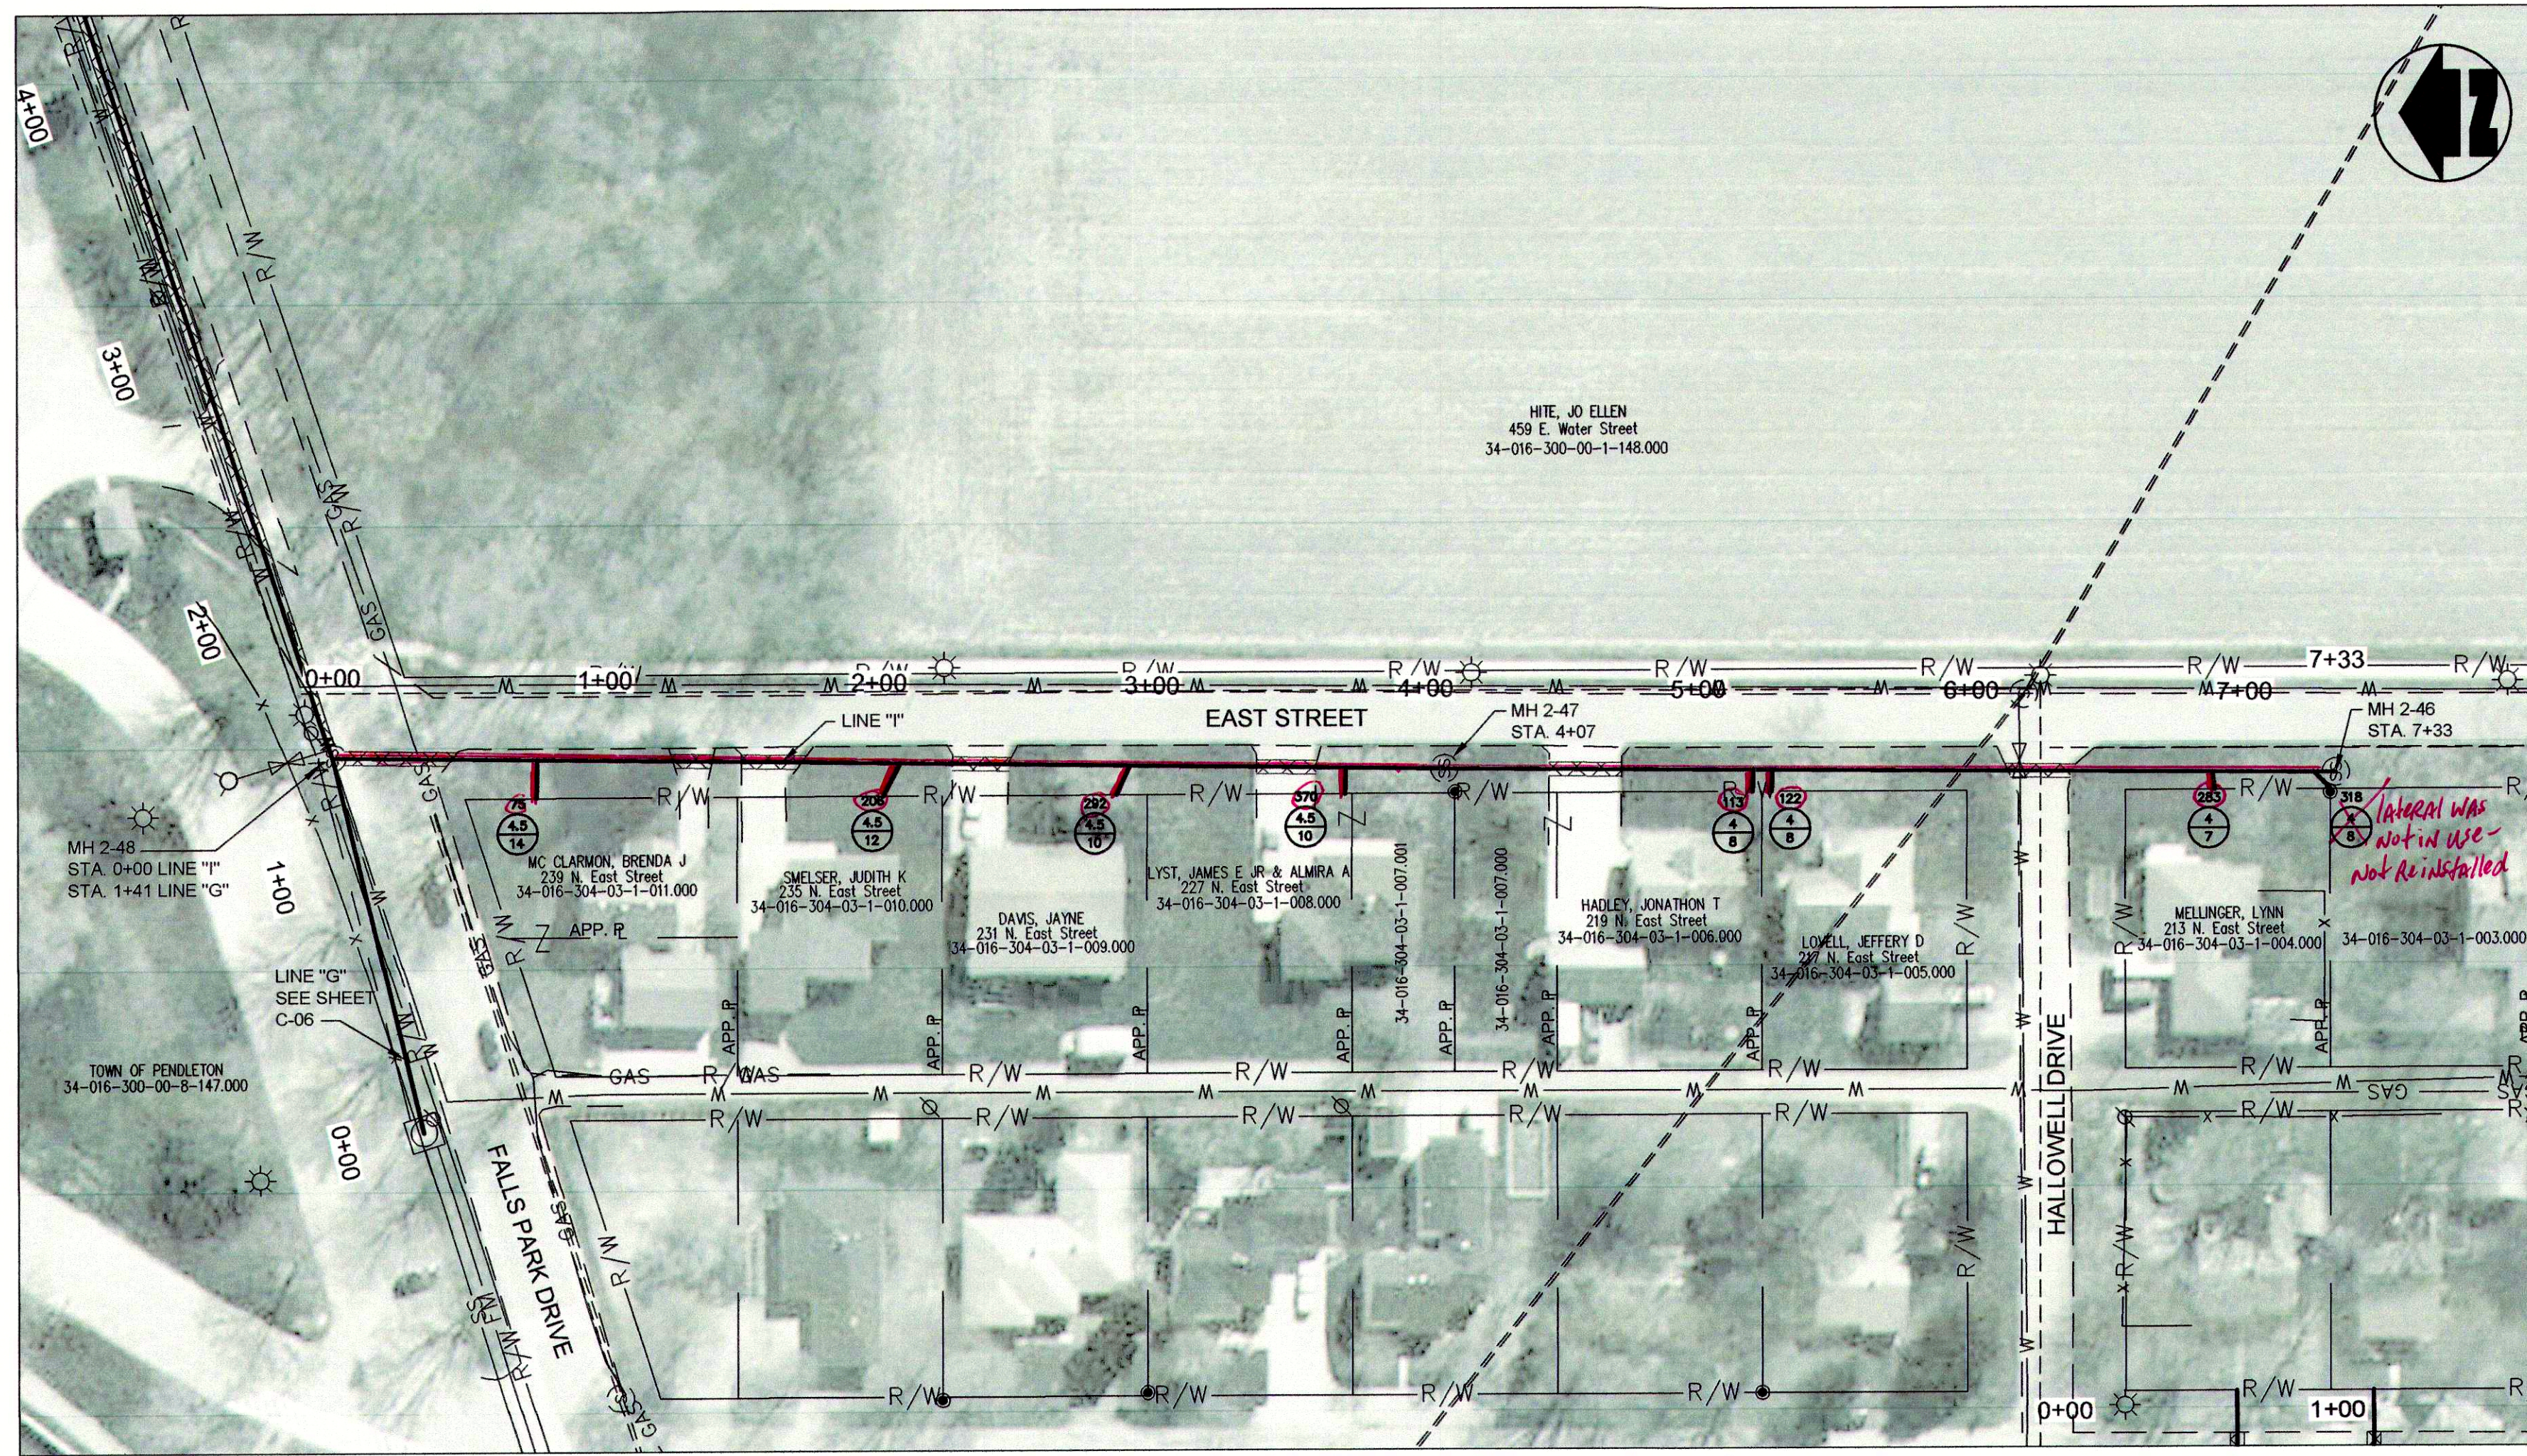

PLAN VIEW - STA. 0+00 TO STA. 7+33 LINE "I"

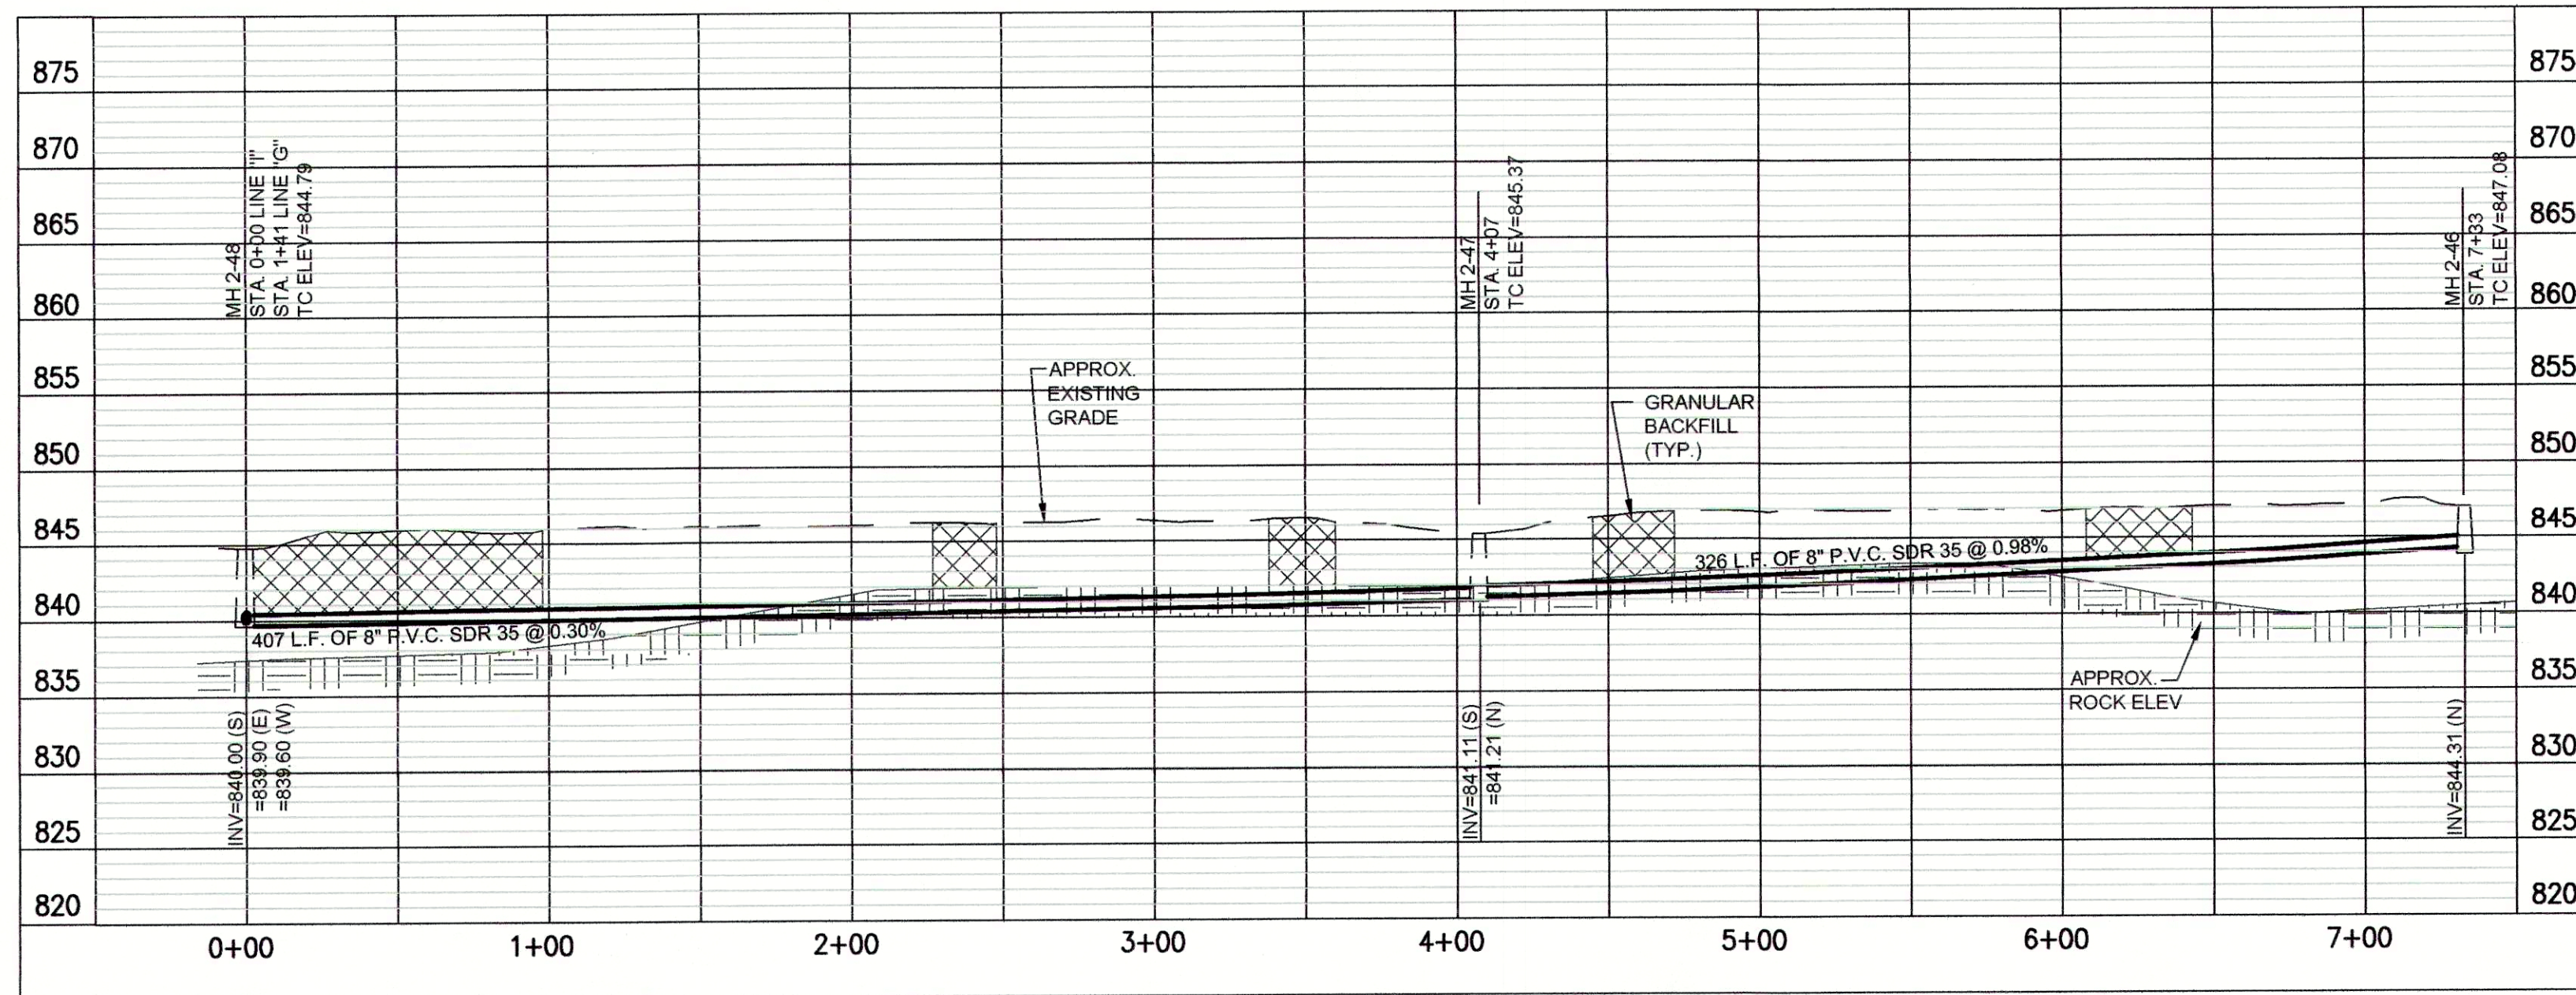


PROFILE - STA. 0+00 TO STA. 7+33 LINE "I"

"BID SCHEDULE A" (OPEN CUT) NOTES:


- LATERAL LOCATIONS SHOWN ARE BASED ON BEST AVAILABLE INFORMATION. CONTRACTOR TO FIELD VERIFY ALL EXISTING SANITARY LATERAL LOCATIONS AND DEPTHS, INSTALL 6" SDR 35 SEWER PIPE TO R/W LINE AND CONNECT TO EXISTING LATERAL.
- THE EXISTING MANHOLES ARE TO REMAIN IN PLACE WITH NEW SEWERS RECONNECTED. THE MANHOLES SHALL BE REHABILITATED PER THE MANHOLE REHABILITATION SCHEDULE.

BID SCHEDULES A & B NOTES:

 
- SANITARY LATERAL LEGEND:



A = DISTANCE FROM DOWN STREAM MANHOLE
X = APPROX. DEPTH AT R/W
Y = LENGTH FROM MAIN TO R/W

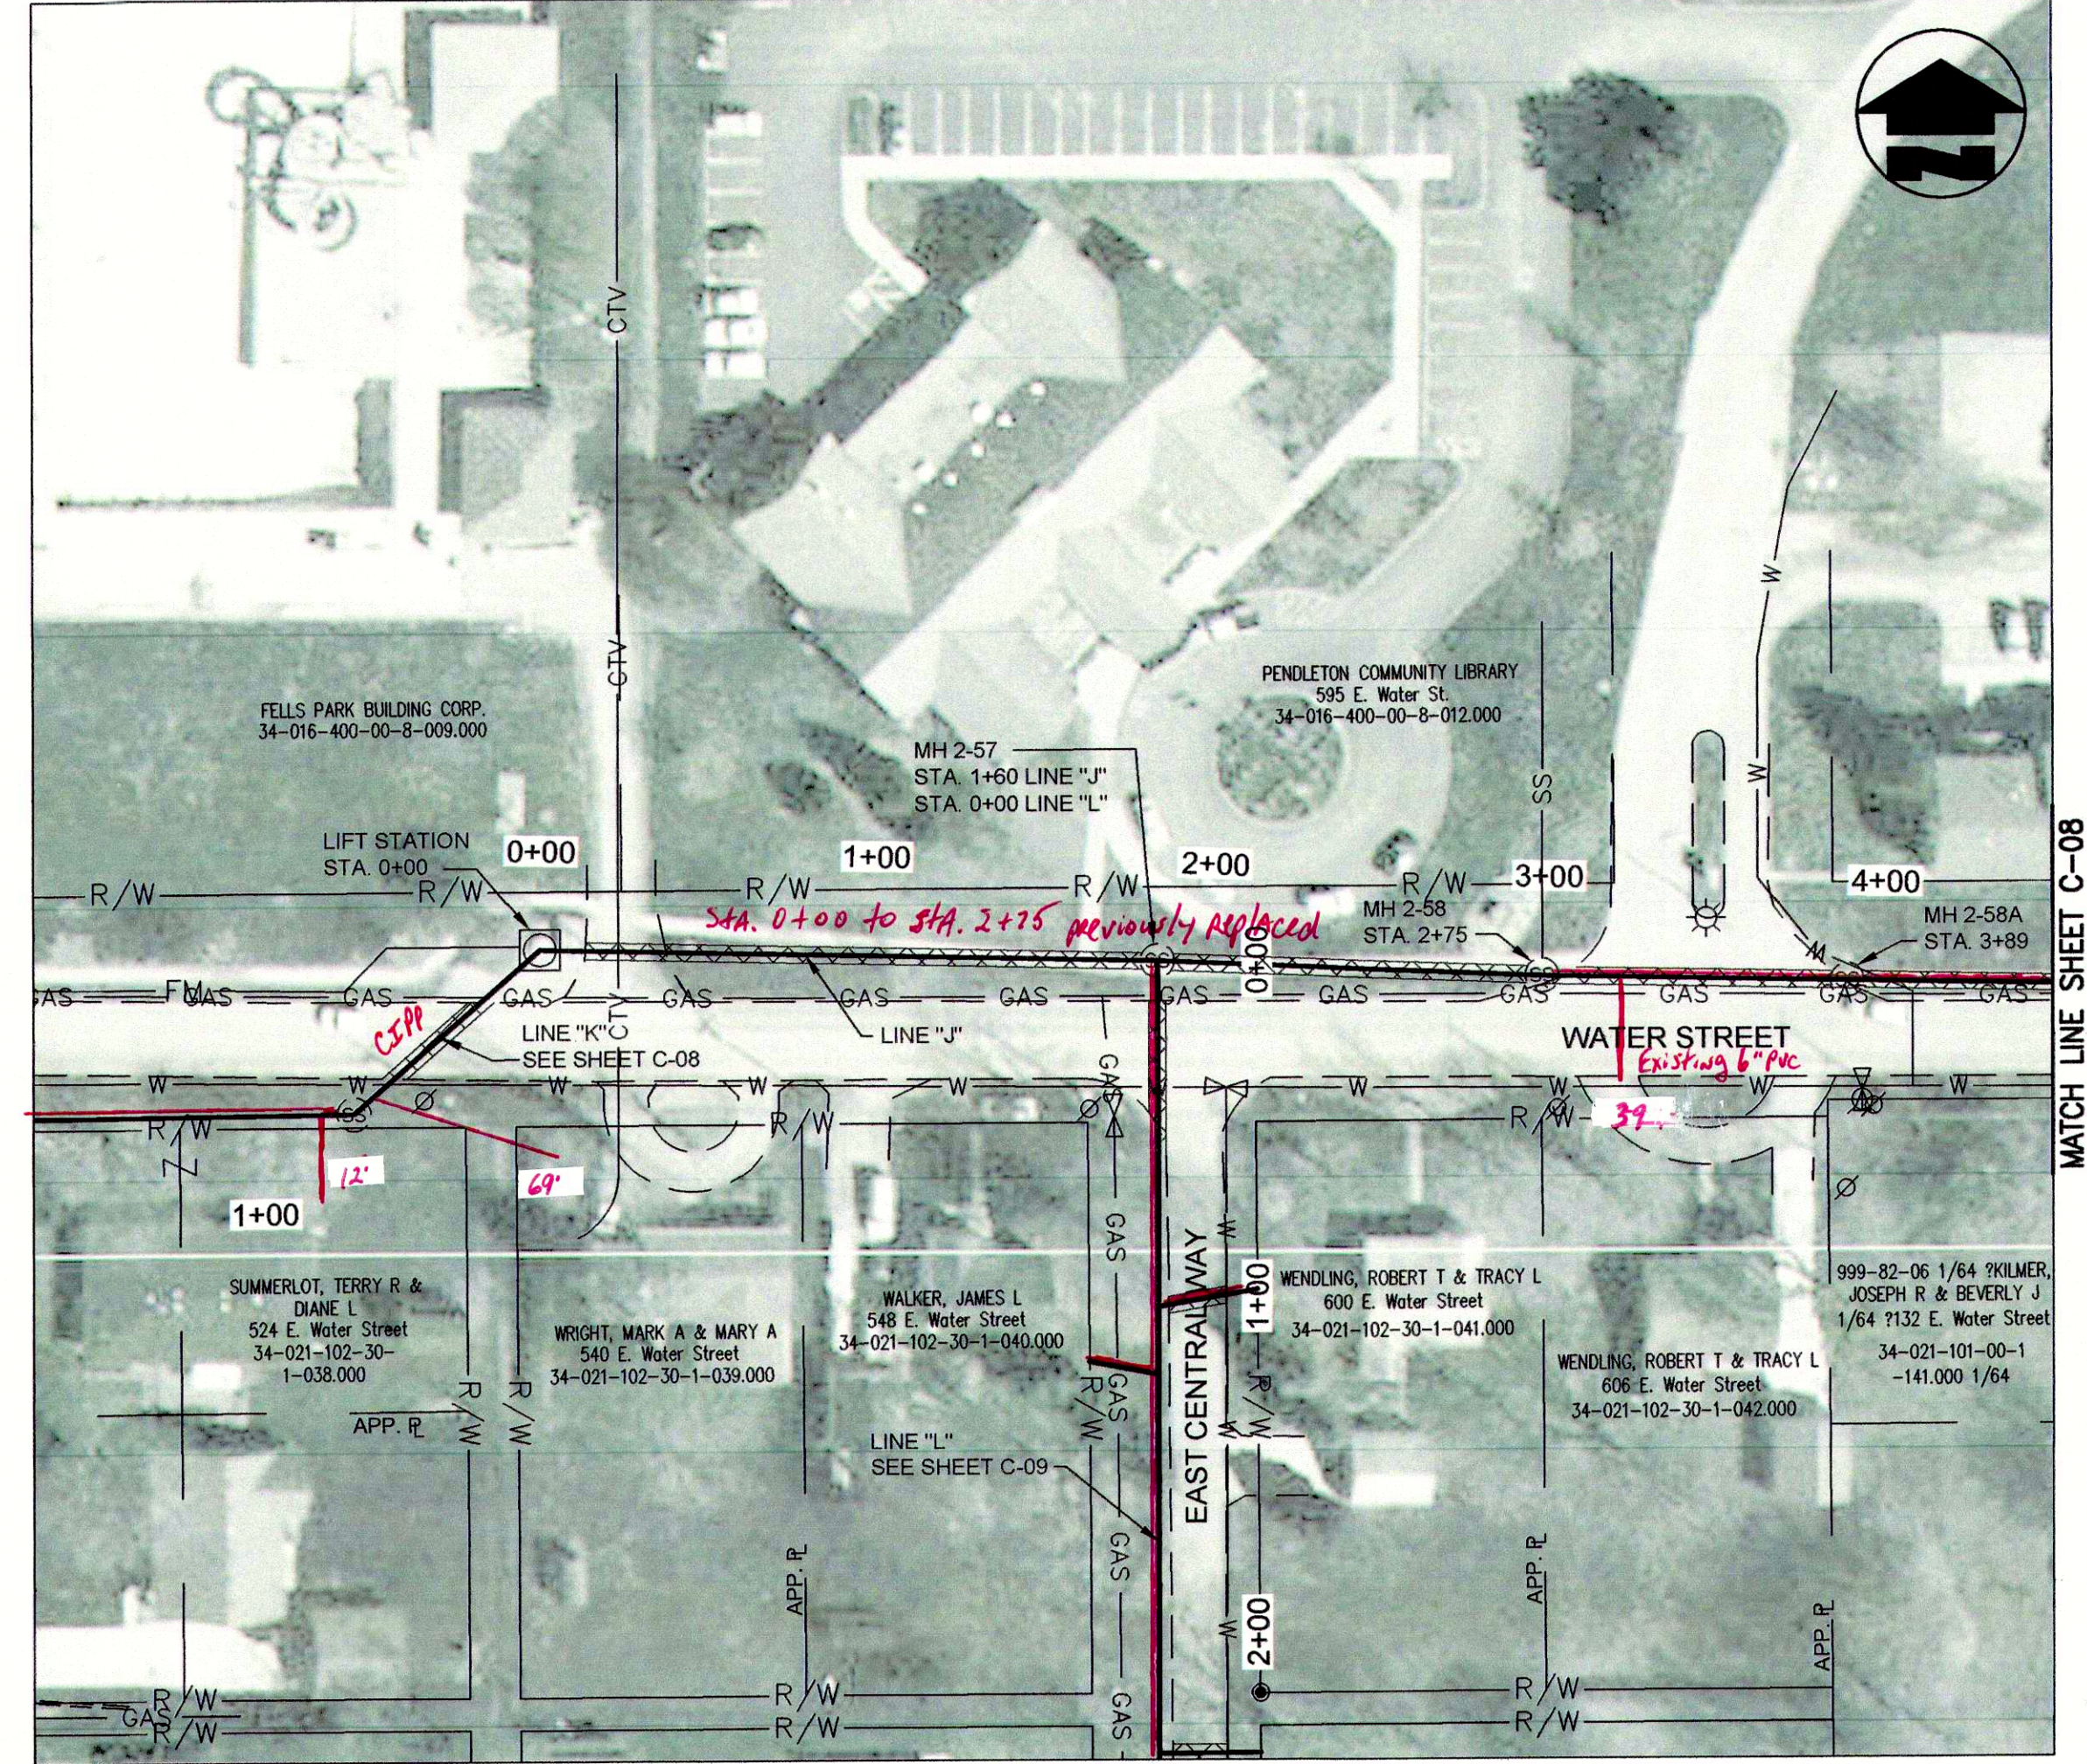


PLAN VIEW - B.O.P. STA. 0+00 TO STA. 4+50 LINE "J"

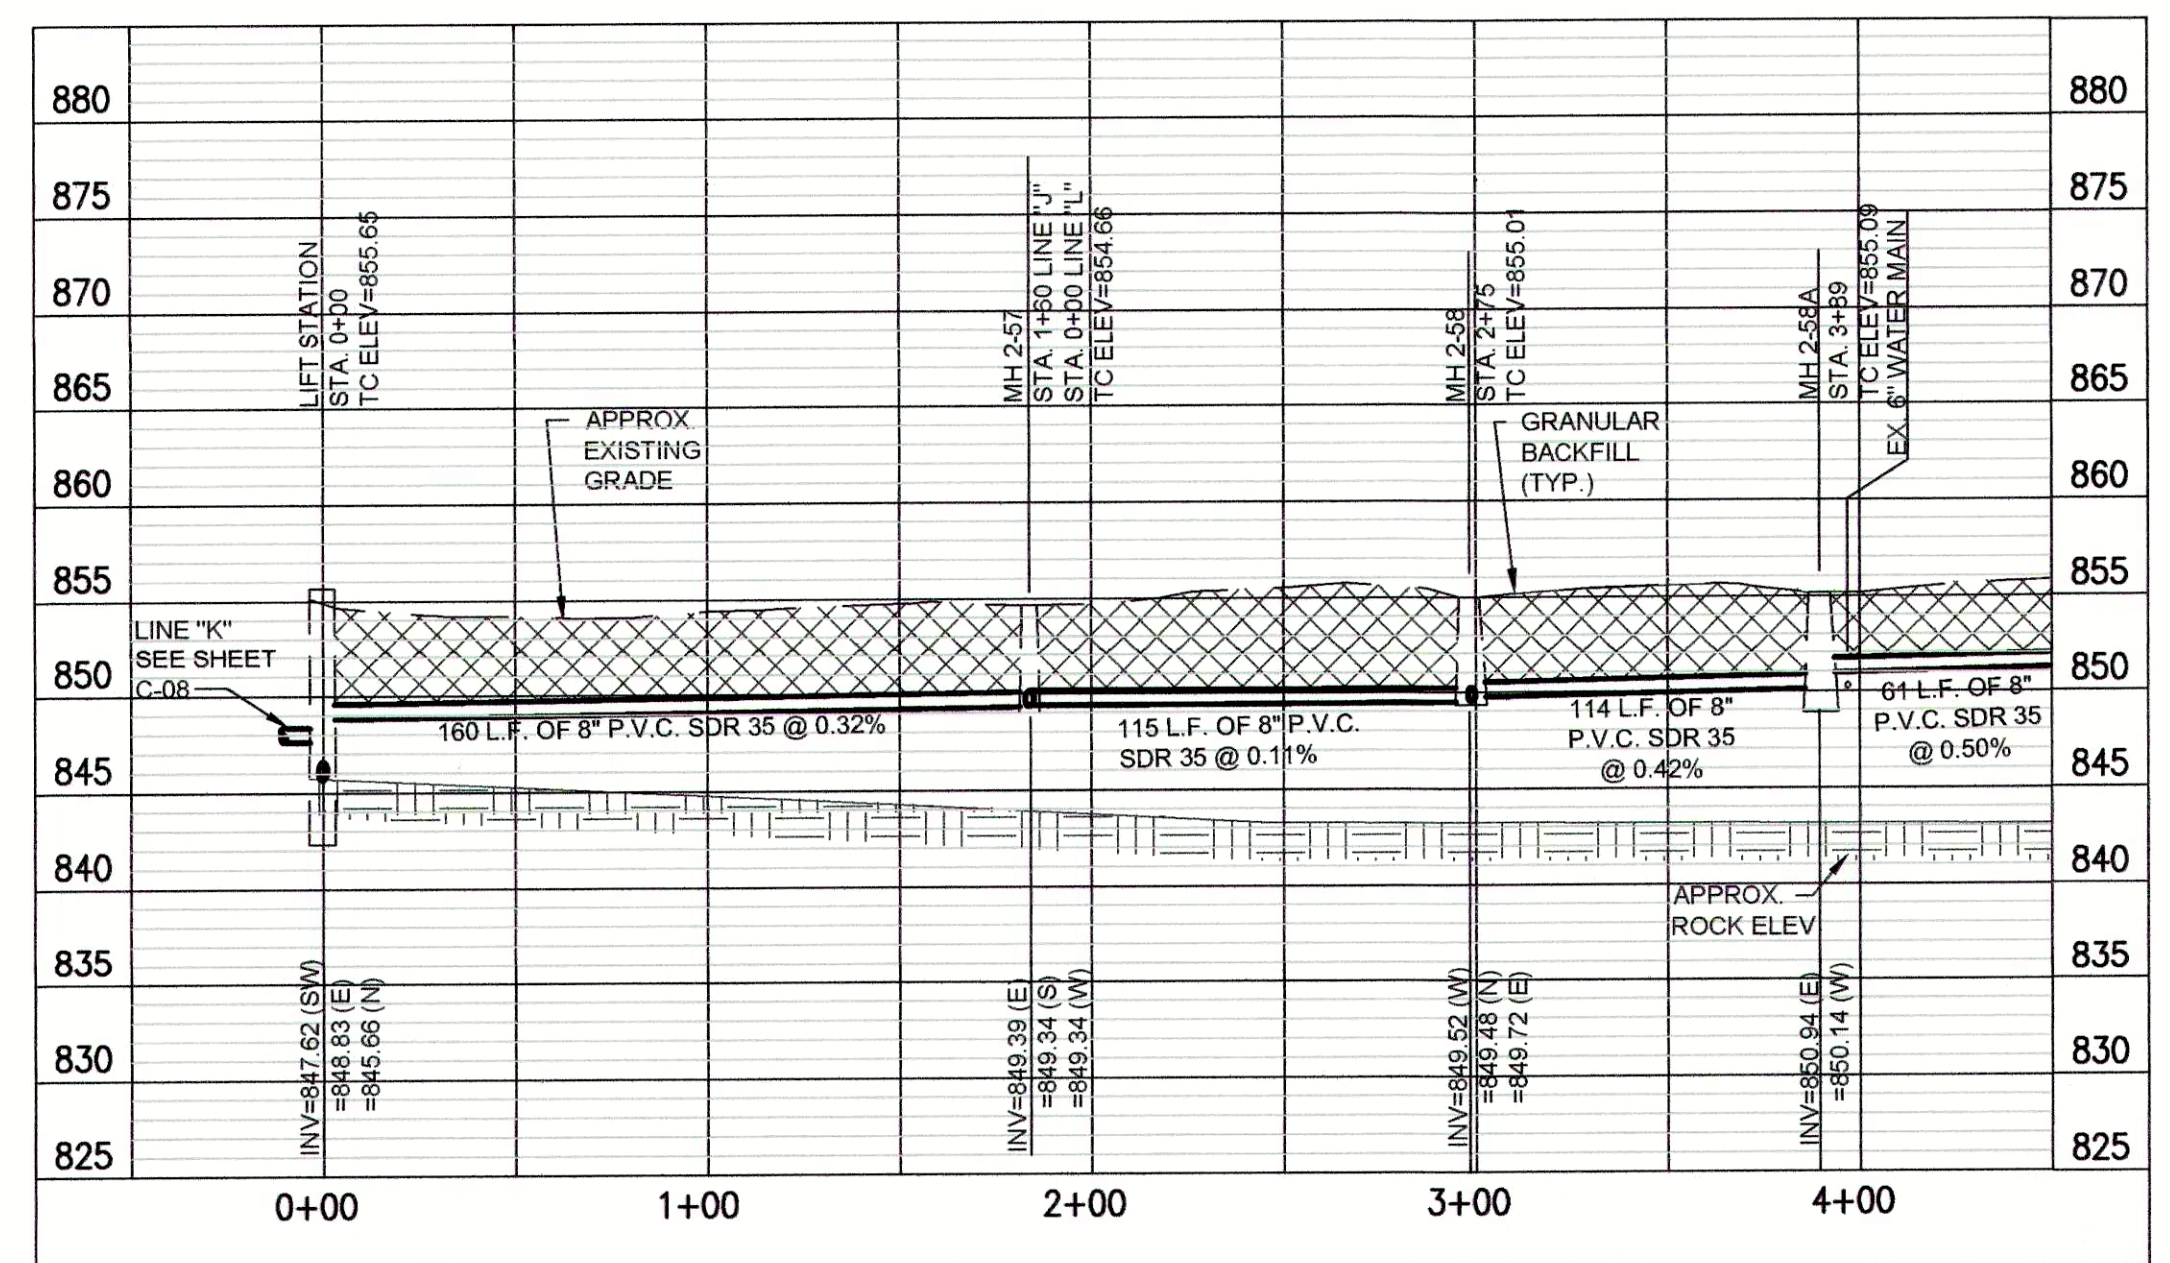


PROFILE - B.O.P. STA. 0+00 TO STA. 4+50 LINE "J"

"BID SCHEDULE B" (CIPP) NOTES:

- LATERAL LOCATIONS SHOWN ARE BASED ON BEST AVAILABLE INFORMATION. CONTRACTOR TO FIELD VERIFY EXISTING SANITARY LATERAL LOCATIONS AND DEPTHS, FOR LATERAL REPLACEMENTS, MAKE CONNECTION DIRECTLY TO CIPP LINER AS SHOWN IN THE DETAILS AND ON SHEET C-16. INSTALL 6" SDR 35 SEWER PIPE FROM MAIN TO R/W LINE AND CONNECT TO EXISTING LATERAL.
- IF THE PLANS SHOW C.I.P.P. LATERAL REHABILITATION, COMPLETE PER THE DETAIL ON SHEET C-16.
- MANHOLE SHALL BE REHABILITATION PER THE MANHOLE REHABILITATION SCHEDULE.

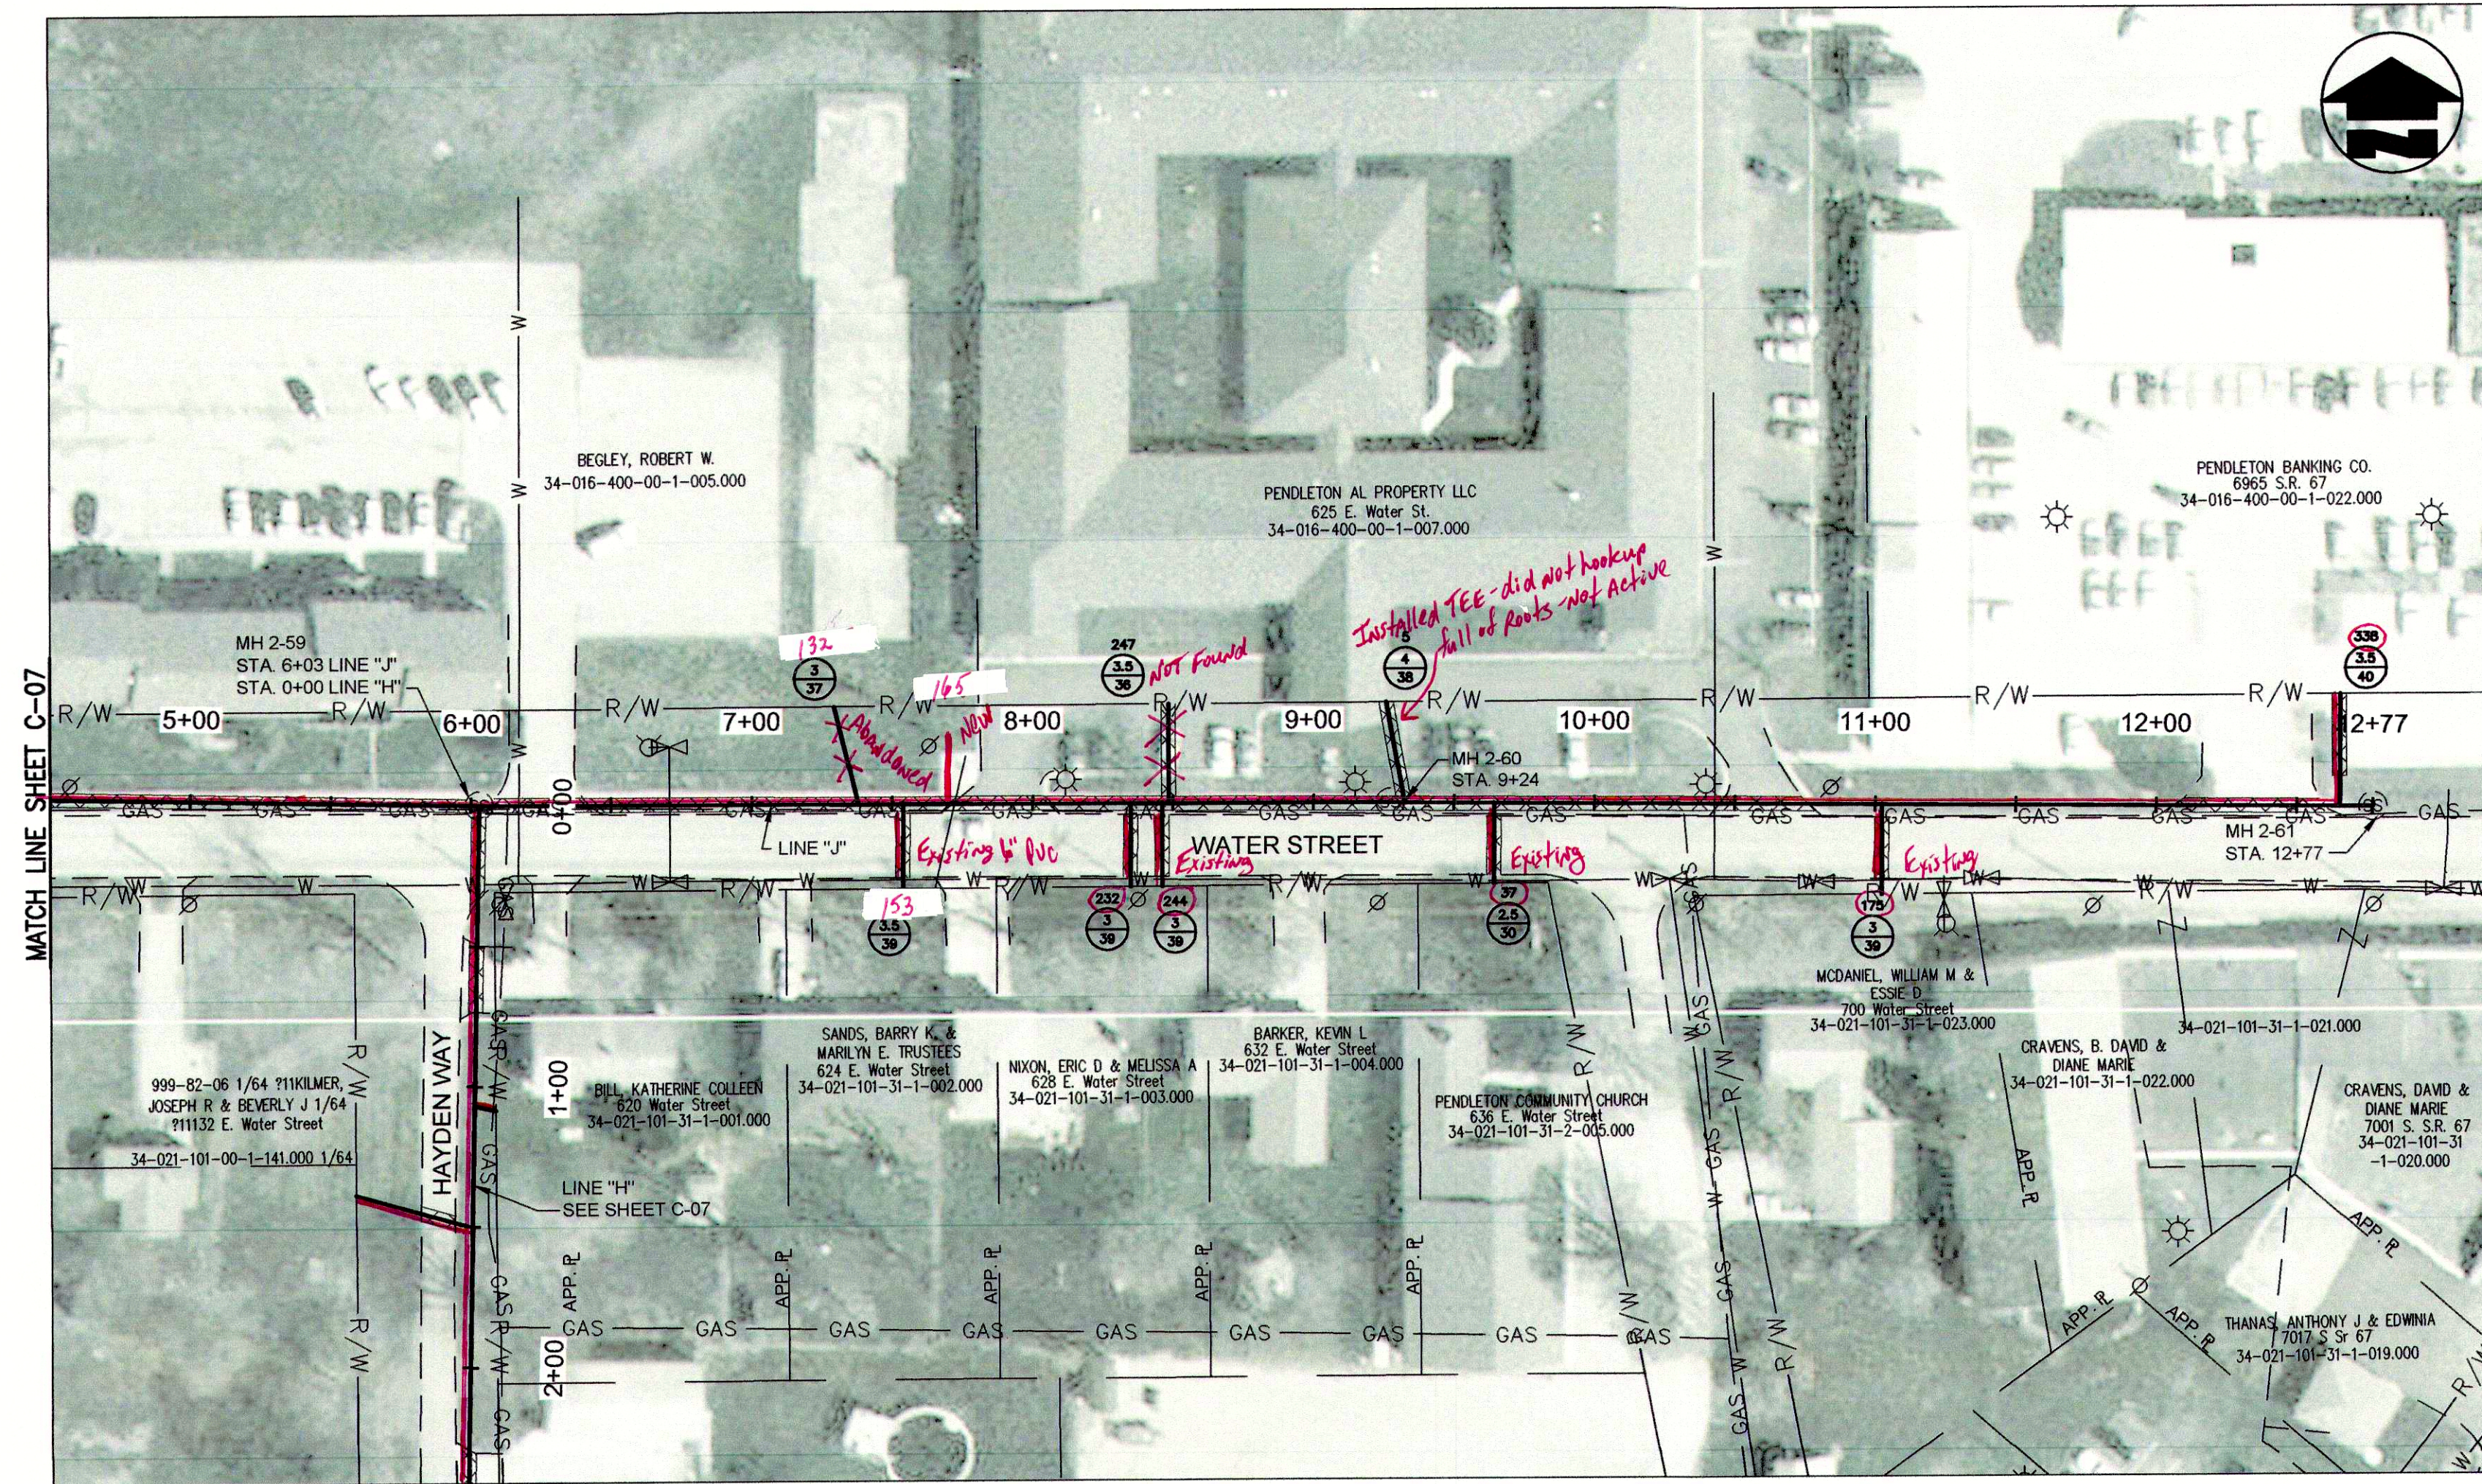

PLAN VIEW - STA. 4+50 TO STA. 12+77 LINE "J"

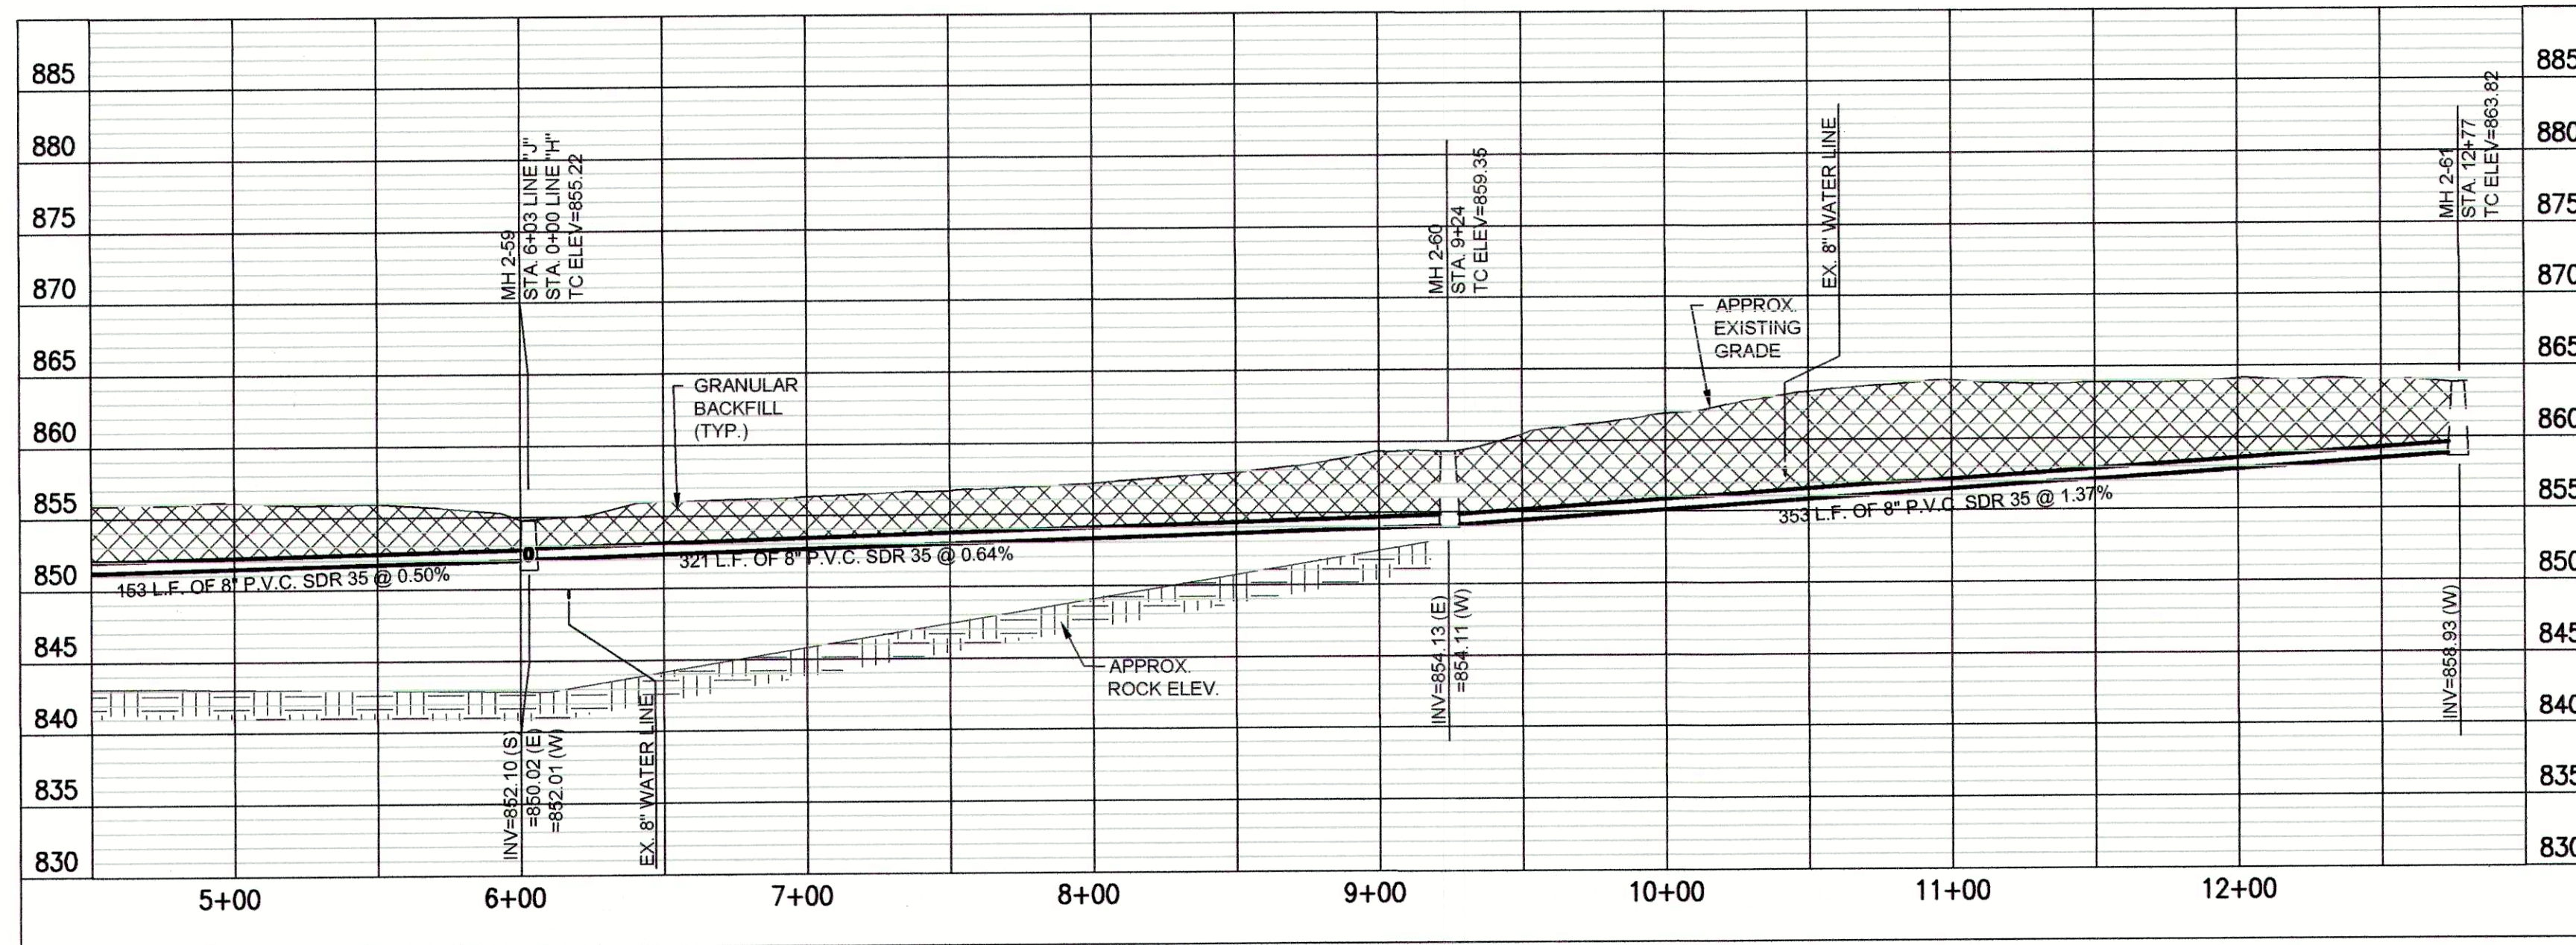


PROFILE - STA. 4+50 TO STA. 12+77 LINE "J"

"BID SCHEDULE A" (OPEN CUT) NOTES:


1. LATERAL LOCATIONS SHOWN ARE BASED ON BEST AVAILABLE INFORMATION. CONTRACTOR TO FIELD VERIFY ALL EXISTING SANITARY LATERAL LOCATIONS AND DEPTHS. INSTALL 6" SDR 35 SEWER PIPE TO R/W LINE AND CONNECT TO EXISTING LATERAL.
2. THE EXISTING MANHOLES ARE TO REMAIN IN PLACE WITH NEW SEWERS RECONNECTED. THE MANHOLES SHALL BE REHABILITATED PER THE MANHOLE REHABILITATION SCHEDULE.

BID SCHEDULES A & B NOTES:

 
1. SANITARY LATERAL LEGEND:



A = DISTANCE FROM DOWN STREAM MANHOLE
X = APPROX. DEPTH AT R/W
Y = LENGTH FROM MAIN TO R/W

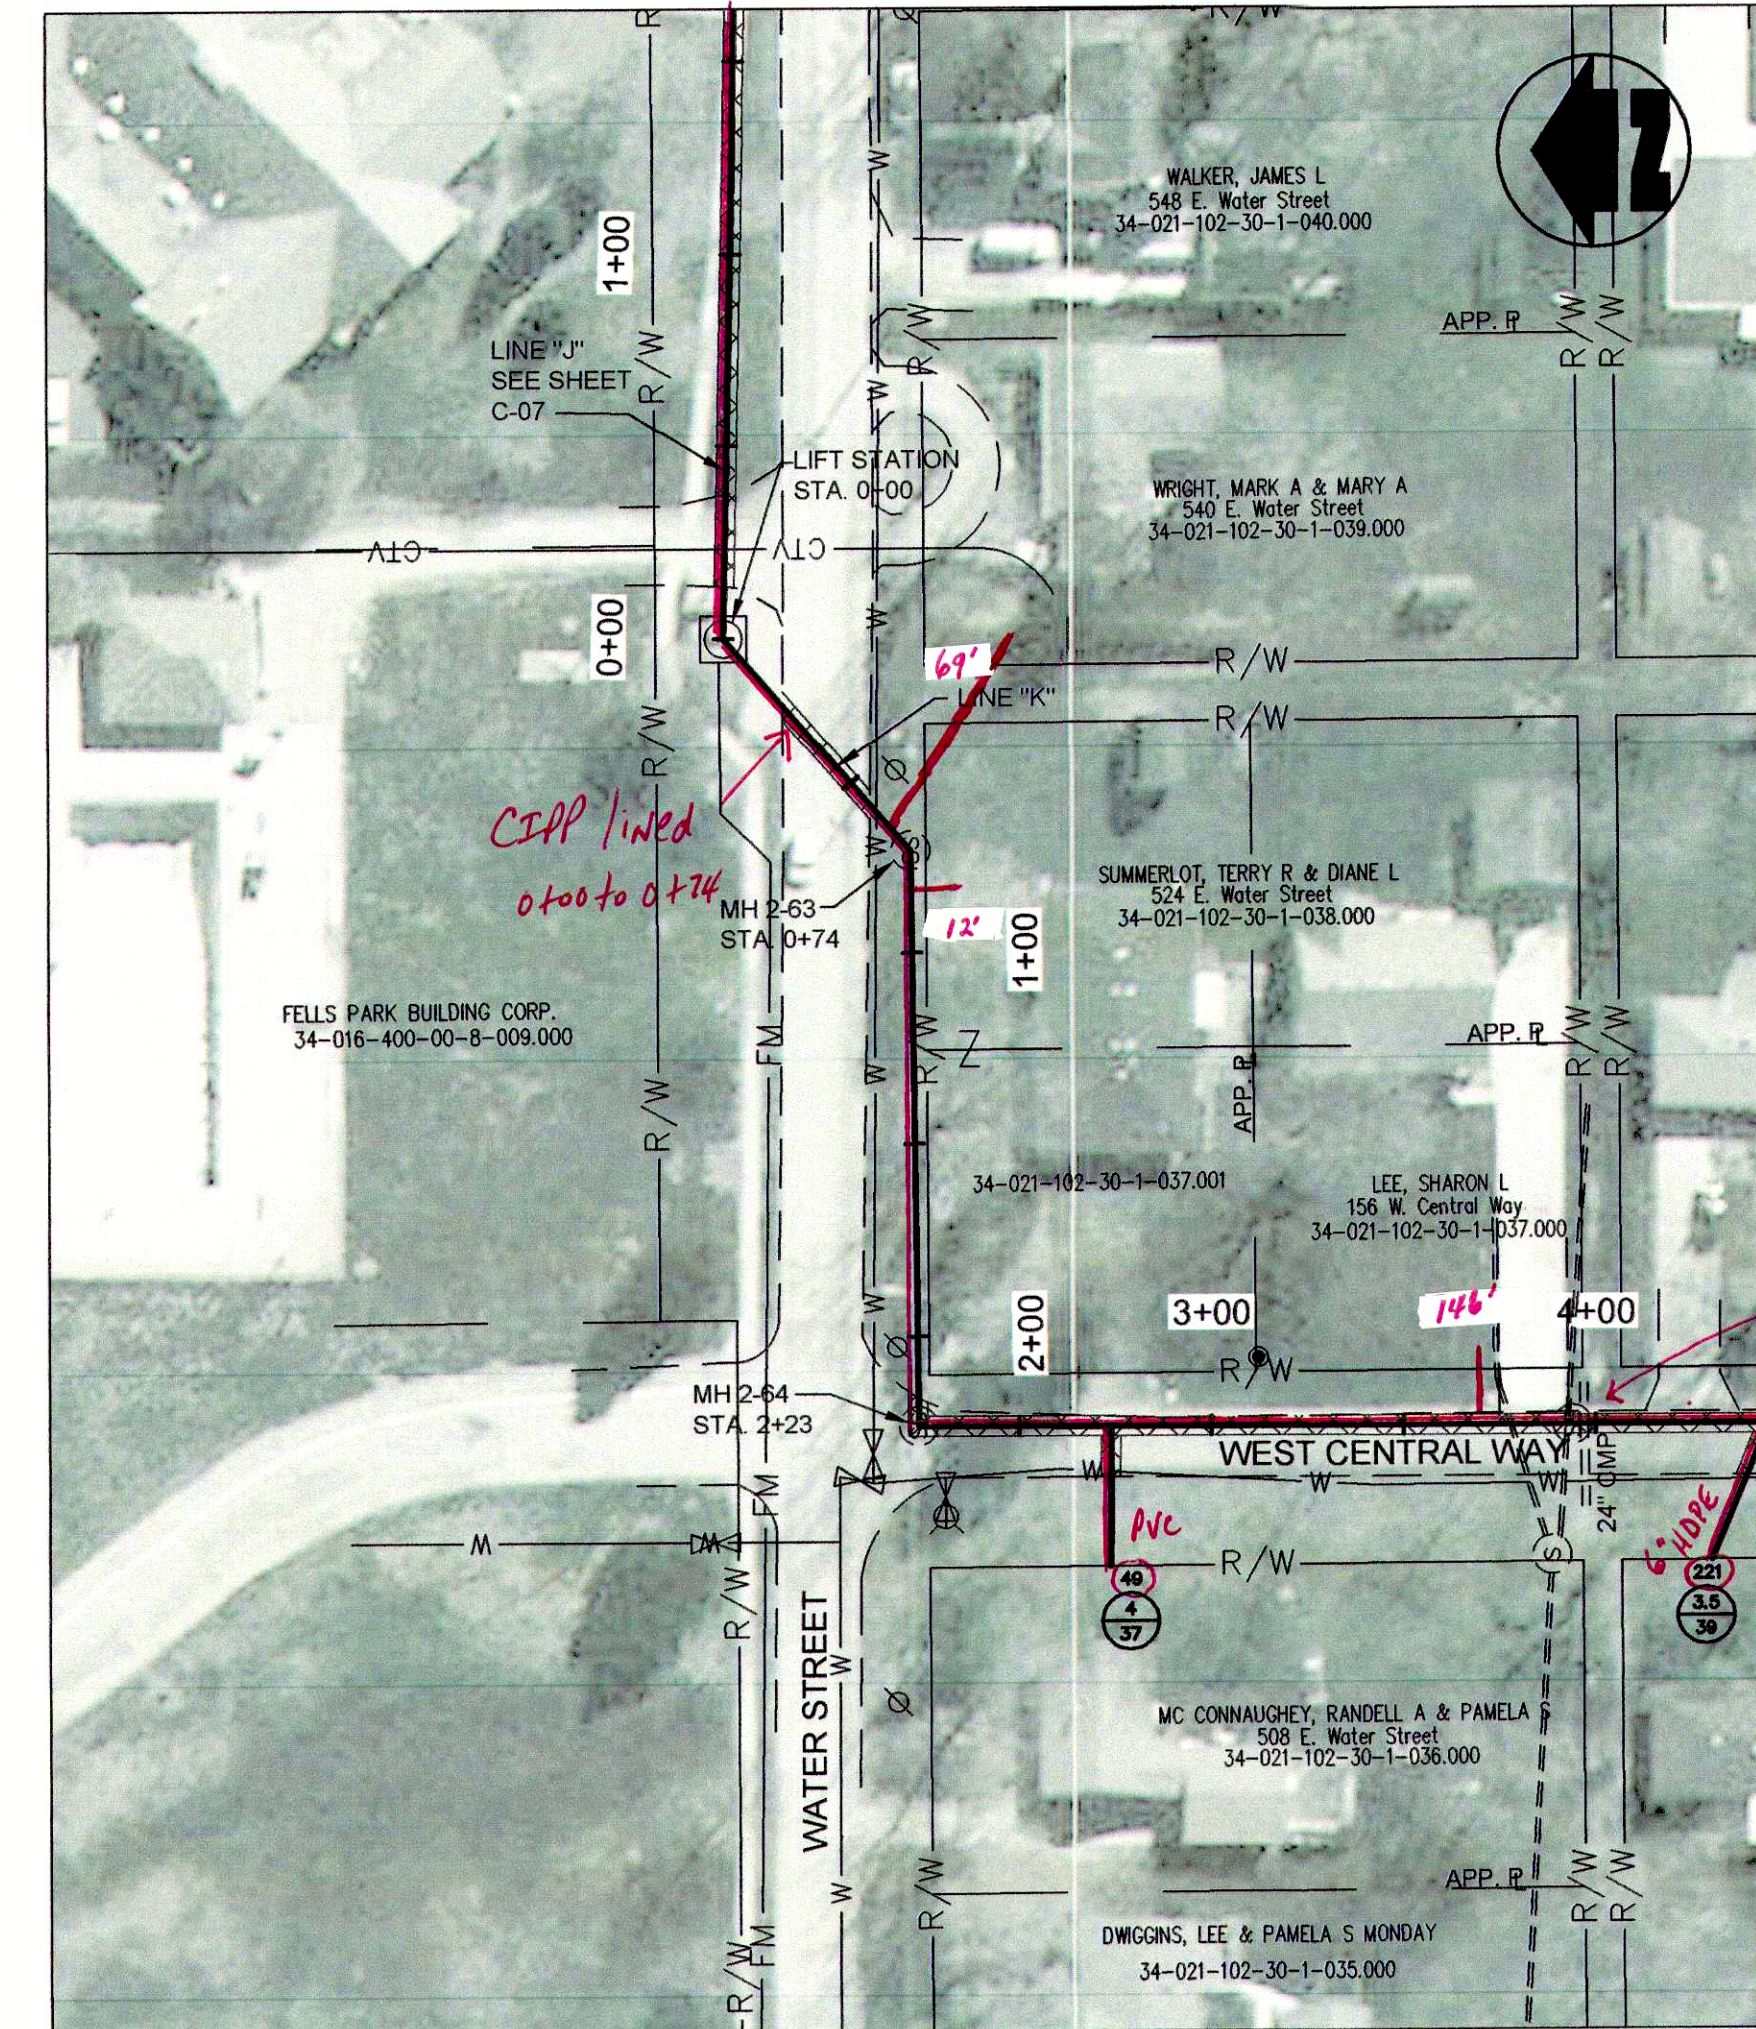

PLAN VIEW - STA. 0+00 TO STA. 4+50 LINE "K"

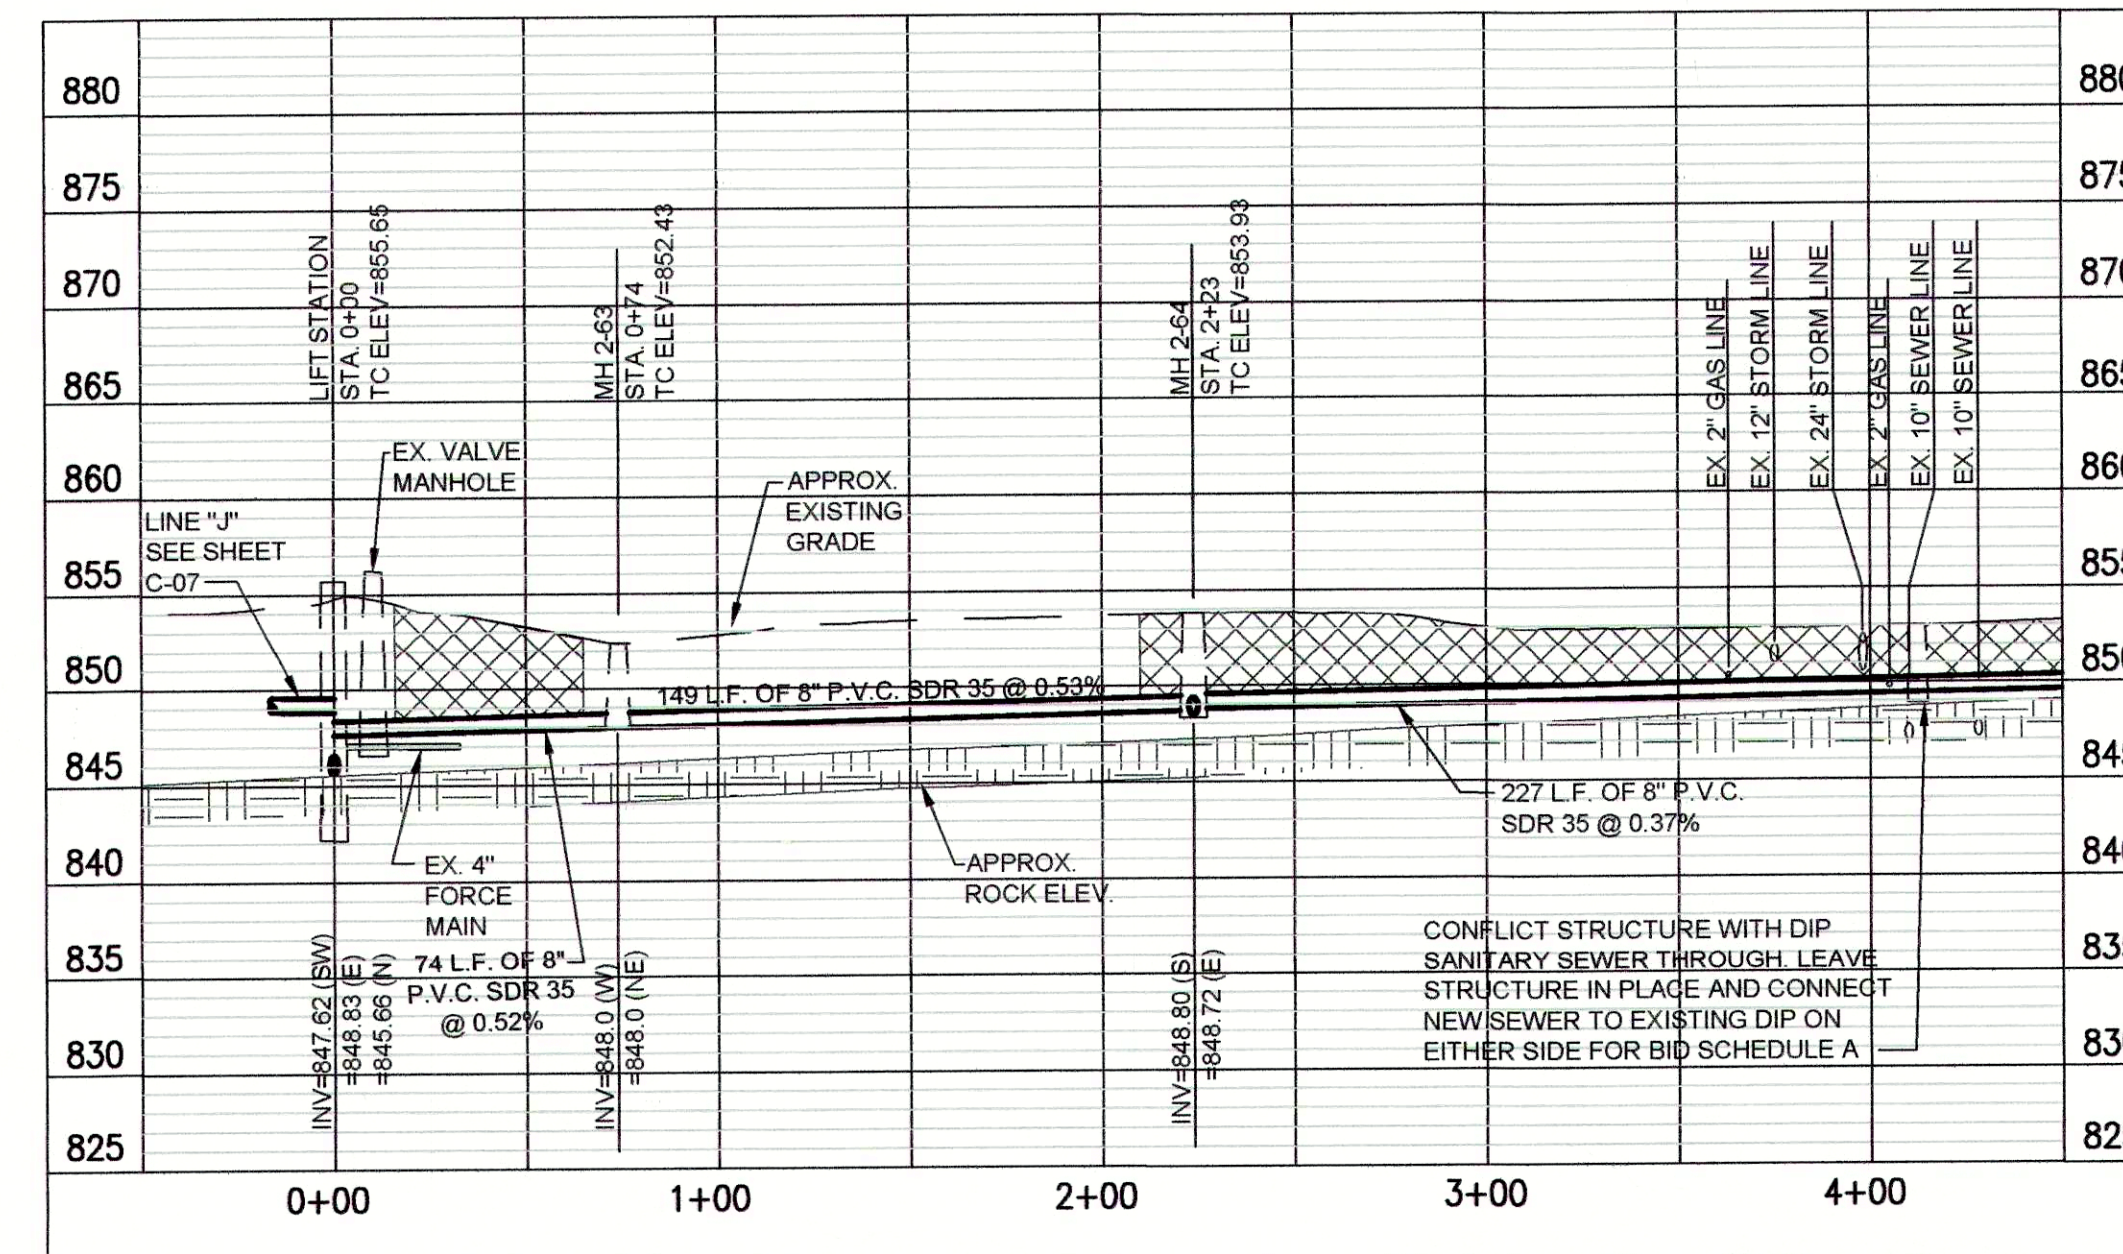

PROFILE - STA. 0+00 TO STA. 4+50 LINE "K"

"BID SCHEDULE B" (CIPP) NOTES:

1. LATERAL LOCATIONS SHOWN ARE BASED ON BEST AVAILABLE INFORMATION. CONTRACTOR TO FIELD VERIFY EXISTING SANITARY LATERAL LOCATIONS AND DEPTHS. FOR LATERAL REPLACEMENTS, MAKE CONNECTION DIRECTLY TO CIPP LINER AS SHOWN IN THE DETAILS AND ON SHEET C-16. INSTALL 6" SDR 35 SEWER PIPE FROM MAIN TO R/W LINE AND CONNECT TO EXISTING LATERAL.
2. IF THE PLANS SHOW C.I.P.P. LATERAL REHABILITATION, COMPLETE PER THE DETAIL ON SHEET C-16.
3. MANHOLE SHALL BE REHABILITATION PER THE MANHOLE REHABILITATION SCHEDULE.

GRW PROJECT NO. 4447-14

SRF NO. WW0074803




PLAN & PROFILE
SANITARY SEWER REHABILITATION
FALL CREEK REGIONAL WASTE DISTRICT
PENDLETON, INDIANA


DESIGNED	BY	DATE	GWL	DRAWN	GCR	REVIEWED	JPT	APPROVED	JPT
NO									

DATE: APRIL 2016
SCALE: H: 1"=50' V: 1"=10'
SHEET NO.

C-08

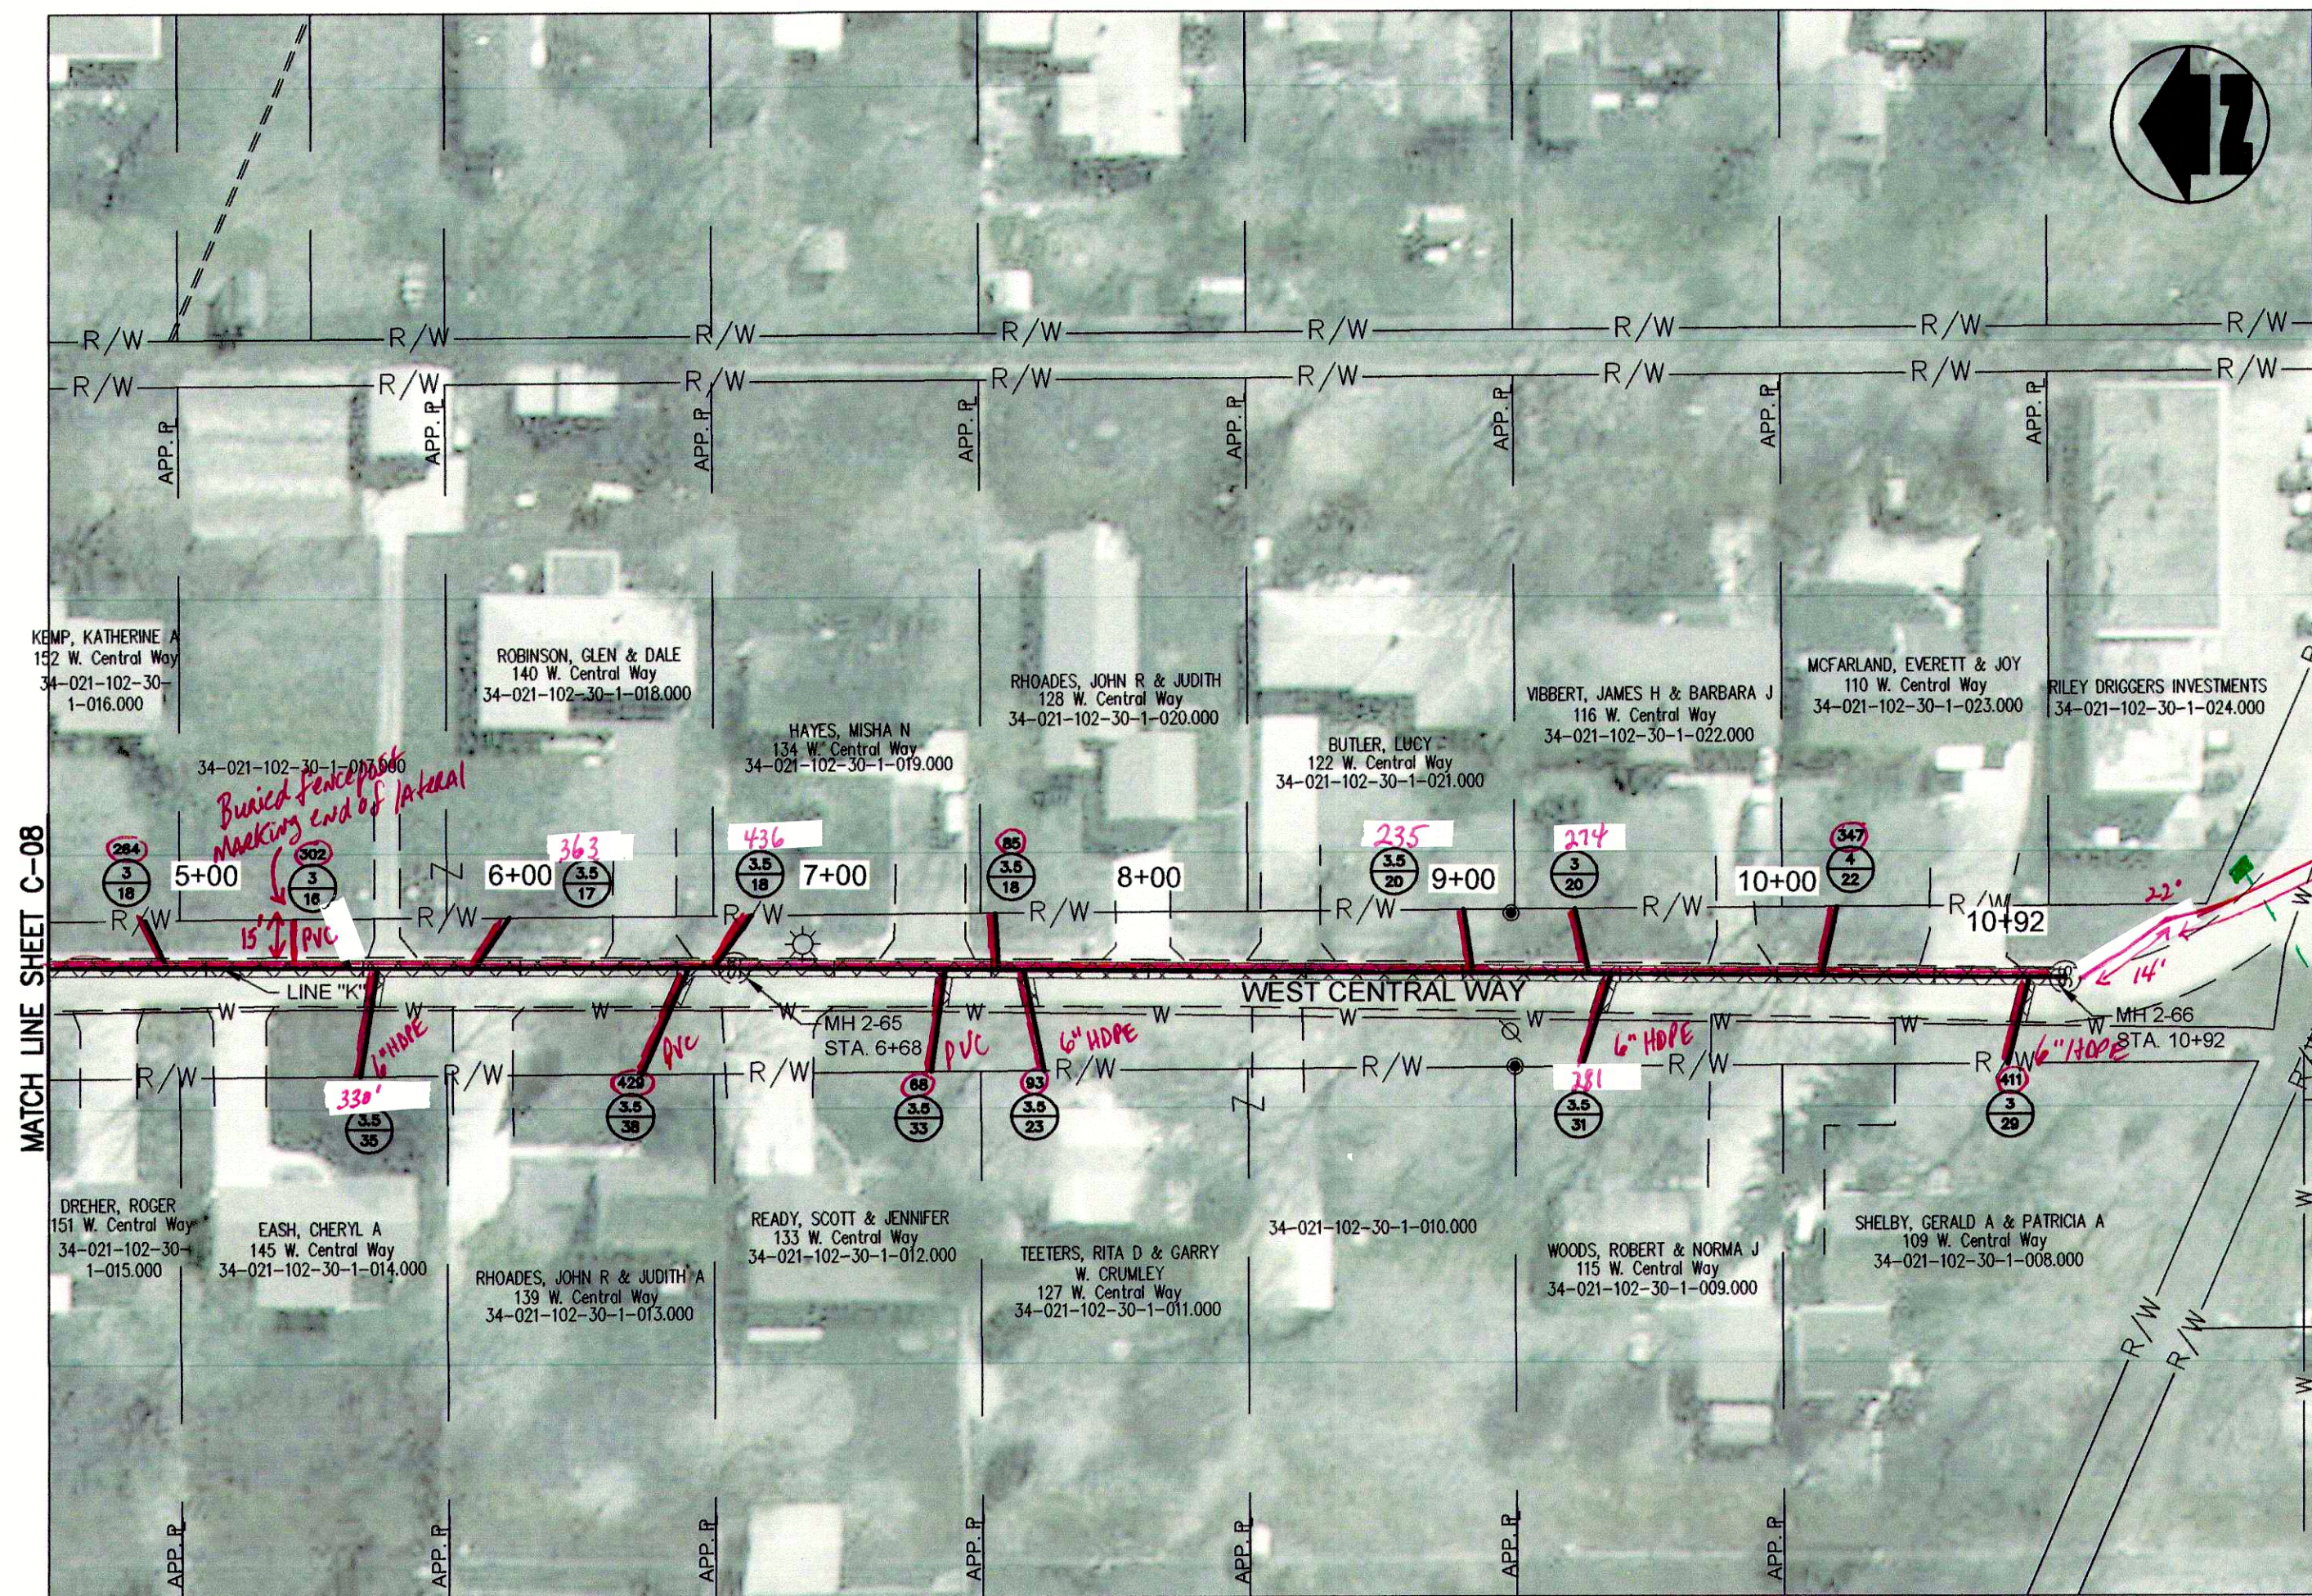

PLAN VIEW - STA. 4+50 TO STA. 10+92 LINE "K"

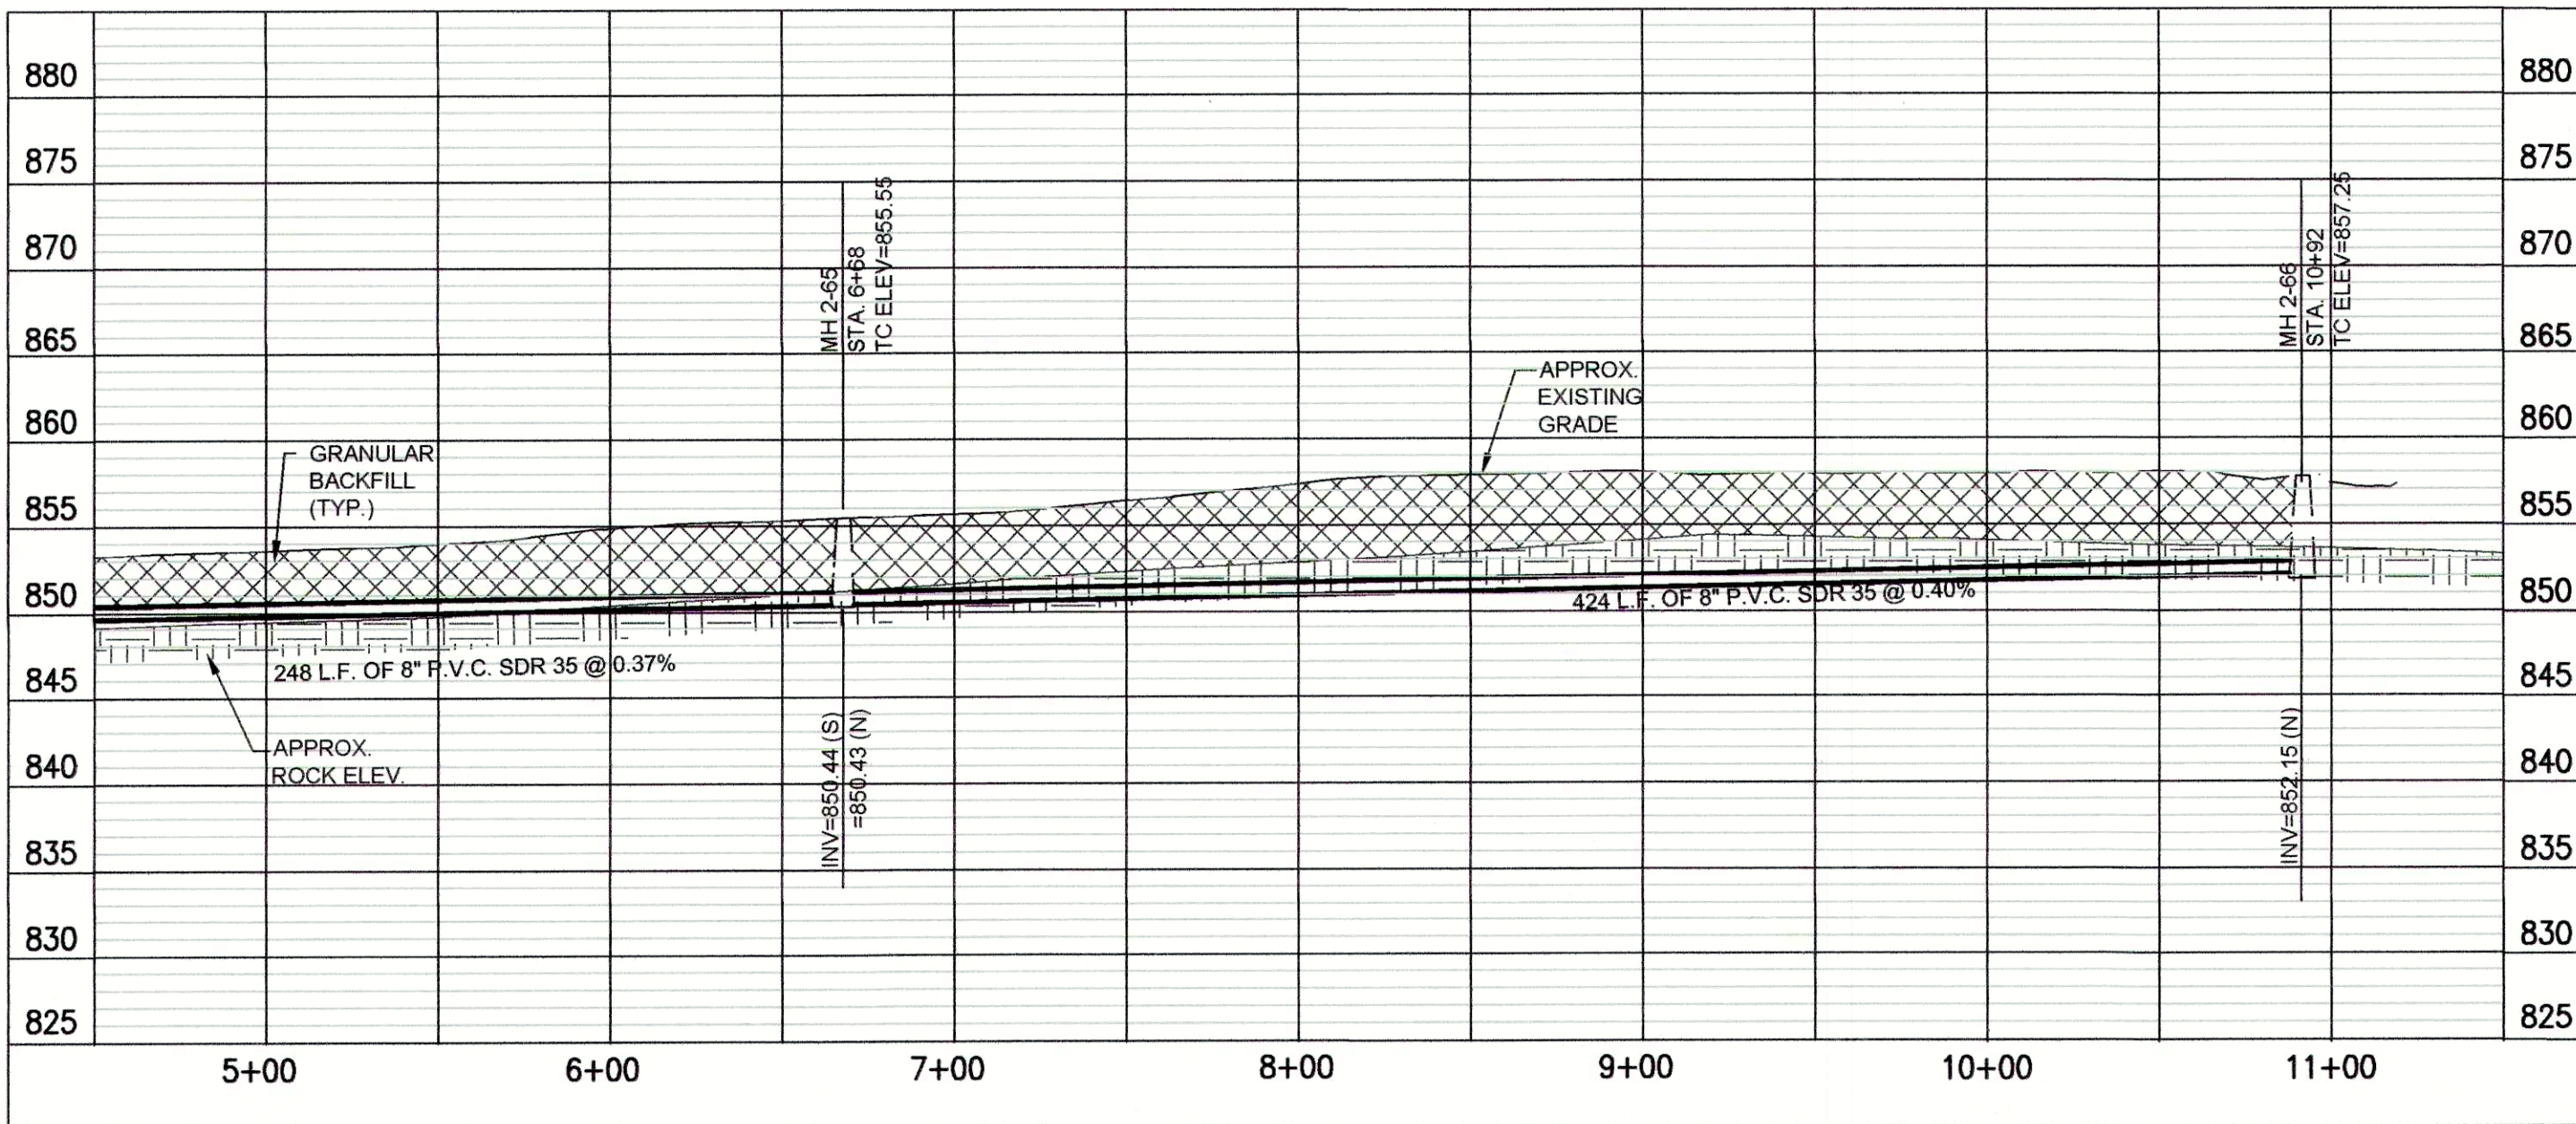


PROFILE - STA. 4+50 TO STA. 10+92 LINE "K"

"BID SCHEDULE A" (OPEN CUT) NOTES:


- LATERAL LOCATIONS SHOWN ARE BASED ON BEST AVAILABLE INFORMATION. CONTRACTOR TO FIELD VERIFY ALL EXISTING SANITARY LATERAL LOCATIONS AND DEPTHS. INSTALL 6" SDR 35 SEWER PIPE TO R/W LINE AND CONNECT TO EXISTING LATERAL.
- THE EXISTING MANHOLES ARE TO REMAIN IN PLACE WITH NEW SEWERS RECONNECTED. THE MANHOLES SHALL BE REHABILITATED PER THE MANHOLE REHABILITATION SCHEDULE.

BID SCHEDULES A & B NOTES:

 
- SANITARY LATERAL LEGEND:



A= DISTANCE FROM DOWN STREAM MANHOLE
X= APPROX. DEPTH AT R/W
Y= LENGTH FROM MAIN TO R/W

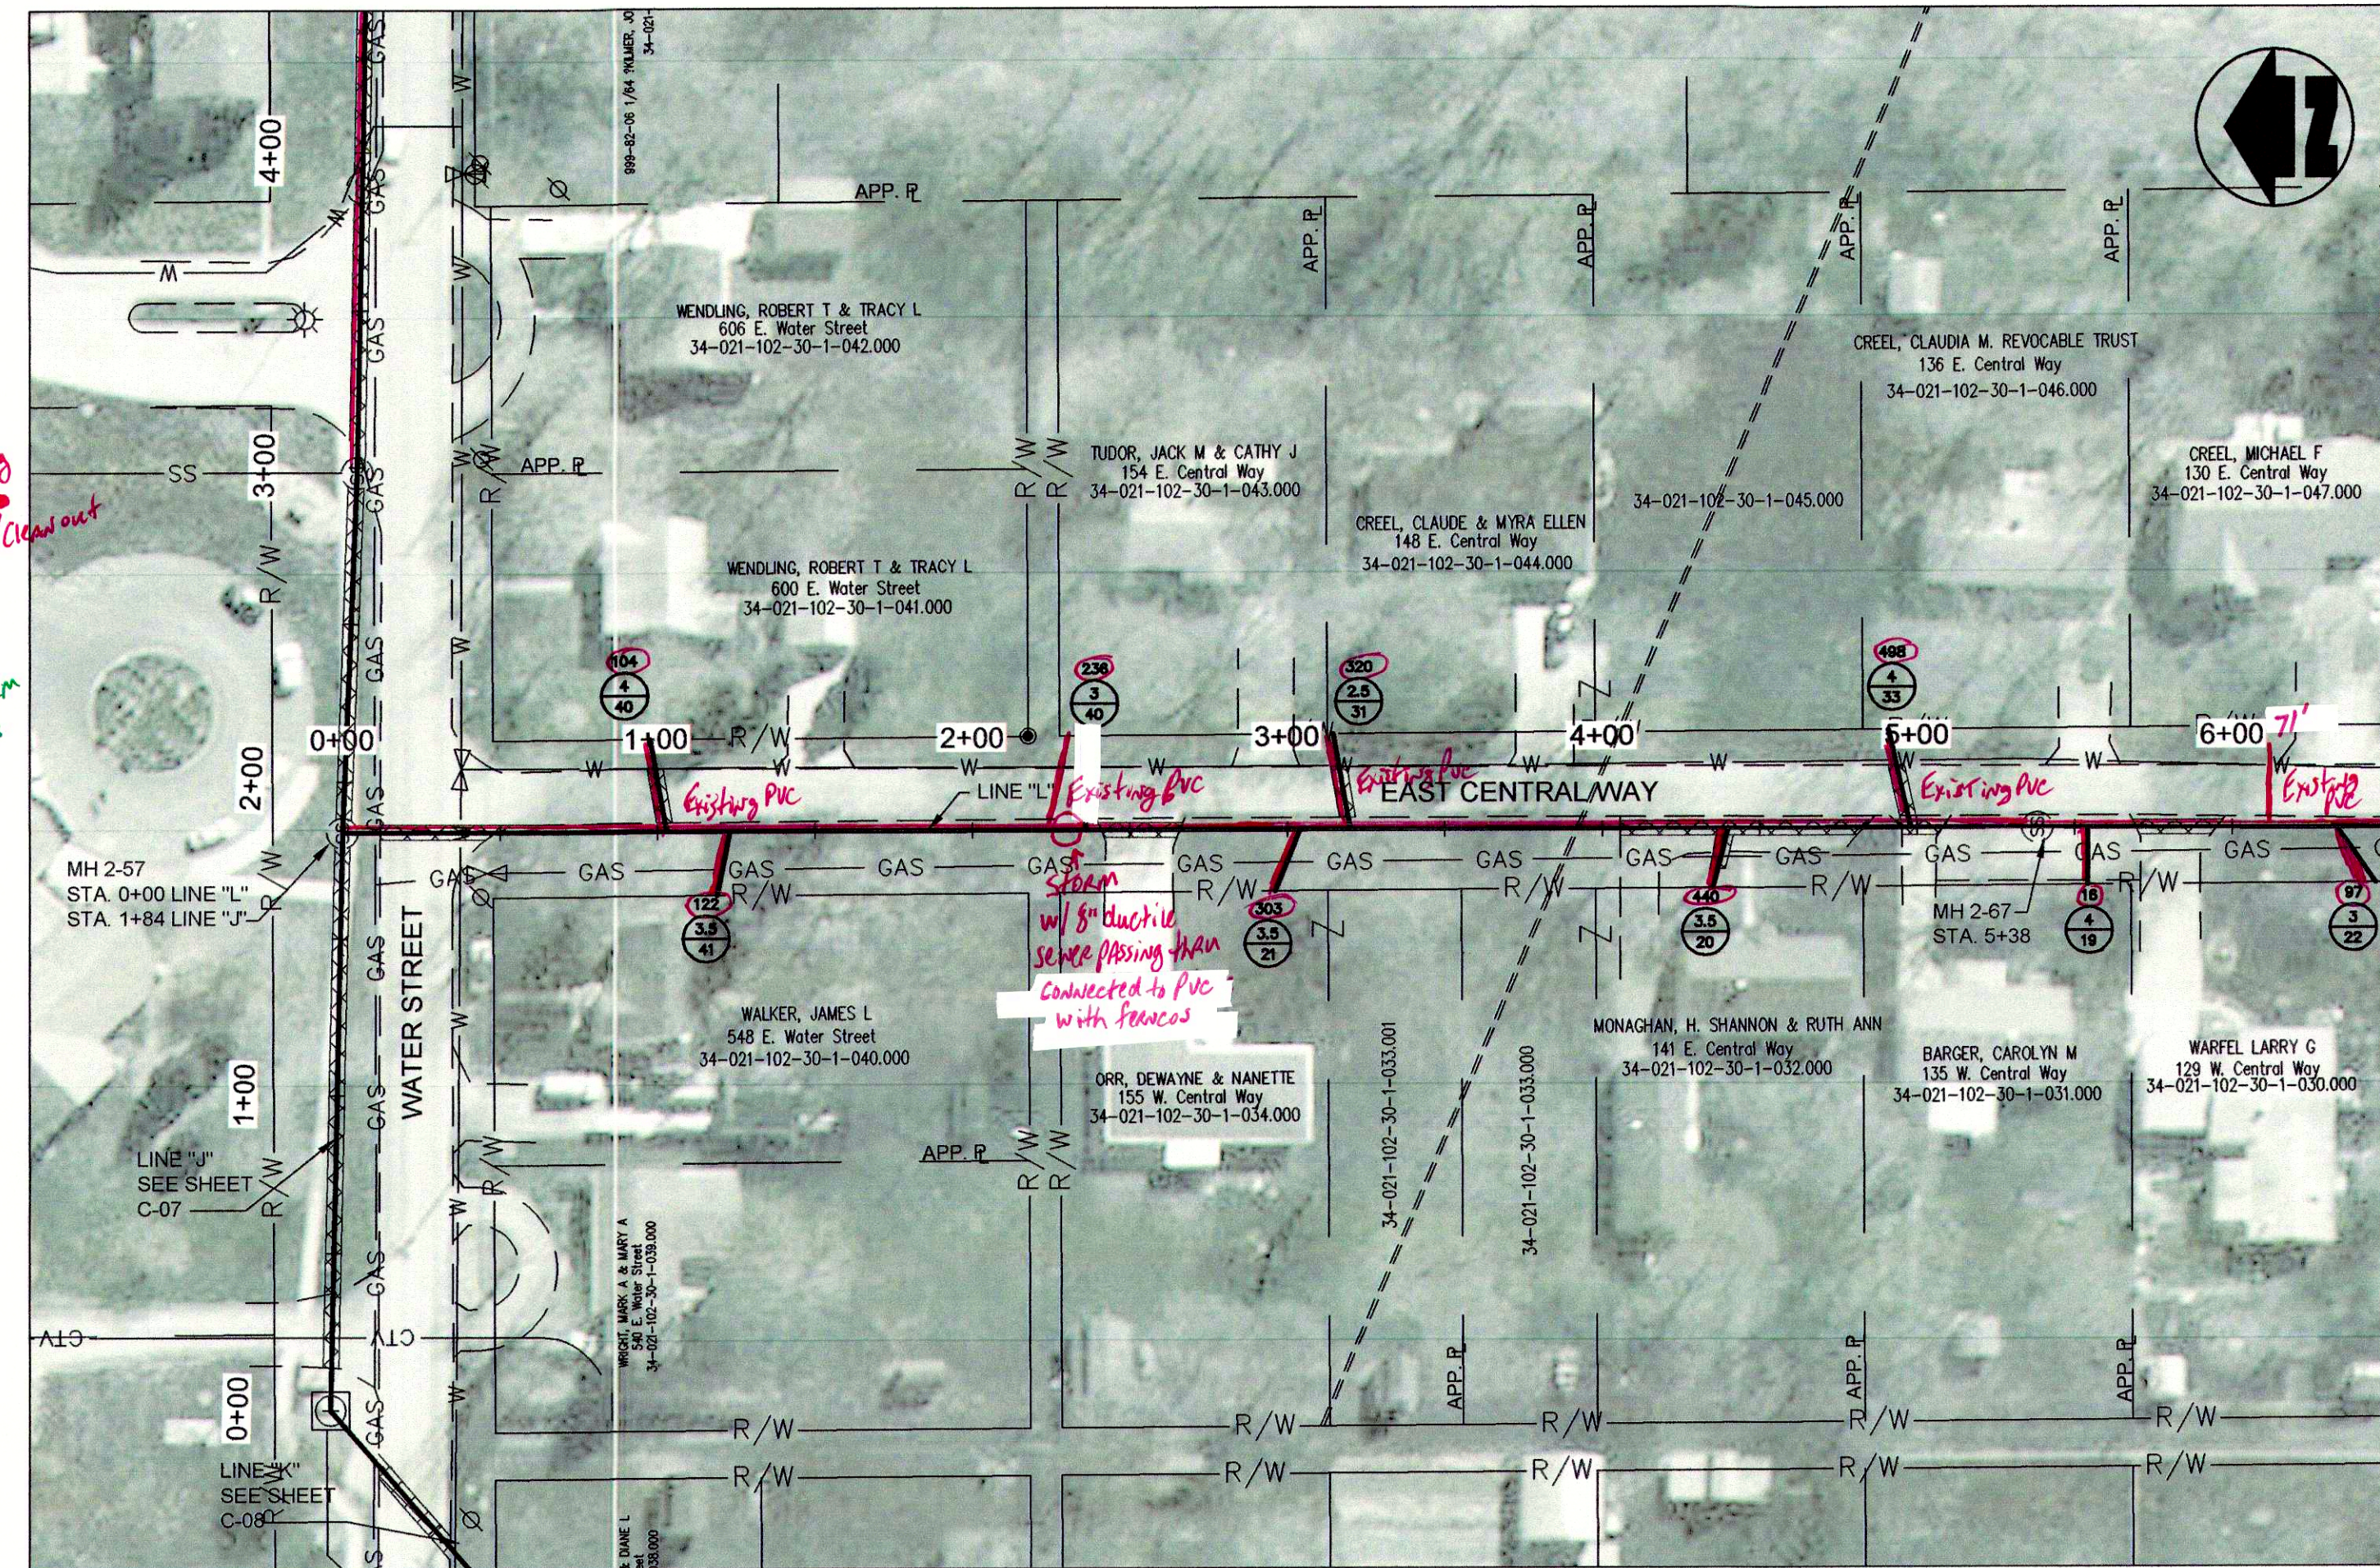

PLAN VIEW - STA. 0+00 TO STA. 6+50 LINE "L"

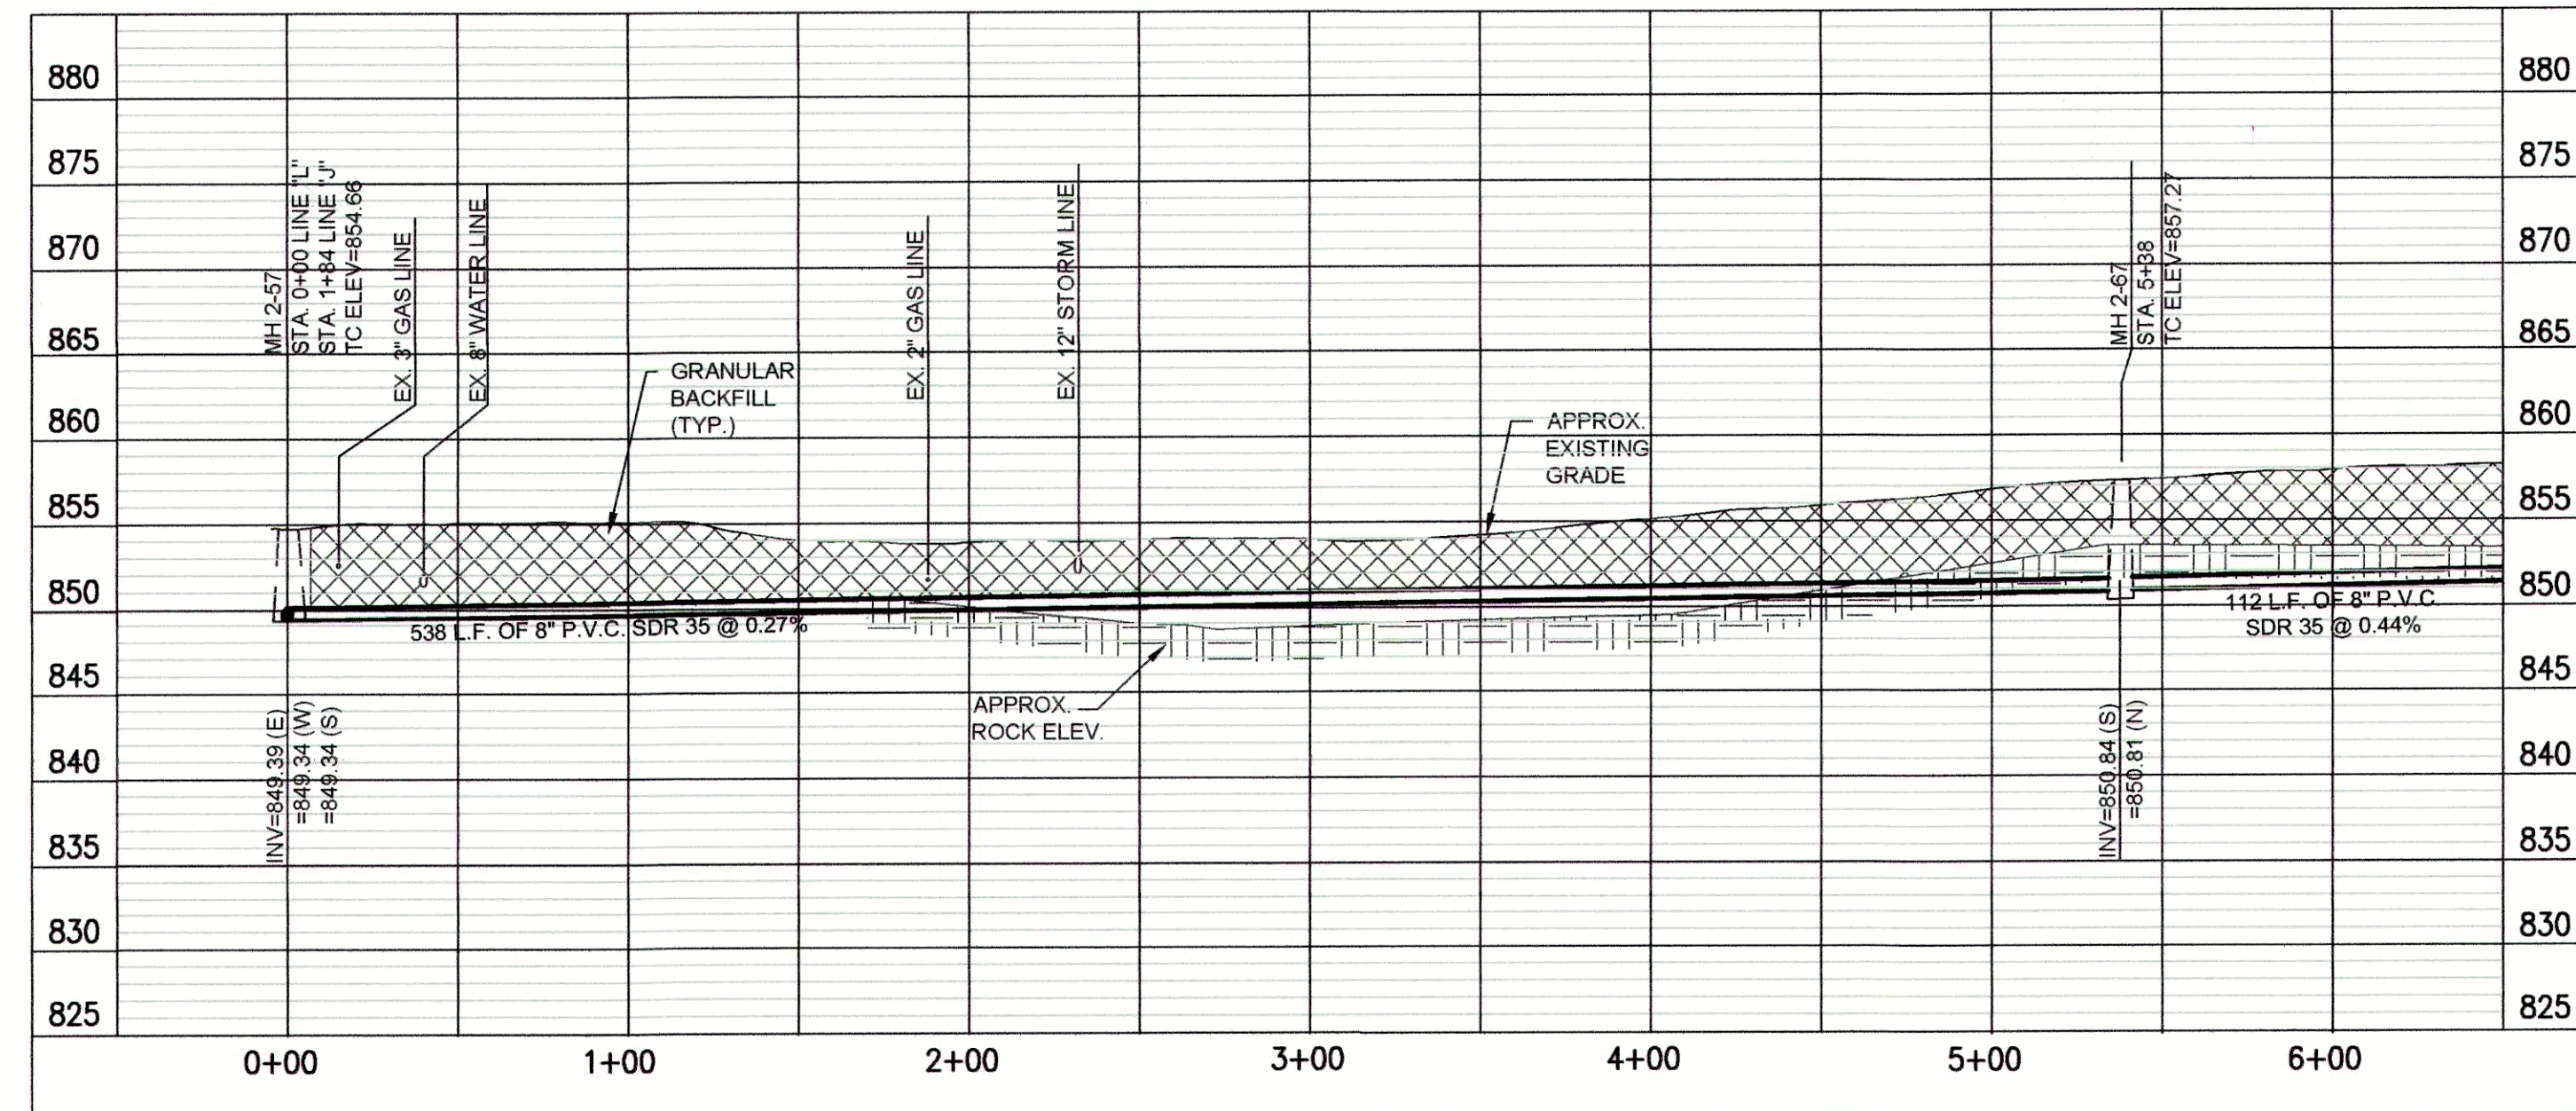

PROFILE - STA. 0+00 TO STA. 6+50 LINE "L"

"BID SCHEDULE B" (CIPP) NOTES:

- LATERAL LOCATIONS SHOWN ARE BASED ON BEST AVAILABLE INFORMATION. CONTRACTOR TO FIELD VERIFY EXISTING SANITARY LATERAL LOCATIONS AND DEPTHS. FOR LATERAL REPLACEMENTS, MAKE CONNECTION DIRECTLY TO CIPP LINER AS SHOWN IN THE DETAILS AND ON SHEET C-16. INSTALL 6" SDR 35 SEWER PIPE FROM MAIN TO R/W LINE AND CONNECT TO EXISTING LATERAL.
- IF THE PLANS SHOW C.I.P.P. LATERAL REHABILITATION, COMPLETE PER THE DETAIL ON SHEET C-16.
- MANHOLE SHALL BE REHABILITATION PER THE MANHOLE REHABILITATION SCHEDULE.

JOSEPH P. TIERNEY
REGISTERED
No. 19300407
STATE OF INDIANA
PROFESSIONAL ENGINEER

GRW PROJECT NO. 4447-14
SRF NO. WW16074803


GR2
engineering | architecture | geospatial
www.grwinc.com

PLAN & PROFILE
SANITARY SEWER REHABILITATION
FALL CREEK REGIONAL WASTE DISTRICT
PENDLETON, INDIANA

REVISIONS	DATE	BY	DESCRIPTION


DESIGNED	GWL	DRAWN	GCR	REVIEWED	JPT	APPROVED	JPT

DATE: APRIL 2016
SCALE: H: 1"=50' V: 1"=10'
SHEET NO. **C-09**

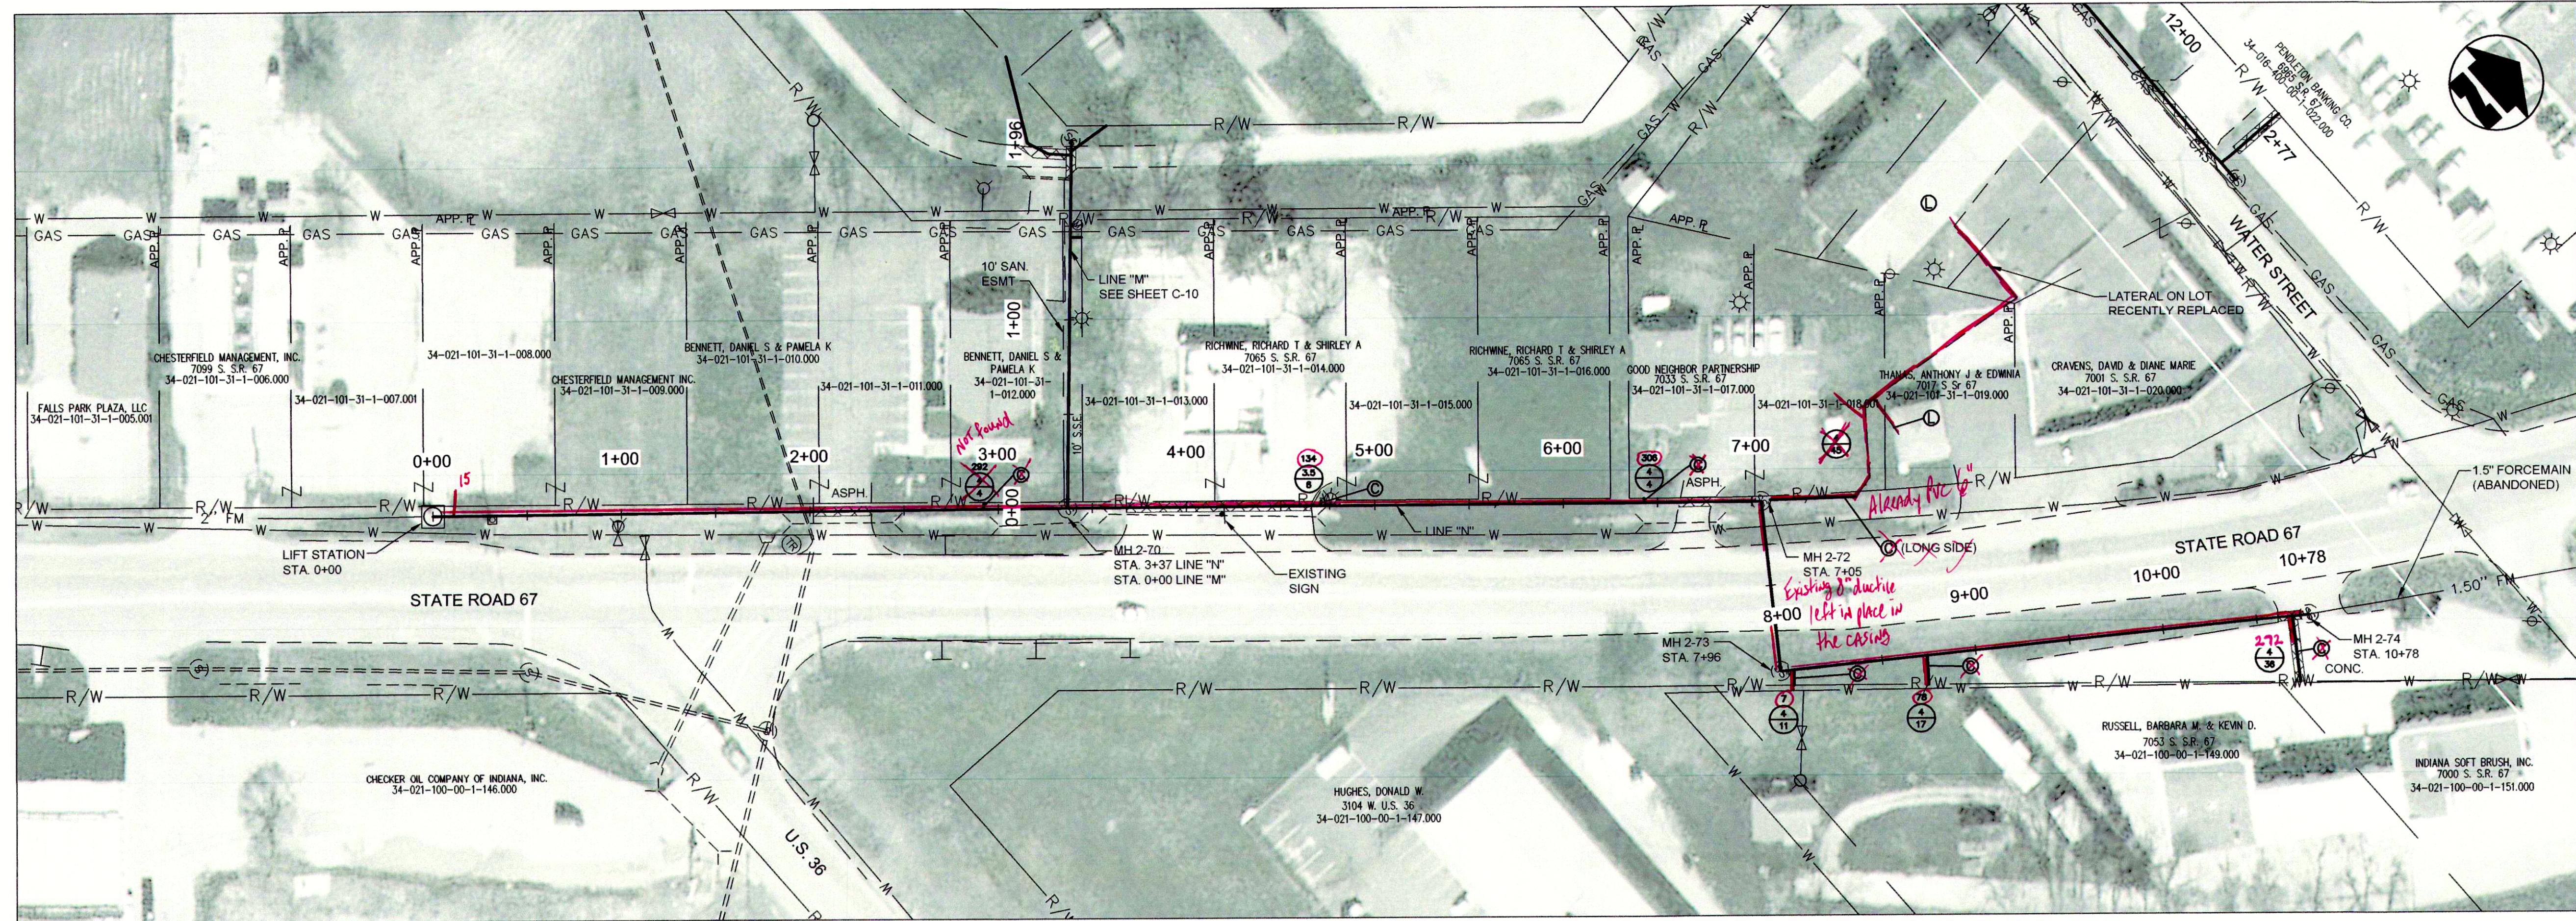

PLAN VIEW - STA. 0+00 TO STA. 10+78 LINE "N"

- ① PRIVATE LATERALS TO BE REPLACED.
SEE WORK DESCRIPTION IN MEASUREMENTS AND PAYMENT.
- ② LATERAL TO BE CIPP LINED -
BID SCHEDULE B ONLY

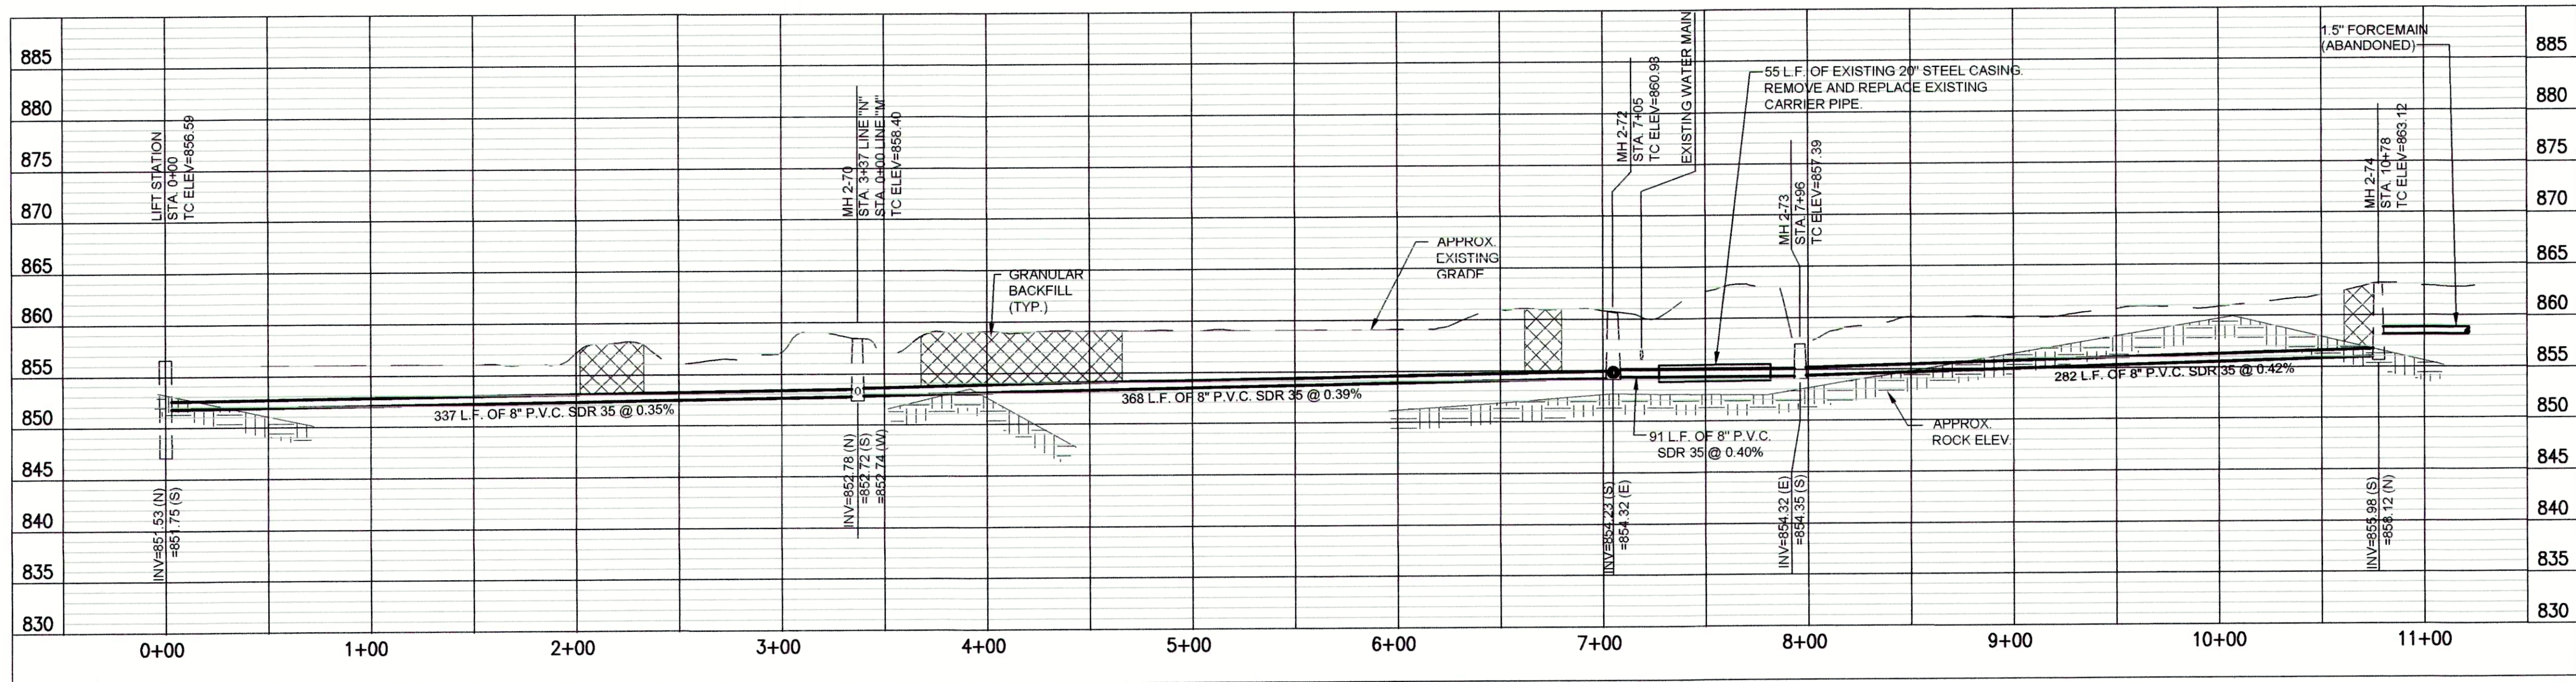

PROFILE - STA. 0+00 TO STA. 10+78 LINE "N"

NOTE:
THE PRIVATE LATERAL REPLACEMENT WORK ON THIS SHEET
SHALL BE INCLUDED IN ADDITIVE ALTERNATE NO.2.

"BID SCHEDULE A" (OPEN CUT) NOTES:

- LATERAL LOCATIONS SHOWN ARE BASED ON BEST AVAILABLE INFORMATION. CONTRACTOR TO FIELD VERIFY ALL EXISTING SANITARY LATERAL LOCATIONS AND DEPTHS, INSTALL 6" SDR 35 SEWER PIPE TO R/W LINE AND CONNECT TO EXISTING LATERAL.
- THE EXISTING MANHOLES ARE TO REMAIN IN PLACE WITH NEW SEWERS RECONNECTED. THE MANHOLES SHALL BE REHABILITATED PER THE MANHOLE REHABILITATION SCHEDULE.


BID SCHEDULES A & B NOTES:

- SANITARY LATERAL LEGEND:

A= DISTANCE FROM DOWN STREAM MANHOLE
X= APPROX. DEPTH AT R/W
Y= LENGTH FROM MAIN TO R/W

"BID SCHEDULE B" (CIPP) NOTES:

- LATERAL LOCATIONS SHOWN ARE BASED ON BEST AVAILABLE INFORMATION. CONTRACTOR TO FIELD VERIFY EXISTING SANITARY LATERAL LOCATIONS AND DEPTHS, FOR LATERAL REPLACEMENTS, MAKE CONNECTION DIRECTLY TO CIPP LINER AS SHOWN IN THE DETAILS AND ON SHEET C-16. INSTALL 6" SDR 35 SEWER PIPE FROM MAIN TO R/W LINE AND CONNECT TO EXISTING LATERAL.
- IF THE PLANS SHOW C.I.P.P. LATERAL REHABILITATION, COMPLETE PER THE DETAIL ON SHEET C-16.
- MANHOLE SHALL BE REHABILITATION PER THE MANHOLE REHABILITATION SCHEDULE.

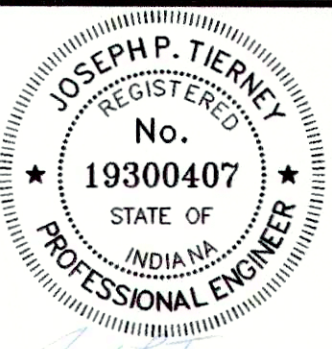

GRW PROJECT NO. 4447-14
SRF NO. WW16074803 ----
ALL RIGHTS RESERVED. NO PART OF THIS DOCUMENT SHALL BE REPRODUCED OR TRANSMITTED IN ANY FORM OR BY ANY MEANS, ELECTRONIC OR MECHANICAL, WITHOUT PERMISSION IN WRITING FROM GRW INC.



**PLAN & PROFILE
SANITARY SEWER REHABILITATION
FALL CREEK REGIONAL WASTE DISTRICT
PENDLETON, INDIANA**


DESIGNED	GWL	GCR	JPT	JPT
NO.	BY	DATE	DATE	DATE
1	---	---	---	---
2	---	---	---	---
3	---	---	---	---
4	---	---	---	---
5	---	---	---	---
6	---	---	---	---
7	---	---	---	---
8	---	---	---	---
9	---	---	---	---
10	---	---	---	---
11	---	---	---	---
12	---	---	---	---
13	---	---	---	---
14	---	---	---	---
15	---	---	---	---
16	---	---	---	---
17	---	---	---	---
18	---	---	---	---
19	---	---	---	---
20	---	---	---	---

DATE: APRIL 2016


SCALE: H: 1"=50' V: 1"=10'

SHEET NO.

C-11

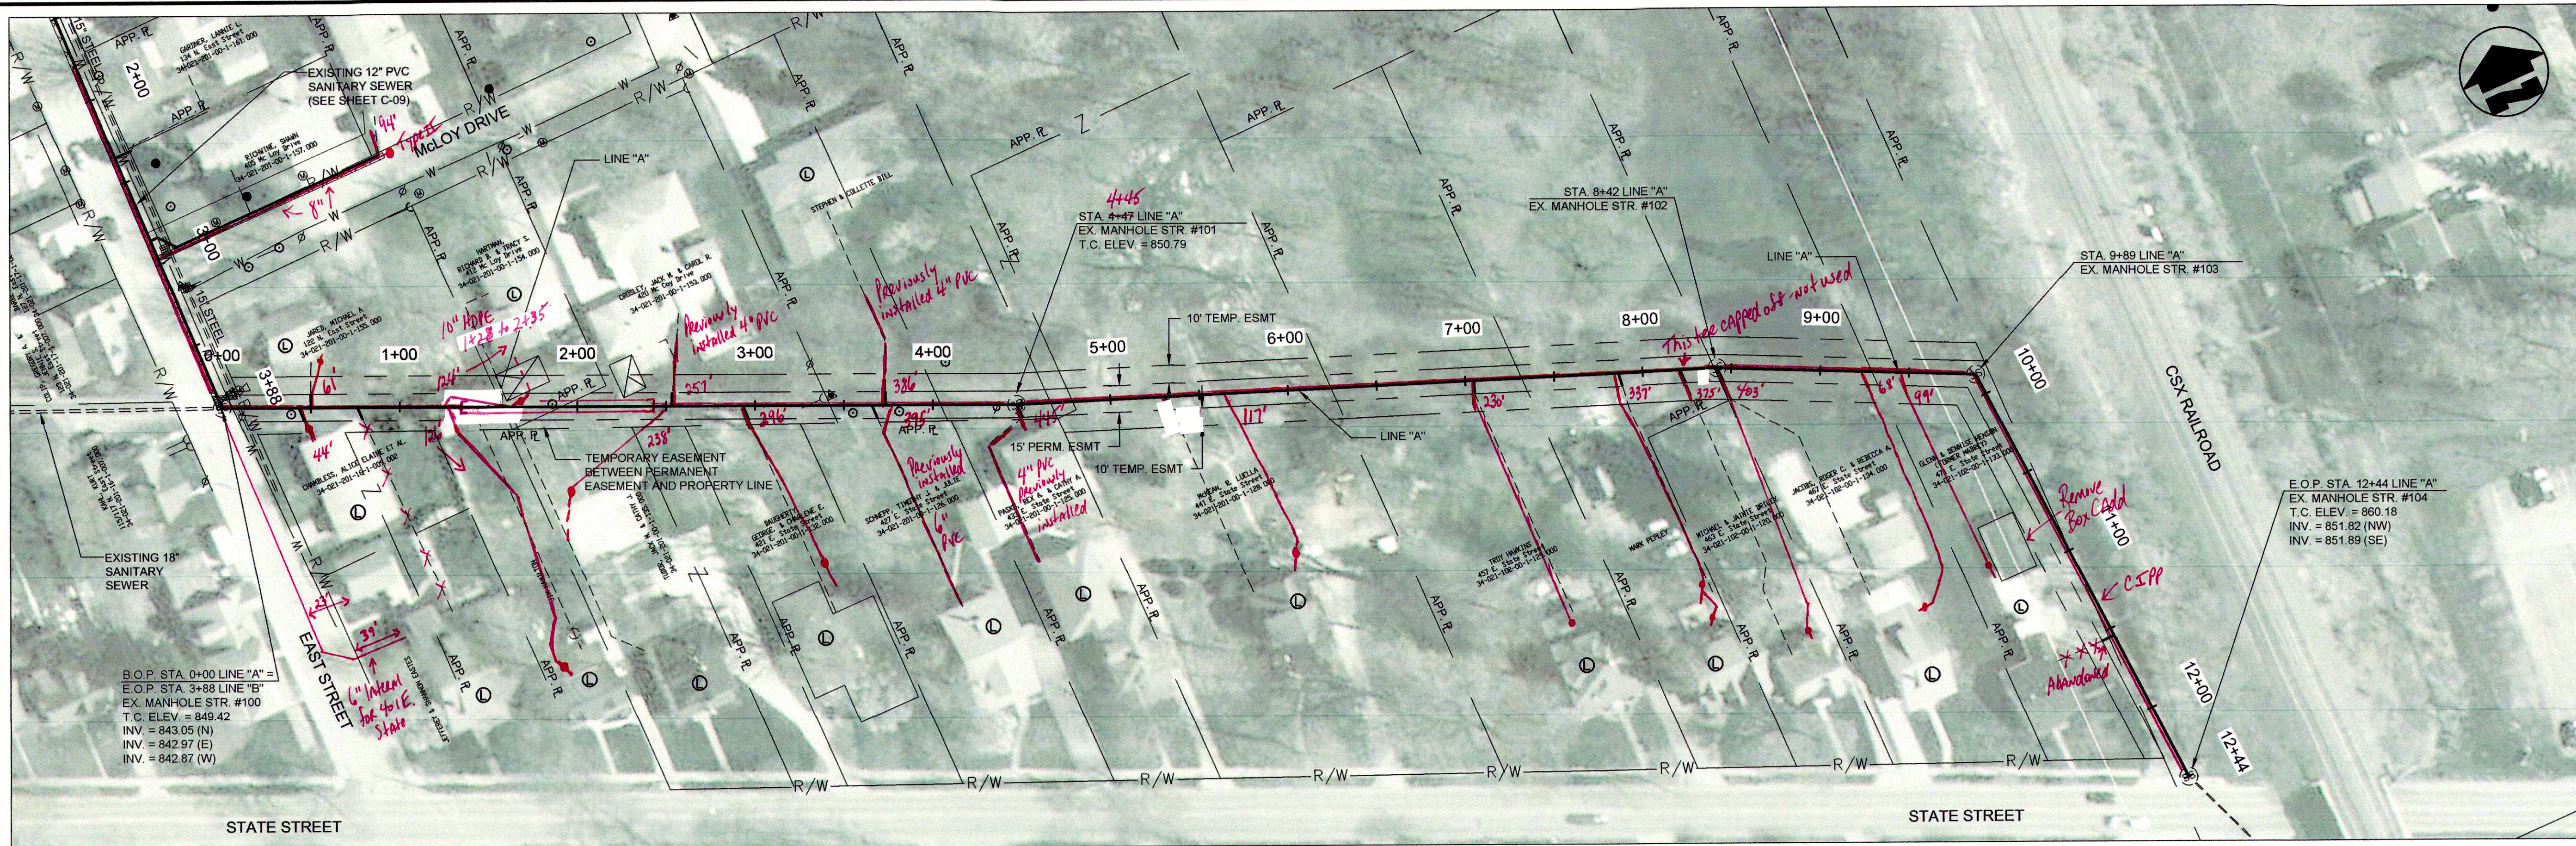

PLAN VIEW - B.O.P. STA. 0+00 TO E.O.P. STA. 12+44 LINE "A"

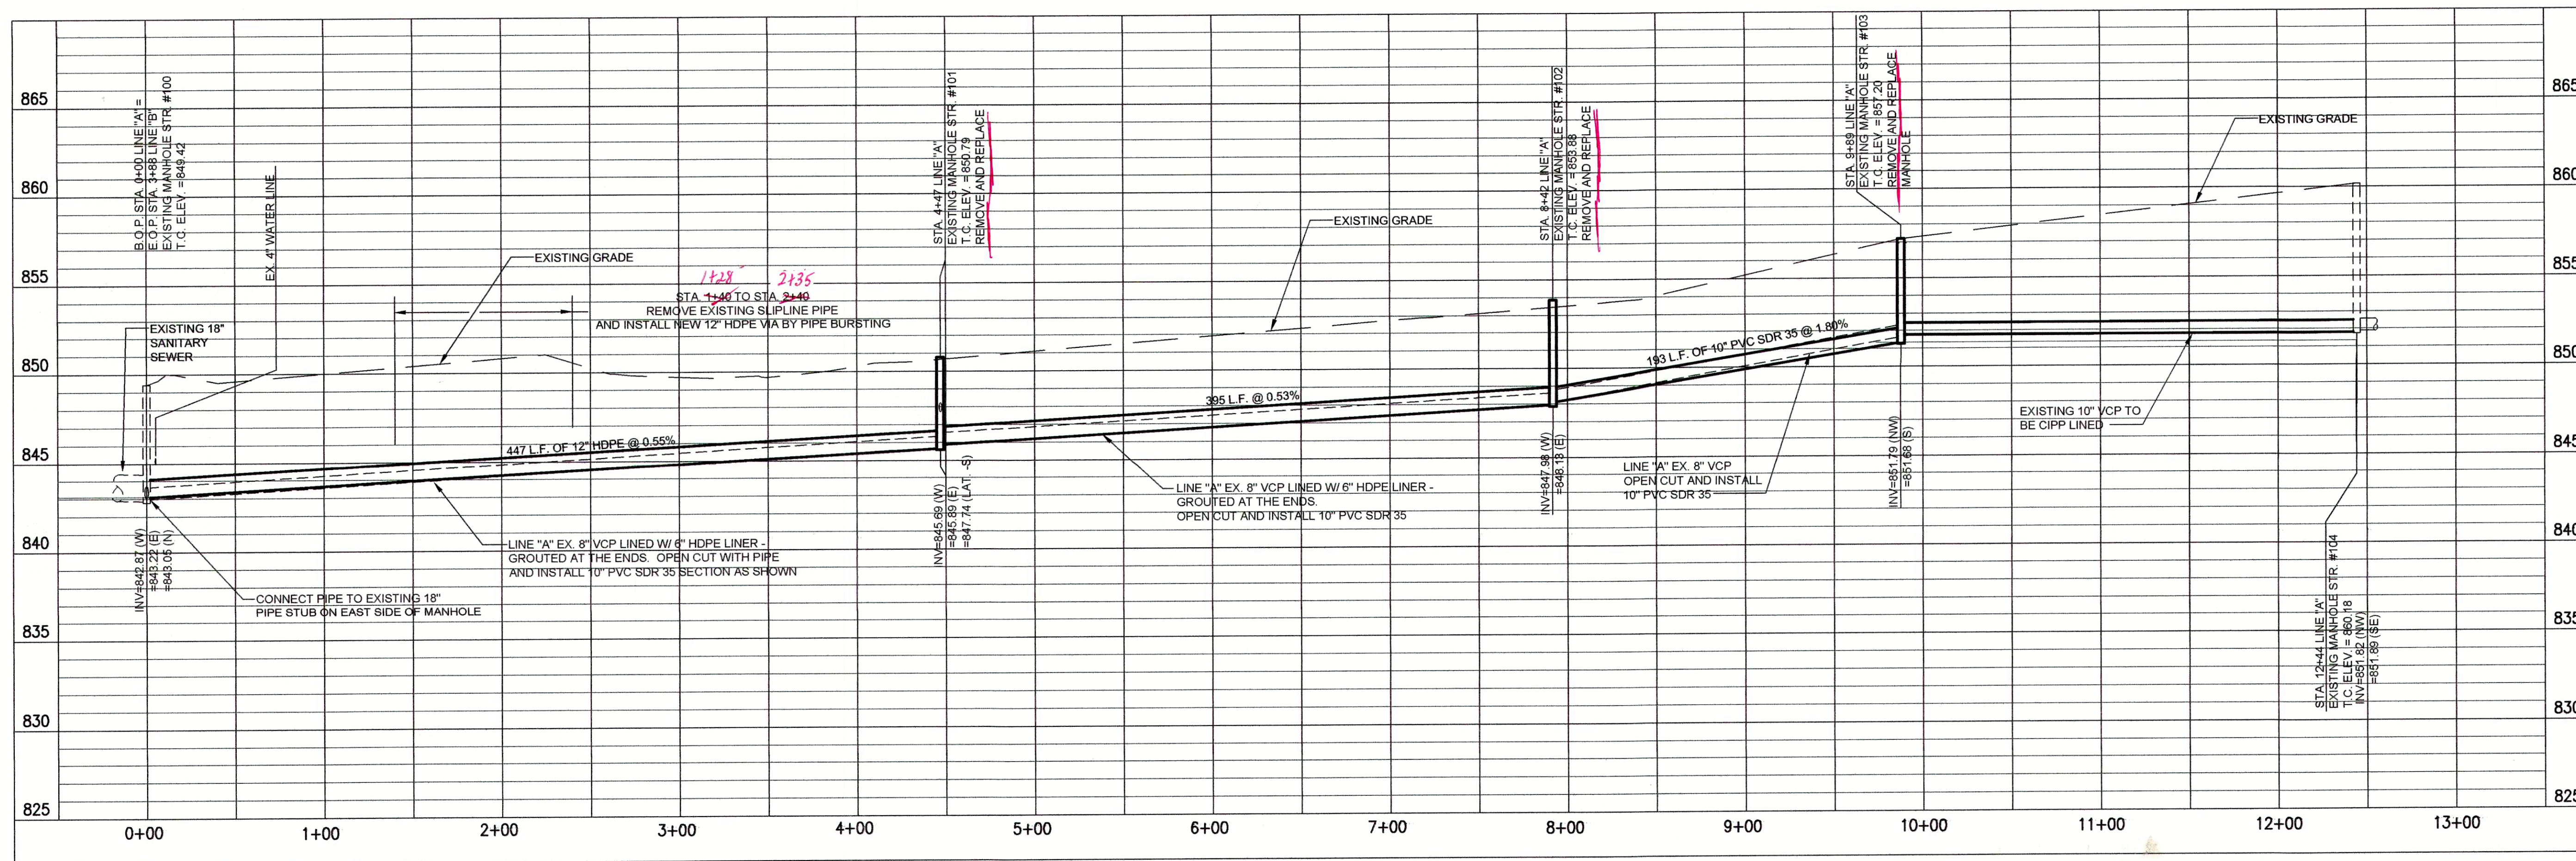

PROFILE - B.O.P. STA. 0+00 TO E.O.P. STA. 12+44 LINE "A"

① PRIVATE LATERALS TO BE REPLACED.
SEE WORK DESCRIPTION IN MEASUREMENT
AND PAYMENT SPECIFICATION.

NOTE:
1. THE WORK ON THIS SHEET TO REPLACE THE MAIN AND RECONNECT TO THE LATERALS WITHIN PERMANENT EASEMENT SHALL BE INCLUDED IN ADDITIVE ALTERNATE NO. 1.
2. THE WORK TO REPLACE THE PRIVATE LATERALS SHALL BE INCLUDED IN ADDITIVE ALTERNATE NO. 2
3. LATERAL LOCATIONS SHOWN ARE BASED ON BEST AVAILABLE INFORMATION. CONTRACTOR SHALL FIELD VERIFY EXISTING LATERAL LOCATIONS AND DEPTHS.

JOSEPH P. TIERNEY
REGISTERED
No. 19300407
STATE OF INDIANA
PROFESSIONAL ENGINEER

GRW PROJECT NO. 4447-14
SPE NO. WW16074803

engineering | architecture | geospatial
www.grwinc.com

PLAN & PROFILE
SANITARY SEWER REHABILITATION
FALL CREEK REGIONAL WASTE DISTRICT
PENDLETON, INDIANA

DESIGNED	GWL	DATE	BY

DRAWN	GCR	DATE	BY

REVIEWED	JPT	DATE	BY

APPROVED	JPT	DATE	BY

REVISIONS

NO.	DESCRIPTION	DATE	BY


SCALE CHECK: THIS MARK SHOULD MEASURE EXACTLY 1" WHEN PLOTTED

DATE:
APRIL 2016


SCALE:
H: 1"=50' V: 1"=10'

SHEET NO.
C-12

BID SET

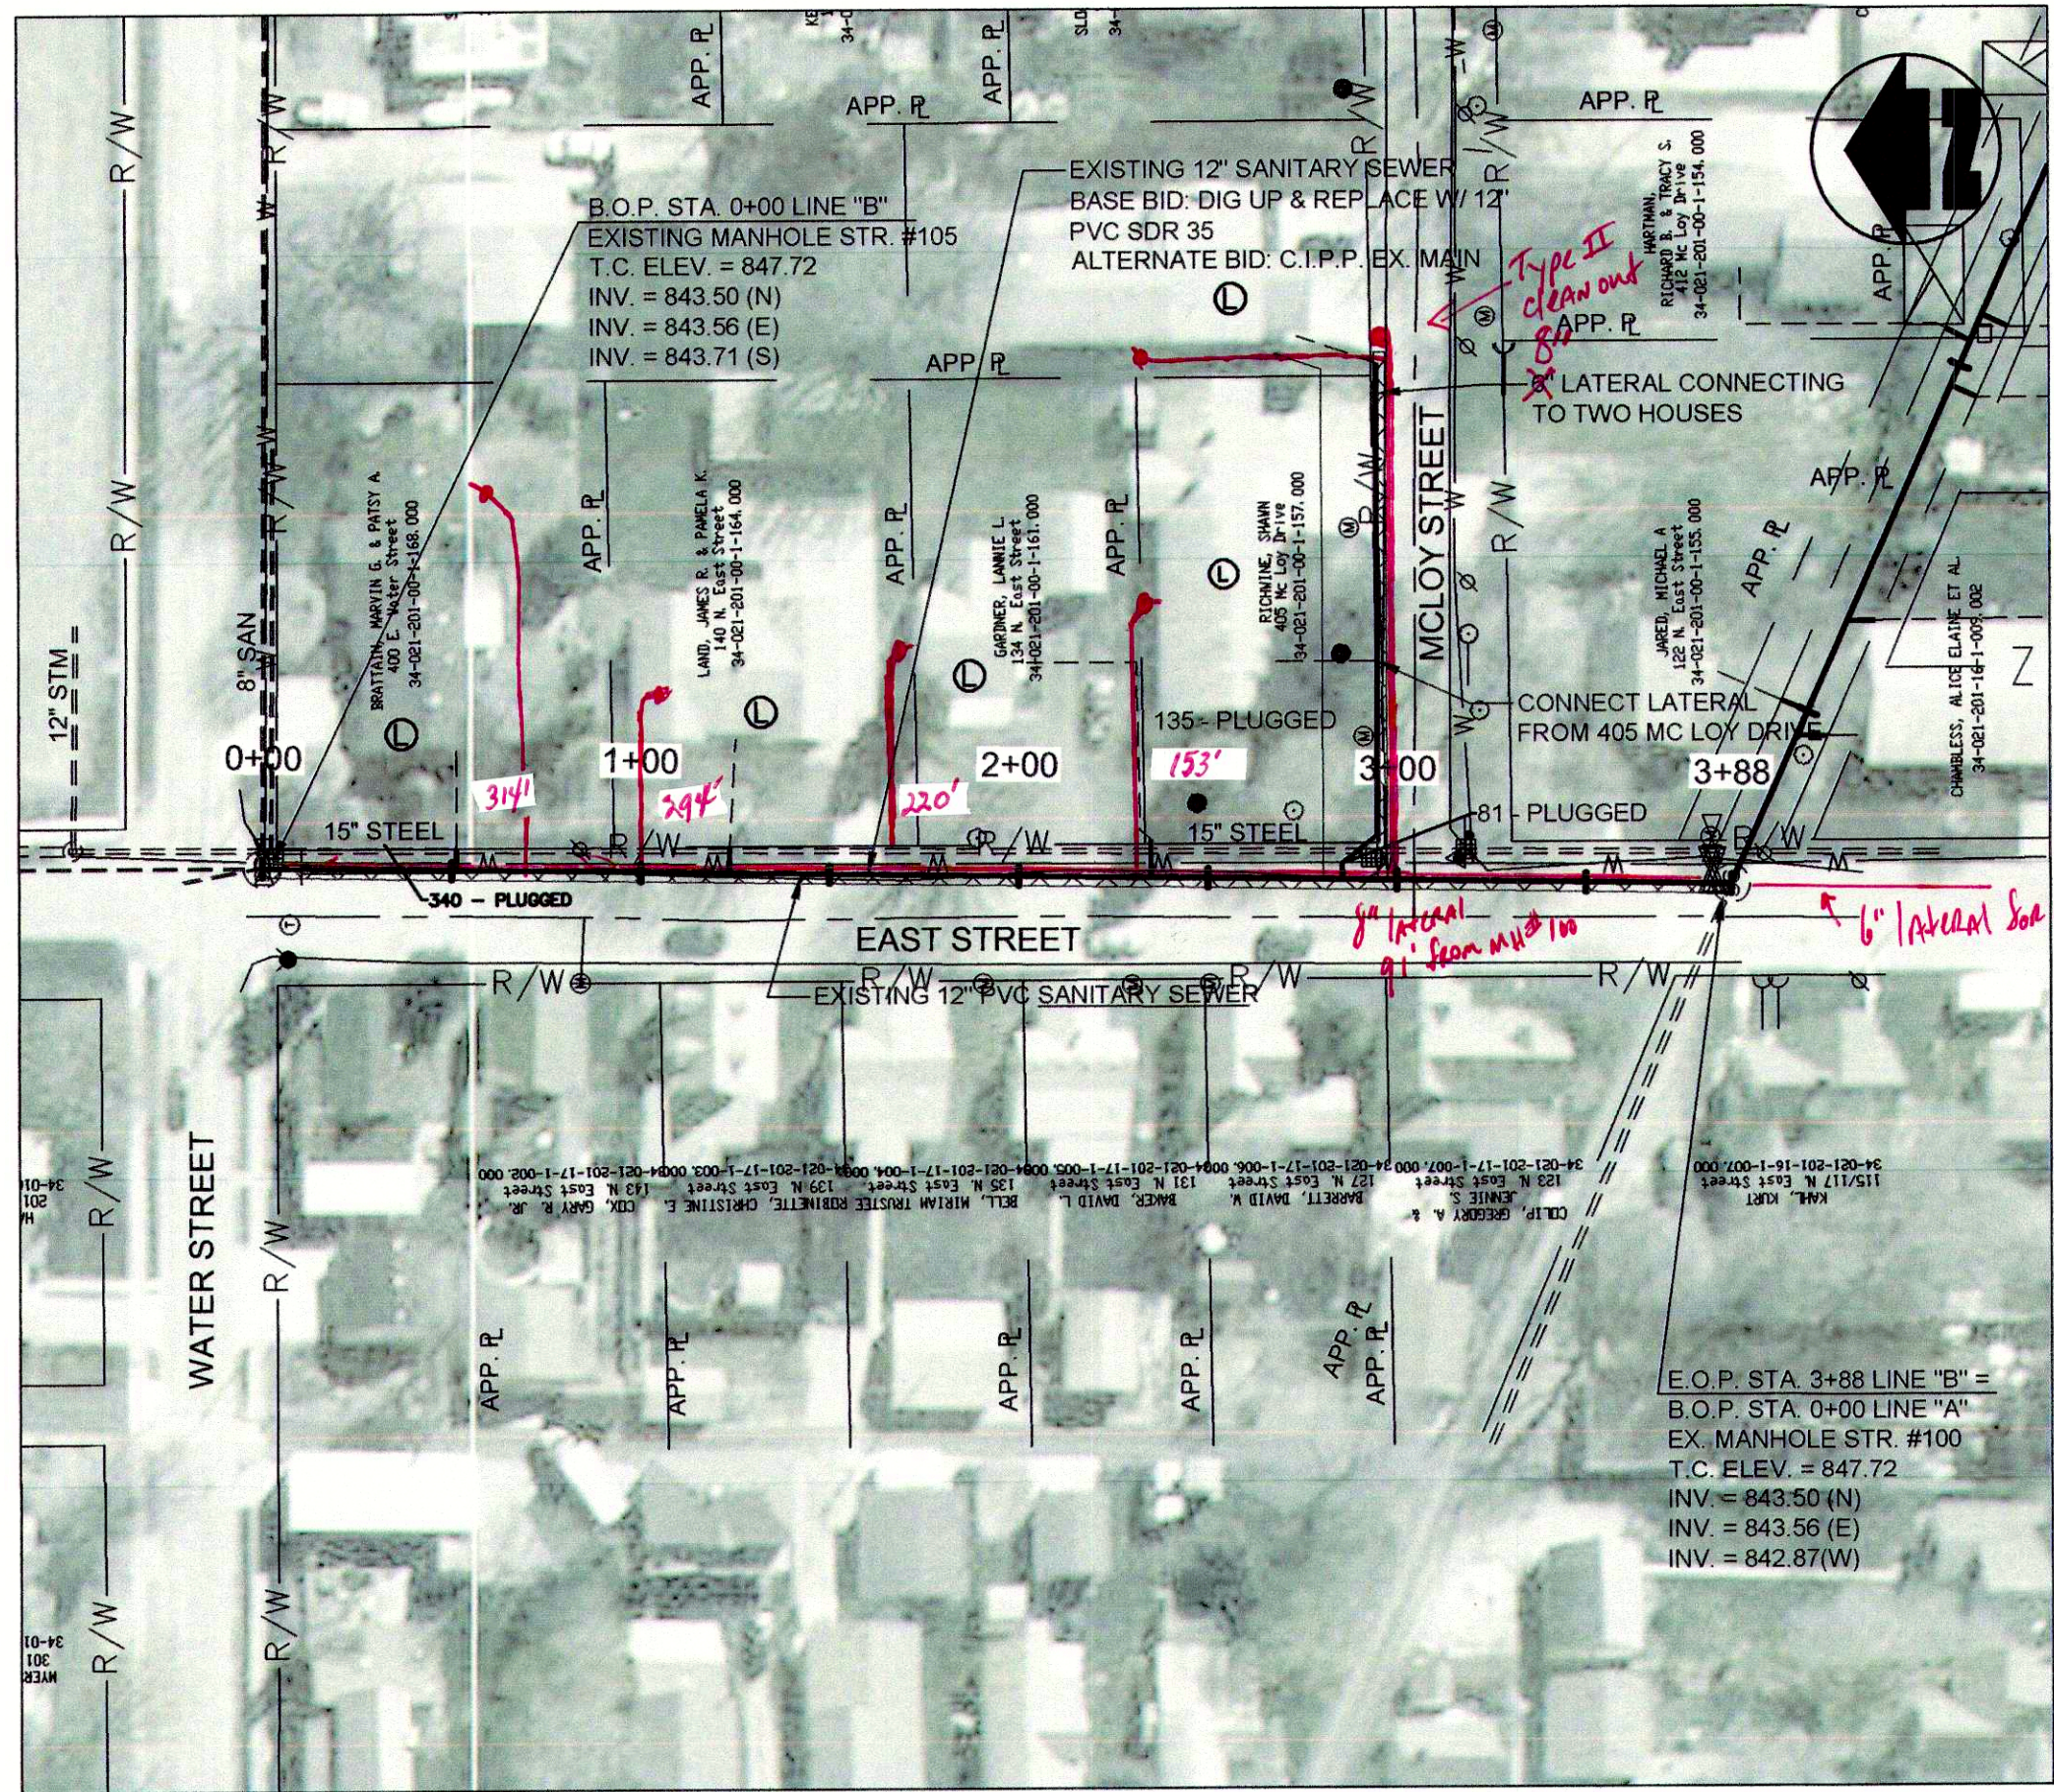

PLAN VIEW - B.O.P. STA. 0+00 TO E.O.P. STA. 3+88 LINE "B"

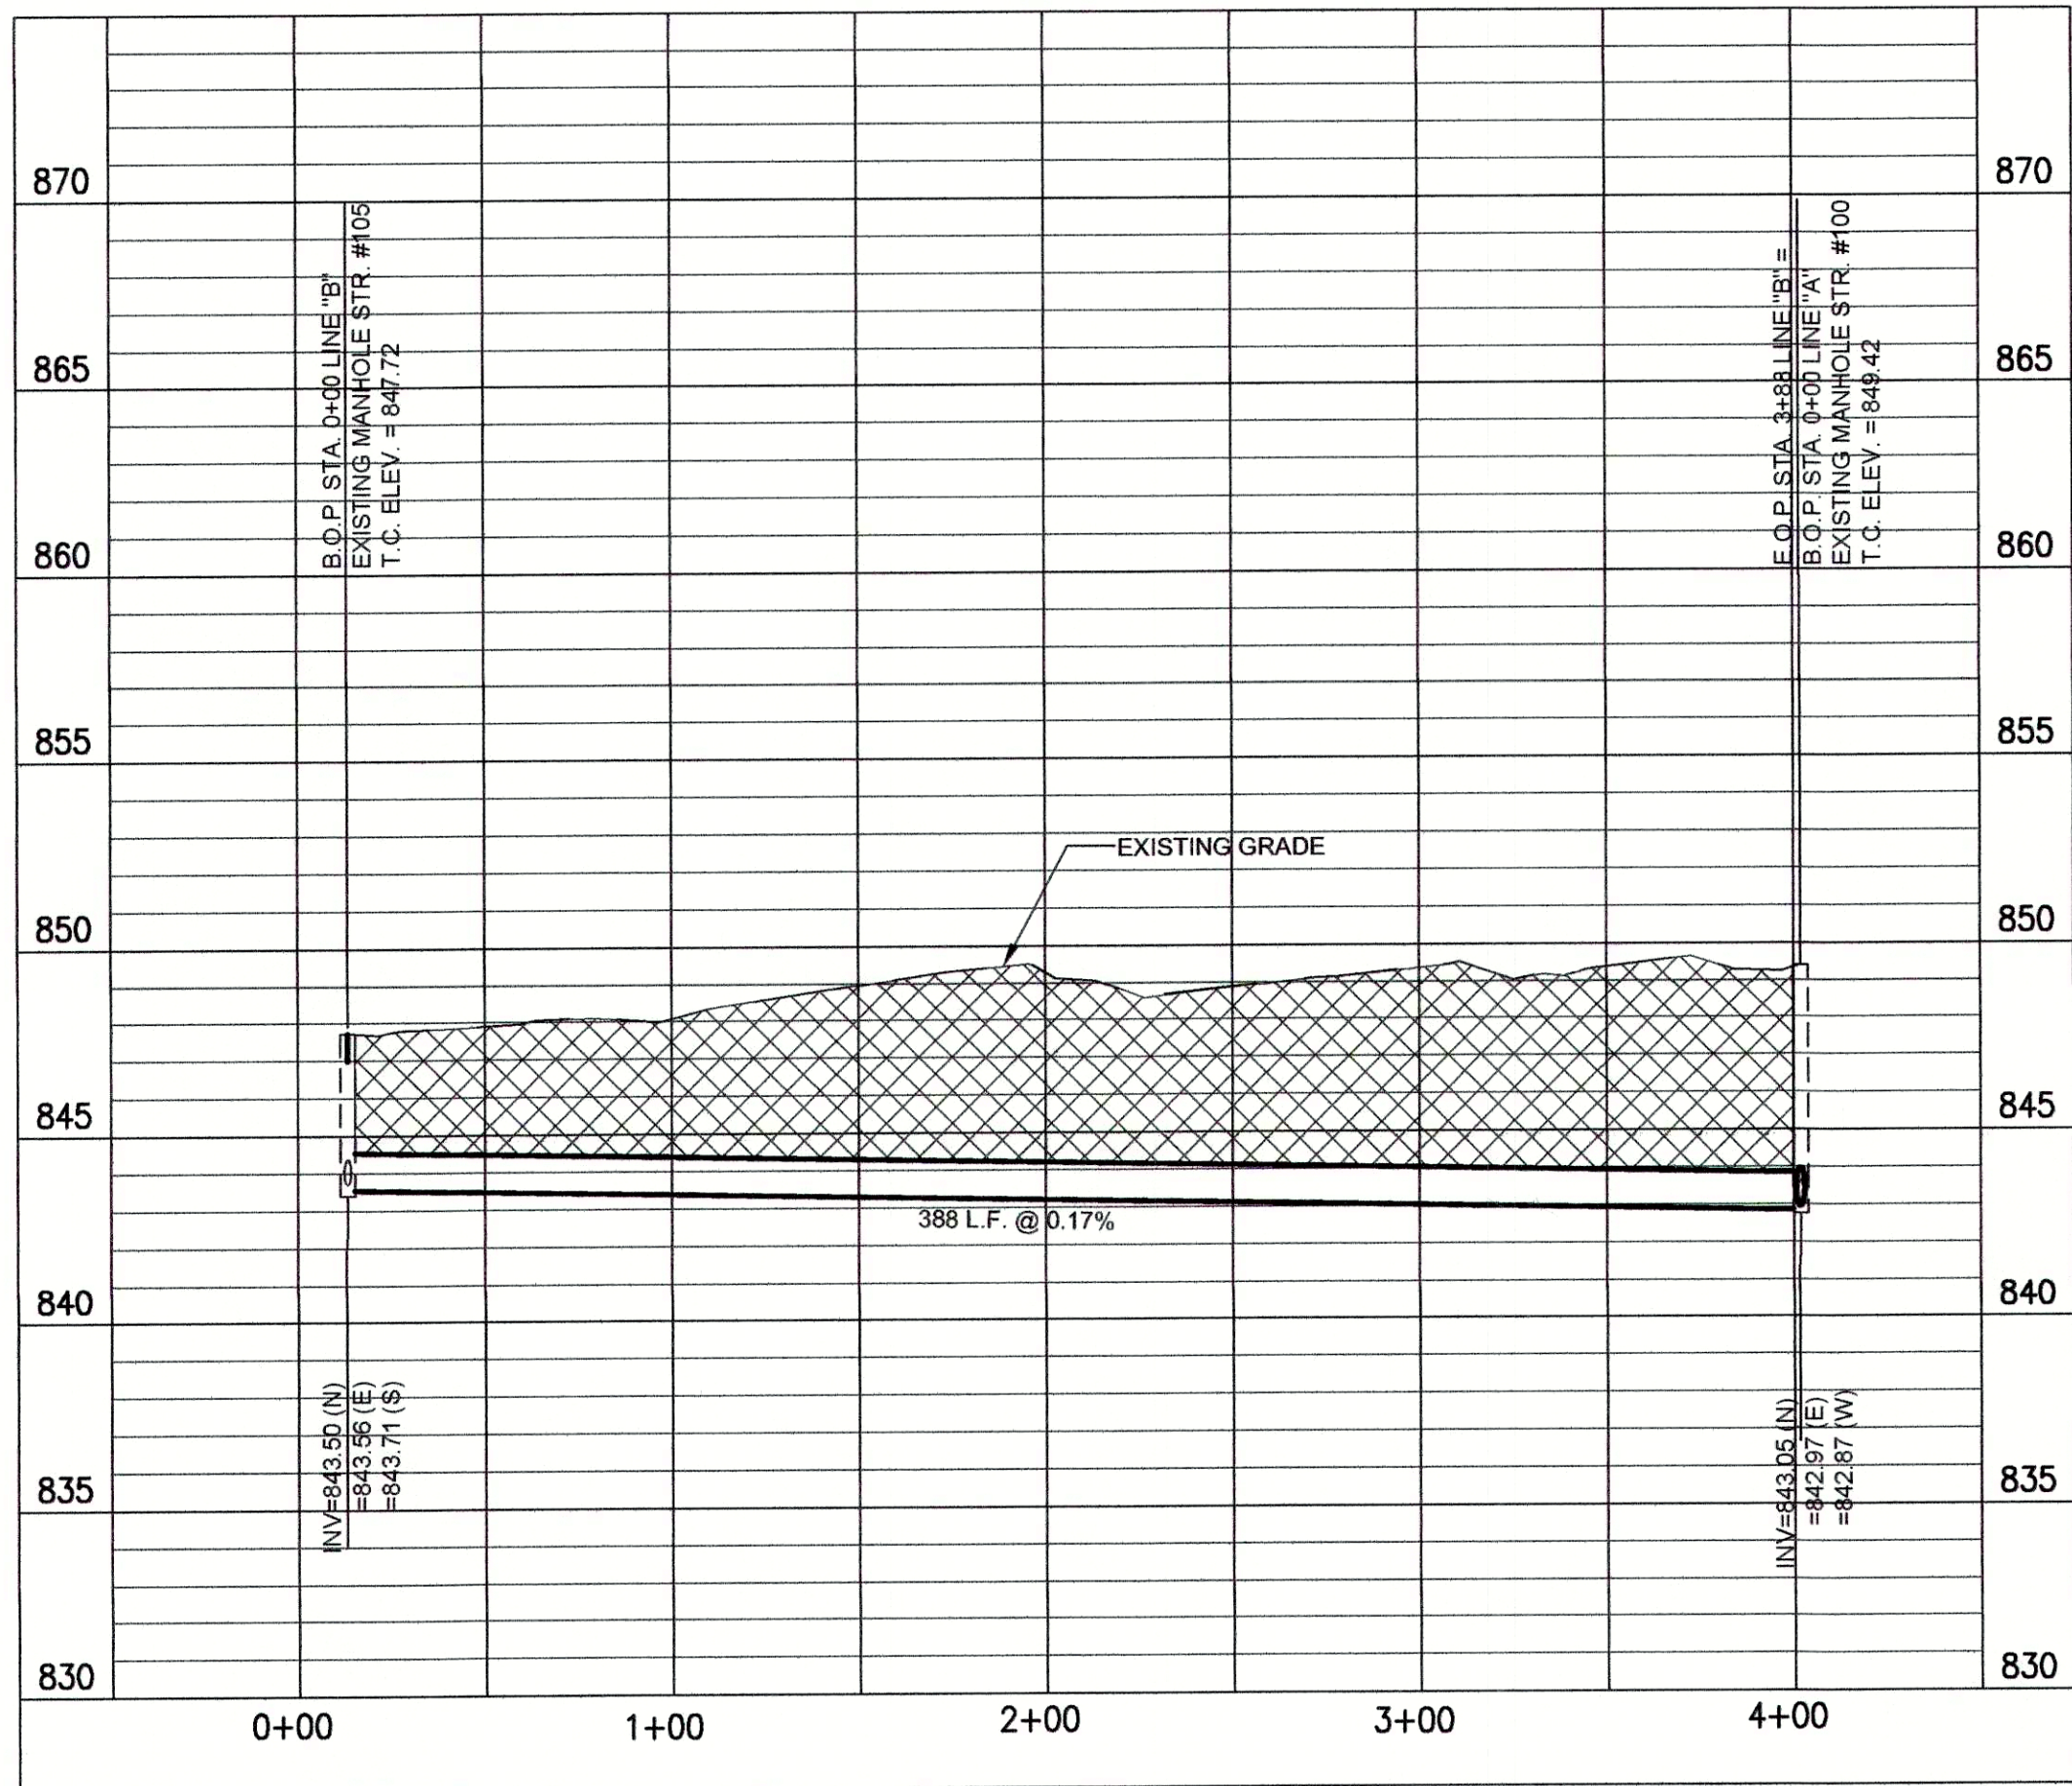

PROFILE - B.O.P. STA. 0+00 TO E.O.P. STA. 3+88 LINE "B"

① PRIVATE LATERALS TO BE REPLACED.
SEE WORK DESCRIPTION IN MEASUREMENTS AND PAYMENT.

- NOTE:
1. THE WORK TO REPLACE THE MAINS AND RECONNECT TO THE LATERALS WITHIN RIGHT-OF-WAY SHALL BE INCLUDED IN THE BAS BID.
 2. THE WORK TO REPLACE THE PRIVATE LATERALS SHALL BE INCLUDED IN ALTERNATE NO. 2
 3. LATERAL LOCATIONS SHOWN ARE BASED ON BEST AVAILABLE INFORMATION. CONTRACTOR SHALL FIELD VERIFY EXISTING LATERAL LOCATIONS AND DEPTHS.
 4. THE 6" LATERAL SERVING TWO HOUSES OFF MCLOY DRIVE SHALL BE INCLUDED IN THE BASE BID, INSTALLED WITHIN THE RIGHT-OF-WAY AND PAID FOR AS 1 LONG SIDE LATERAL AND 1 SHORT SIDE LATERAL. THE PORTIONS ON PRIVATE PROPERTY SHALL BE PART OF ALTERNATE NO. 2

- "BID SCHEDULE A" (OPEN CUT) NOTES:
1. LATERAL LOCATIONS SHOWN ARE BASED ON BEST AVAILABLE INFORMATION. CONTRACTOR TO FIELD VERIFY ALL EXISTING SANITARY LATERAL LOCATIONS AND DEPTHS, INSTALL 6" SDR 35 SEWER PIPE TO R/W LINE AND CONNECT TO EXISTING LATERAL.
 2. THE EXISTING MANHOLES ARE TO REMAIN IN PLACE WITH NEW SEWERS RECONNECTED. THE MANHOLES SHALL BE REHABILITATED PER THE MANHOLE REHABILITATION SCHEDULE.

- "BID SCHEDULE B" (CIPP) NOTES:
1. LATERAL LOCATIONS SHOWN ARE BASED ON BEST AVAILABLE INFORMATION. CONTRACTOR TO FIELD VERIFY EXISTING SANITARY LATERAL LOCATIONS AND DEPTHS, FOR LATERAL REPLACEMENTS, MAKE CONNECTION DIRECTLY TO CIPP LINER AS SHOWN IN THE DETAILS AND ON SHEET C-16. INSTALL 6" SDR 35 SEWER PIPE FROM MAIN TO R/W LINE AND CONNECT TO EXISTING LATERAL.
 2. IF THE PLANS SHOW C.I.P.P. LATERAL REHABILITATION, COMPLETE PER THE DETAIL ON SHEET C-16.
 3. MANHOLE SHALL BE REHABILITATION PER THE MANHOLE REHABILITATION SCHEDULE.

JOSEPH P. TIERNEY
REGISTERED
No
19300407
STATE OF
INDIANA
PROFESSIONAL ENGINEER

GRW PROJECT NO. 4447-14

SRF NO. WW0074803

ALL RIGHTS RESERVED. PROPERTY OF
GRW ENGINEERS, INC. AND SHALL NOT
BE REPRODUCED OR TRANSMITTED IN
ANY FORM OR BY ANY MEANS, ELECTRONIC
OR MECHANICAL, INCLUDING PHOTOCOPYING,
RECORDING, OR BY ANY INFORMATION
SYSTEMS, WITHOUT WRITTEN PERMISSION.

engineering | architecture | geospatial
www.grwinc.com



PLAN & PROFILE
SANITARY SEWER REHABILITATION
FALL CREEK REGIONAL WASTE DISTRICT
PENDLETON, INDIANA

DESIGNED	GWL
DRAWN	GCR
REVIEWED	JPT
APPROVED	JPT

DATE:
APRIL 2016
SCALE:
H: 1"=50' V: 1"=10'
SHEET NO.

C-13

BID SET

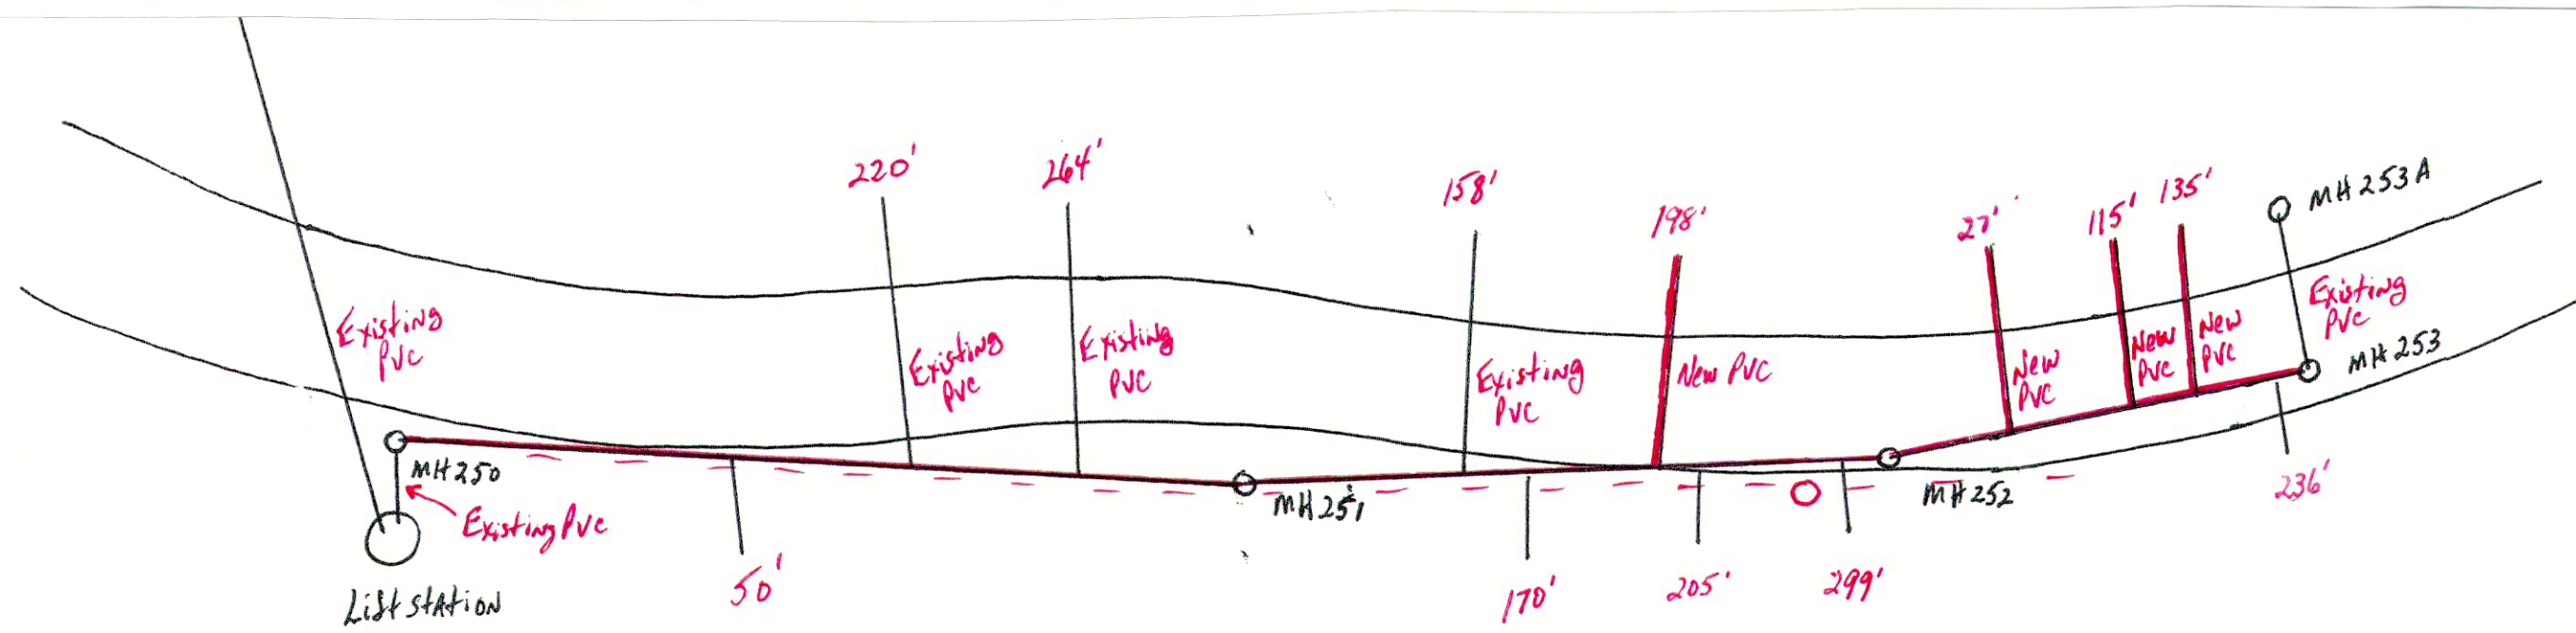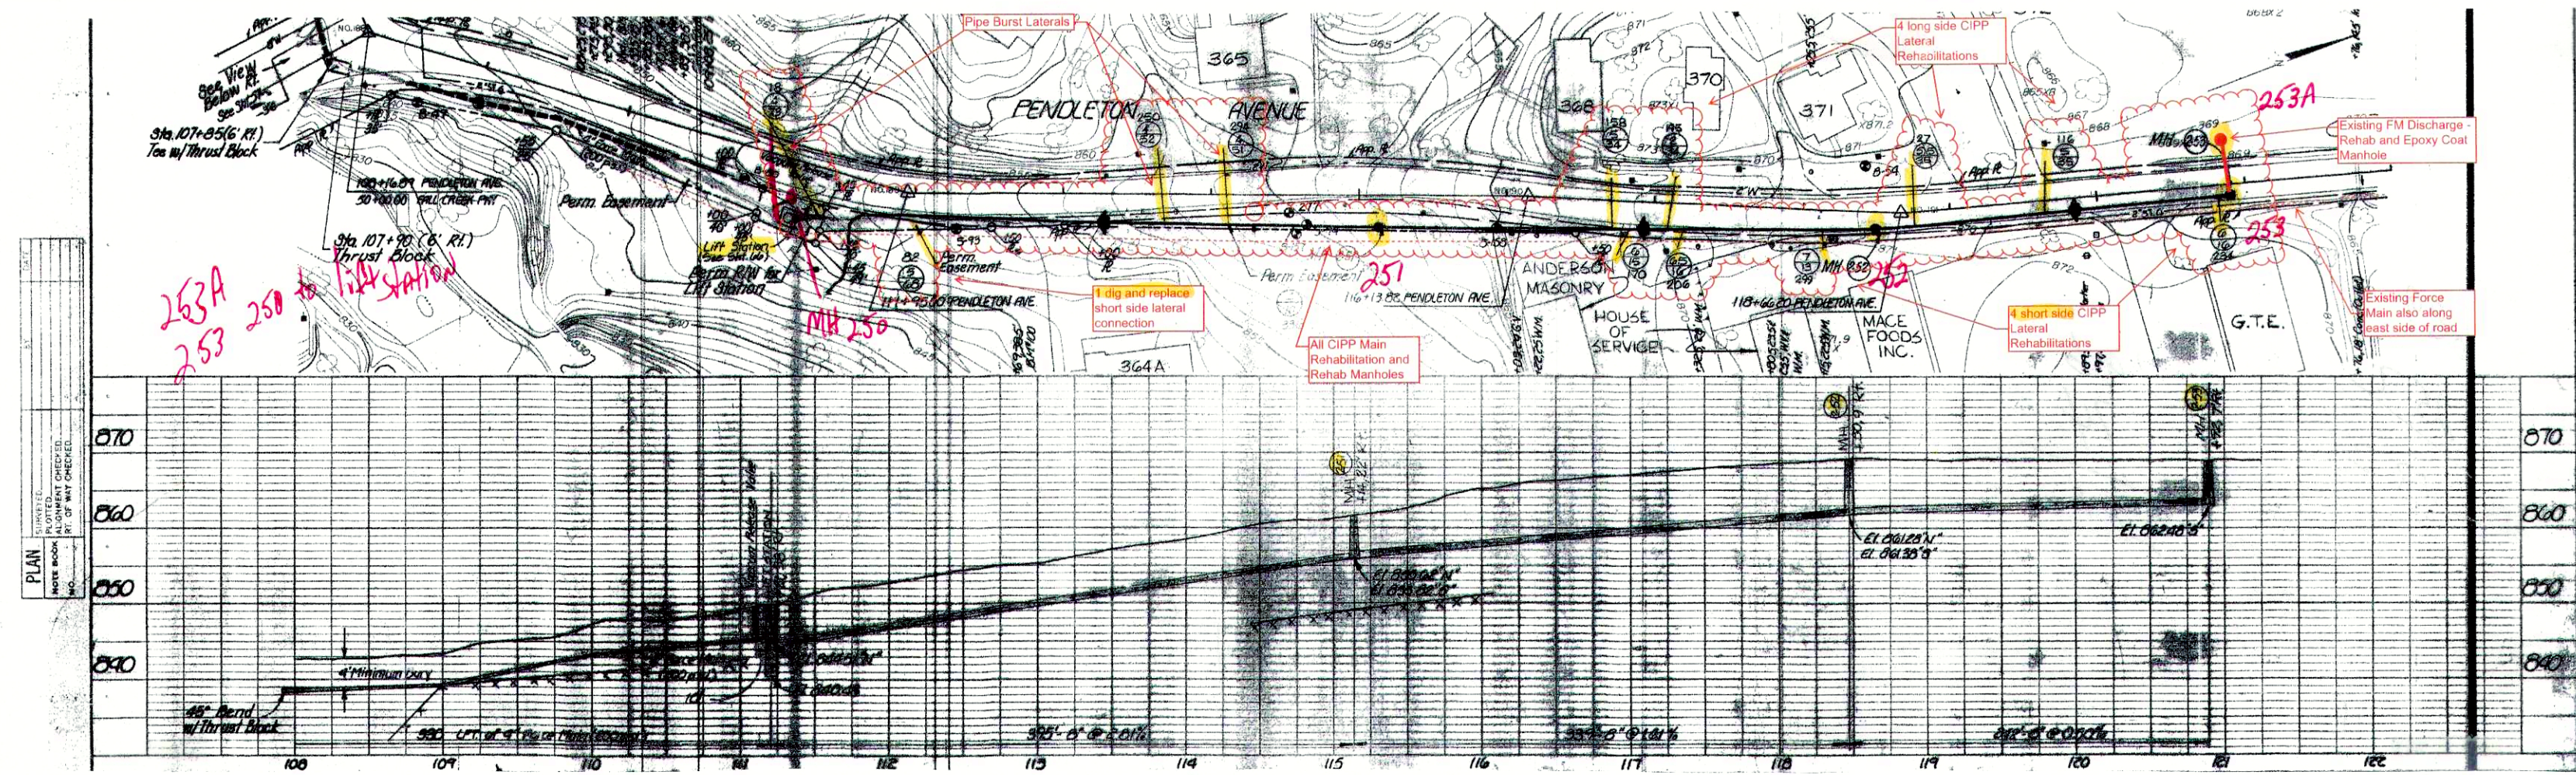


MH#250 to MH#253 CIPP

Existing force main on east side of the road
Rehab all manholes/epoxy coat

North

N. Pendleton

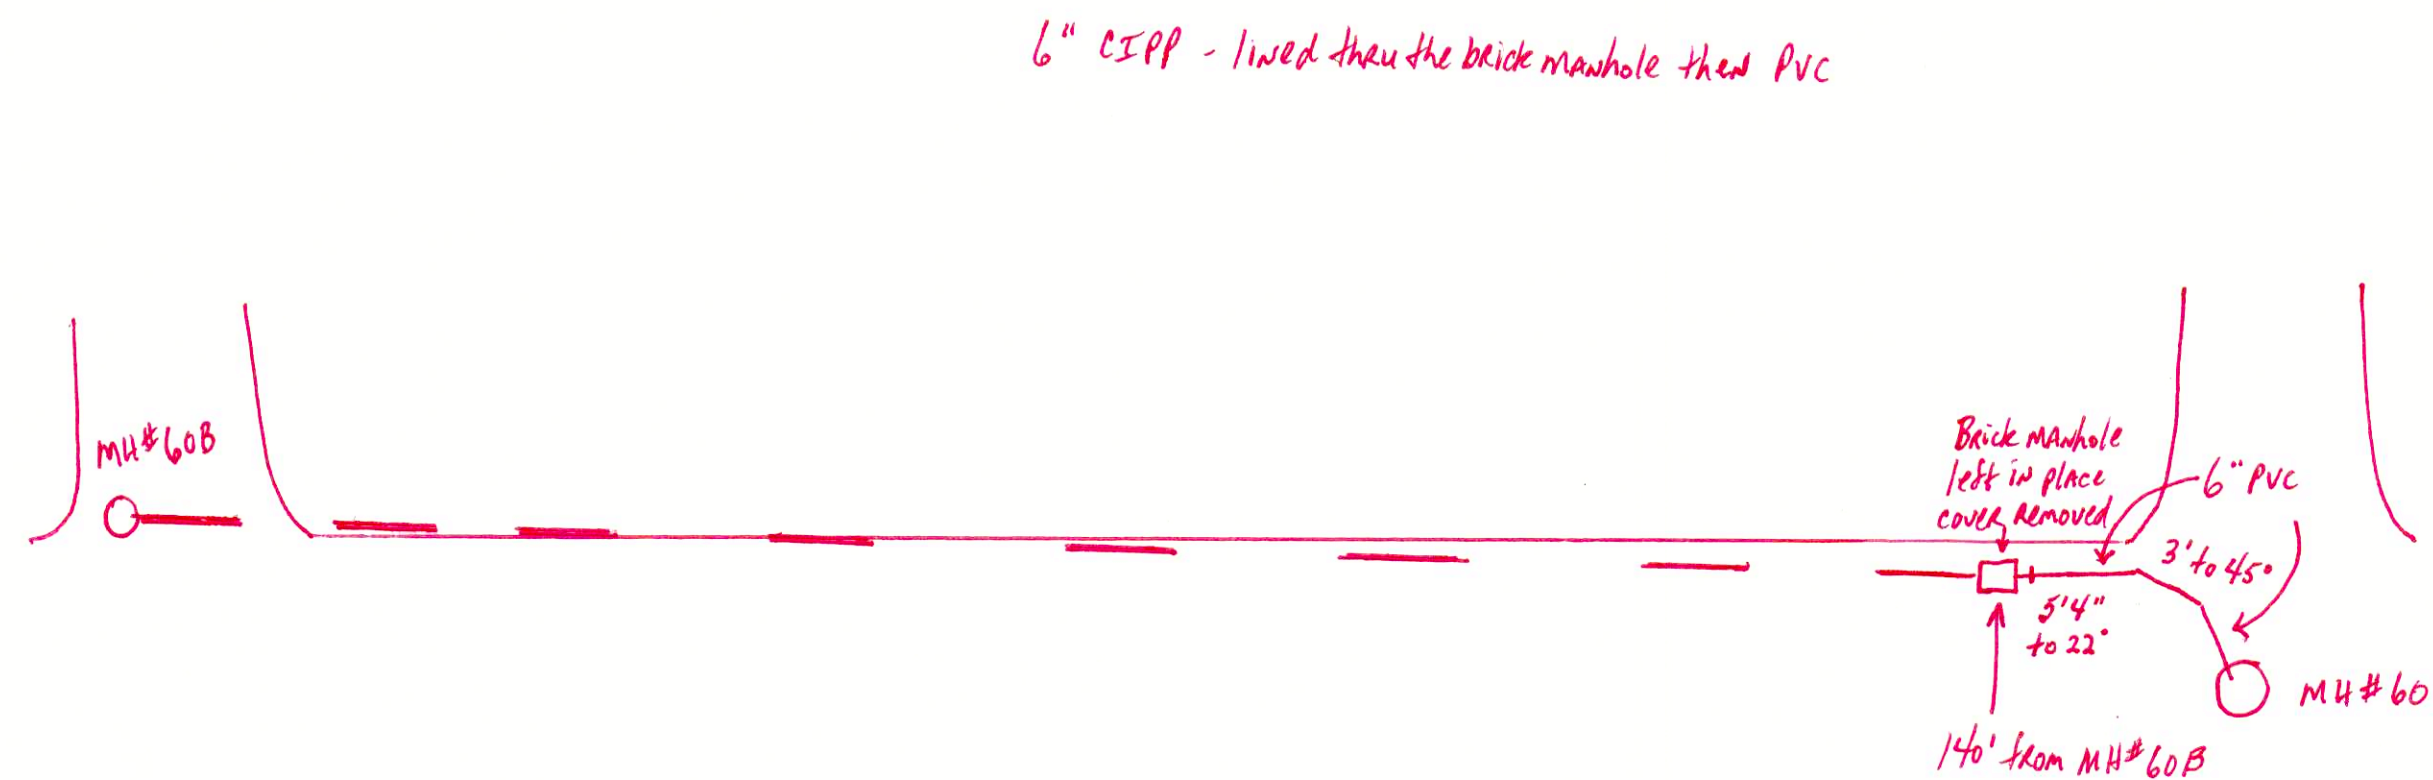

6" CIPP - lined thru the brick manhole then PVC

South

JOSEPH P. TIERNEY
REGISTERED
No.
19300407
STATE OF
INDIANA
PROFESSIONAL ENGINEER

GRW PROJECT NO. 4447-14

SRF NO. WW16074803

ALL RIGHTS RESERVED. PROPERTY OF
GRW ENGINEERS, INC. AND SHALL NOT
BE REPRODUCED OR USED FOR CONSTRUCTION OF
ANY PROJECT WITHOUT WRITTEN PERMISSION



engineering | architecture | geospatial

www.grwinc.com

PLAN & PROFILE ADDITIONAL AREA
SANITARY SEWER REHABILITATION
FALL CREEK REGIONAL WASTE DISTRICT
PENDLETON, INDIANA

DESIGNED	GWL
DRAWN	GCR
REVIEWED	JPT
APPROVED	JPT

DATE: APRIL 2016

SCALE: N.T.S.

SHEET NO. C-13 A

REVISIONS

NO.	DATE	DESCRIPTION

SCALE CHECK: THIS MARK SHOULD MEASURE EXACTLY 1" WHEN PLOTTED

BID SET

PRINTED: 6/24/2016 @ 12:04PM

FILE NAME: G:\4447-FCRW\DWG\Working Drawings\AutoCAD\REHABILITATION PHASE I\4447-14-C-14-Rehab Schedule.dwg

SANITARY SEWER REHABILITATION SCHEDULE - MANHOLE																
Sheet No.	Manhole (MH) No.	MH Material	General Location	MH Diameter (ft.)	MH Depth (ft.)	Surface Type	Grout Leaks, Patch Defects and Apply Cementitious Sealant to all Joints	Full Cementitious Lining	Epoxy Lining	Mastic Chimney Seal	Replace Frame & Cover	Raise Casting	Remove Steps	Install Marker Post	Notes	
PENDLETON AVENUE																
C-01	MH 6-37	PRECAST CONCRETE	WEST OF PENDLETON AVENUE	4	6.3	GRASS	YES	NO	NO	YES	NO	NO	NO	NO		
C-01	MH 6-36	PRECAST CONCRETE	WEST OF PENDLETON AVENUE	4	6.9	GRASS	YES	NO	NO	YES	NO	NO	NO	NO		
C-01	MH 6-35	PRECAST CONCRETE	WEST OF PENDLETON AVENUE	4	7.7	GRASS	YES	NO	NO	YES	NO	NO	NO	NO		
C-01	MH 6-34	PRECAST CONCRETE	WEST OF PENDLETON AVENUE	4	9.3	GRASS	YES	NO	NO	YES	NO	NO	NO	NO		
C-02	MH 6-33	PRECAST CONCRETE	WEST OF PENDLETON AVENUE	4	8.1	GRASS	YES	NO	NO	YES	NO	NO	NO	NO		
C-02	MH 6-32	PRECAST CONCRETE	WEST OF PENDLETON AVENUE	4	8.2	GRASS	YES	NO	NO	YES	NO	NO	NO	NO		
C-02	MH 6-31	PRECAST CONCRETE	WEST OF PENDLETON AVENUE	4	8.7	ASPHALT	YES	NO	NO	YES	NO	NO	NO	NO		
C-02	MH 6-30	PRECAST CONCRETE	WEST OF PENDLETON AVENUE	4	6.9	GRASS	YES	NO	NO	YES	NO	NO	NO	NO		
C-03	MH 6-29	PRECAST CONCRETE	WEST OF PENDLETON AVENUE	4	13.9	GRASS	YES	NO	NO	YES	NO	NO	NO	NO		
C-03	MH 6-28	PRECAST CONCRETE	WEST OF PENDLETON AVENUE	4	10.0	GRASS	YES	NO	NO	YES	NO	NO	NO	NO		
				Total:	86.0											
GARDEN DRIVE																
C-03	MH 6-38	PRECAST CONCRETE	WEST END OF GARDEN DRIVE	4	4.8	GRASS	YES	NO	NO	YES	NO	NO	NO	NO		
C-03	MH 6-39	PRECAST CONCRETE	APPROX 227 FT. SOUTH OF GARDEN DRIVE	4	5.8	GRAVEL	YES	NO	NO	YES	NO	NO	NO	NO		
				Total:	10.6											
REFORMATORY ROAD																
C-04	MH 6-40	PRECAST CONCRETE	SOUTH SIDE OF REFORMATORY ROAD	4	6.7	GRASS	YES	NO	NO	YES	NO	NO	NO	NO		
				Total:	6.7											
HALLOWELL DRIVE																
C-04	MH 2-42	PRECAST CONCRETE	INTERSECTION OF HALLOWELL DR. AND JOHN ST.	4	5.9	ASPHALT	YES	NO	NO	YES	NO	NO	NO	NO		
C-04	MH 2-45	PRECAST CONCRETE	HALLOWELL DRIVE WITHIN PAVEMENT	4	2.8	ASPHALT	YES	NO	NO	YES	NO	NO	NO	NO		
				Total:	8.7											
JOHN STREET																
C-04	MH 2-41	PRECAST CONCRETE	WEST EDGE OF JOHN STREET	4	4.6	GRAVEL	YES	NO	NO	YES	NO	NO	NO	NO		
				Total:	4.6											
BROADWAY RD																
C-05	MH 5-45	PRECAST CONCRETE	WEST SIDE OF BROADWAY	4	9.9	CONCRETE	YES	NO	NO	YES	NO	NO	NO	NO		
C-05	MH 5-44	PRECAST CONCRETE	WEST SIDE OF BROADWAY	4	5.8	CONCRETE	YES	NO	NO	YES	NO	NO	NO	NO		
				Total:	15.7											
FALLS PARK DRIVE																
C-06	MH 2-48	PRECAST CONCRETE	NORTH OF FALLS PARK DRIVE	4	4.9	GRASS	YES	NO	NO	YES	NO	NO	NO	NO		
C-06	MH 2-49	PRECAST CONCRETE	NORTH OF FALLS PARK DRIVE	4	6.0	CONCRETE	YES	NO	NO	YES	NO	NO	NO	NO		
C-06	MH 2-50	PRECAST CONCRETE	NORTH OF FALLS PARK DRIVE	4	5.6	CONCRETE	YES	NO	NO	YES	NO	NO	NO	NO		
				Total:	16.5											
HAYDEN WAY																
C-06	MH 2-59	PRECAST CONCRETE	NORTH SIDE OF INTERSECTION OF HAYDEN WAY AND WATER ST.	4	3.2	CONCRETE	YES	NO	NO	YES	NO	NO	NO	NO		
C-06	MH 2-62	PRECAST CONCRETE	EAST SIDE OF HAYDEN WAY	4	3.5	ASPHALT	YES	NO	NO	YES	NO	NO	NO	NO		
				Total:	6.7											
EAST STREET																
C-07	MH 2-47	PRECAST CONCRETE	WEST SIDE OF EAST STREET	4	4.2	GRASS	YES	NO	NO	YES	NO	NO	NO	NO		
C-07	MH 2-46	PRECAST CONCRETE	WEST SIDE OF EAST STREET	4	2.7	ASPHALT	YES	NO	NO	YES	NO	NO	NO	NO		
				Total:	6.9											
WATER STREET																
C-07	MH 2-57	PRECAST CONCRETE	NORTH SIDE OF WATER STREET	4	5.3	GRASS	YES	NO	NO	YES	NO	NO	NO	NO		
C-07	MH 2-58	PRECAST CONCRETE	NORTH SIDE OF WATER STREET	4	5.3	GRASS	YES	NO	NO	YES	NO	NO	NO	NO		
C-07	MH 2-58A	PRECAST CONCRETE	NORTH SIDE OF WATER STREET	4	5.0	GRASS	YES	NO	NO	YES	NO	NO	NO	NO		
C-08	MH 2-60	PRECAST CONCRETE	NORTH SIDE OF WATER STREET	4	5.2	CONCRETE	YES	NO	NO	YES	NO	NO	NO	NO		
C-08	MH 2-61	PRECAST CONCRETE	NORTH SIDE OF WATER STREET	4	4.9	GRASS	YES	NO	NO	YES	NO	NO	NO	NO		
C-08	MH 2-63	PRECAST CONCRETE	SOUTH SIDE OF WATER STREET	4	4.4	GRASS	YES	NO	NO	YES	NO	NO	NO	NO		
				Total:	30.1											
WEST CENTRAL WAY																
C-08	MH 2-64	PRECAST CONCRETE	INTERSECTION OF WEST CENTRAL WAY AND WATER ST.	4	5.2	ASPHALT	YES	NO	NO	YES	NO	NO	NO	NO		
C-09	MH 2-65	PRECAST CONCRETE	EAST SIDE OF WEST CENTRAL WAY	4	5.1	ASPHALT	YES	NO	NO	YES	NO	NO	NO	NO		
C-09	MH 2-66	PRECAST CONCRETE	EAST SIDE OF WEST CENTRAL WAY	4	5.1	ASPHALT	YES	NO	NO	YES	NO	NO	NO	NO		
				Total:	15.4											
EAST CENTRAL WAY																
C-09	MH 2-67	PRECAST CONCRETE	WEST SIDE OF EAST CENTRAL WAY	4	6.5	ASPHALT	YES	NO	NO	YES	NO	NO	NO	NO		
C-10	MH 2-68	PRECAST CONCRETE	WEST SIDE OF EAST CENTRAL WAY	4	4.3	GRASS	YES	NO	NO	YES	NO	NO	NO	NO		
C-10	MH 2-69	PRECAST CONCRETE	APPROX 200 FT EAST OF EAST CENTRAL WAY IN EASEMENT	4	2.9	ASPHALT	YES	NO	NO	YES	NO	NO	NO	NO		
				Total:	13.7											
STATE ROAD 67																
C-10	MH 2-70	PRECAST CONCRETE	WEST SIDE OF STATE ROAD 67	4	5.5	GRASS	YES	NO	NO	YES	NO	NO	NO	NO		
C-10	MH 2-71	PRECAST CONCRETE	APPROX 200 FT WEST OF SR 67, JUST WEST OF HAYDEN WAY	4	2.6	GRASS	YES	NO	NO	YES	NO	NO	NO	NO		
C-11	MH 2-72	PRECAST CONCRETE	WEST SIDE OF STATE ROAD 67	4	6.6	GRASS	YES	NO	NO	YES	NO	NO	NO	NO		
C-11	MH 2-73	PRECAST CONCRETE	EAST SIDE OF STATE ROAD 67	4	3.0	GRASS	YES	NO	NO	YES	NO	NO	NO	NO		
C-11	MH 2-74	PRECAST CONCRETE	EAST SIDE OF STATE ROAD 67	4	7.5	ASPHALT	YES	NO	NO	YES	NO	NO	NO	NO		
				Total:	25.3											
STATE STREET																
C-12	MH 100	PRECAST CONCRETE	EAST SIDE OF EAST STREET	4	6.4	ASPHALT	YES	NO	NO	YES	NO	NO	NO	NO		
C-12	MH 101	PRECAST CONCRETE	WITHIN EASEMENT APPROX 200 FT NORTH OF STATE STREET	4	5.0	GRASS	NO	NO	NO	YES	NO	NO	NO	NO	TO BE REPLACED	
C-12	MH 102	PRECAST CONCRETE	WITHIN EASEMENT APPROX 200 FT NORTH OF STATE STREET	4	6.0	GRASS	NO	NO	NO	YES	NO	NO	NO	NO	TO BE REPLACED	
C-12	MH 103	PRECAST CONCRETE	WITHIN EASEMENT APPROX 200 FT NORTH OF STATE STREET	4	6.0	GRASS	NO	NO	NO	YES	NO	NO	NO	NO	TO BE REPLACED	
C-12	MH 104	PRECAST CONCRETE	NORTH SIDE OF STATE STREET WEST OF RR	4	8.4	GRAVEL	YES	NO	NO	YES	NO	NO	NO	NO		
				Total:	31.8											
EAST STREET																
C-13	MH 105	PRECAST CONCRETE	INTERSECTION OF EAST AND WATER	4	4.2	ASPHALT	YES	NO	NO	YES	NO	NO	NO	NO		
				Total:	4.2											
				Combined:	282.9											

JOSEPH P. TIERNAN
REGISTERED
No. 19300407
STATE OF INDIANA
PROFESSIONAL ENGINEER

GRW PROJECT NO. 4447-14
SRF NO. WW16074803 ---
ALL RIGHTS RESERVED
THIS DOCUMENT IS THE PROPERTY OF
GWINC ENGINEERS, INC. AND SHALL NOT
BE REPRODUCED IN WHOLE OR IN PART
WITHOUT WRITTEN PERMISSION
OF GWINC ENGINEERS, INC.



engineering | architecture | geospatial
www.gwinco.com

MANHOLE REHABILITATION SCHEDULE
SANITARY SEWER REHABILITATION
FALL CREEK REGIONAL WASTE DISTRICT
PENDLETON, INDIANA

DESIGNED: GWL
DRAWN: JPT
REVIEWED: JPT
APPROVED: JPT

REVISIONS

NO.	DATE	BY	DESCRIPTION

THIS MARK SHOULD MEASURE EXACTLY 1" WHEN PLOTTED

DATE:
APRIL 2016

SCALE:
NONE

SHEET NO.
C-14

BID SET

SOUTH PENDLETON C.I.P.P. REHABILITATION SCHEDULE – BID SCHEDULE "B"				
SEWER SEGMENT (USMH TO DSMH)	PIPE DIAMETER (IN)	APPROXIMATE LENGTH (FT)	NUMBER OF ACTIVE CONNECTIONS	SHEET NUMBER
6-37 TO 6-36	8	427	5	C-01
6-36 TO 6-35	8	164	1	C-01
6-35 TO 6-34	8	478	6	C-01
6-34 TO 6-33	8	372	4	C-01/C-02
6-33 TO 6-32	8	435	4	C-02
6-32 TO 6-31	8	493	5	C-02
6-31 TO LIFT STATION	8	65	0	C-02
6-30 TO LIFT STATION	8	44	0	C-02
6-29 TO 6-30	8	456	1	C-02/C-03
6-28 TO 6-29	8	434	5	C-03
6-38 TO 6-35	8	585	5	C-03
6-39 TO 6-38	8	227	2	C-03
6-40 TO 6-31	8	455	2	C-04
SUB-TOTALS		4635	40	

FALLS PARK C.I.P.P. REHABILITATION SCHEDULE – BID SCHEDULE "B"				
SEWER SEGMENT (USMH TO DSMH)	PIPE DIAMETER (IN)	APPROXIMATE LENGTH (FT)	NUMBER OF ACTIVE CONNECTIONS	SHEET NUMBER
2-41 TO 2-42	8	197	5	C-04
2-45 TO 2-42	8	209	2	C-04
2-50 TO 2-49	8	319	1	C-06
2-49 TO 2-48	8	295	0	C-06
2-48 TO LIFT STATION	8	141	0	C-06
2-46 TO 2-47	8	326	4	C-07
2-47 TO 2-48	8	407	4	C-07
SUB-TOTALS		1894	16	

SOUTH BROADWAY REHABILITATION SCHEDULE – BID SCHEDULE "B"				
SEWER SEGMENT (USMH TO DSMH)	PIPE DIAMETER (IN)	APPROXIMATE LENGTH (FT)	NUMBER OF ACTIVE CONNECTIONS	SHEET NUMBER
5-45 TO LIFT STATION	8	496	6	C-05
5-44 TO LIFT STATION	8	440	6	C-05
SUB-TOTALS		936	12	

STATE ROAD 67 REHABILITATION SCHEDULE – BID SCHEDULE "B"				
SEWER SEGMENT (USMH TO DSMH)	PIPE DIAMETER (IN)	APPROXIMATE LENGTH (FT)	NUMBER OF ACTIVE CONNECTIONS	SHEET NUMBER
2-71 TO 2-70	8	196	3	C-10
2-74 TO 2-73	8	282	3	C-11
2-73 TO 2-72	8	91	0	C-11
2-72 TO 2-70	8	368	2	C-11
2-70 TO LIFT STATION	8	337	1	C-11
SUB-TOTALS		1274	9	

EAST WATER STREET REHABILITATION SCHEDULE – BID SCHEDULE "B"				
SEWER SEGMENT (USMH TO DSMH)	PIPE DIAMETER (IN)	APPROXIMATE LENGTH (FT)	NUMBER OF ACTIVE CONNECTIONS	SHEET NUMBER
2-61 TO 2-60	8	353	4	C-08
2-60 TO 2-59	8	321	5	C-08
2-59 TO 2-58A	8	214	0	C-07/C-08
2-58A TO 2-58	8	114	0	C-07
2-58 TO 2+57	8	115	0	C-07
2-57 TO LIFT STATION	8	160	0	C-07
2-66 TO 2-65	8	424	8	C-09
2-65 TO 2-64	8	445	8	C-08/C-09
2-64 TO 2-63	8	149	0	C-08
2-63 TO LIFT STATION	8	74	0	C-08
2-69 TO 2-68	8	201	3	C-10
2-68 TO 2-67	8	537	9	C-09/C-10
2-67 TO 2-57	8	538	7	C-09
2-62 TO 2-59	8	351	4	C-06
SUB-TOTALS		3996	48	

REHABILITATION SCHEDULE SUMMARY – BID SCHEDULE "B"		
	APPROX. LENGTH (FT.)	NO. SERVICE CONNECTIONS
TOTALS FOR ALL AREAS – BID SCHEDULE "B"	13,123	129

NOTES:

1. REFERENCE PLAN AND PROFILE SHEETS FOR APPROXIMATE LENGTHS, DEPTHS AND LOCATIONS OF LATERALS.
2. THE BIDDERS ARE RESPONSIBLE FOR DETERMINING THE ACTUAL NUMBER OF ACTIVE SERVICE CONNECTIONS.

EAST STREET REHAB SUMMARY – BID SCHEDULE "B"				
SEWER SEGMENT (USMH TO DSMH)	PIPE DIAMETER (IN)	APPROXIMATE LENGTH (FT)	NUMBER OF ACTIVE CONNECTIONS	SHEET NUMBER
105 TO 100	12	388	4	C-13

STATE STREET REHAB SUMMARY – ADDITIVE ALTERNATE NO. 1				
SEWER SEGMENT (USMH TO DSMH)	PIPE DIAMETER (IN)	APPROXIMATE LENGTH (FT)	NUMBER OF ACTIVE CONNECTIONS	SHEET NUMBER
103 TO 104	10	252	1	C-12

JOSEPH P. TIERNEY

REGISTERED

No.

19300407

STATE OF

INDIANA

PROFESSIONAL ENGINEER

GRW PROJECT NO. 4447-14

SRF NO. WW0074803 ---

ALL RIGHTS RESERVED. PROPERTY OF GRW ENGINEERS, INC. AND SHALL NOT BE REPRODUCED OR TRANSMITTED IN ANY FORM OR USED FOR CONSTRUCTION OF ANY PROJECT WITHOUT WRITTEN PERMISSION.



engineering | architecture | geospatial

www.gwrinc.com

C.I.P.P. REHABILITATION SCHEDULE

SANITARY SEWER REHABILITATION

FALL CREEK REGIONAL WASTE DISTRICT

PENDLETON, INDIANA

DESIGNED

GWL

DRAWN

GCR

REVIEWED

JPT

APPROVED

JPT

REVISIONS

NO

DESCRIPTION

DATE

BY

DATE

BY

DATE

BY

DATE

BY

SCALE CHECK

THIS MARK SHOULD MEASURE EXACTLY 1" WHEN PLOTTED

DATE:

APRIL 2016


SCALE:

NONE

SHEET NO.

C-15


BID SET

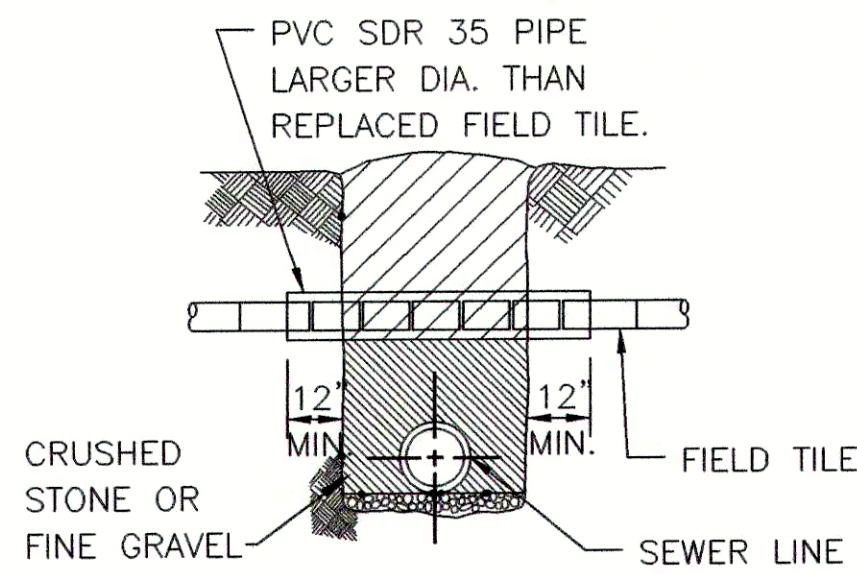

NOTE: FIELD DRAIN REPLACEMENT SHALL BE INCLUDED IN UNIT PRICE FOR GRAVITY SEWER INSTALLATION.


FIELD DRAIN REPLACEMENT DETAIL

SCALE: N.T.S.

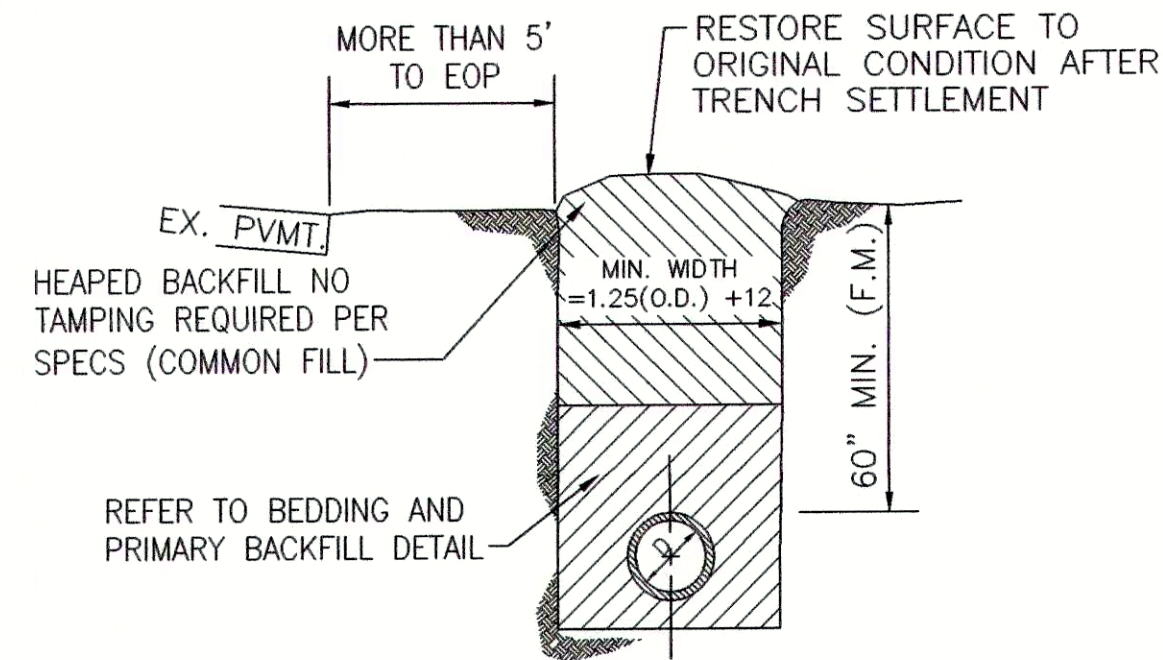


OPEN TERRAIN - METHOD "A"

SCALE: N.T.S.

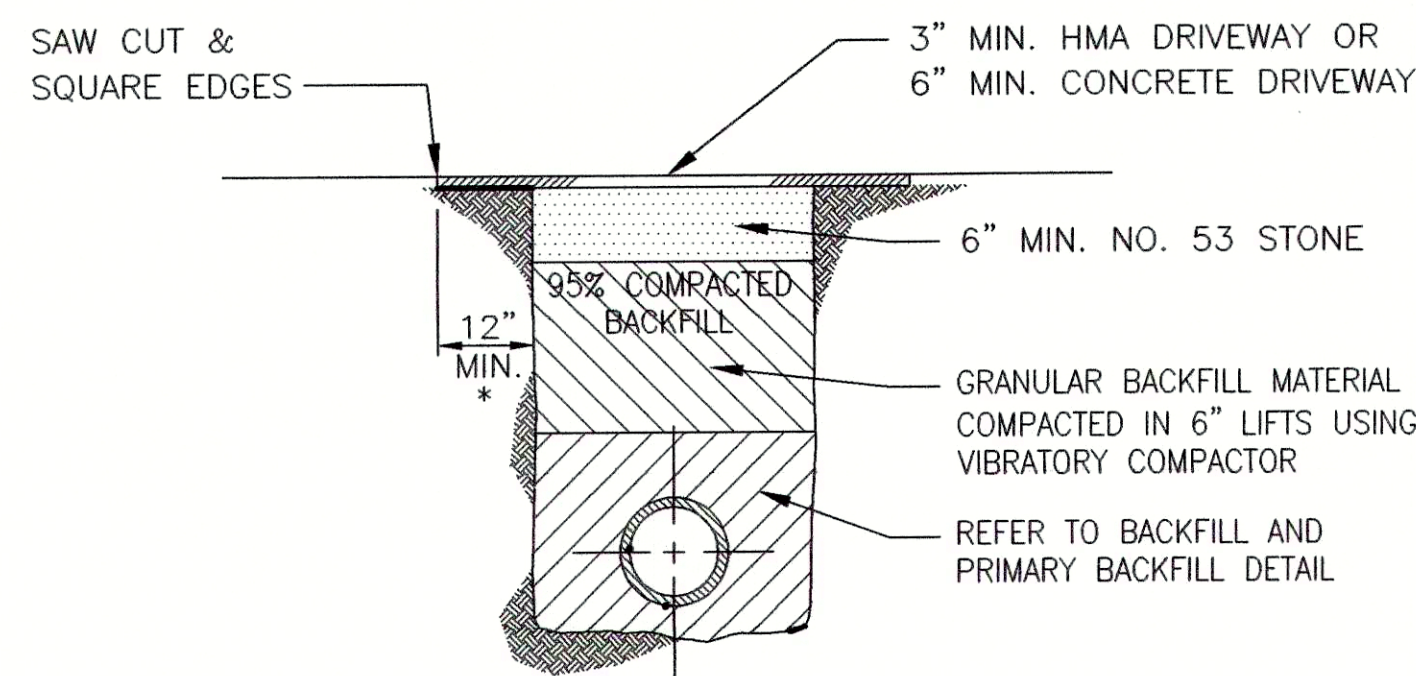

PAVED DRIVEWAYS - METHOD "D1"


SCALE: N.T.S.

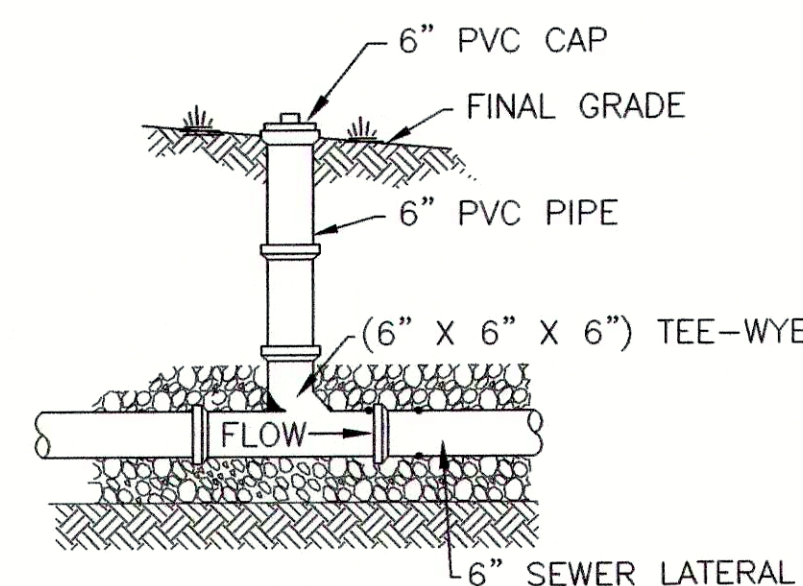

TYPE I - LANDSCAPE CLEANOUT DETAIL

SCALE: N.T.S.


NOTE: FOR PRIVATE LATERAL REPLACEMENTS, CLEANOUT SHALL BE WITHIN 5 FT. OF THE HOME AND EVERY 100 FT.

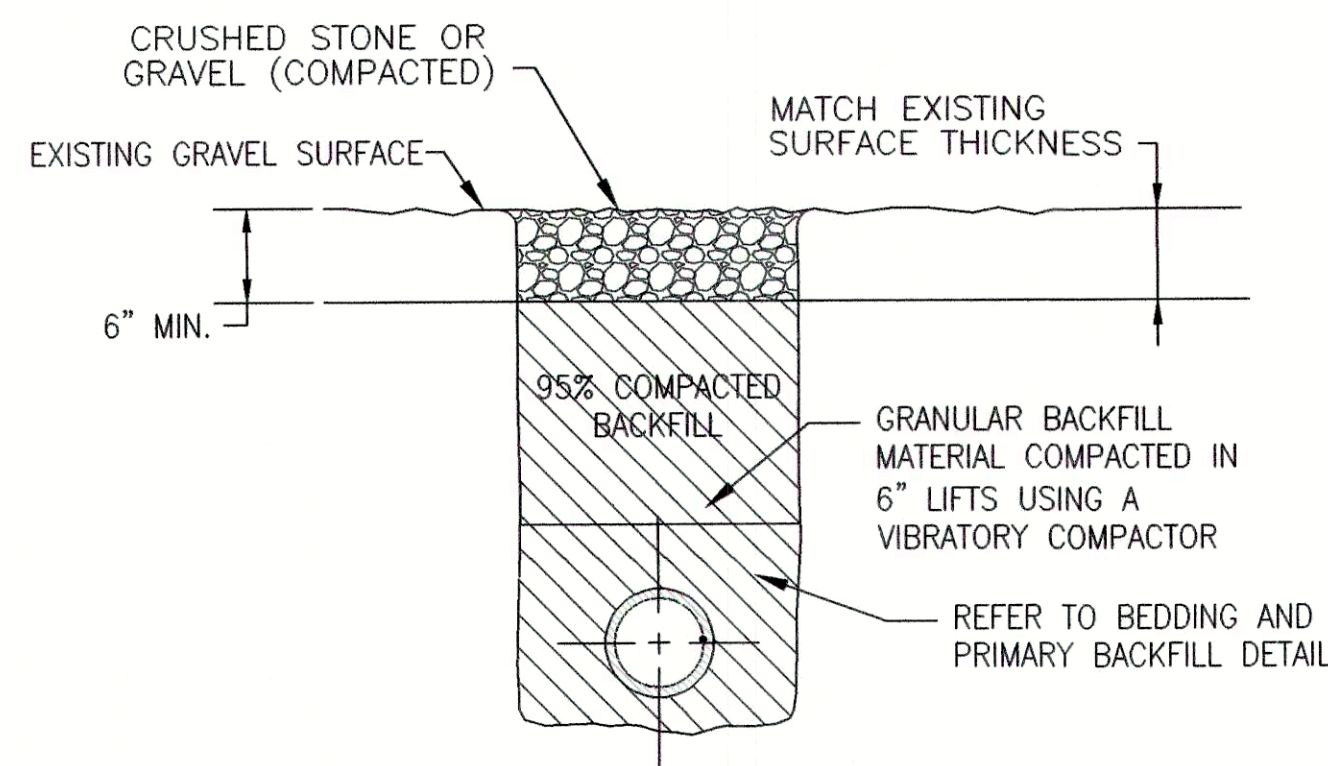

GRAVEL DRIVEWAYS - METHOD "B"


SCALE: N.T.S.

NOTES:
1.) GRANULAR BACKFILL MECHANICAL COMPACTION TO 95% PROCTOR DENSITY UNDER OR WITHIN 5 FEET OF PAVEMENT.

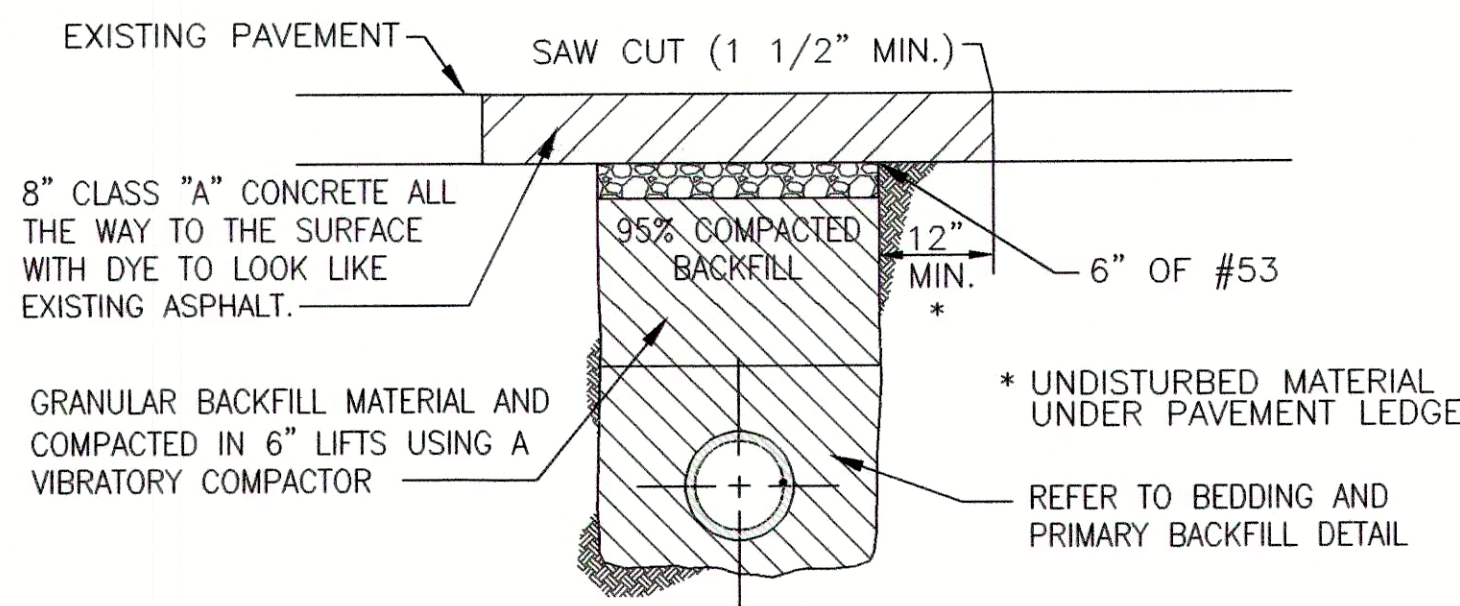


PAVED ALLEY DETAIL - METHOD "C1"

SCALE: N.T.S.

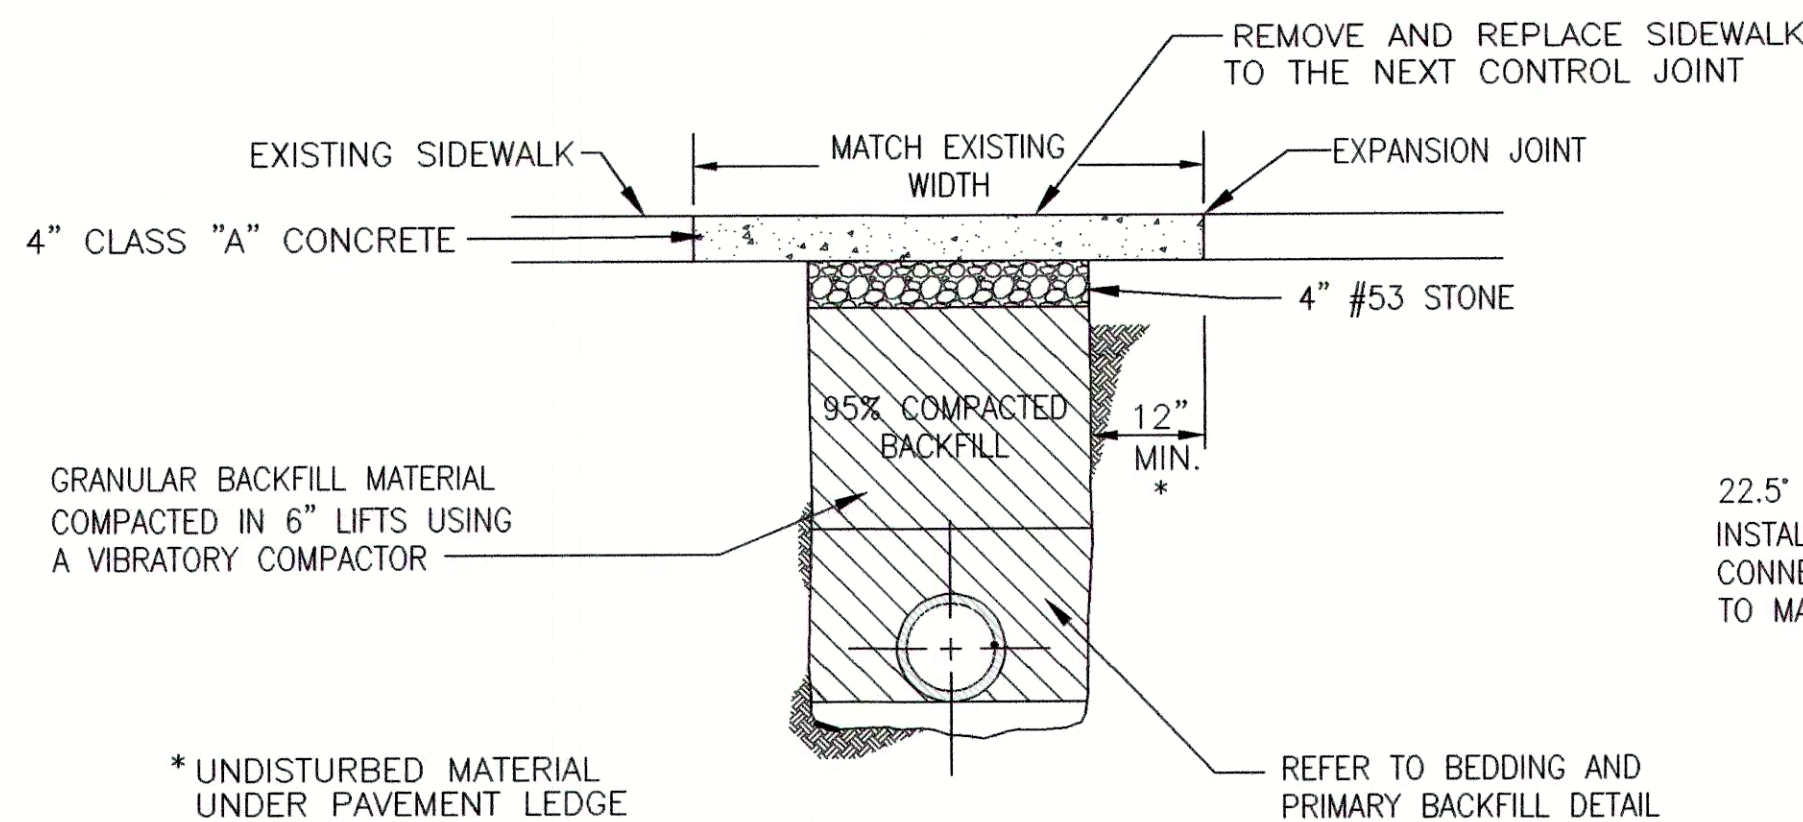


CONCRETE SIDEWALKS - METHOD "D2"

SCALE: N.T.S.

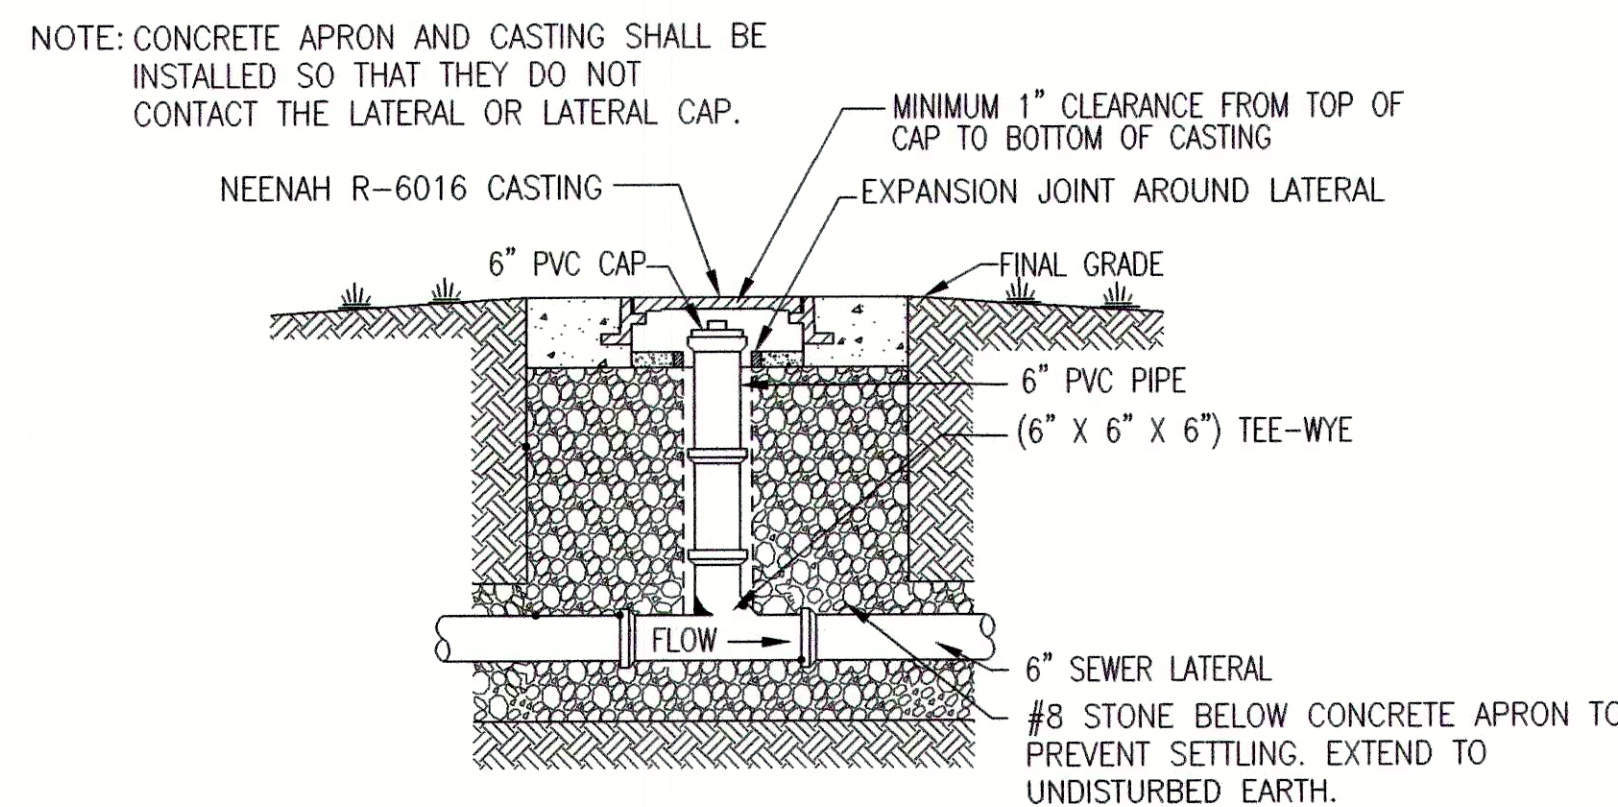


TYPE II - HARDSCAPE CLEANOUT DETAIL

SCALE: N.T.S.

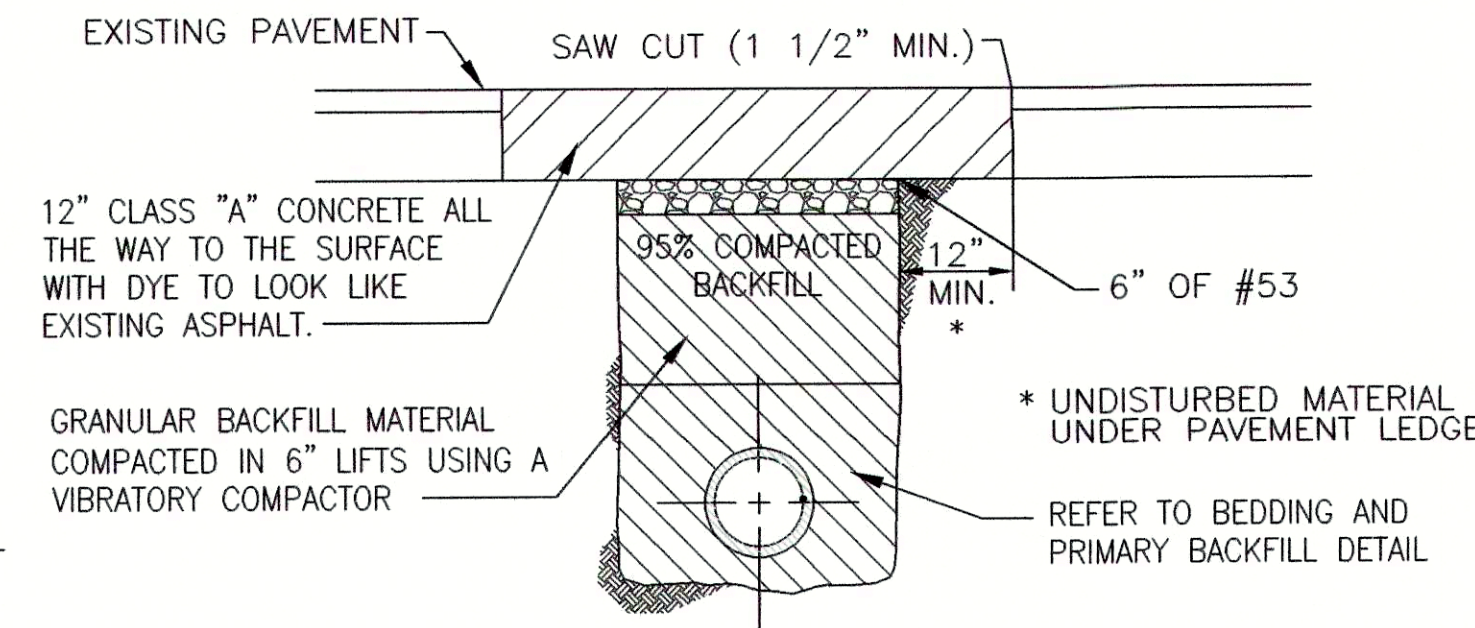


ROADWAYS DETAIL - METHOD "C"

SCALE: N.T.S.

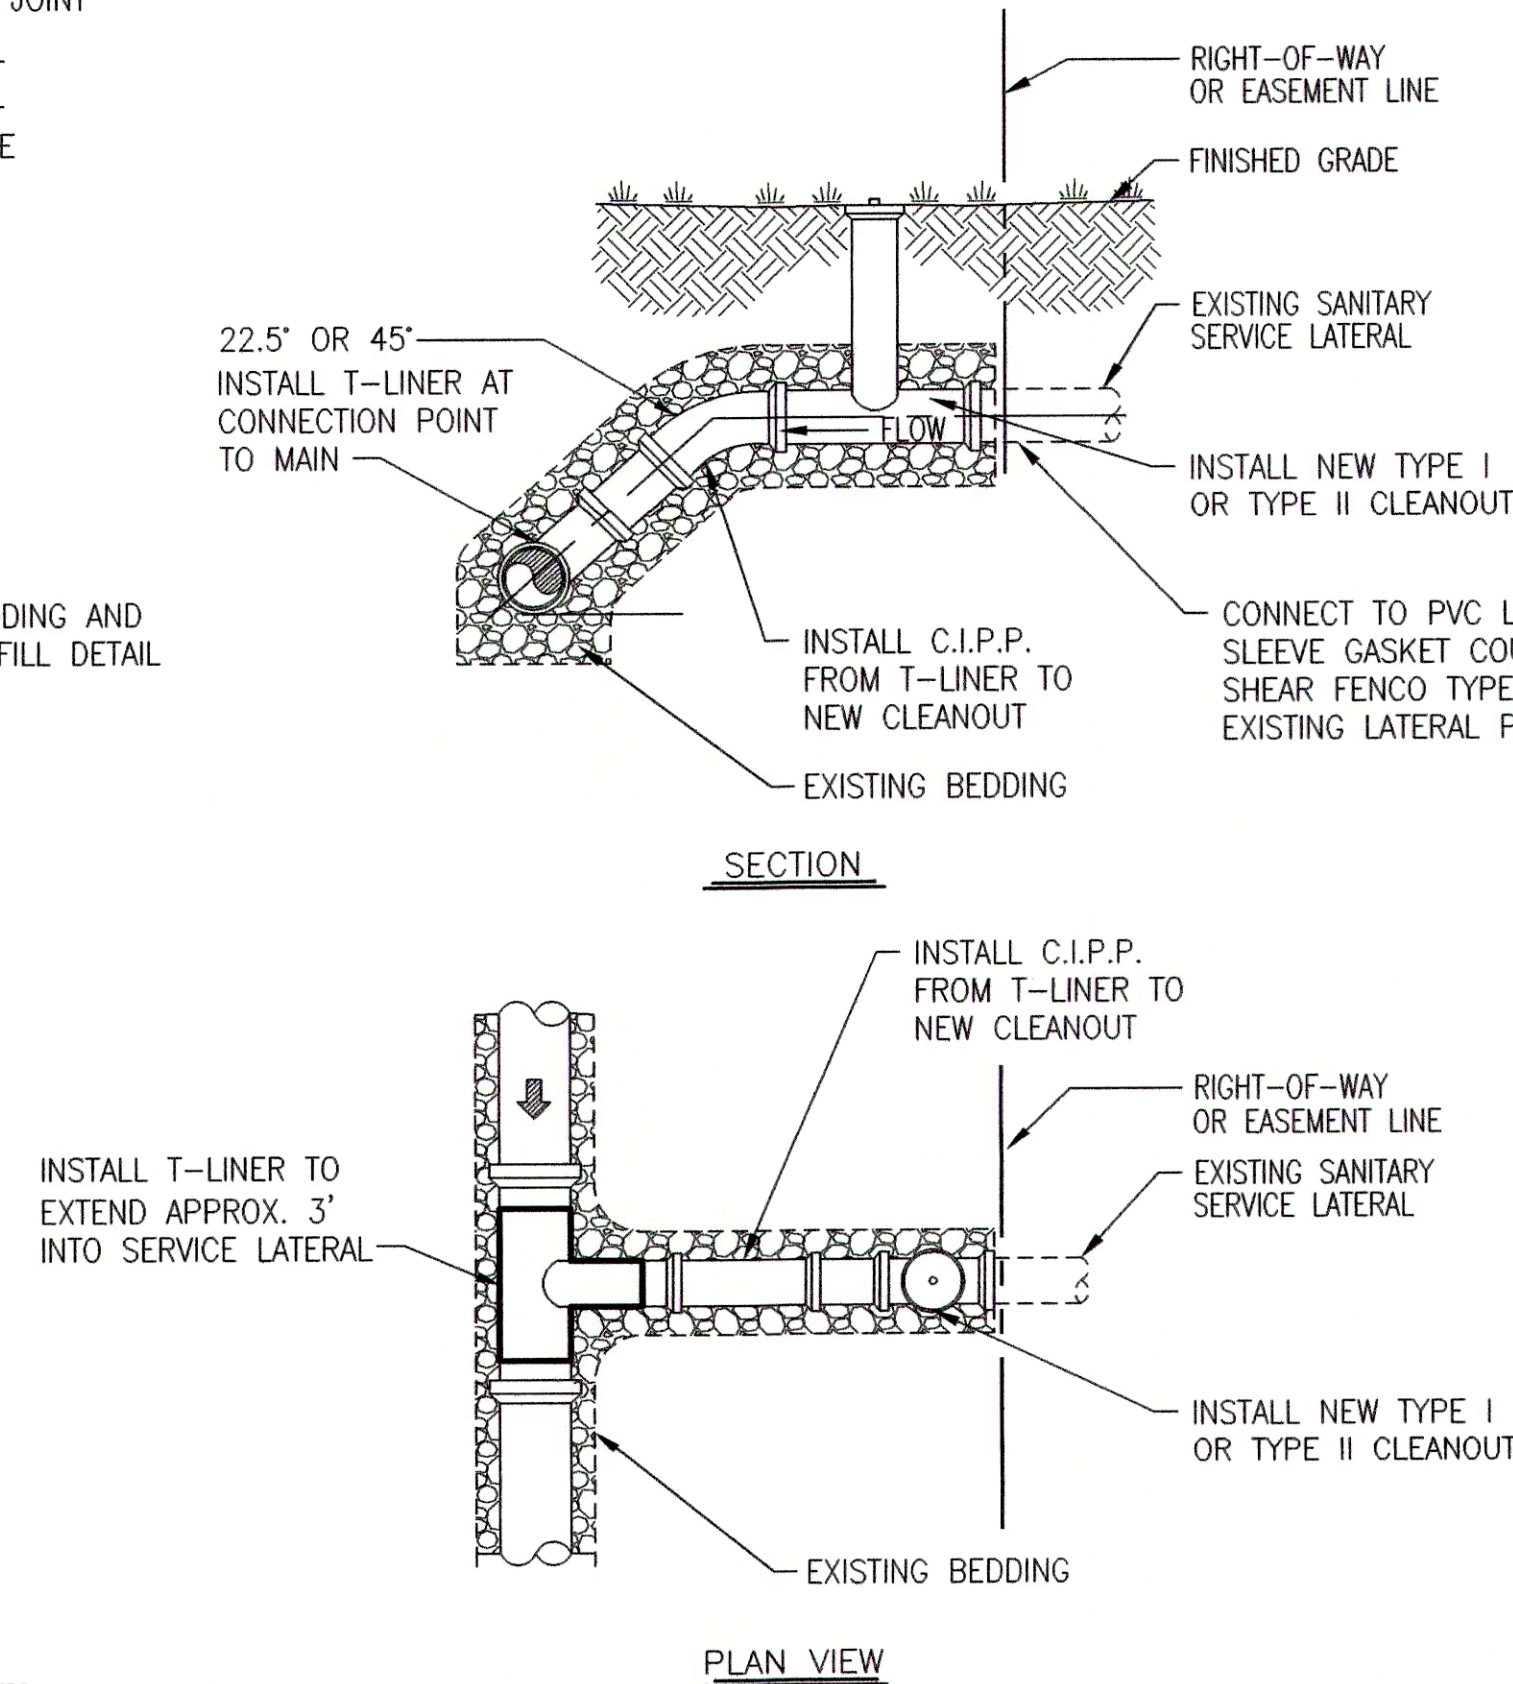

CIPP SERVICE LATERAL LINING DETAILS


SCALE: N.T.S.

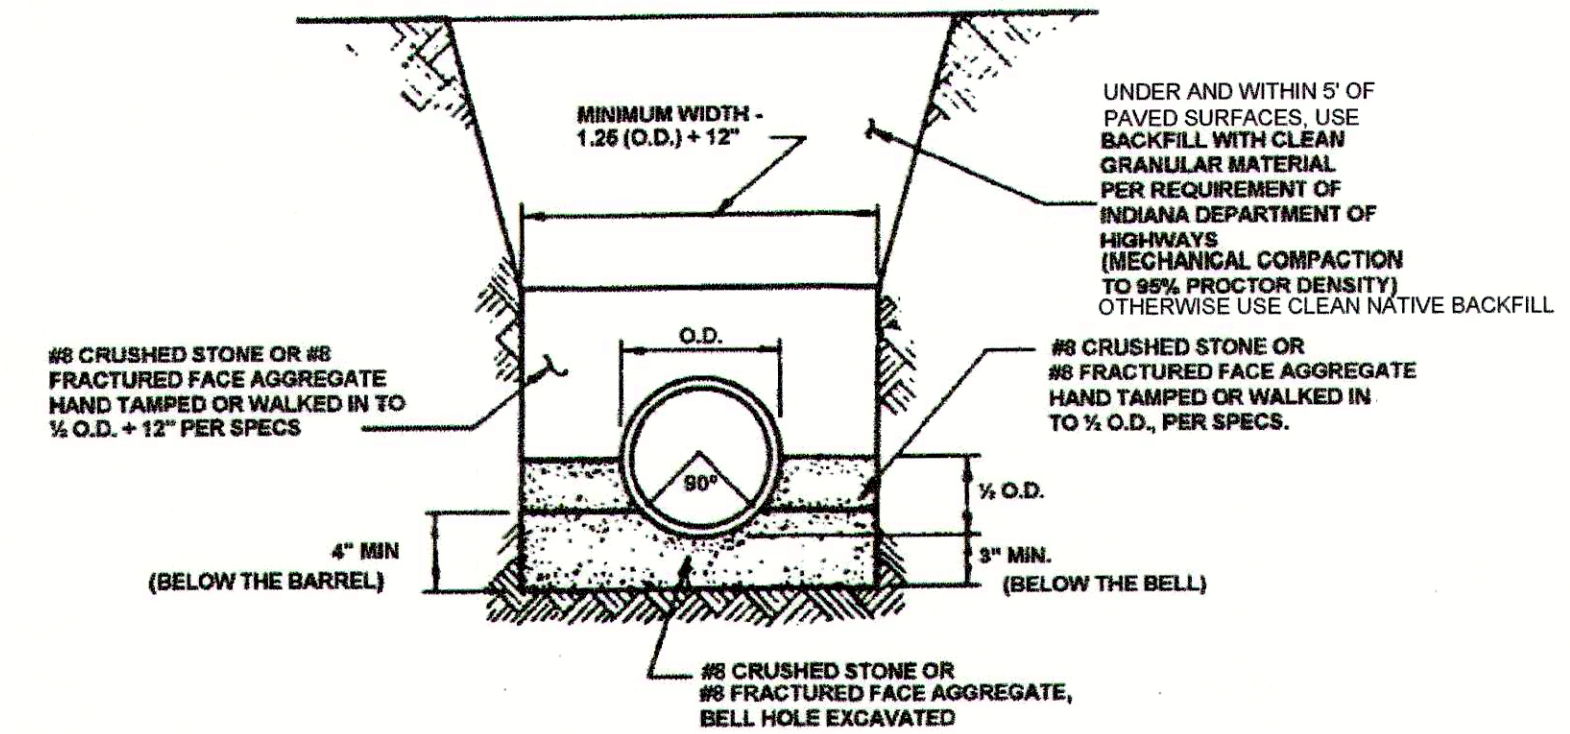


FLEXIBLE PIPE BEDDING DETAIL - PVC AND HDPE PIPE

SCALE: N.T.S.

PIPE SIZE	8" TO 15"	16" & OVER
BEDDING BELOW THE PIPE BARREL	O.D. / 4 MIN. = 4"	O.D. / 4 MAX. = 6"

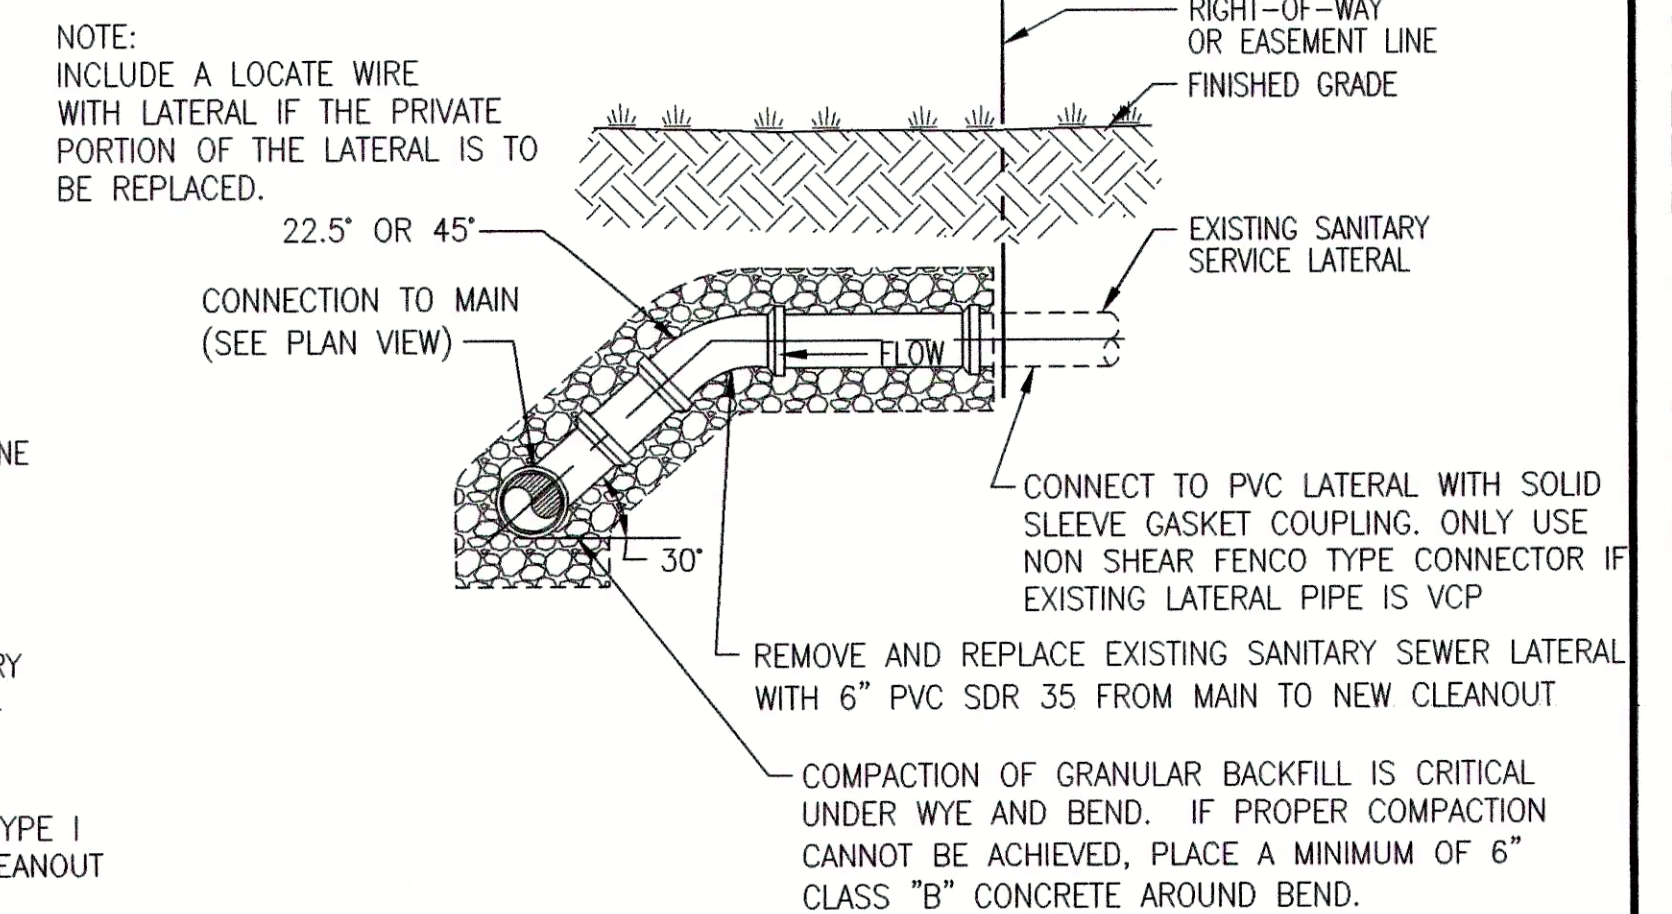

SECTION

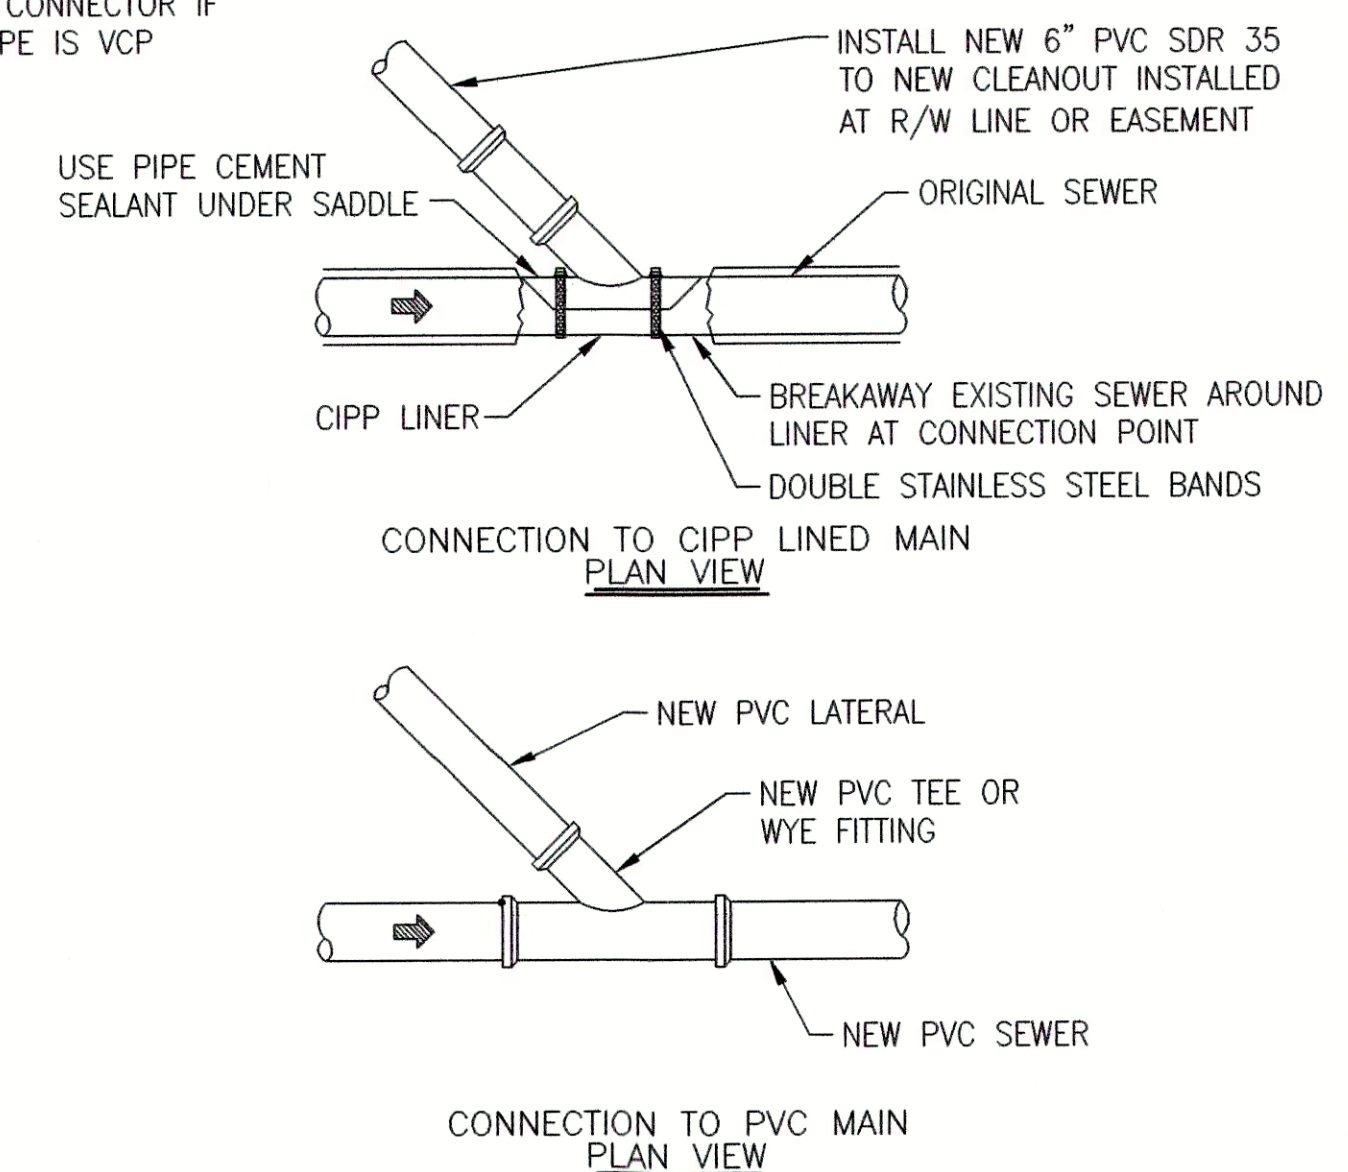


CONNECTION TO PVC MAIN

DIG AND REPLACE SERVICE LATERAL DETAILS


SCALE: N.T.S.

DESIGNED	GWL	GC	JPT	JPT
DATE	DATE	DATE	DATE	DATE
BY	BY	BY	BY	BY
DATE	DATE	DATE	DATE	DATE
DESCRIPTION	DESCRIPTION	DESCRIPTION	DESCRIPTION	DESCRIPTION
NO.	NO.	NO.	NO.	NO.

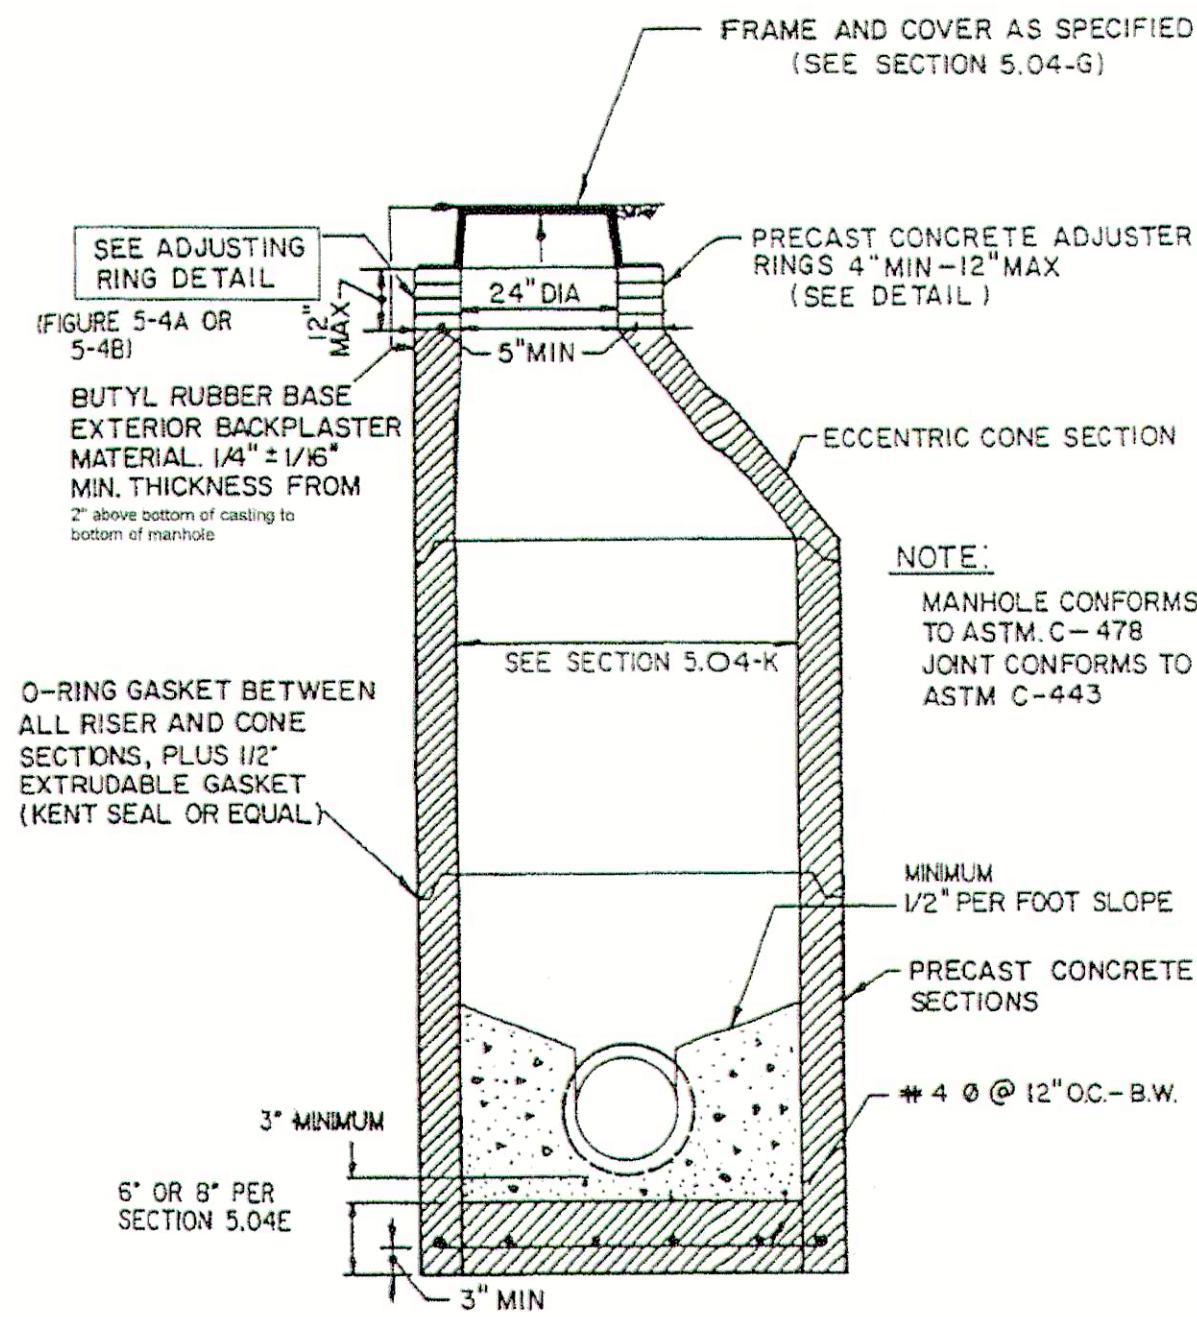


STANDARD MANHOLE FOR PIPE
SIZES 8" - 24" (STRAIGHT THRU)

FIGURE 5-1

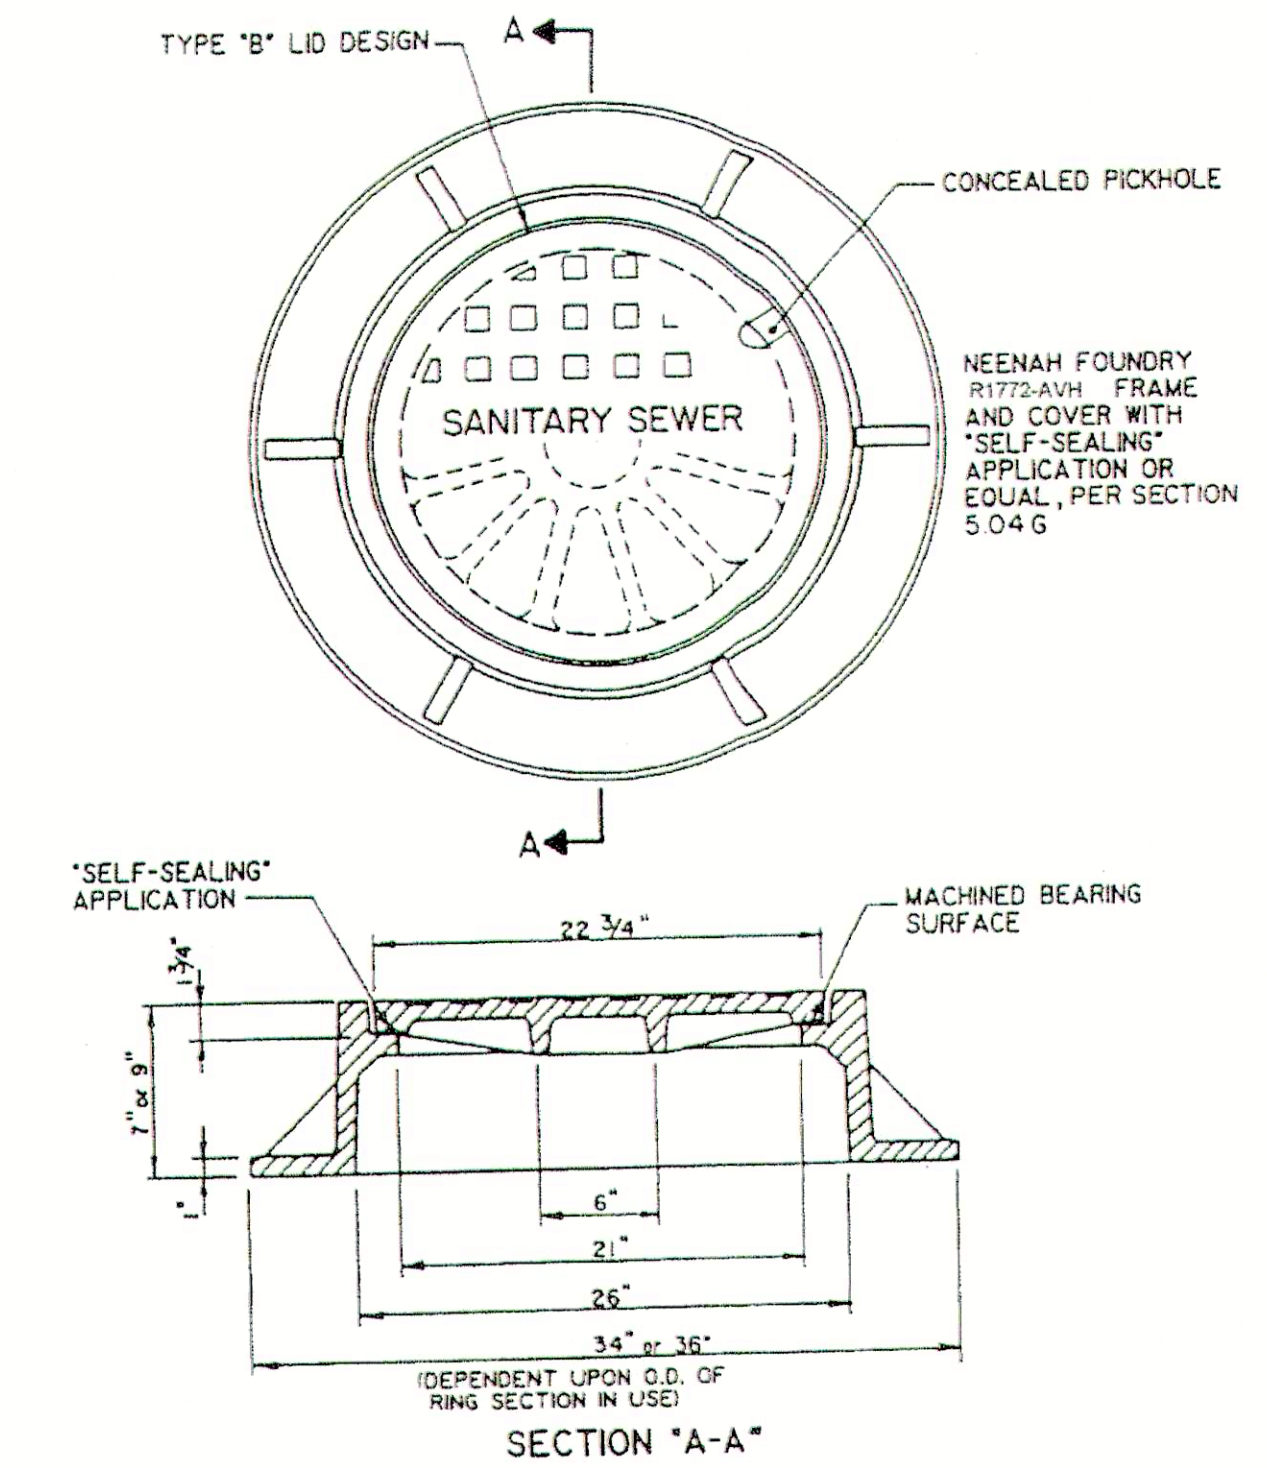


SANITARY SEWER MANHOLE
FRAME & COVER - STANDARD MANHOLE

FIGURE 5-7

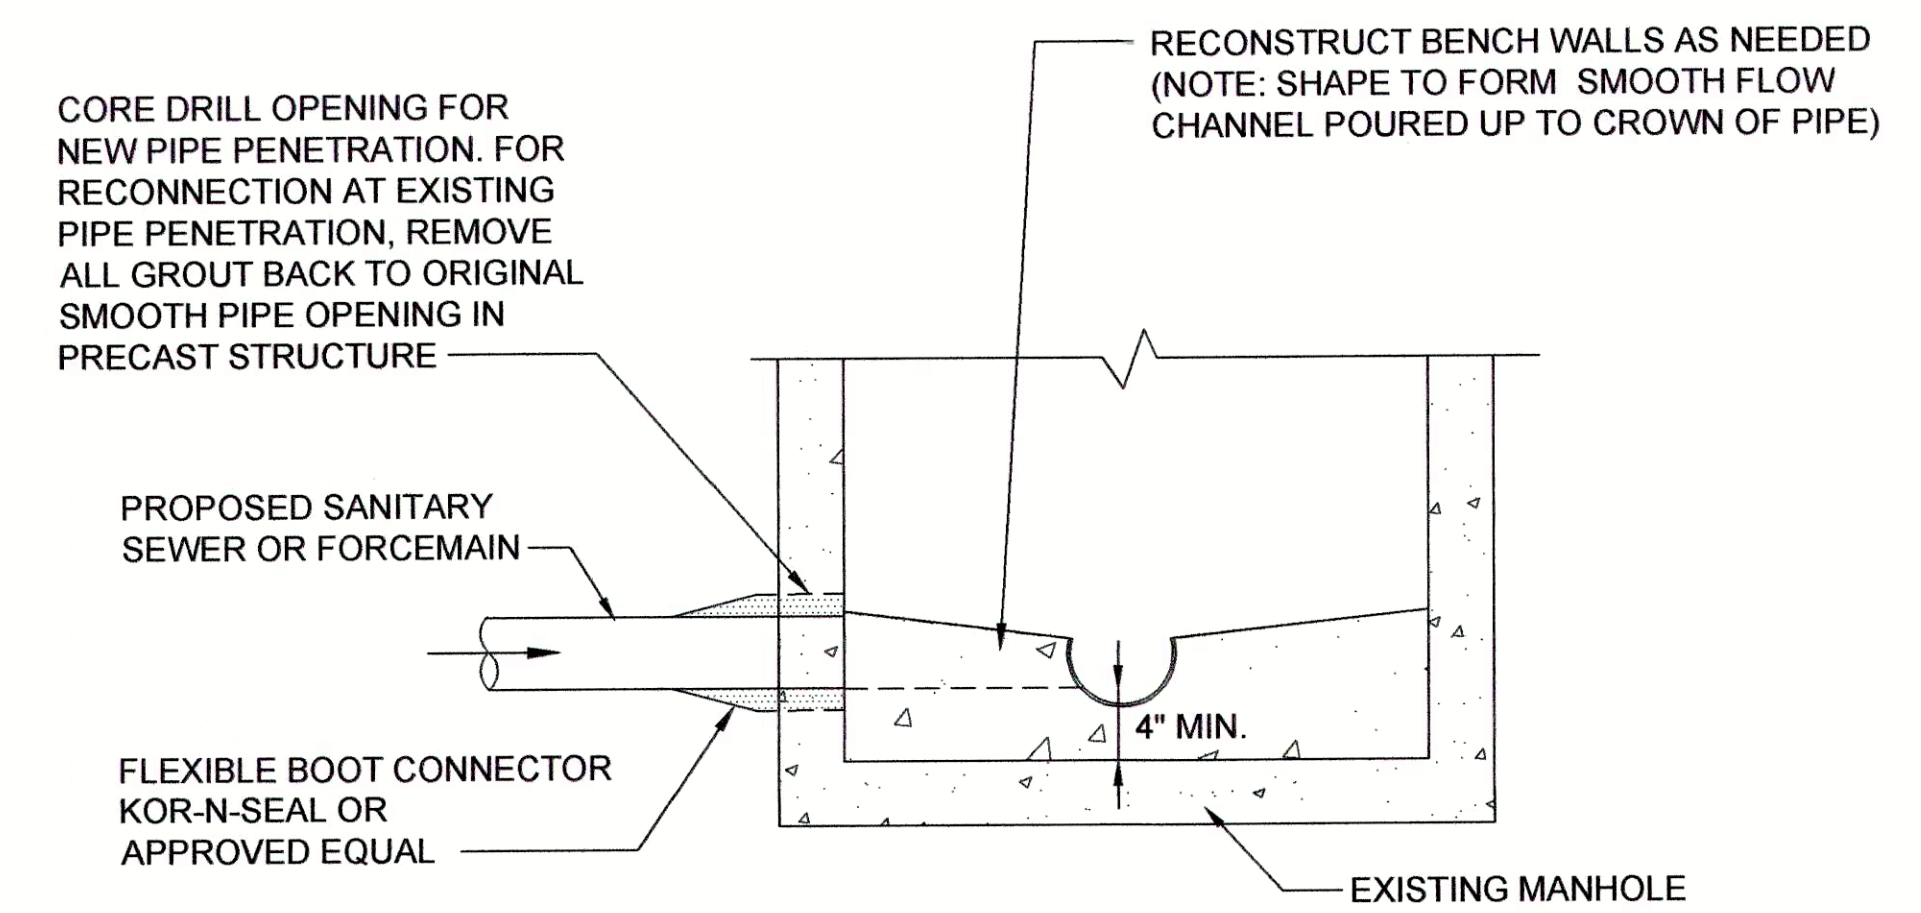

EXISTING MANHOLE CONNECTION DETAIL
NOT TO SCALE

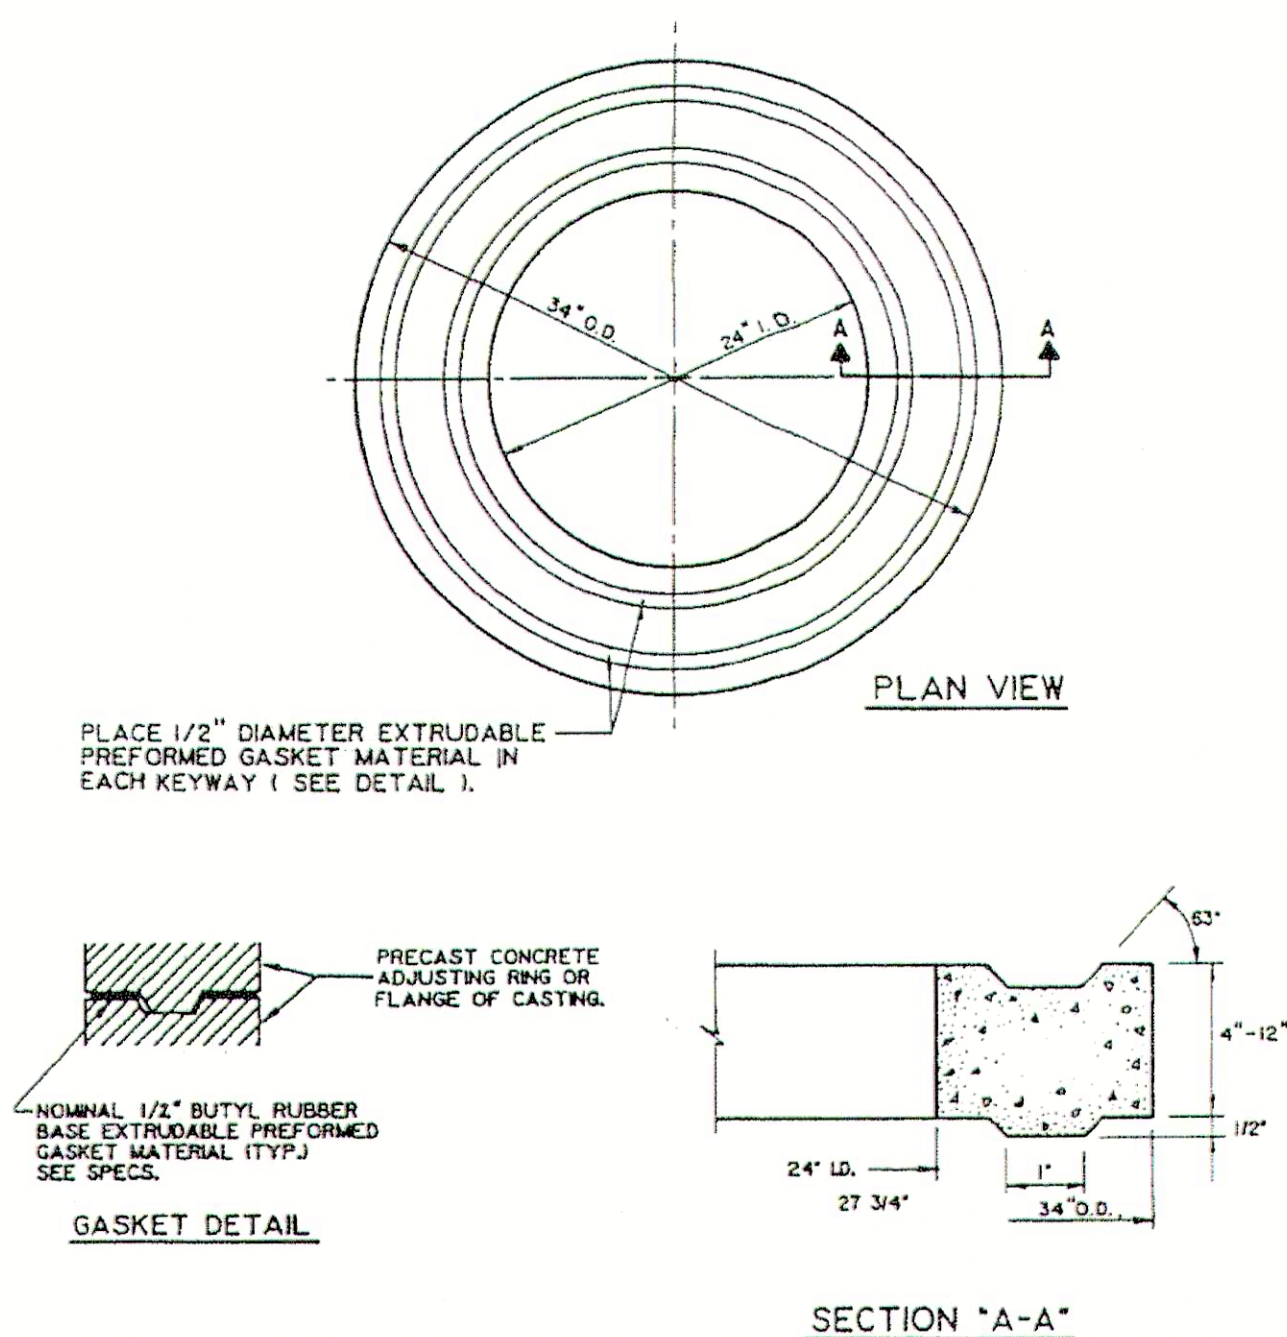

ADJUSTING RING

FIGURE 5-48

SEWER POINT REPAIR NOTES (IF REQUIRED & APPROVED BY OWNER):

1. PRIOR TO CIPP INSTALLATION, CONTRACTOR SHALL PERFORM DIG-UP & REPLACE POINT REPAIR WITH NEW PVC SDR-35 PIPE CONFORMING TO A.S.T.M. D3034 WITH A.S.T.M. 3212 BELL AND SPIGOT RUBBER GASKETED JOINTS. POINT REPAIR SHALL EXTEND A MINIMUM OF ONE FULL PIPE JOINT BEYOND EITHER SIDE OF REPAIR LOCATION, NOT TO EXCEED 10FT. TOTAL LENGTH. JOIN NEW PIPE SECTION WITH EXISTING PIPE USING NON-SHEAR TYPE FERNCO COMPRESSION COUPLINGS; OR EQUAL, MEETING THE REQUIREMENTS OF A.S.T.M. C425 AND SUITABLE FOR THE SERVICE IN WHICH IT IS INTENDED. BANDS SHALL BE SERIES 300 STAINLESS STEEL CONFORMING TO A.S.T.M. A240.
2. REFER TO DETAILS ON SHEET C-16 FOR PIPE BEDDING, BACKFILL, AND SURFACE RESTORATION REQUIREMENTS.
3. SHOULD SEWER POINT REPAIR VARY SIGNIFICANTLY FROM DESCRIPTION ABOVE, ITEM SHALL BE NEGOTIATED THROUGH THE CHANGE ORDER PROCESS.

JOSEPH P. TIERNY
REGISTERED
No. 19300407
STATE OF INDIANA
PROFESSIONAL ENGINEER

GRW PROJECT NO. 4447-14

SRF NO. WW0074803

ALL RIGHTS RESERVED. PROPERTY OF GRW ENGINEERS, INC. AND SHALL NOT BE REPRODUCED OR TRANSMITTED IN ANY FORM OR BY ANY MEANS, ELECTRONIC OR MECHANICAL, INCLUDING PHOTOCOPYING, RECORDING, OR BY ANY INFORMATION STORAGE AND RETRIEVAL SYSTEM, WITHOUT THE WRITTEN PERMISSION OF GRW ENGINEERS, INC.

engineering | architecture | geospatial
www.grwinc.com

FALL CREEK STANDARD DETAILS
SANITARY SEWER REHABILITATION
FALL CREEK REGIONAL WASTE DISTRICT
PENDLETON, INDIANA

REVISIONS		DESIGNED		DRAWN		REVIEWED		APPROVED	
		NO.	DATE	BY	DATE	BY	DATE	BY	DATE

DATE: APRIL 2016

SCALE: N.T.S.

SHEET NO.

SCALE CHECK: THIS MARK SHOULD MEASURE EXACTLY 1" WHEN PLOTTED

C-17

During all phases of construction the site general contractor and all sub-contractors shall exercise measures to prevent the erosion of soils due to the action of water and wind. The contractors shall use the following measures to accomplish this objective:

1. Clearing shall be limited so as to expose the smallest possible area of land for the shortest possible time.
2. Exposed areas shall be immediately graded and protected with temporary or permanent cover, such as sod, seed and mulch, crown vetch, lespedeza or creeper. Newly graded channels or steep slopes will require the use of fibrous matting, netting of seeded and mulched areas, or the staking or shingling of sod while vegetation is becoming established.

1. Long and/or steep slopes will require contour benching and furrowing, or berms to reduce run-off velocities.

 
1. The trapping of eroded particles will be accomplished by the diversion of run-off to sediment basins, excavation traps, berms, staked hay bales, or floating silt curtains.
2. The proposed retention and/or detention pond(s) along with any environmental berm(s)/fear yard and swale(s) shall be constructed first. The pond(s) and outfall structure(s) must be complete and operational prior to the placement of any impervious surface.
3. Trapping devices shall be periodically inspected during dry periods and after each rainfall event by the site contractor. Trapping devices shall be replaced if determined to be incapable of performing intended function of sediment trapping.
4. Trapping devices shall remain in place until a vegetative cover has established sufficiently to stabilize the soils and prevent erosion.

1. The contractor shall have available on the construction site a water source capable of applying water to dry exposed soil in order to prevent wind erosion. The application rate and manner shall be such that soil moisture is attained and no surface run-off is created.

1. The contractor shall be held responsible until the Certificate of Completion is issued. After that, the Owner will be responsible for maintenance of the stormwater collection and detention system.



SCALE: N.T.S



SCALE: N.T.S



SCALE: N.T.S.

STABILIZATION PRACTICE	JAN.	FEB.	MAR.	APR.	MAY	JUN.	JUL.	AUG.	SEP.	OCT.	NOV.	DEC.
PERMANENT SEEDING				A	*////////N/////////*							
DORMANT SEEDING	B										B	
TEMPORARY SEEDING				C					D			
SODDING				E**								
MULCHING	F											

A = INDOT SEED MIXTURE TYPE "R" - 170 LBS/ACRE
PLUS 2 TONS STRAW MULCH/ACRE.

B = KENTUCKY BLUEGRASS 60 LBS/ACRE; CREEPING RED FESCUE 60 LBS/ACRE;
PLUS 2 TONS STRAW MULCH/ACRE, OR ADD ANNUAL RYEGRASS 30 LBS/ACRE.

C = INDOT SEED MIXTURE TYPE "T" SPRING OATS - 150 LBS/ACRE

D = INDOT SEE MIXTURE TYPE "T" WINTER WHEAT - 150 LBS/ACRE

E = SOD

 
F = STRAW MULCH 2 TONS/ACRE

*/././ IRRIGATION NEEDED DURING JUNE, JULY, AND/OR AUGUST.

** IRRIGATION NEEDED FOR 2 TO 3 WEEKS AFTER APPLYING SOD.



NOTE: FIBER ROLLS OR COMMERCIAL SILT CHECK PRODUCTS MAY BE USED.
INSTALL IN SIMILAR MANNER. TIE EDGES INTO SIDES AND TOP OF BANK.



SCALE: N.T.S.

MADISON EMERGENCY MANAGEMENT AGENT: (765) 642-0221

SCALE: N.T.S

NOTE: REGULAR SILT FENCE WITHOUT WIRE FENCING TO BE INSTALLED IN SAME MANNER.

PRINTED: 6/24/2016 @ 12:05PM

FILE NAME: G:\4447-FCRWD-2019\Working Drawings\AutoCAD\REHABILITATION PHASE (M447-14-C-19-MOT.dwg

NOTES:

1. FOR LOW-VOLUME SITUATIONS WITH SHORT WORK ZONES ON STRAIGHT ROADWAYS WHERE THE FLAGGER IS VISIBLE TO ROAD USERS APPROACHING FROM BOTH DIRECTIONS, A SINGLE FLAGGER, POSITIONED TO BE VISIBLE TO ROAD USERS APPROACHING FROM BOTH DIRECTIONS, MAY BE USED.
2. THE "ROAD WORK AHEAD" AND THE "END ROAD WORK" SIGNS MAY BE OMITTED FOR SHORT-DURATION OPERATIONS.
3. FLASHING WARNING LIGHTS AND/OR FLAGS MAY BE USED TO CALL ATTENTION TO THE ADVANCE WARNING SIGNS. A "BE PREPARED TO STOP" SIGN MAY BE ADDED TO THE SIGN SERIES.
4. THE BUFFER SPACE SHOULD BE EXTENDED SO THAT THE TWO-WAY TRAFFIC TAPER IS PLACED BEFORE A HORIZONTAL (OR CREST VERTICAL) CURVE TO PROVIDE ADEQUATE SIGHT DISTANCE FOR THE FLAGGER AND A QUEUE OF STOPPED VEHICLES.
5. AT NIGHT, FLAGGER STATIONS SHALL BE ILLUMINATED, EXCEPT IN EMERGENCIES.
6. WHEN USED, THE "BE PREPARED TO STOP" SIGN SHOULD BE LOCATED BETWEEN THE "FLAGGER" SIGN AND THE "ONE LANE ROAD" SIGN.

FOR HIGH SPEED URBAN CONDITIONS *


A=350 FT.
B=350 FT.
C=350 FT.
L=350 FT.

FOR LOW SPEED URBAN CONDITIONS *

A=100 FT.
B=100 FT.
C=100 FT.
L=350 FT.

* SPEED CATEGORY SHALL BE DETERMINED BY HIGHWAY AGENCY

NOTE: TRAFFIC CONTROL PLANS ARE GUIDELINES ONLY. ALL TRAFFIC CONTROL PLANS AND LANE CLOSURES MUST BE APPROVED BY THE APPROPRIATE AGENCY.
TOWN OF PENDLETON: (765) 778-2173

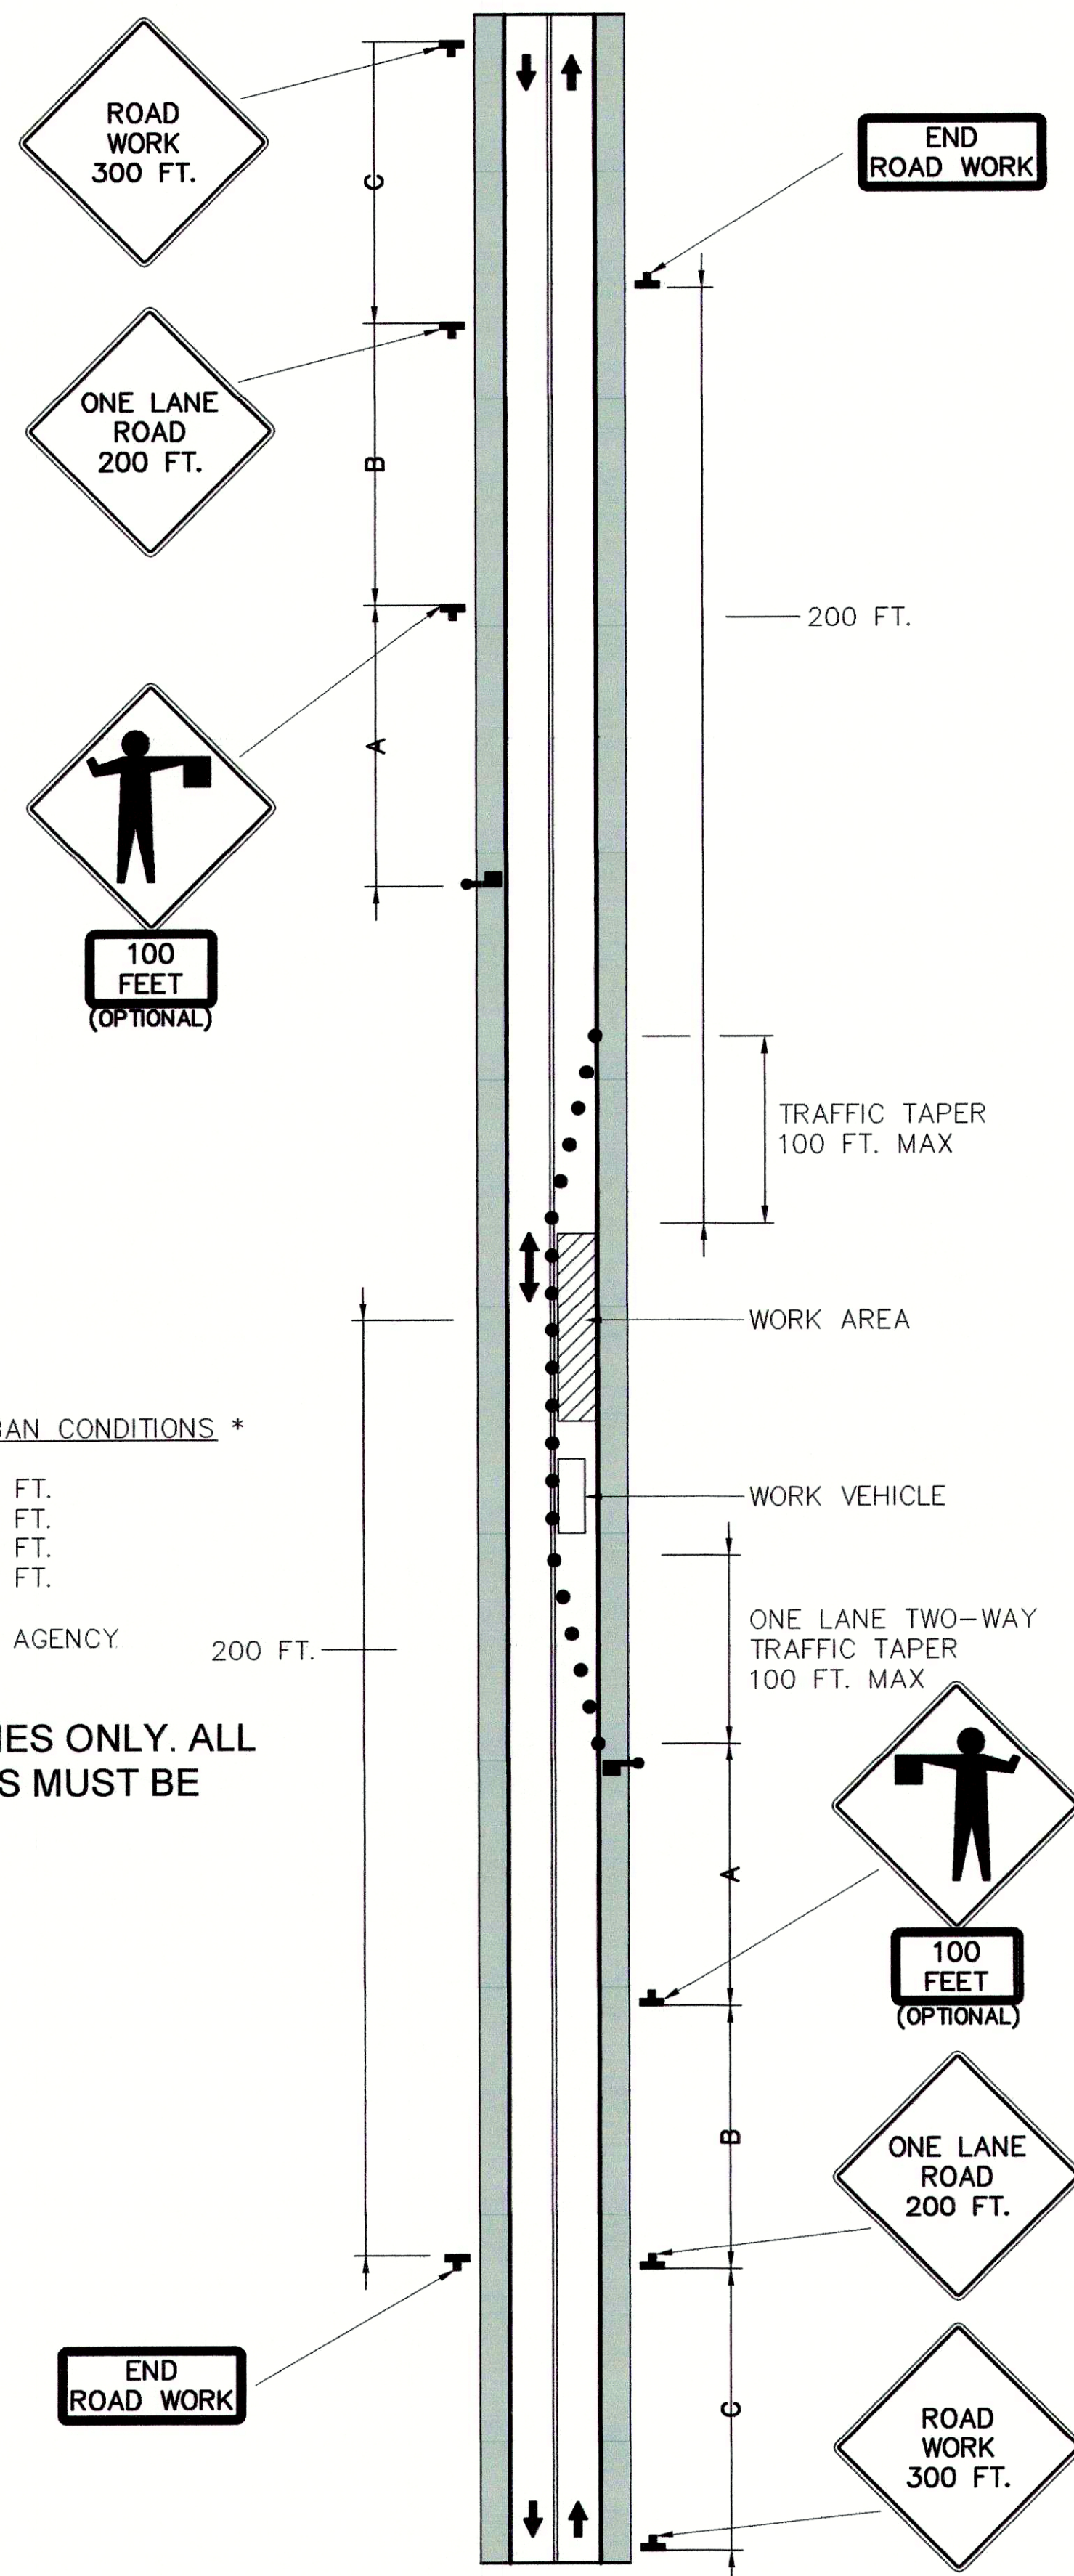

DETAIL - TRAFFIC CONTROL PLAN (AT TWO LANE ROAD)

SCALE: N.T.S.


NOTES:

1. FLASHING WARNING LIGHTS AND/OR FLAGS MAY BE USED TO CALL ATTENTION TO THE ADVANCE WARNING SIGNS. A "BE PREPARED TO STOP" SIGN MAY BE ADDED TO THE SIGN SERIES.
2. FOR MORE DETAILED DRAWINGS AND NOTES, SEE INDOT DETAILS E 801-TCLC-07 AND E 801-TCLG-01.
3. THIS IS APPLICABLE TO THE WORK PLANNED ALONG S.R. 67 - POSTED SPEED LIMIT 40 MPH.
4. FOR ALL LOCAL STREET AND ALLEY CLOSURES, SEE INDOT "URBAN DETOUR" DETAIL E 801-TCDT-02 (THIS SHEET) AND DETAIL E 801-TCDT-03.

LEGEND

■	SIGN
●	CHANNELIZING DEVICE

NOTE: TRAFFIC CONTROL PLANS ARE GUIDELINES ONLY. ALL TRAFFIC CONTROL PLANS AND LANE CLOSURES MUST BE APPROVED BY THE APPROPRIATE AGENCY.
LOCAL INDOT: (317) 467-3426
TOWN OF PENDLETON: (765) 778-2173

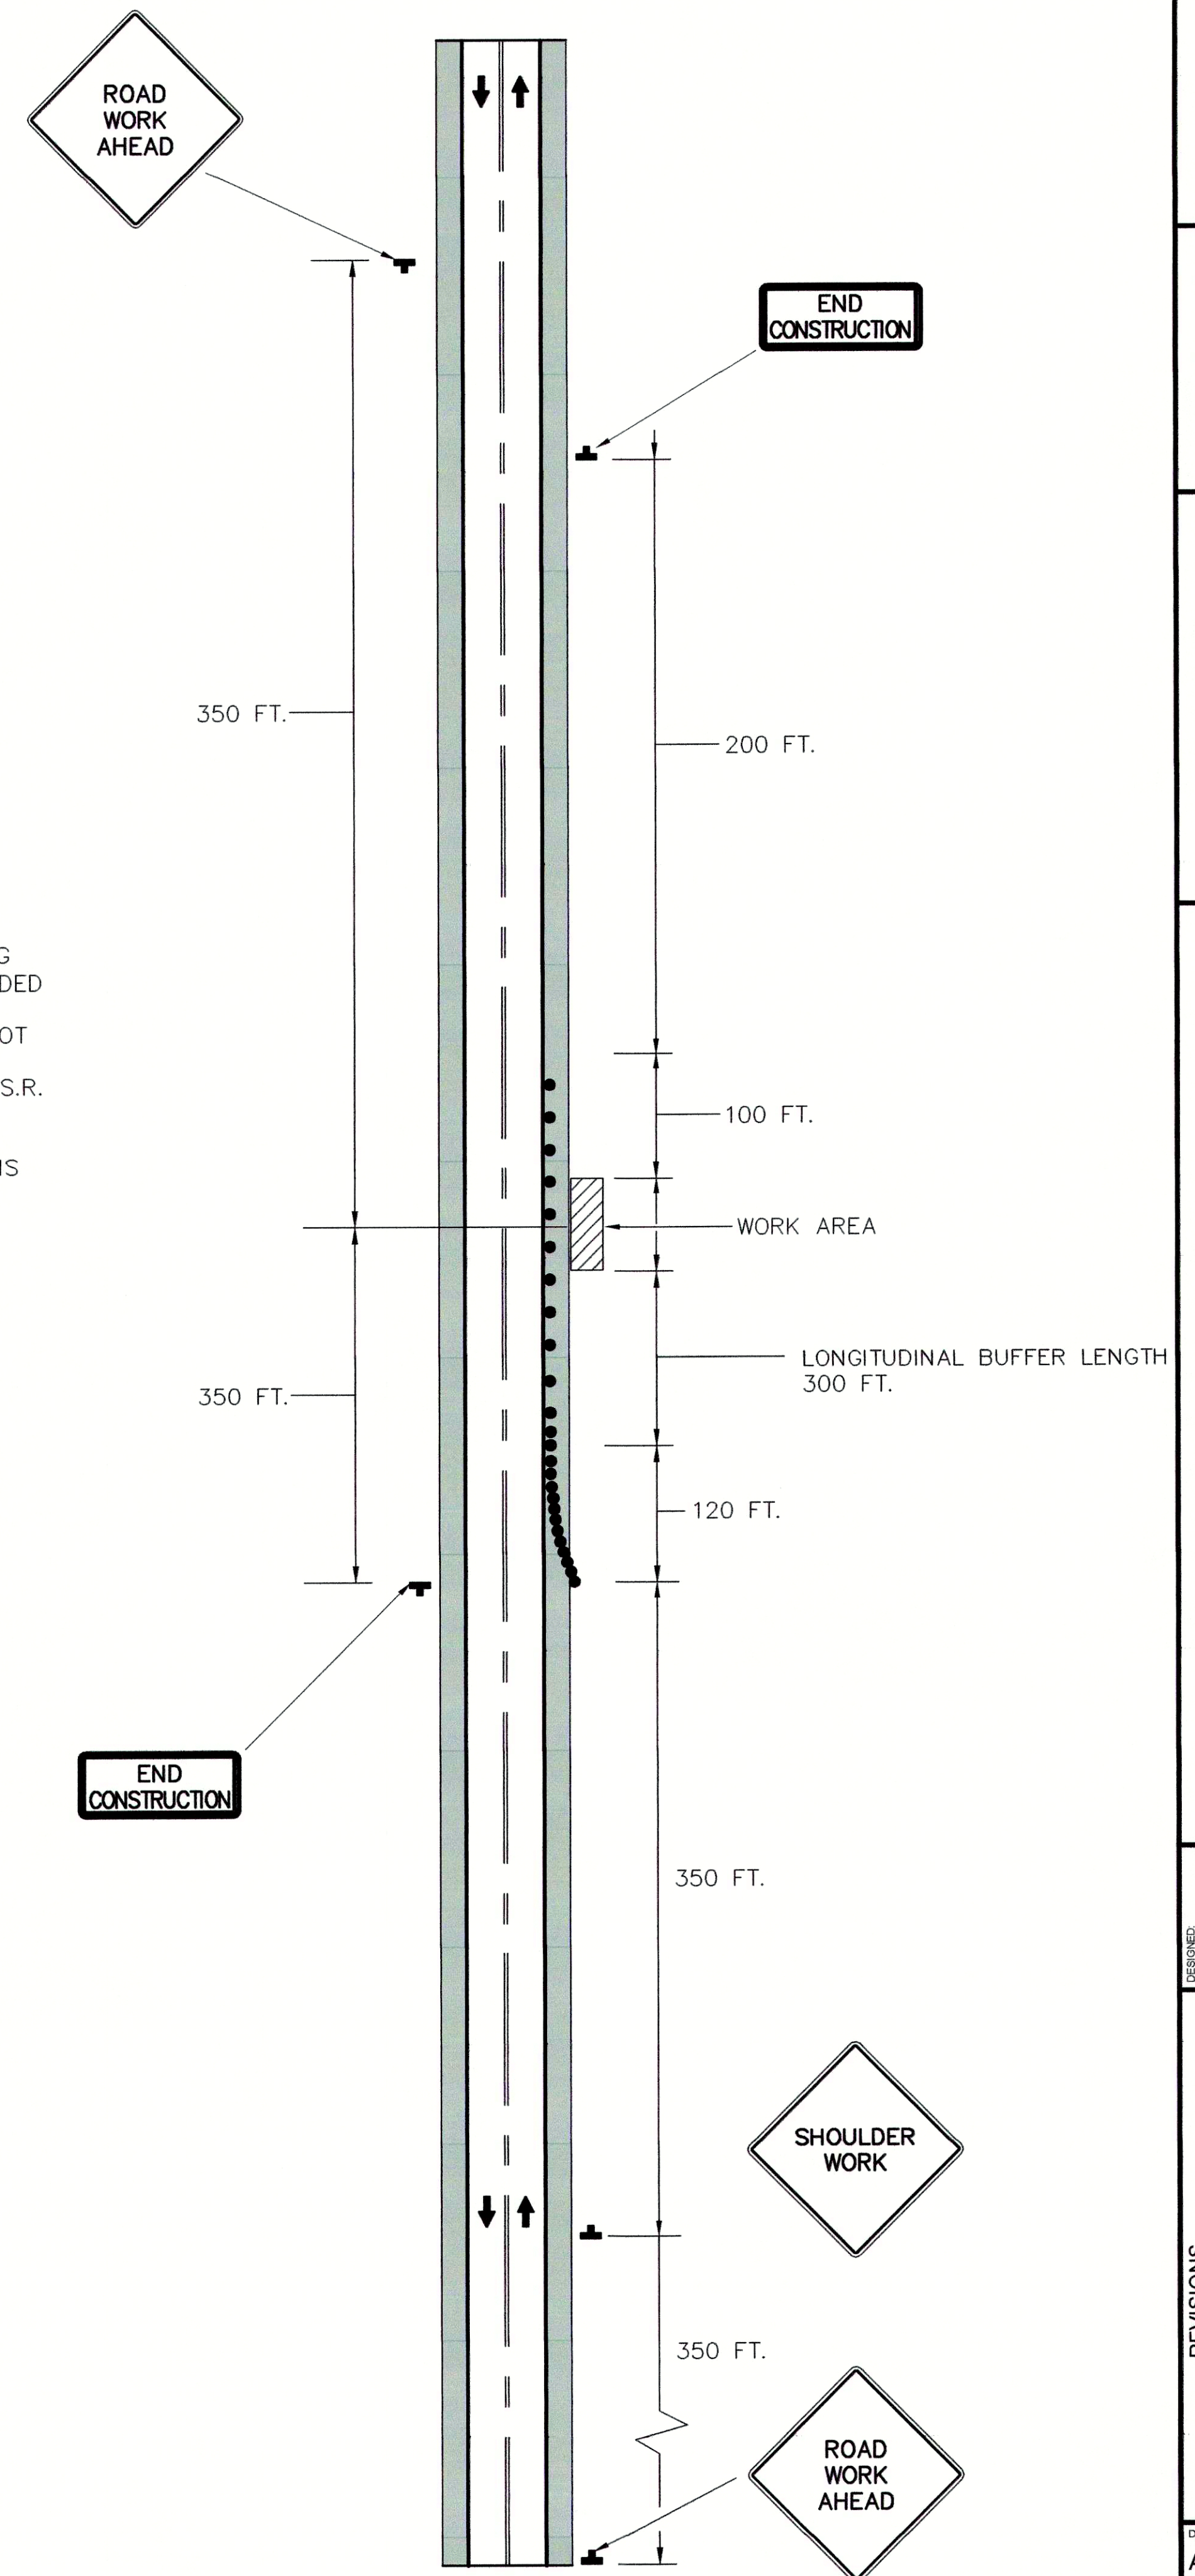


DETAIL - TRAFFIC CONTROL PLAN FOR SHOULDER WORK
ON TWO-LANE TWO-WAY HIGHWAY

SCALE: N.T.S.

JOSEPH P. TIERNEY REGISTERED No. 19300407 STATE OF INDIANA PROFESSIONAL ENGINEER	
GRW PROJECT NO. 4447-14	SRF NO. WW16074803
ALL RIGHTS RESERVED. PROPERTY OF GRW ENGINEERS, INC. AND SHALL NOT BE REPRODUCED OR USED FOR CONSTRUCTION OF ANY PROJECT WITHOUT WRITTEN PERMISSION.	
GRW engineering architecture geospatial www.grwinc.com	
MAINTENANCE OF TRAFFIC SANITARY SEWER REHABILITATION FALL CREEK REGIONAL WASTE DISTRICT PENDLETON, INDIANA	
DESIGNED GWL	DRAWN GCR
REVIEWED GWL	APPROVED JPT
NO.	DATE
DESCRIPTION	DATE
THIS MARK SHOULD MEASURE EXACTLY WHEN PLOTTED	
DATE: APRIL 2016	
SCALE: NOT TO SCALE	
SHEET NO. C-19	

BID SET

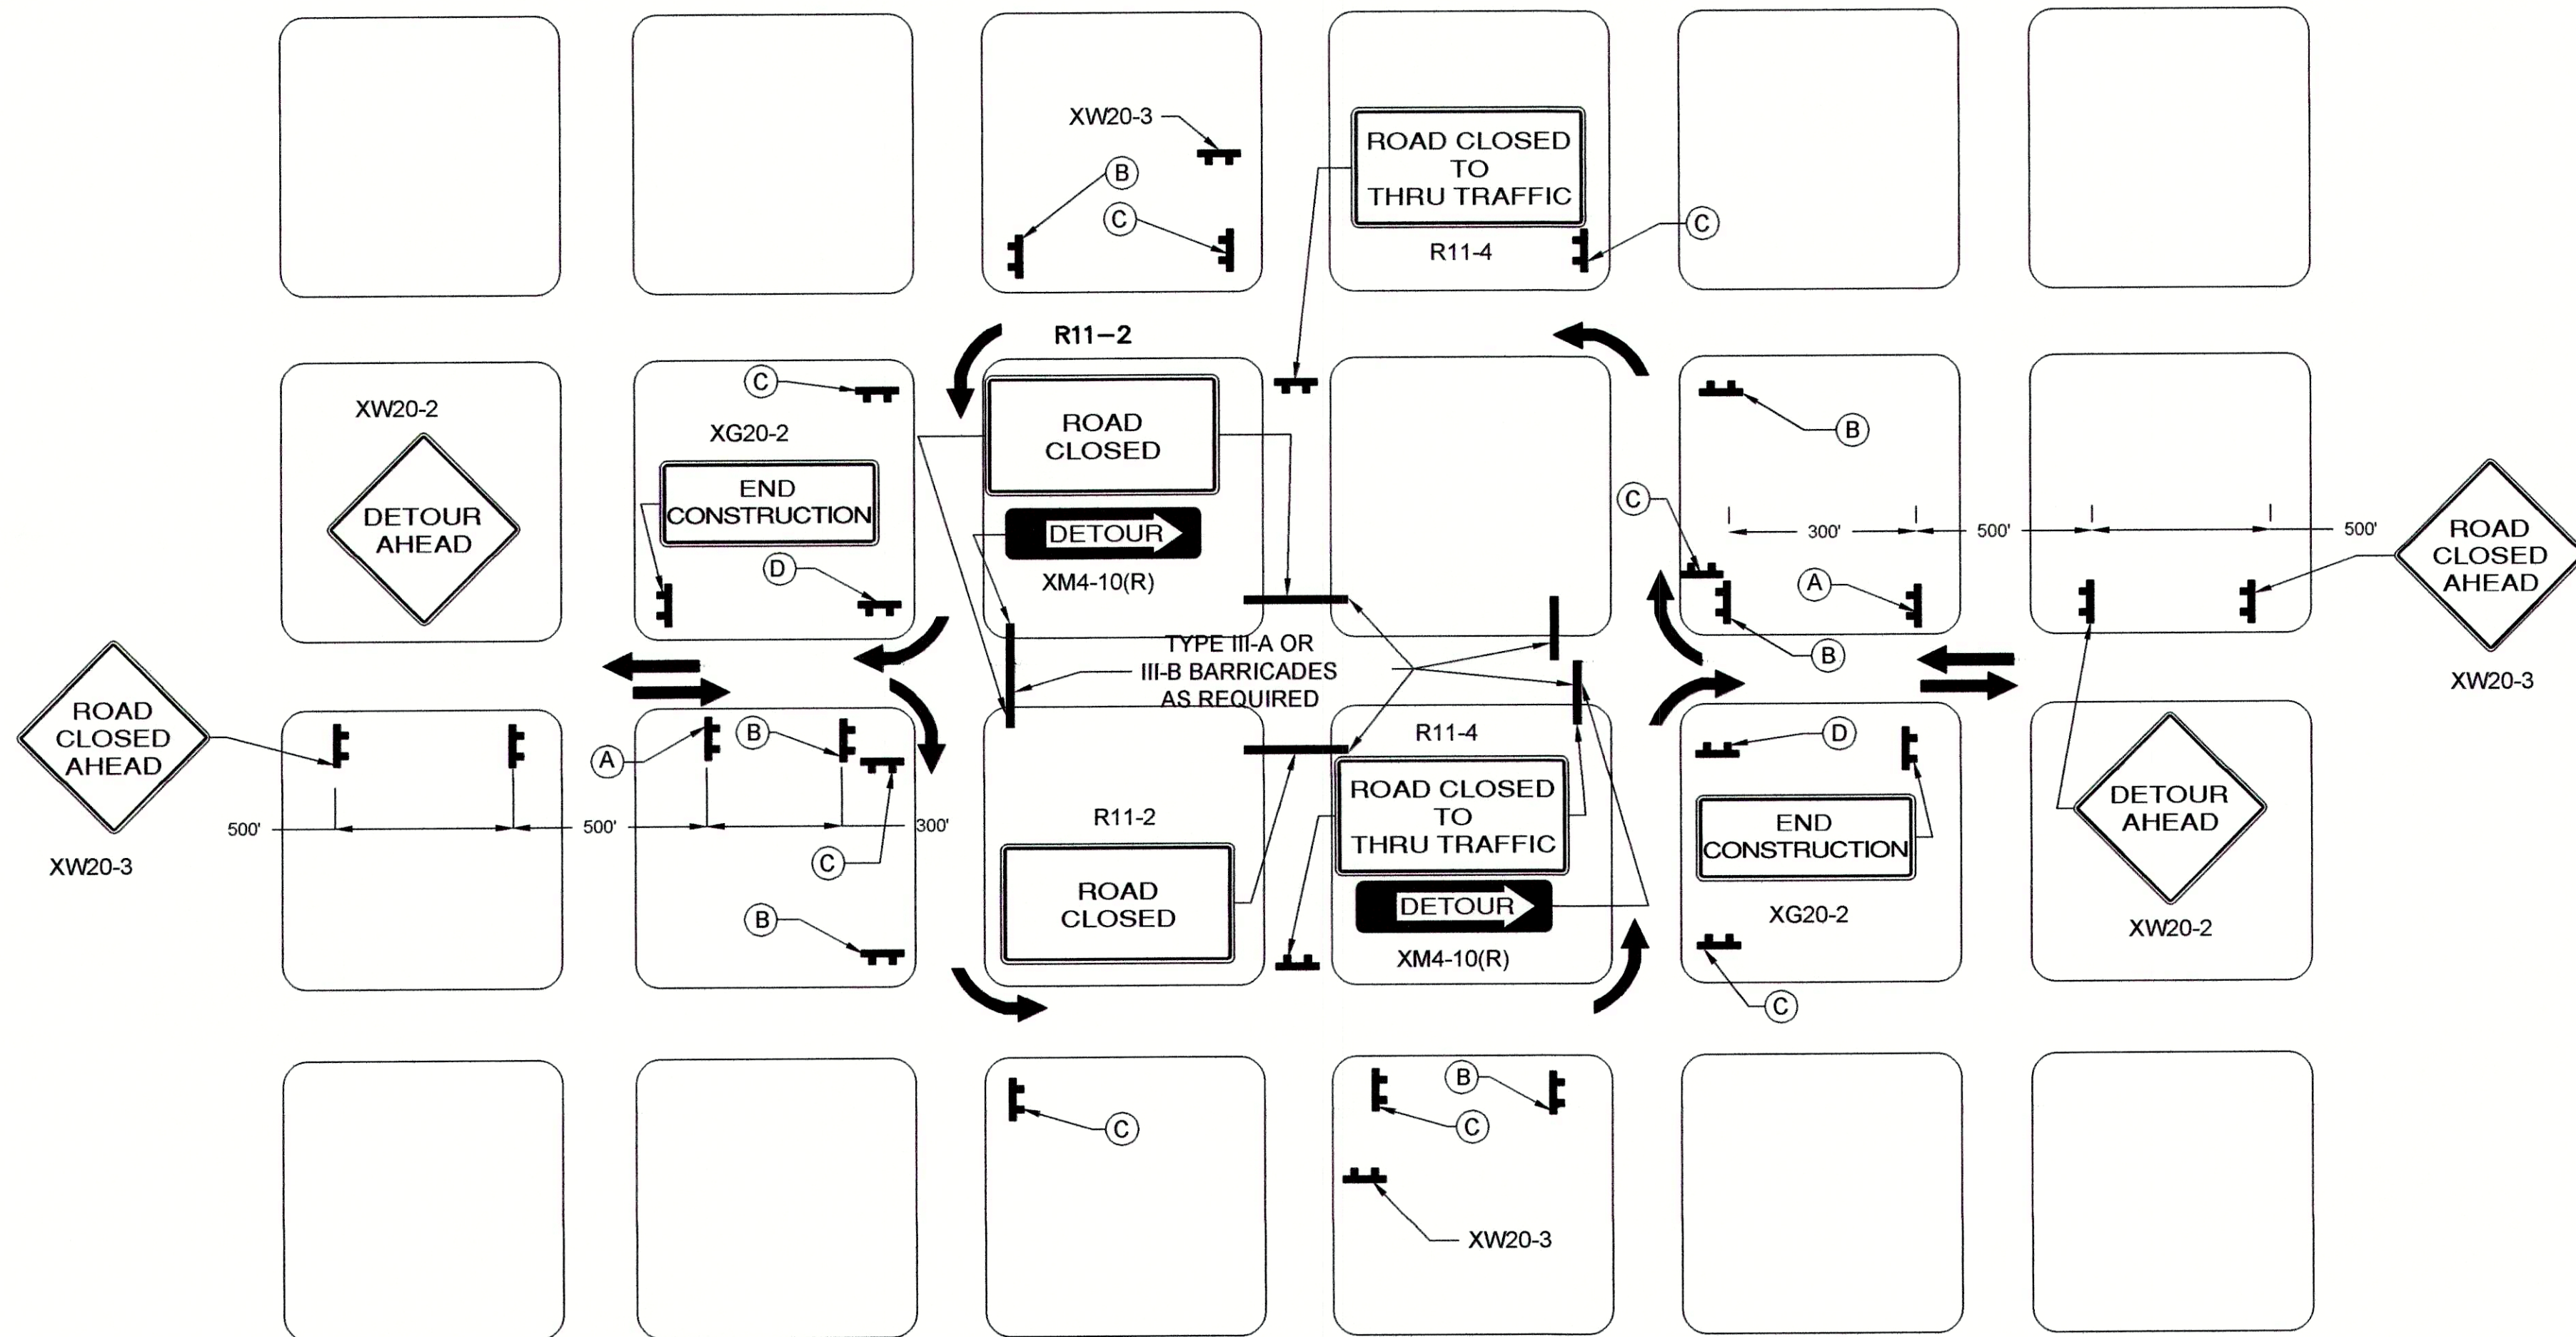

**TYPICAL APPLICATIONS OF TRAFFIC DEVICES
FOR AN URBAN DETOUR**

NOTES:

1. FOR DETOUR ROUTE MARKER ASSEMBLIES (A), (B), (C), AND (D) SEE INDOT STANDARD DRAWINGS E 801-TCDT-03.
2. SEE INDOT STANDARD DRAWING E 801-TCLG-01 FOR STANDARD NOTES AND LEGEND.

DETAIL - TRAFFIC CONTROL PLAN FOR LOCAL DETOUR
SCALE: N.T.S.

NOTE: TRAFFIC CONTROL PLANS ARE GUIDELINES ONLY. ALL TRAFFIC CONTROL PLANS AND LANE CLOSURES MUST BE APPROVED BY THE APPROPRIATE AGENCY.
TOWN OF PENDLETON: (765) 778-2173



GRW PROJECT NO. 4447-14
SRF NO. WW6074803
ALL RIGHTS RESERVED. PROPERTY OF
GRW ENGINEERS, INC. AND SHALL NOT
BE REPRODUCED OR USED FOR CONSTRUCTION OF
OTHER PROJECTS WITHOUT WRITTEN PERMISSION.



**MAINTENANCE OF TRAFFIC
SANITARY SEWER REHABILITATION
FALL CREEK REGIONAL WASTE DISTRICT
PENDLETON, INDIANA**

DESIGNED	GWL
DRAWN	GCR
REVIEWED	GWL
APPROVED	JPT

NO.	DATE	BY

SCALE CHECK: _____ THIS MARK SHOULD MEASURE EXACTLY 1" WHEN PLOTTED

DATE: APRIL 2016
SCALE: NOT TO SCALE
SHEET NO.