

SADDLEBROOK SUBDIVISION

SANITARY SEWER COLLECTION SYSTEM

PROJECT FOR THE

SADDLE BROOK ADDITION

MADISON CO., IN.


NOVEMBER 1999

OWNER: MR. LARRY KEESLING

SHEET INDEX


SHEET NO.	DESCRIPTION
1	TITLE SHEET AND INDEX
2	PROJECT BASE MAP
3-7	PLAN AND PROFILES
8	STANDARD DETAILS

AREA MAP

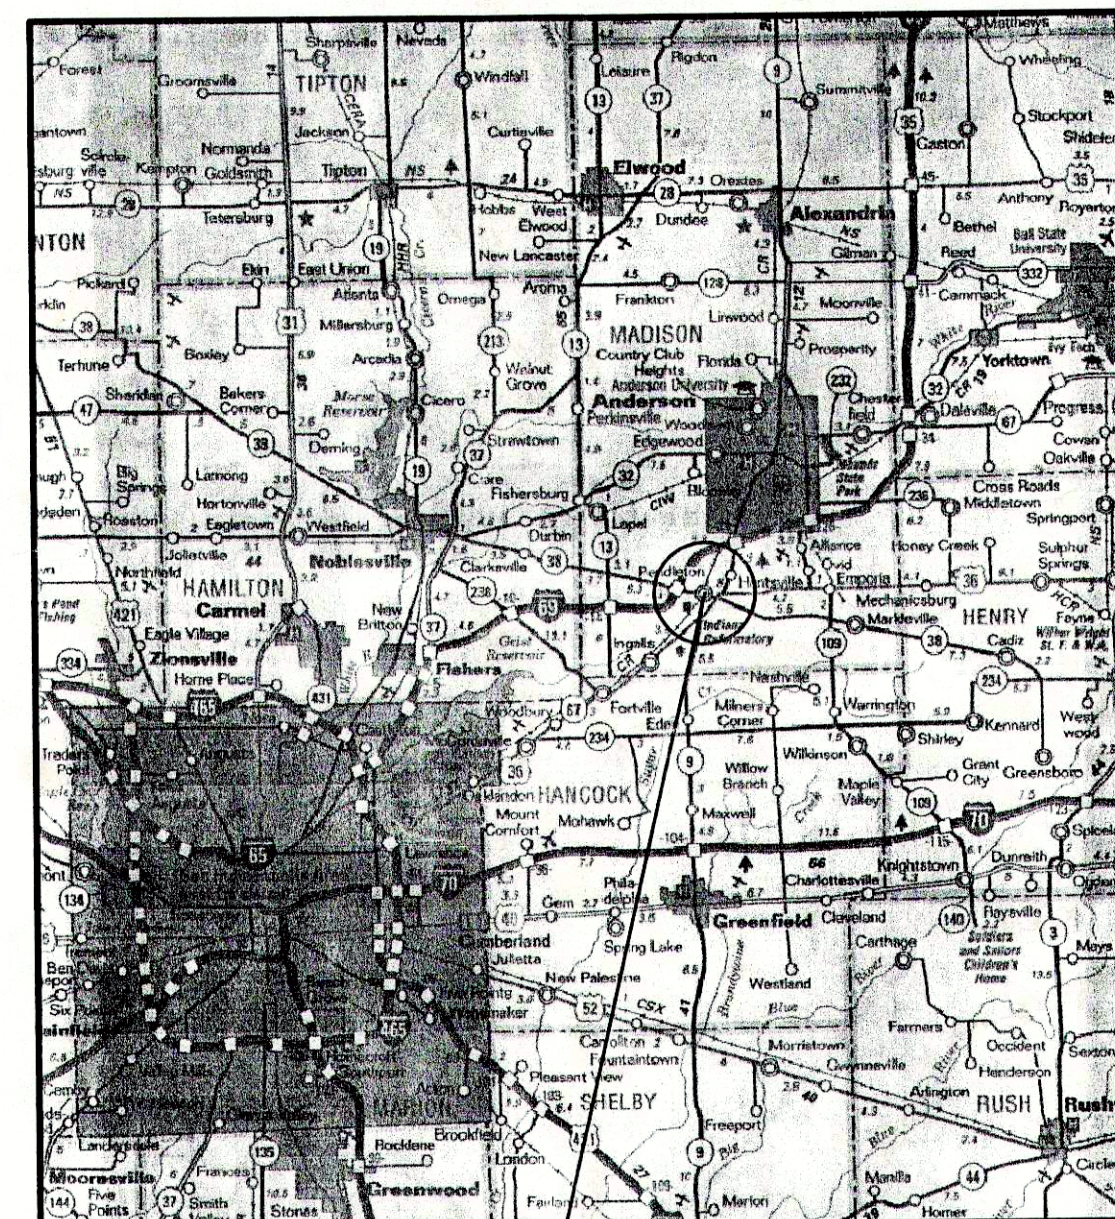

AREA
LOCATION

LOCATION MAP

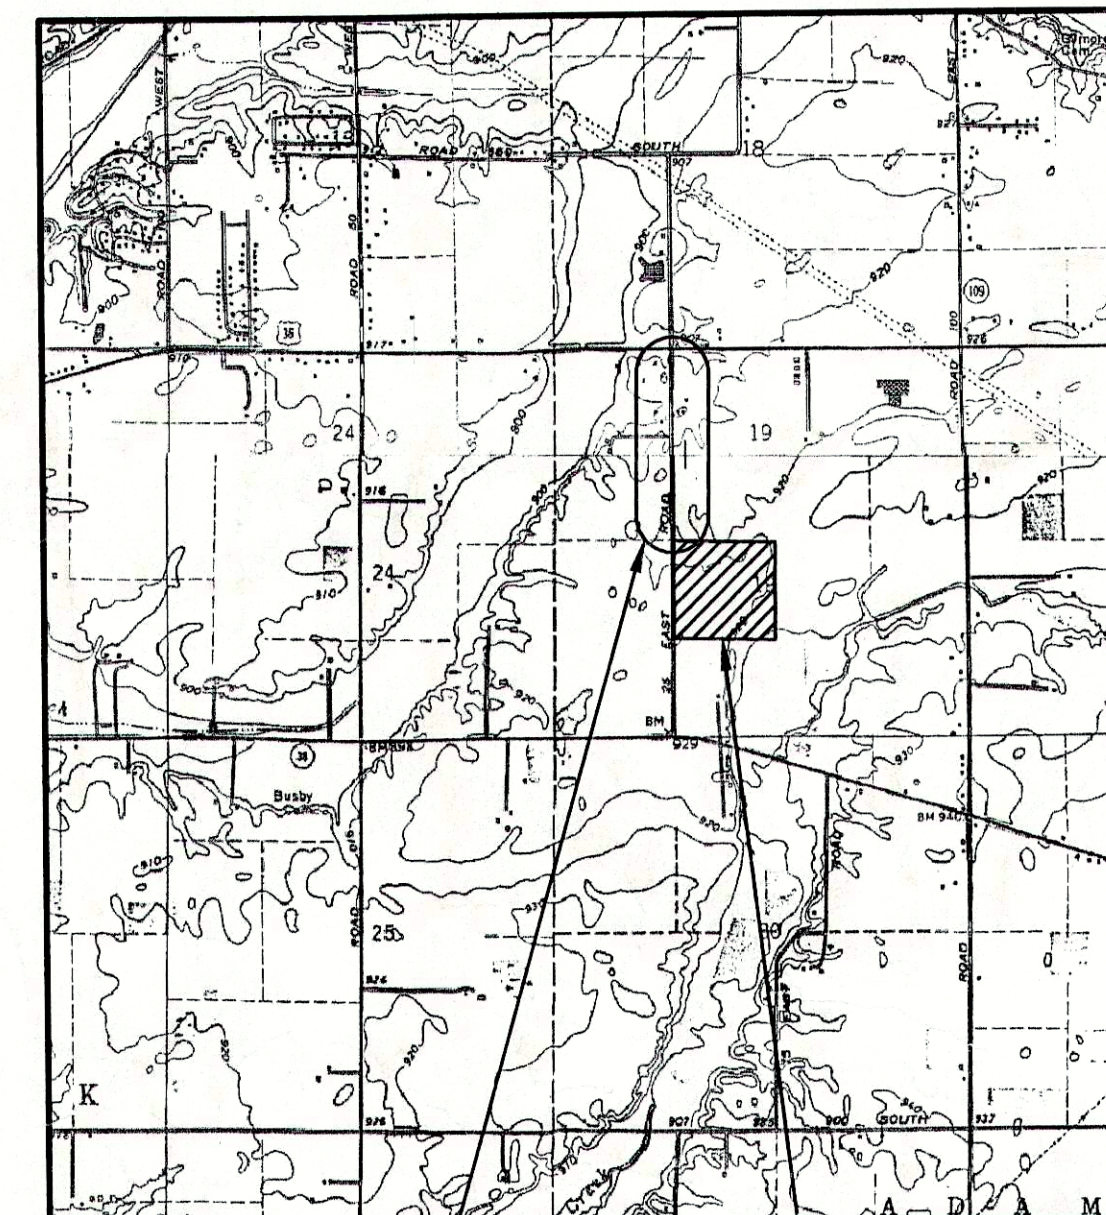

PROJECT
LOCATION

SADDLEBROOK
SUBDIVISION

PLANS PREPARED BY:

TRIAD
ASSOCIATES
INC.
INDIANAPOLIS, INDIANA

NOTE:
ADDITIONAL RIGHT-OF-WAY OR EASEMENTS MAY
NEED TO BE ACQUIRED FOR INSTALLATION OF SEWER.




DON'T DIG BLIND
CALL BEFORE YOU DIG
1-800-382-5544
1-800-428-5200

PER INDIANA STATE LAW IS-69-1991, IT IS
AGAINST THE LAW TO EXCAVATE WITHOUT
NOTIFYING THE UNDERGROUND LOCATION SERVICE
TWO (2) WORKING DAYS BEFORE COMMENCING WORK.
NOTE: CONTRACTOR TO VERIFY ALL UTILITY LOCATIONS
PRIOR TO THE START OF CONSTRUCTION

THESE PLANS CERTIFIED BY:


James W. Frazell, Professional Engineer


James W. Frazell

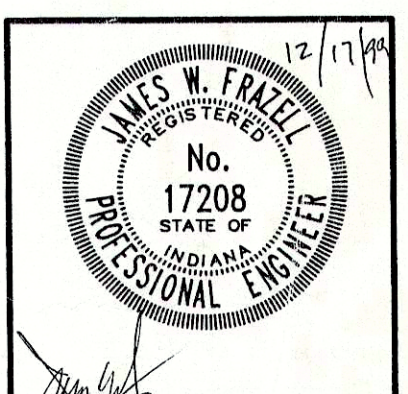

Thomas M. Schubert, Professional Engineer

Thomas M. Schubert

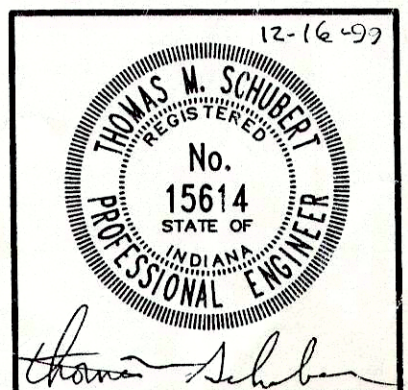

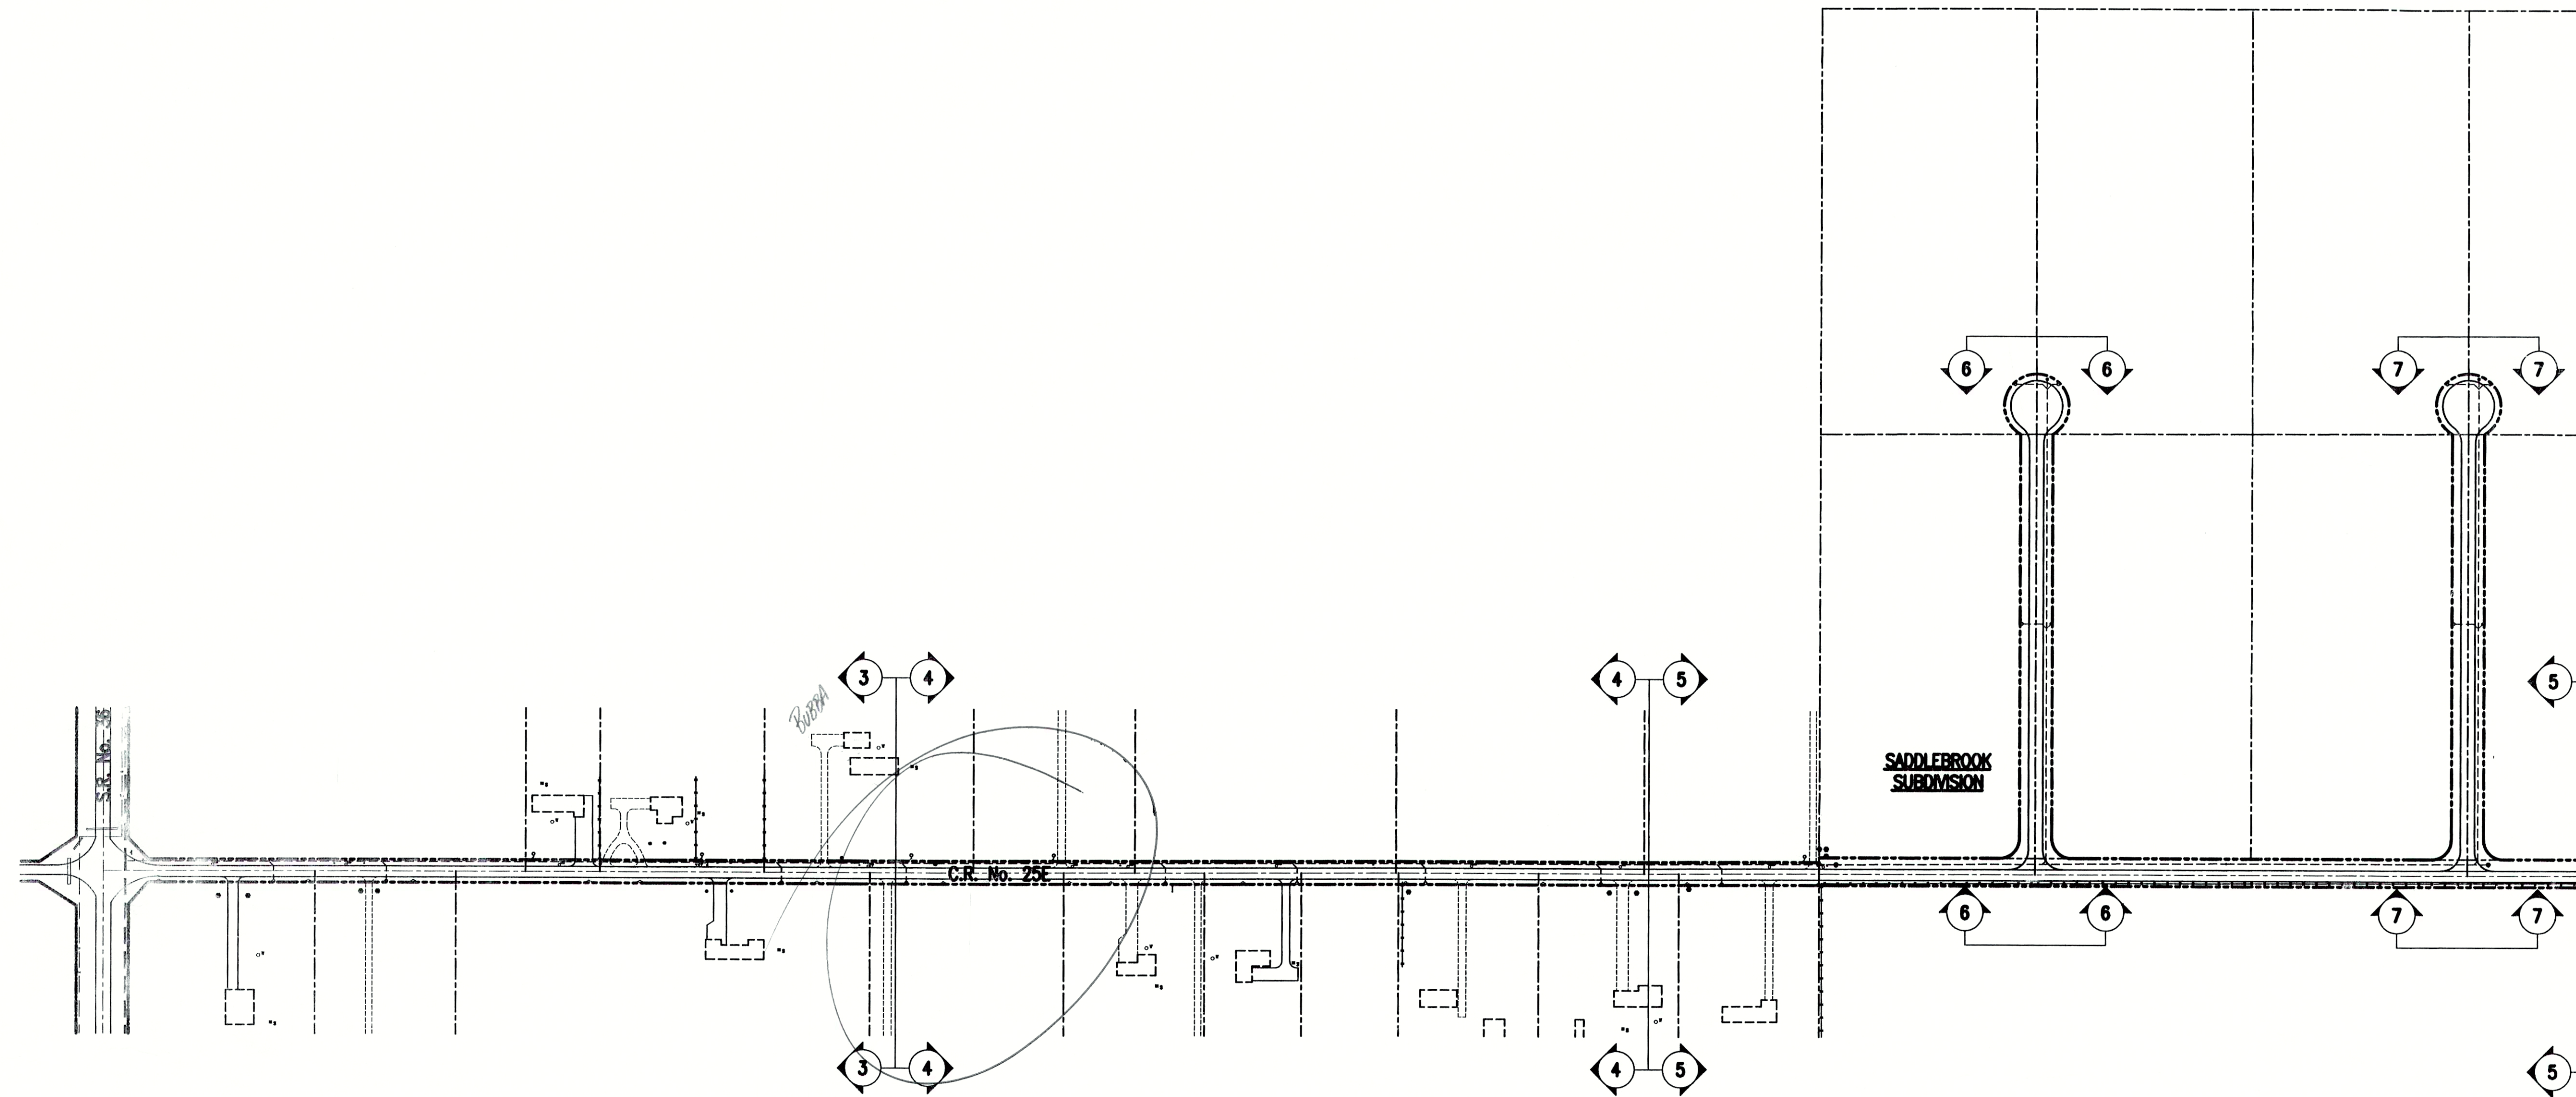

NOTE:
ADDITIONAL RIGHT-OF-WAY OR EASEMENTS MAY
NEED TO BE ACQUIRED FOR INSTALLATION OF SEWER.



**DON'T DIG BLIND.
CALL BEFORE YOU DIG**
1-800-382-5544
1-800-428-5200

PER INDIANA STATE LAW IS-89-1991, IT IS
AGAINST THE LAW TO EXCAVATE WITHOUT
NOTIFYING THE UNDERGROUND LOCATION SERVICE
TWO (2) WORKING DAYS BEFORE COMMENCING WORK.

NOTE: CONTRACTOR TO VERIFY ALL UTILITY LOCATIONS
PRIOR TO THE START OF CONSTRUCTION

ANDERSON LIGHT AND POWER
550 BAXTER ROAD
ANDERSON, INDIANA 46016
1 (765) 648-6187

CYENERGY/PSI
100 S. MILL CREEK ROAD
P.O. BOX 312
NOBLESVILLE, INDIANA 46060
1 (800) 521-2232

TCI OF CENTRAL INDIANA
633 JACKSON STREET
ANDERSON, INDIANA 46016
1 (765) 649-0407

 
GTE
P.O. BOX 1406
RICHMOND, INDIANA 47375
1 (800) 832-0129

INDIANA GAS COMPANY, INC.
2001 LOUISE STREET
ANDERSON, INDIANA 46016
1 (800) 777-2060


LEGEND



SHEET DESIGNATION



EXISTING SANITARY FORCEMAIN

 

PROPOSED SANITARY FORCEMAIN

UTILITIES

**COUNTY ROAD 25E
BASE MAP**

SCALE: 1" = 150'



CONSULTANT:

REVISIONS:


DATE	DESCRIPTION	BY

APPROVED BY:

12-16-99



Thomas M. Schubert
Thomas M. Schubert, P.E.

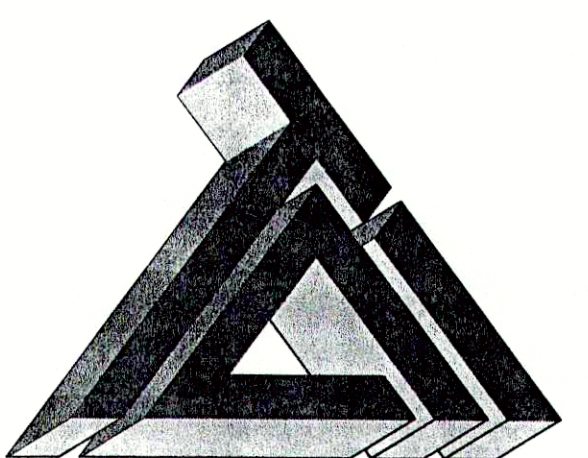

TRIAD ASSOCIATES INC.
5835 LAWTON LOOP EAST DRIVE
INDIANAPOLIS, INDIANA 46216
PHONE: 317-377-5230 FAX: 317-377-5241

DESIGNED FOR:

**SADDLE BROOK ADDITION
OWNER: MR. LARRY KEESLING**

SHEET TITLE:


**SANITARY SEWER COLLECTION
SYSTEM BASE MAP**

JOB NUMBER: 980021	CHECKED BY: J.W.F.
SCALE: AS NOTED	PLOT DATE: 12/17/99
PLOT SCALE: 1"=150'	DATE: 04/12/98
DRAWN BY: D.A.P.	DESIGNED BY: D.A. Pauling
DRAWING NAME: CR25E_OA	

SHEET No.

02

OF 08

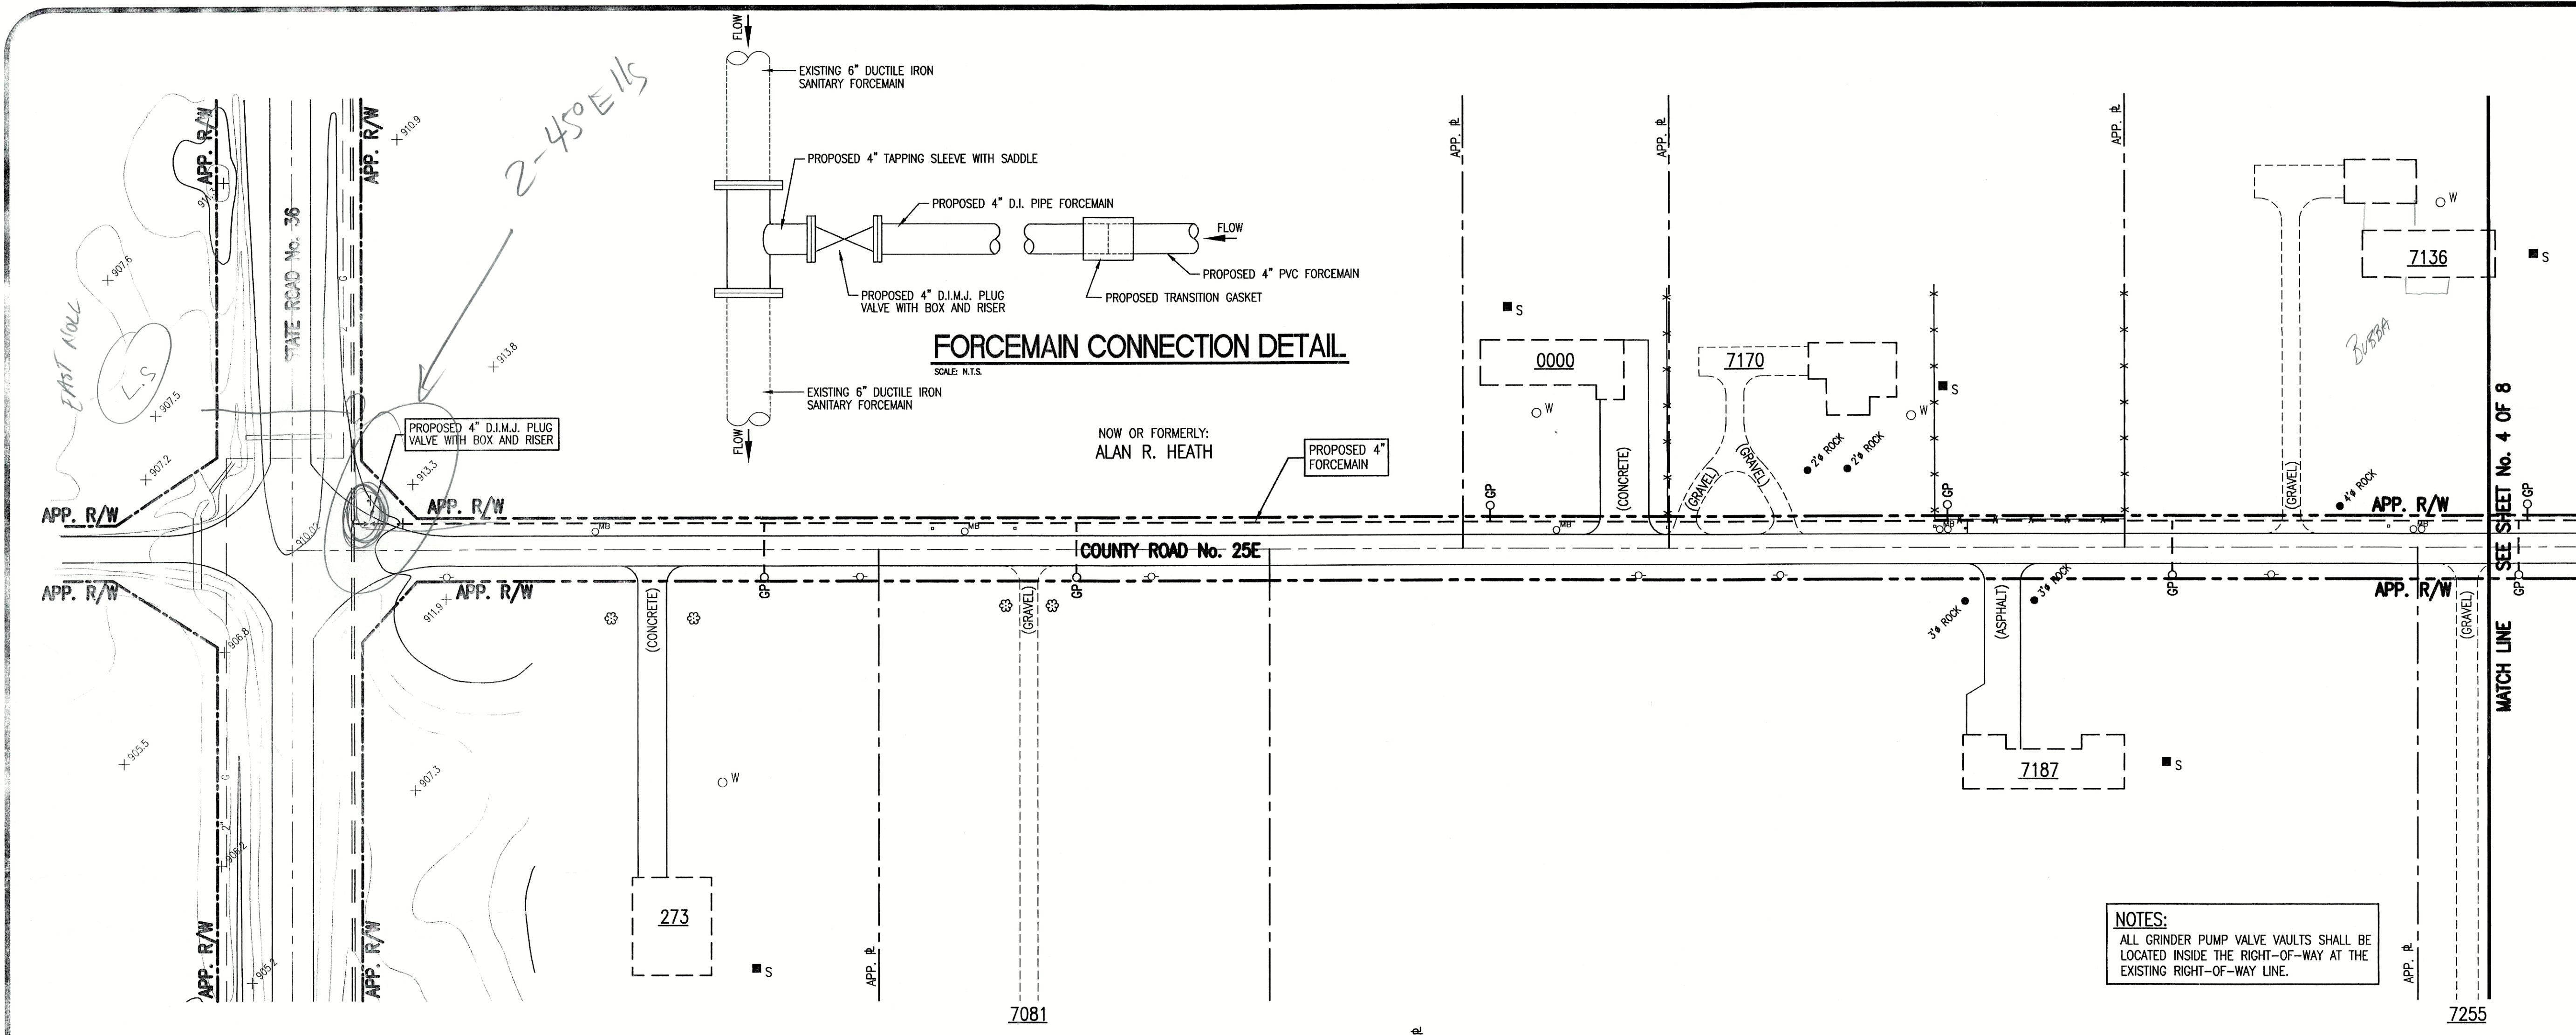

NOTE:
ADDITIONAL RIGHT-OF-WAY OR EASEMENTS MAY
NEED TO BE ACQUIRED FOR INSTALLATION OF SEWER.



DON'T DIG BLIND
CALL BEFORE YOU DIG
TOLL FREE
1-800-382-5544
OUTSIDE INDIANA
1-800-428-5200

PER INDIANA STATE LAW IS-89-1891, IT IS
AGAINST THE LAW TO EXCAVATE WITHOUT
NOTIFYING THE UNDERGROUND LOCATION SERVICE
TWO (2) WORKING DAYS BEFORE COMMENCING WORK.

NOTE: CONTRACTOR TO VERIFY ALL UTILITY LOCATIONS
PRIOR TO THE START OF CONSTRUCTION

GENERAL NOTES:


- ALL UTILITY LOCATIONS ARE APPROXIMATE. THE CONTRACTOR SHALL HAVE ALL UTILITIES FIELD VERIFIED AND MARKED PRIOR TO CONSTRUCTION.
- CONTRACTOR SHALL MAINTAIN A MINIMUM 10'-0" HORIZONTAL AND 18" VERTICAL SEPARATION BETWEEN SEWER AND WATER MAINS.
- ALL PROPOSED TOP OF CASTING ELEVATIONS ARE APPROXIMATE. THE CONTRACTOR SHALL ADJUST FINAL ELEVATIONS AS REQUIRED TO BE FLUSH WITH PAVEMENT.
- ALL SEWER TRENCHES SHALL BE BACKFILLED WITH FULL DEPTH COMPACTED GRANULAR BACKFILL ("B" BORROW) UNDER OR WITHIN 5' OF EDGE OF PAVEMENT.
- THE CONTRACTOR SHALL VISIT THE SITE PRIOR TO BID TO BECOME FAMILIAR WITH ALL SITE CONDITIONS.
- THE CONTRACTOR SHALL PROVIDE THE REQUIRED MEANS FOR MAINTAINING SAFE TRAFFIC AT ALL TIMES.
- CONTRACTOR SHALL RESTORE ALL DISTURBED LAWN AREAS, STREETS, WALKS, DRIVES, ETC. AS SHOWN ON DRAWINGS, IN THE SPECIFICATIONS, OR TO AT LEAST PRE-EXISTING CONDITIONS.
- ALL UTILITY CROSSINGS SHALL BE PROTECTED AND SUPPORTED WITH GRANULAR FILL OR CONCRETE AS REQUIRED PER THE DETAIL SHEET.

LEGEND:

- TREE
- POWER POLE
- GUY WIRE
- FIRE HYDRANT
- MAILBOX
- FLAGPOLE
- SPOT SHOT
- CONTOUR
- FENCE
- EXISTING SANITARY SEWER FORCEMAIN
- NEW SANITARY SEWER FORCEMAIN
- NEW GRINDER PUMP VAULT
- WATER LINE
- GAS LINE
- UNDERGROUND ELECTRIC LINE
- UNDERGROUND TELEPHONE LINE
- APPROX. RIGHT-OF-WAY
- APPROX. CORPORATE LIMITS
- APPROX. PROPERTY LINE
- EXISTING WATER WELL
- EXISTING SEPTIC TANK
- EXISTING TELEPHONE RISER



SCALE:
HORIZONTAL 1" = 50'
VERTICAL 1" = 5'

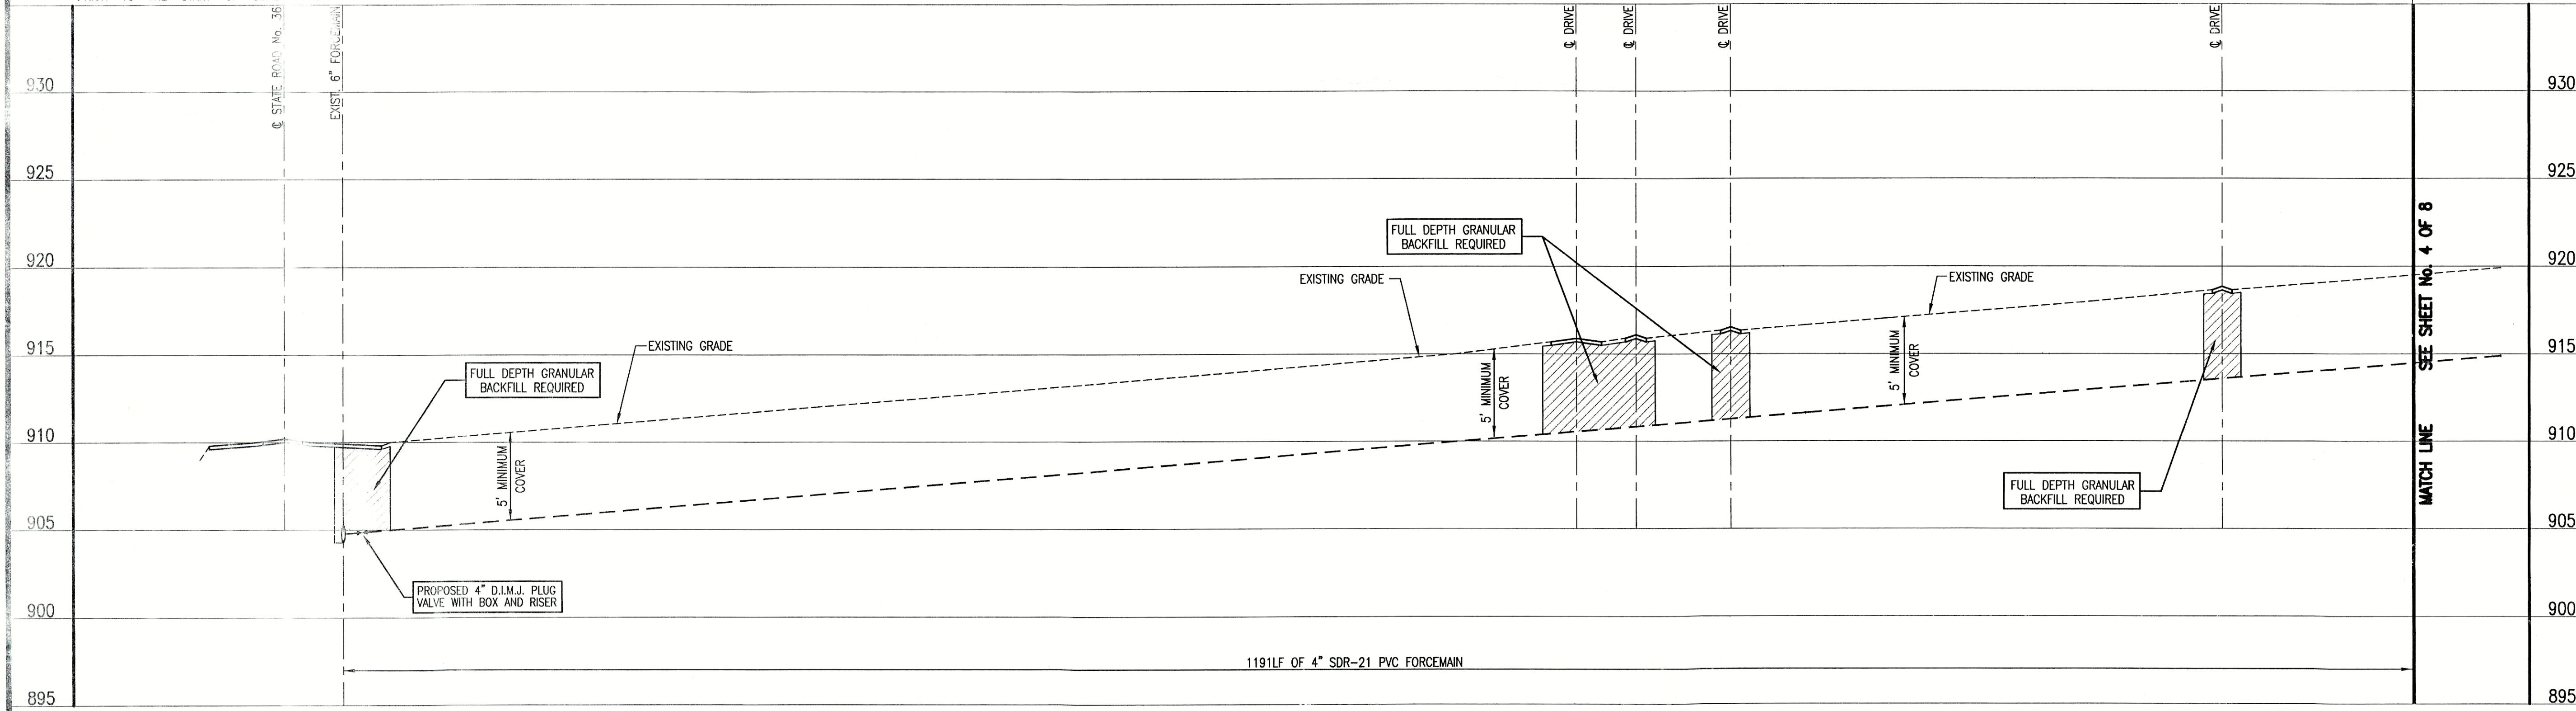


CONSULTANT:

REVISIONS:

DATE	DESCRIPTION	BY

APPROVED BY:

12-22-99

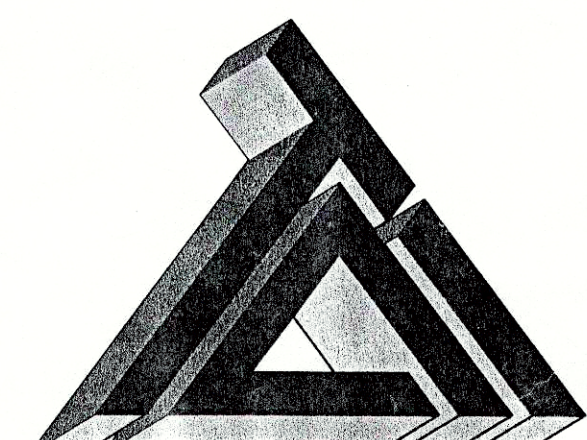

TRIAD ASSOCIATES INC.
5835 LAWTON LOOP EAST DRIVE
INDIANAPOLIS, INDIANA 46216
PHONE: 317-377-5230 FAX: 317-377-5241

DESIGNED FOR:

SADDLE BROOK ADDITION
OWNER: MR. LARRY KEESLING

SHEET TITLE:
**SANITARY SEWER COLLECTION
SYSTEM PLAN AND PROFILES**

JOB NUMBER: 980021	CHECKED BY: J.W.F.
SCALE: AS NOTED	PLOT DATE: 12/22/99
PLOT SCALE: 1"=50'	DATE: 04/12/98
DRAWN BY: DAP	DESIGNED BY: D.A. Pauling
DRAWING NAME: CR25E_C1	

SHEET No.

03

OF 03

CONSULTANT:

REVISIONS:


DATE	DESCRIPTION	BY

APPROVED BY:

12-22-99



Thomas M. Schubert, P.E.

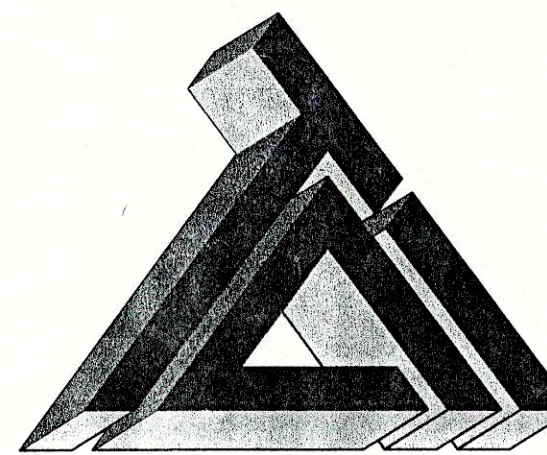

TRIAD ASSOCIATES INC.
5835 LAWTON LOOP EAST DRIVE
INDIANAPOLIS, INDIANA 46216
PHONE: 317-377-5230 FAX: 317-377-5241

DESIGNED FOR:

SADDLE BROOK ADDITION
OWNER: MR. LARRY KEESLING

SHEET TITLE:


SANITARY SEWER COLLECTION
SYSTEM PLAN AND PROFILES

JOB NUMBER: 980021	CHECKED BY: J.W.F.
SCALE: AS NOTED	PLOT DATE: 12/21/99
PLOT SCALE: 1"=50'	DATE: 04/12/98
DRAWN BY: DAP	DESIGNED BY: D.A. Pauling
DRAWING NAME: CR25E_C2	

SHEET No.

04

OF 08

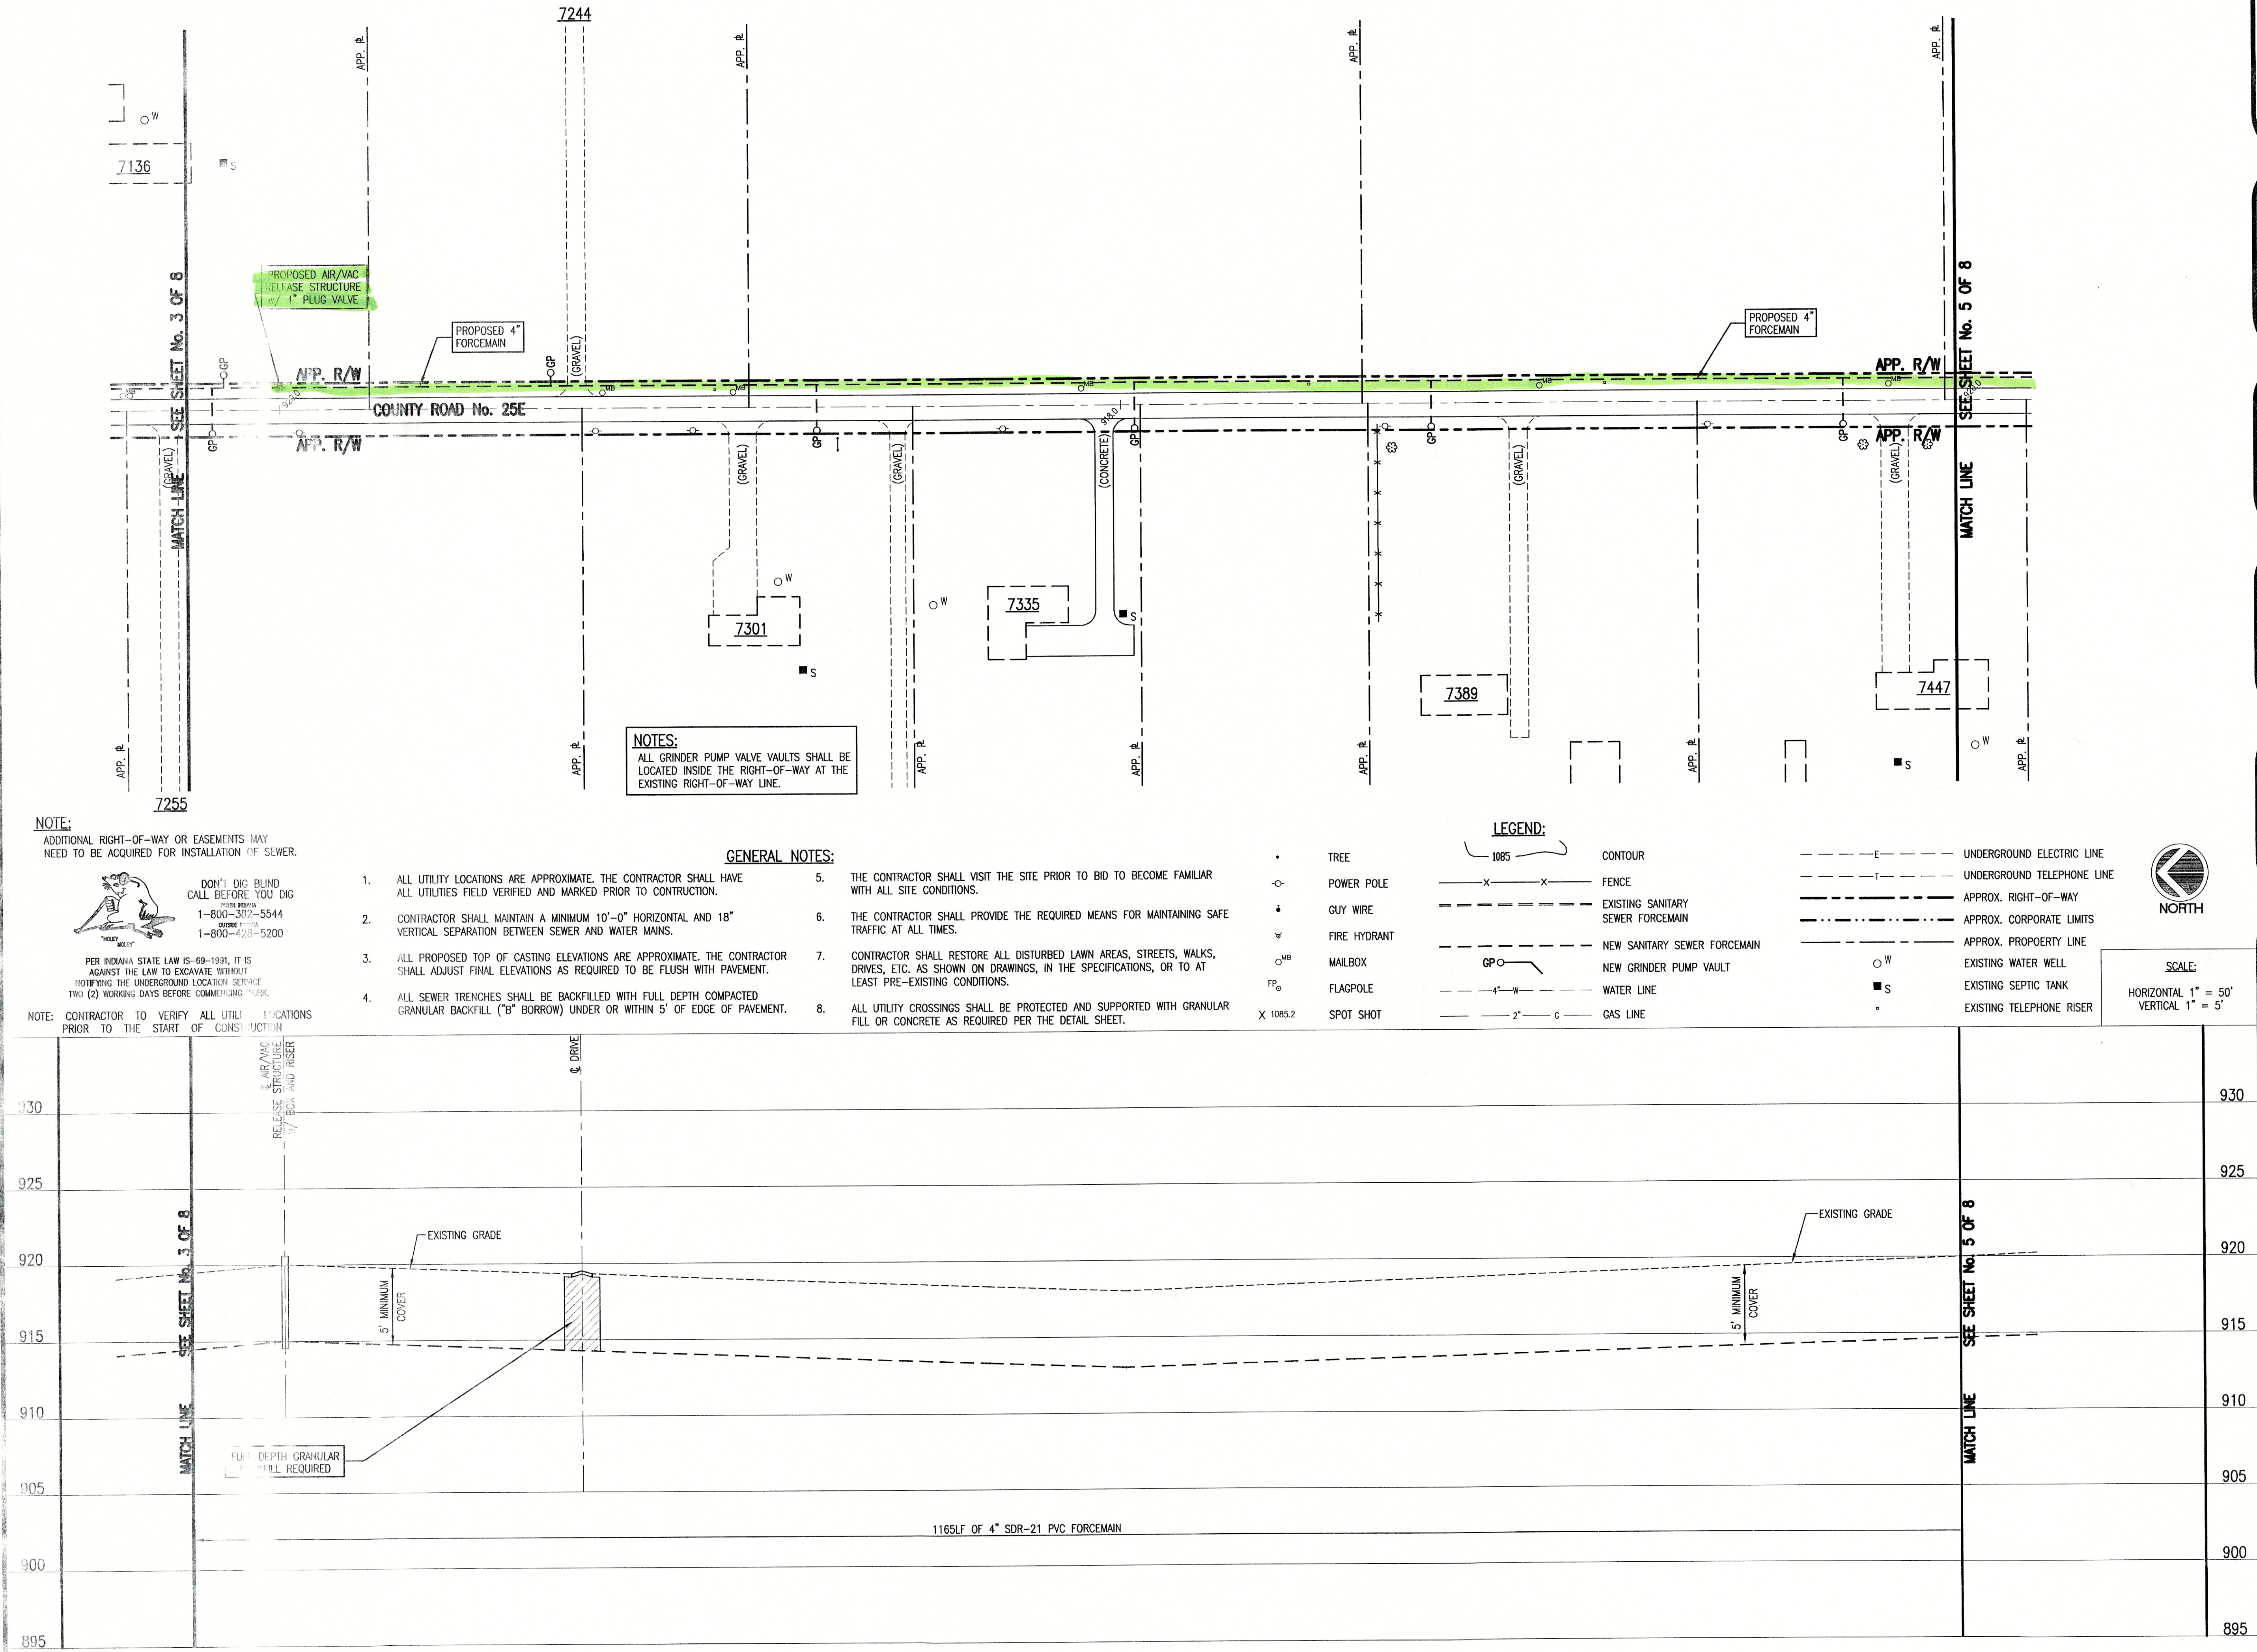

CONSULTANT:

REVISIONS:		
DATE	DESCRIPTION	BY

APPROVED BY: 12-22-99


THOMAS M. SCHUBERT
REGISTERED
No.
15614
STATE OF
INDIANA
PROFESSIONAL ENGINEER

Thomas Schubert
Thomas M. Schubert, P.E.



DESIGNED FOR:	
SADDLE BROOK ADDITION	
OWNER: MR. LARRY KEESLING	
SHEET TITLE:	
SANITARY SEWER COLLECTION SYSTEM PLAN AND PROFILES	
JOB NUMBER: 980021	
SCALE: AS NOTED	CHECKED BY: J.W.F.
PLOT SCALE: 1=50	PLOT DATE: 12/19/99
DRAWN BY: DAP	DATE: 04/12/98
DESIGNED BY: D.A. Pauling	
DRAWING NAME: CR25E C3	

SHEET No. **05**
OF 08

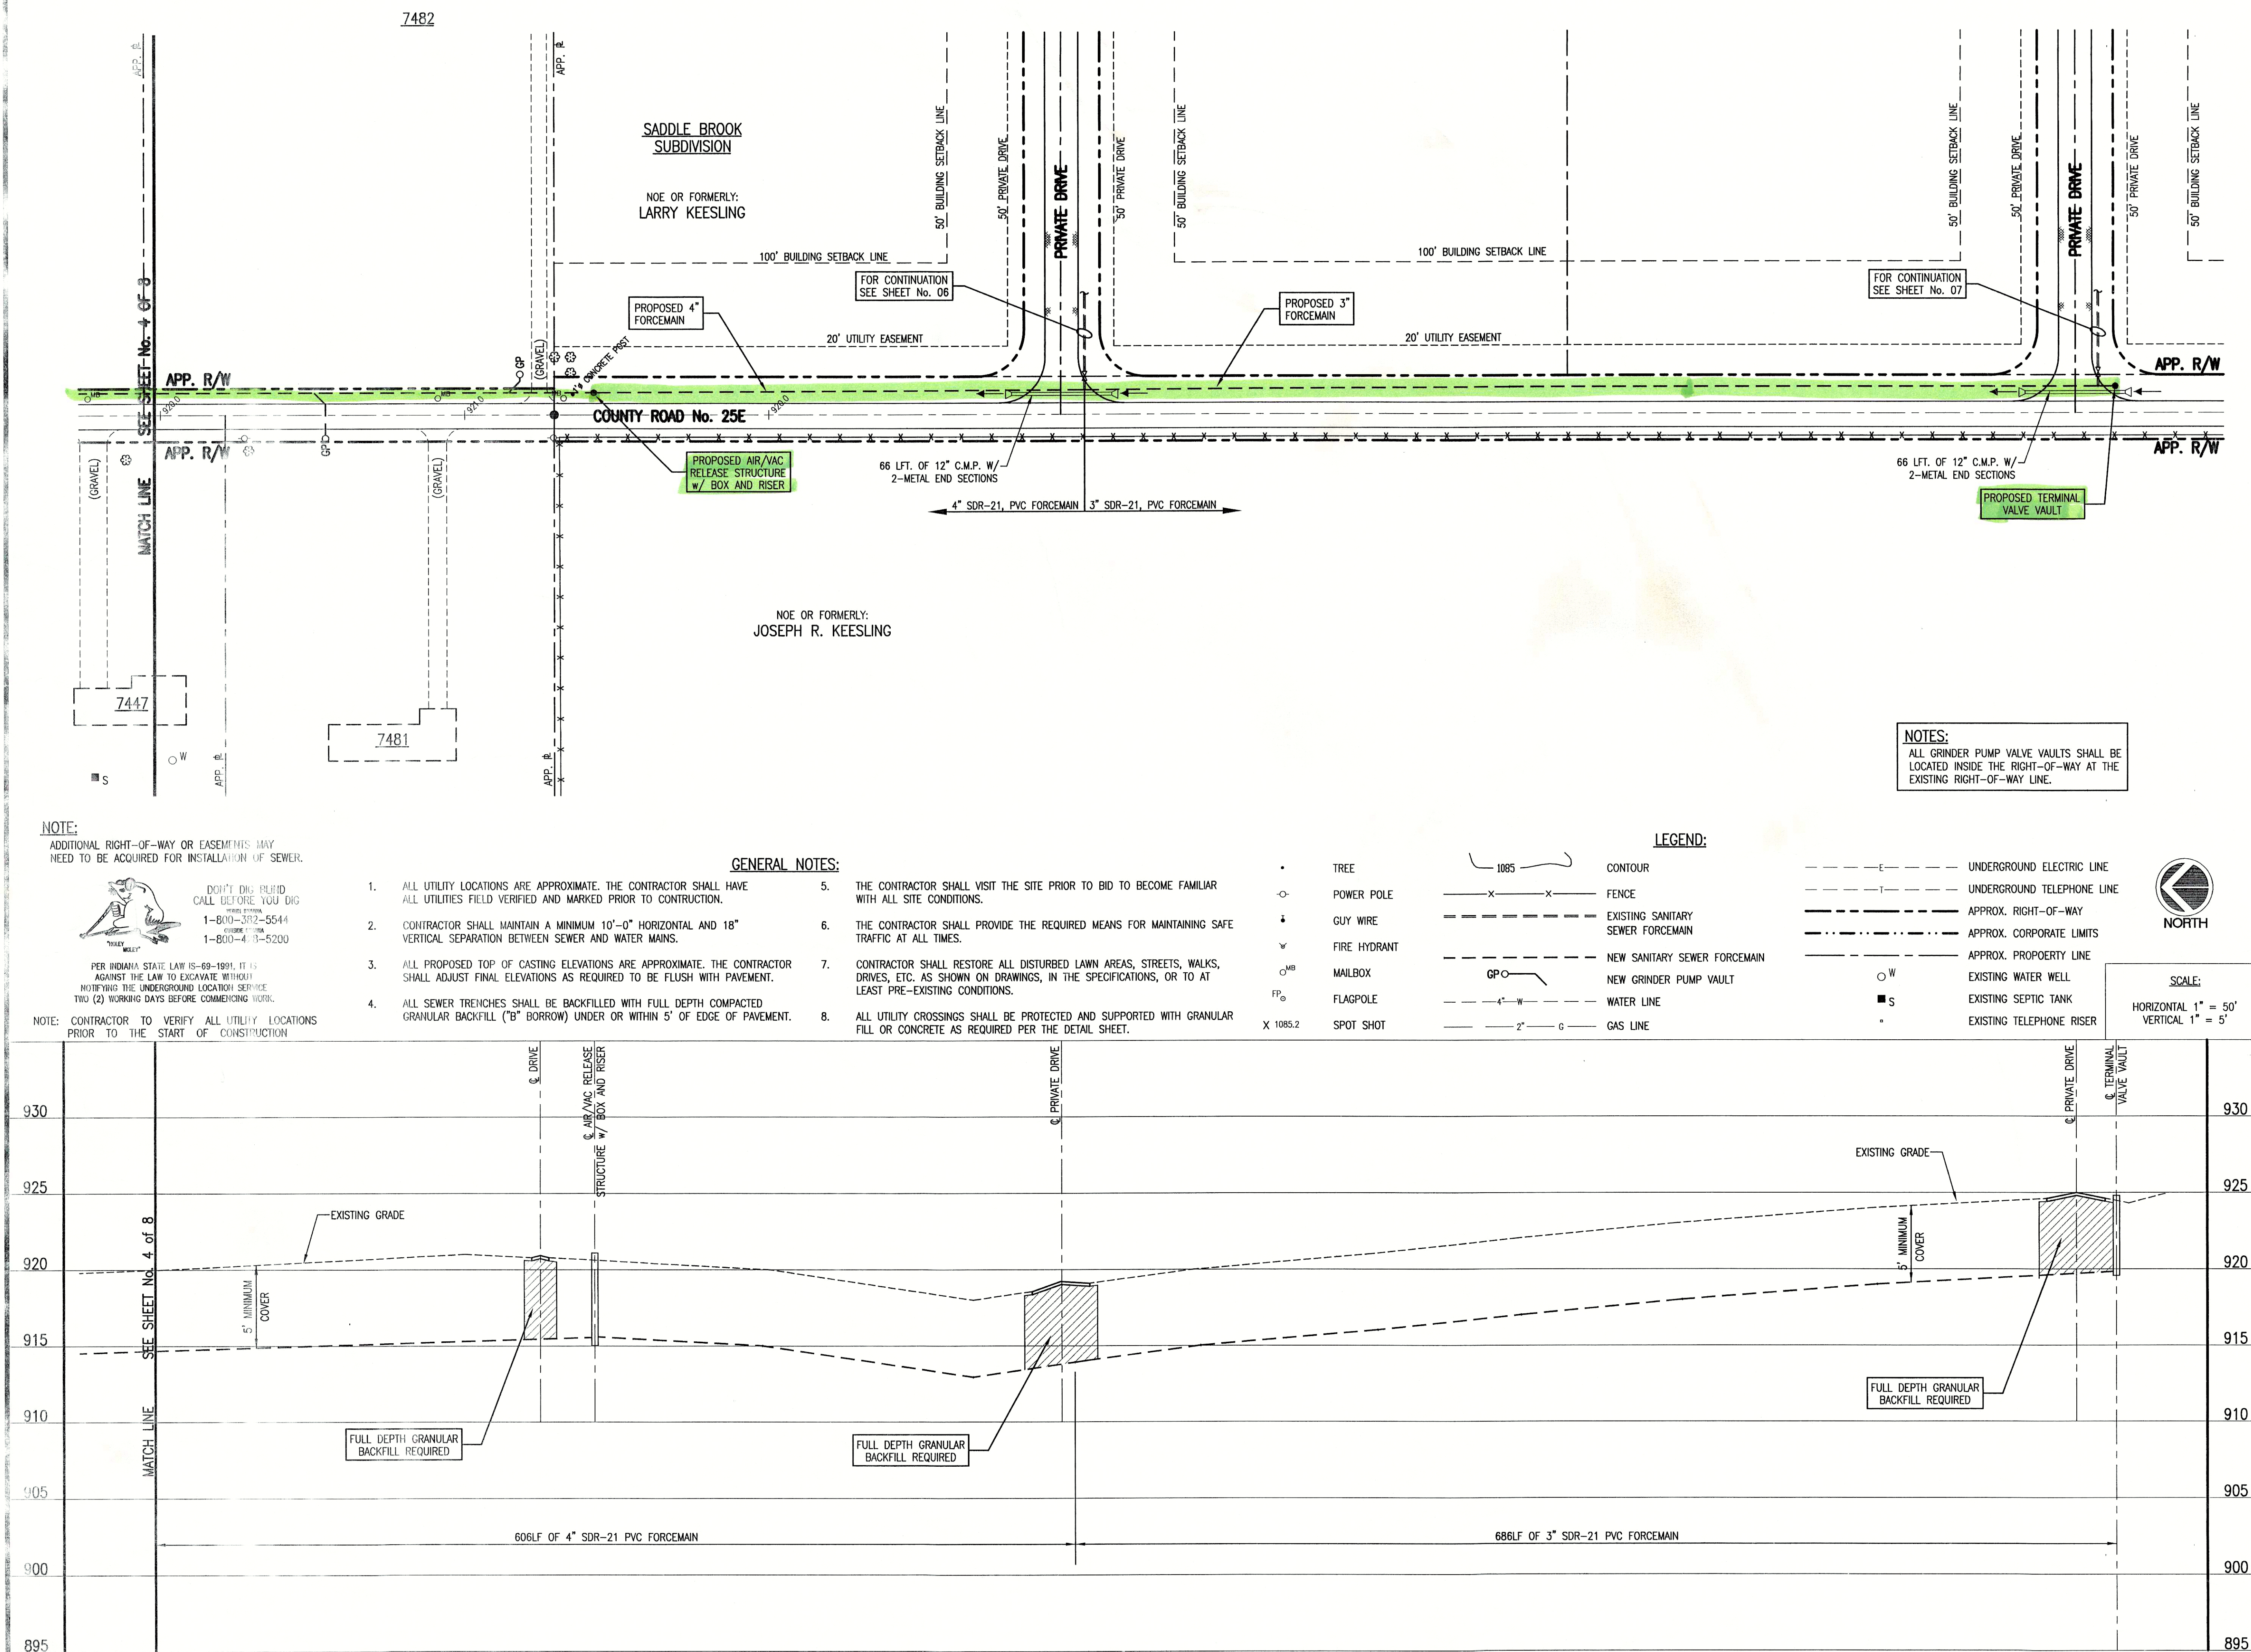

CONSULTANT:

REVISIONS:


DATE	DESCRIPTION	BY

APPROVED BY:

12-22-99



Thomas M. Schubert, P.E.

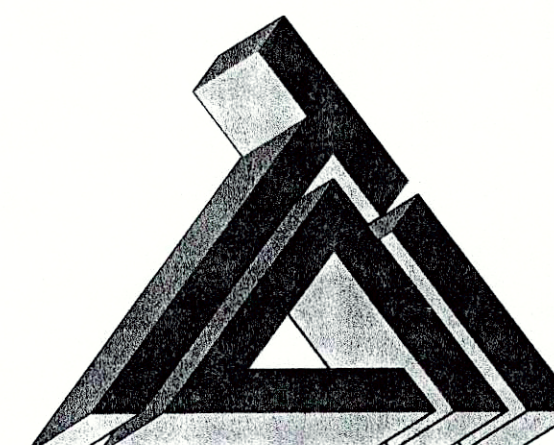

TRIAD ASSOCIATES INC.
5835 LAWTON LOOP EAST DRIVE
INDIANAPOLIS, INDIANA 46216
PHONE: 317-377-5230 FAX: 317-377-5241

DESIGNED FOR:

SADDLE BROOK ADDITION
OWNER: MR. LARRY KEESLING

SHEET TITLE:


**SANITARY SEWER COLLECTION
SYSTEM PLAN AND PROFILE**

JOB NUMBER: 980021	CHECKED BY: J.W.F.
SCALE: AS NOTED	PLOT DATE: 12/22/99
PLOT SCALE: 1"=50'	DATE: 04/12/98
DRAWN BY: DAP	DESIGNED BY: D.A. Pauling
DRAWING NAME: CR25E C4	

SHEET No.

06

OF 03

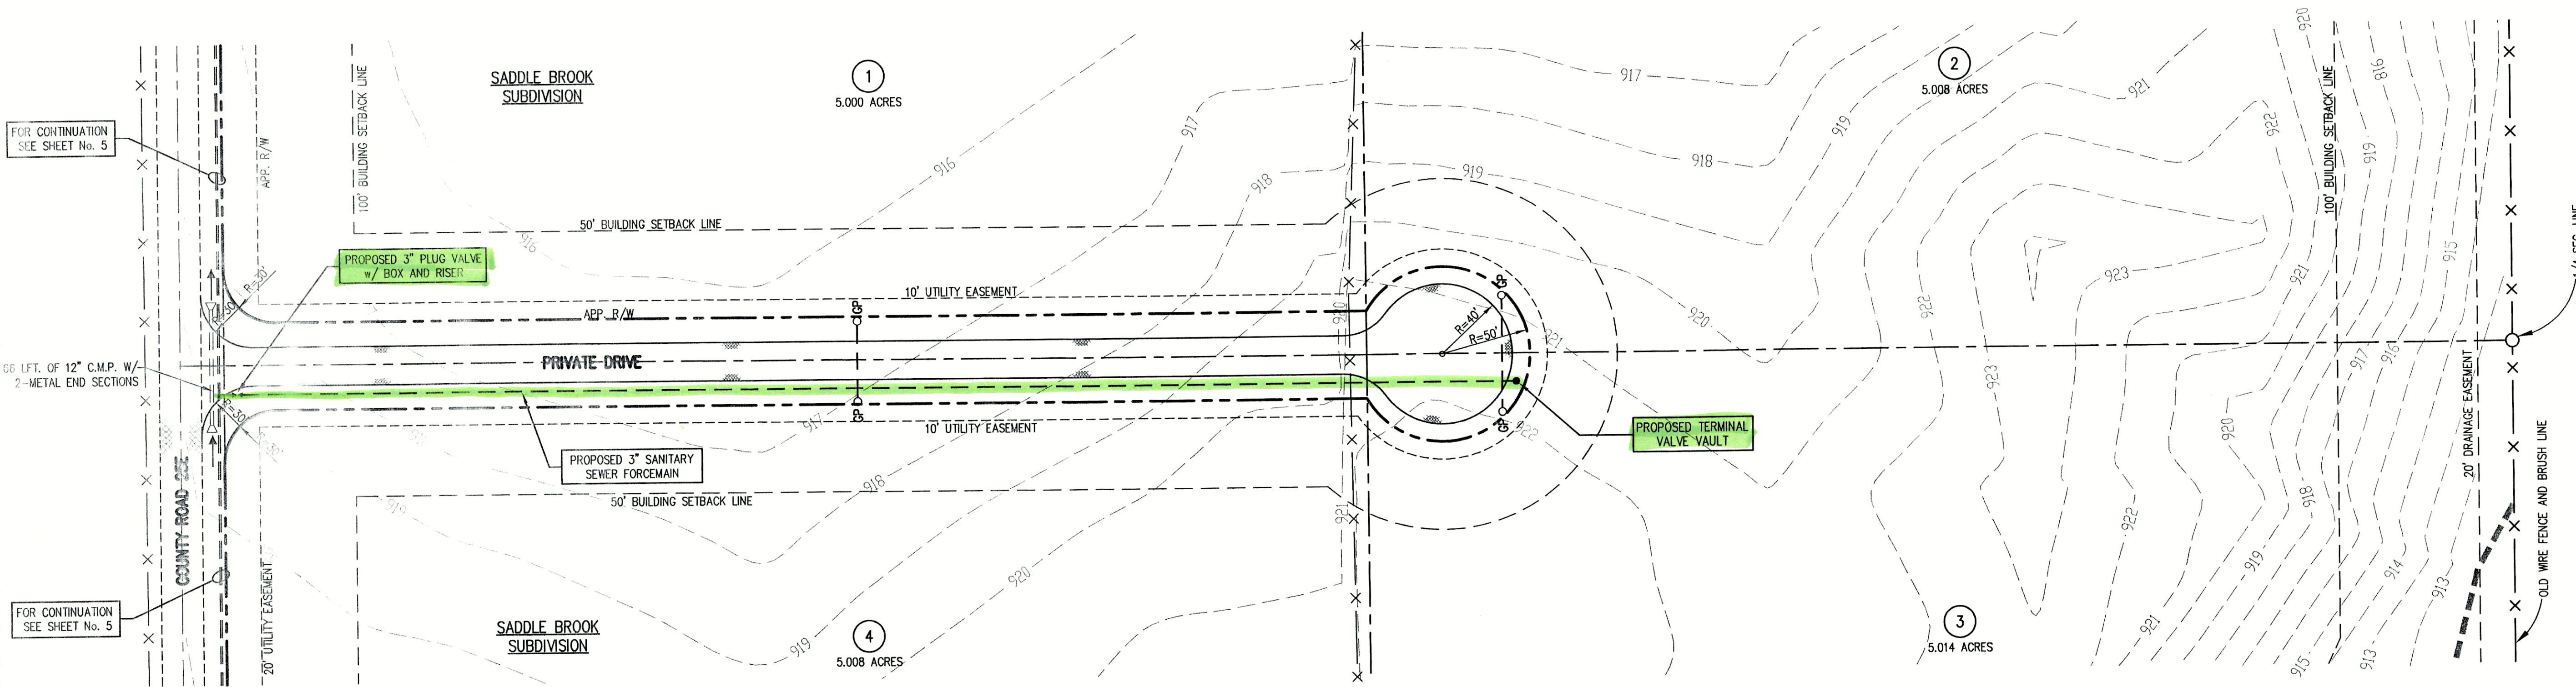

NOTES:
ALL GRINDER PUMP VALVE VAULTS SHALL BE LOCATED INSIDE THE RIGHT-OF-WAY AT THE EXISTING RIGHT-OF-WAY LINE.

LEGEND:

1085	CONTOUR	---	UNDERGROUND ELECTRIC LINE
X	FENCE	---	UNDERGROUND TELEPHONE LINE
---	EXISTING SANITARY SEWER FORCEMAIN	---	APPROX. RIGHT-OF-WAY
---	NEW SANITARY SEWER FORCEMAIN	---	APPROX. CORPORATE LIMITS
GP	NEW GRINDER PUMP VAULT	---	APPROX. PROPERTY LINE
---	WATER LINE	○ W	EXISTING WATER WELL
---	GAS LINE	■ S	EXISTING SEPTIC TANK
---		•	EXISTING TELEPHONE RISER



SCALE:
HORIZONTAL 1" = 50'
VERTICAL 1" = 5'

NOTE:
ADDITIONAL RIGHT-OF-WAY OR EASEMENTS MAY NEED TO BE ACQUIRED FOR INSTALLATION OF SEWER.





PER INDIANA STATE LAW 15-69-1891, IT IS AGAINST THE LAW TO EXCAVATE WITHOUT NOTIFYING THE UNDERGROUND LOCATION SERVICE TWO (2) WORKING DAYS BEFORE COMMENCING WORK.

NOTE: CONTRACTOR TO VERIFY ALL UTILITY LOCATIONS PRIOR TO THE START OF CONSTRUCTION

GENERAL NOTES:

- ALL UTILITY LOCATIONS ARE APPROXIMATE. THE CONTRACTOR SHALL HAVE ALL UTILITIES FIELD VERIFIED AND MARKED PRIOR TO CONSTRUCTION.
- CONTRACTOR SHALL MAINTAIN A MINIMUM 10'-0" HORIZONTAL AND 18" VERTICAL SEPARATION BETWEEN SEWER AND WATER MAINS.
- ALL PROPOSED TOP OF CASTING ELEVATIONS ARE APPROXIMATE. THE CONTRACTOR SHALL ADJUST FINAL ELEVATIONS AS REQUIRED TO BE FLUSH WITH PAVEMENT.
- ALL SEWER TRENCHES SHALL BE BACKFILLED WITH FULL DEPTH COMPACTED GRANULAR BACKFILL ("B" BORROW) UNDER OR WITHIN 5' OF EDGE OF PAVEMENT.
- THE CONTRACTOR SHALL VISIT THE SITE PRIOR TO BID TO BECOME FAMILIAR WITH ALL SITE CONDITIONS.
- THE CONTRACTOR SHALL PROVIDE THE REQUIRED MEANS FOR MAINTAINING SAFE TRAFFIC AT ALL TIMES.
- CONTRACTOR SHALL RESTORE ALL DISTURBED LAWN AREAS, STREETS, WALKS, DRIVES, ETC. AS SHOWN ON DRAWINGS, IN THE SPECIFICATIONS, OR TO AT LEAST PRE-EXISTING CONDITIONS.
- ALL UTILITY CROSSINGS SHALL BE PROTECTED AND SUPPORTED WITH GRANULAR FILL OR CONCRETE AS REQUIRED PER THE DETAIL SHEET.

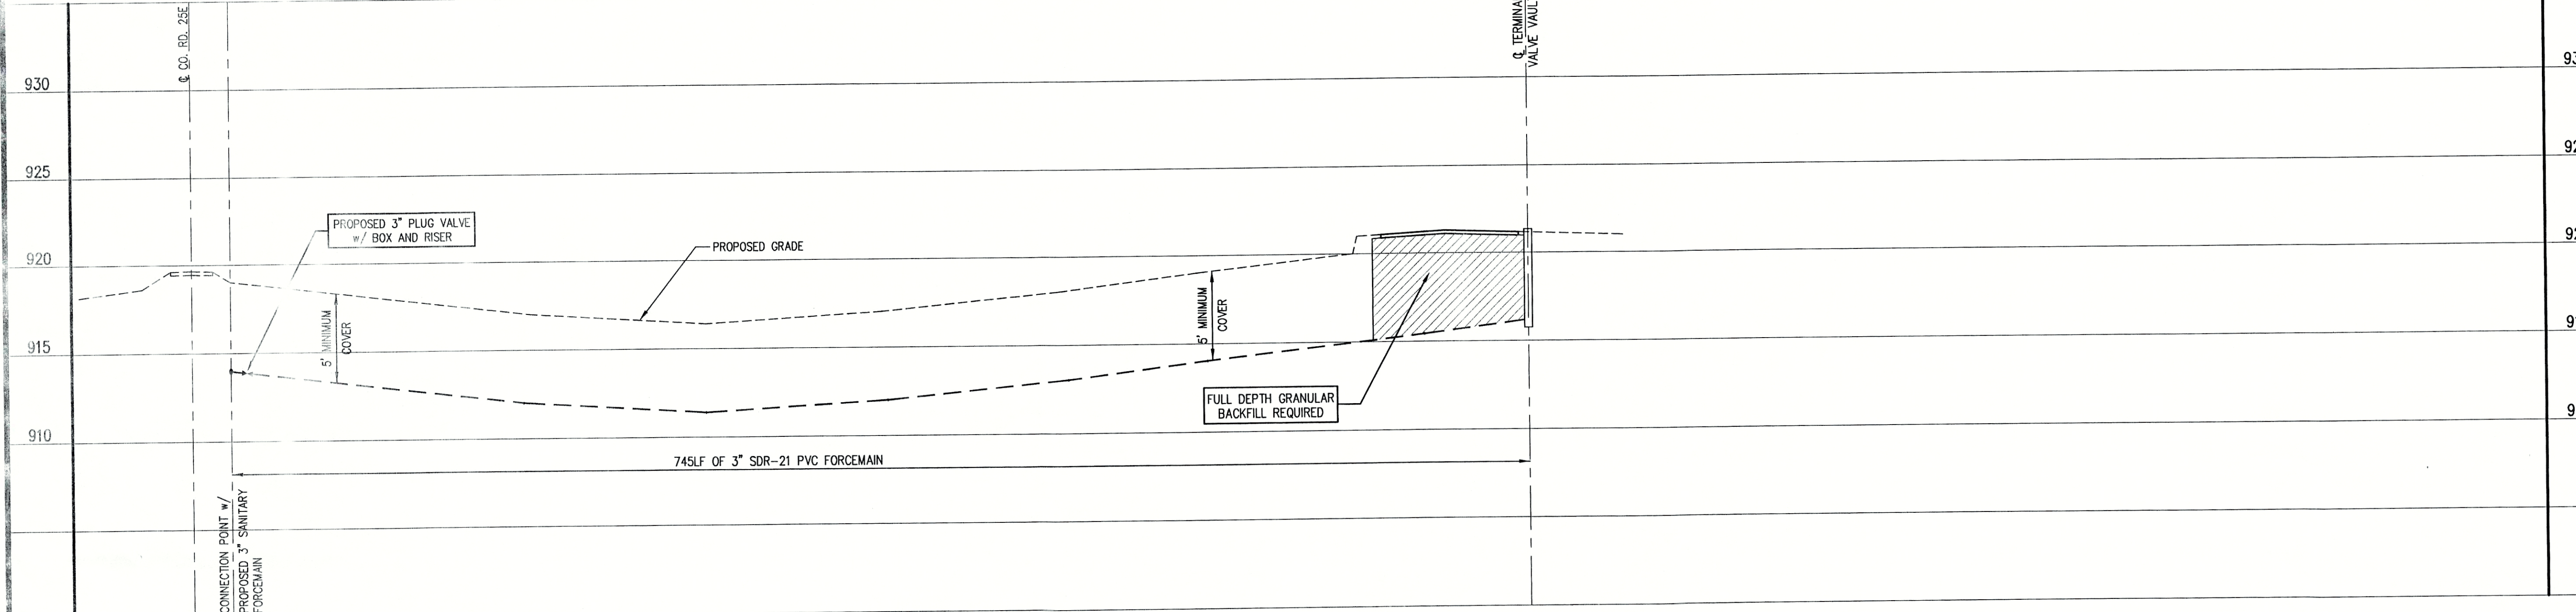

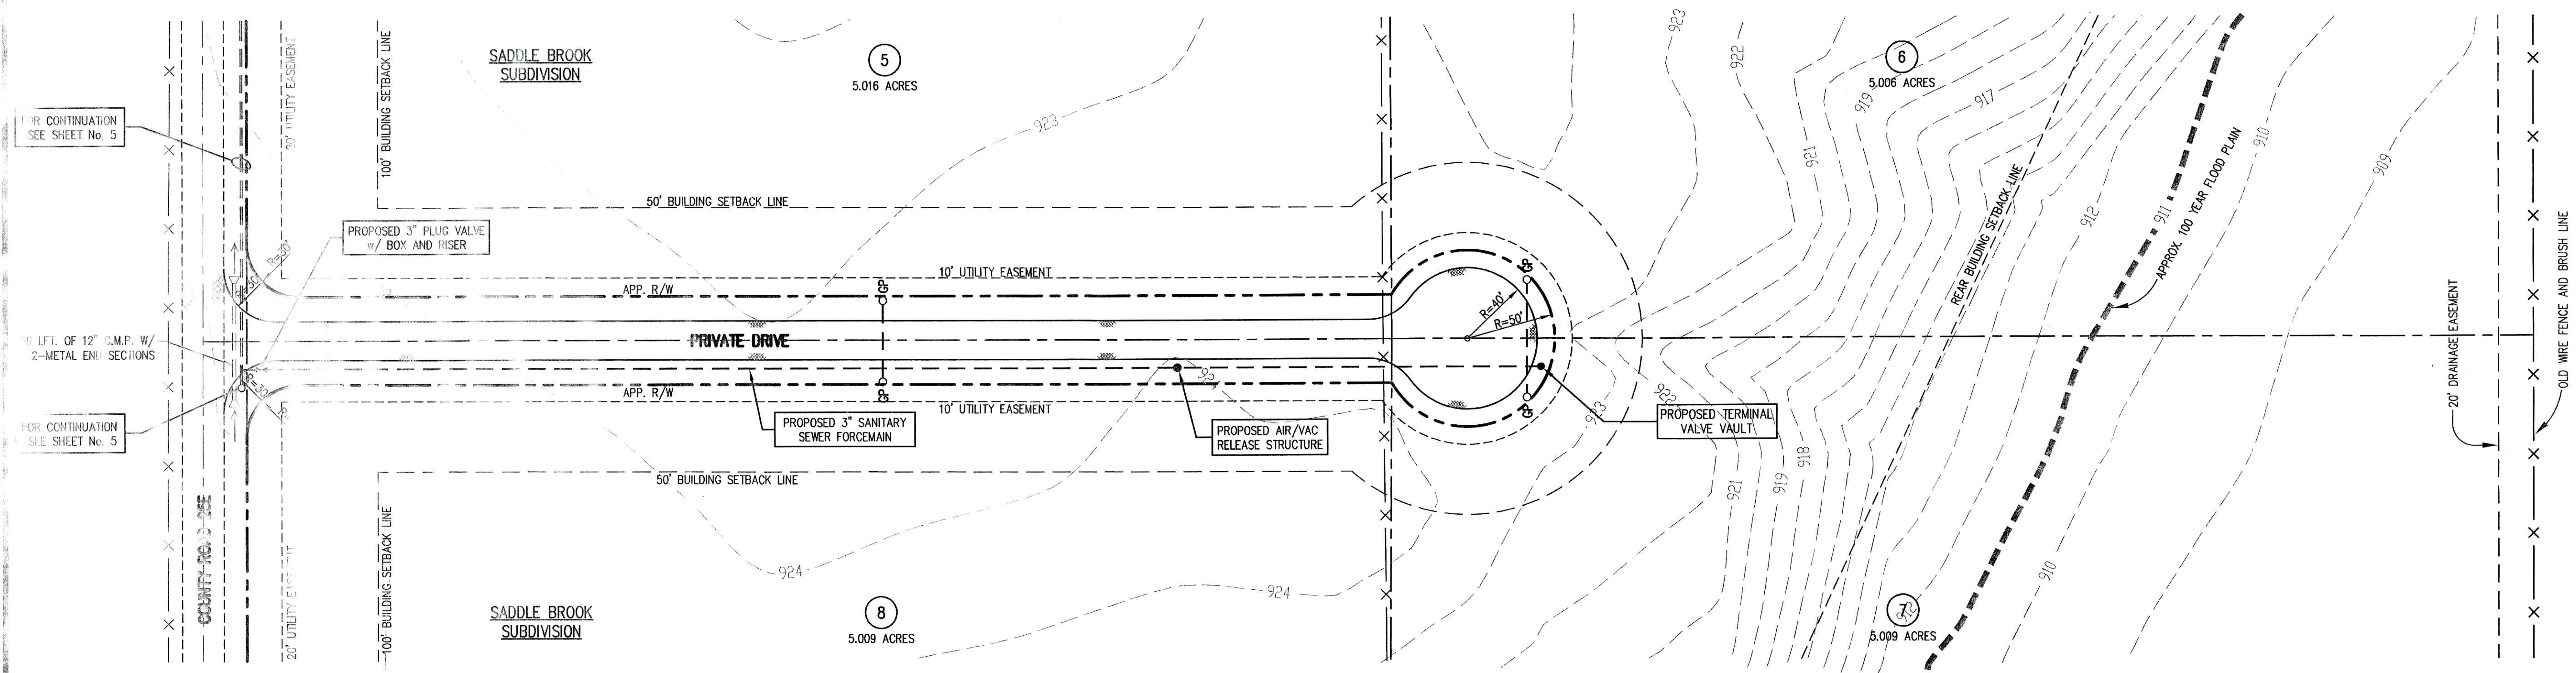

NOTE:
ADDITIONAL RIGHT-OF-WAY OR EASEMENTS MAY
NEED TO BE ACQUIRED FOR INSTALLATION OF SEWER.



PER INDIANA STATE LAW IS-89-1991, IT IS
AGAINST THE LAW TO EXCAVATE WITHOUT
NOTIFYING THE UNDERGROUND LOCATION SERVICE
TWO (2) WORKING DAYS BEFORE COMMENCING WORK.

NOTE: CONTRACTOR TO VERIFY ALL UTILITY LOCATIONS
PRIOR TO THE START OF CONSTRUCTION

GENERAL NOTES:

1. ALL UTILITY LOCATIONS ARE APPROXIMATE. THE CONTRACTOR SHALL HAVE ALL UTILITIES FIELD VERIFIED AND MARKED PRIOR TO CONSTRUCTION.
2. CONTRACTOR SHALL MAINTAIN A MINIMUM 10'-0" HORIZONTAL AND 18" VERTICAL SEPARATION BETWEEN SEWER AND WATER MAINS.
3. ALL PROPOSED TOP OF CASTING ELEVATIONS ARE APPROXIMATE. THE CONTRACTOR SHALL ADJUST FINAL ELEVATIONS AS REQUIRED TO BE FLUSH WITH PAVEMENT.
4. ALL SEWER TRENCHES SHALL BE BACKFILLED WITH FULL DEPTH COMPACTED GRANULAR BACKFILL ("B" BORROW) UNDER OR WITHIN 5' OF EDGE OF PAVEMENT.
5. THE CONTRACTOR SHALL VISIT THE SITE PRIOR TO BID TO BECOME FAMILIAR WITH ALL SITE CONDITIONS.
6. THE CONTRACTOR SHALL PROVIDE THE REQUIRED MEANS FOR MAINTAINING SAFE TRAFFIC AT ALL TIMES.
7. CONTRACTOR SHALL RESTORE ALL DISTURBED LAWN AREAS, STREETS, WALKS, DRIVES, ETC. AS SHOWN ON DRAWINGS, IN THE SPECIFICATIONS, OR TO AT LEAST PRE-EXISTING CONDITIONS.
8. ALL UTILITY CROSSINGS SHALL BE PROTECTED AND SUPPORTED WITH GRANULAR FILL OR CONCRETE AS REQUIRED PER THE DETAIL SHEET.


- TREE
- POWER POLE
- GUY WIRE
- ⋈ FIRE HYDRANT
- ⊕ MAILBOX
- ⊕ FLAGPOLE
- X 1085.2 SPOT SHOT

LEGEND:

- 1085 CONTOUR
- FENCE
- EXISTING SANITARY SEWER FORCEMAIN
- NEW SANITARY SEWER FORCEMAIN
- NEW GRINDER PUMP VAULT
- 4" W WATER LINE
- 2" G GAS LINE
- UNDERGROUND ELECTRIC LINE
- UNDERGROUND TELEPHONE LINE
- APPROX. RIGHT-OF-WAY
- APPROX. CORPORATE LIMITS
- APPROX. PROPERTY LINE
- W EXISTING WATER WELL
- S EXISTING SEPTIC TANK
- EXISTING TELEPHONE RISER



SCALE:
HORIZONTAL 1" = 50'
VERTICAL 1" = 5'

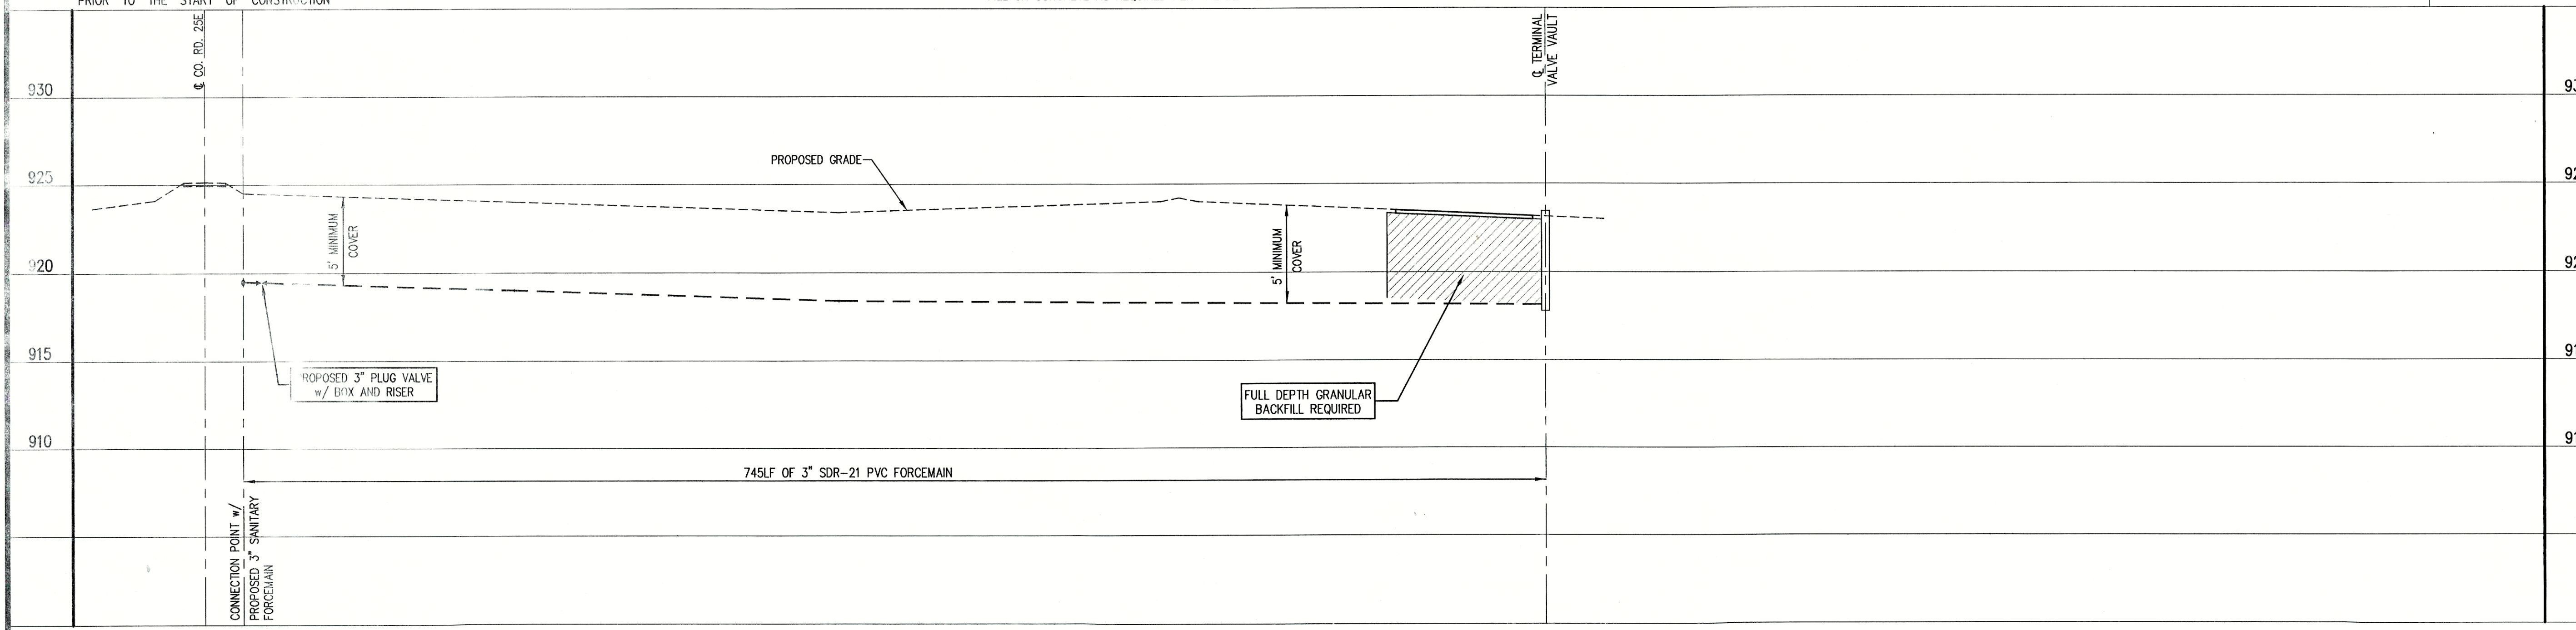



NOTES:
ALL GRINDER PUMP VALVE VAULTS SHALL BE
LOCATED INSIDE THE RIGHT-OF-WAY AT THE
EXISTING RIGHT-OF-WAY LINE.

CONSULTANT:

REVISIONS:

DATE	DESCRIPTION	BY

APPROVED BY:

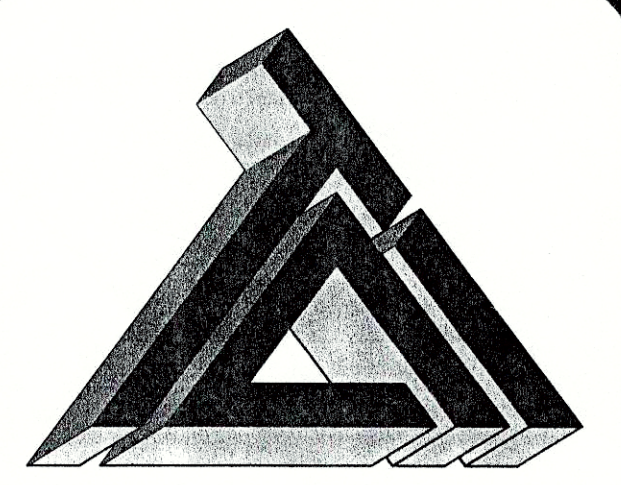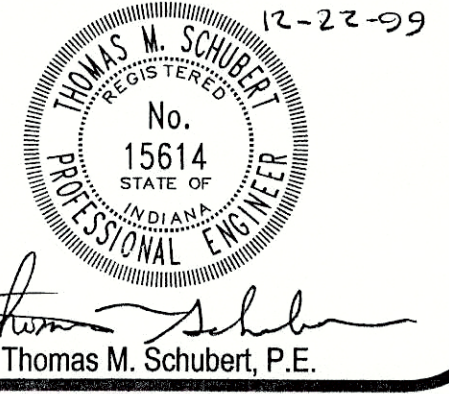

TRIAD ASSOCIATES INC.
5835 LAWTON LOOP EAST DRIVE
INDIANAPOLIS, INDIANA 46216
PHONE: 317-377-5230 FAX: 317-377-5241

DESIGNED FOR:

**SADDLE BROOK ADDITION
OWNER: MR. LARRY KEESLING**

SHEET TITLE:
SANITARY SEWER COLLECTION
SYSTEM PLAN AND PROFILE


JOB NUMBER: 980021
SCALE: AS NOTED
PLOT SCALE: 1"=50'
DRAWN BY: DAP
DESIGNED BY: D.A. Pauling
DRAWING NAME: CR25E_C5

CHECKED BY: J.W.F.
PLOT DATE: 12/22/99
DATE: 04/12/98


SHEET No.

07


OF 08

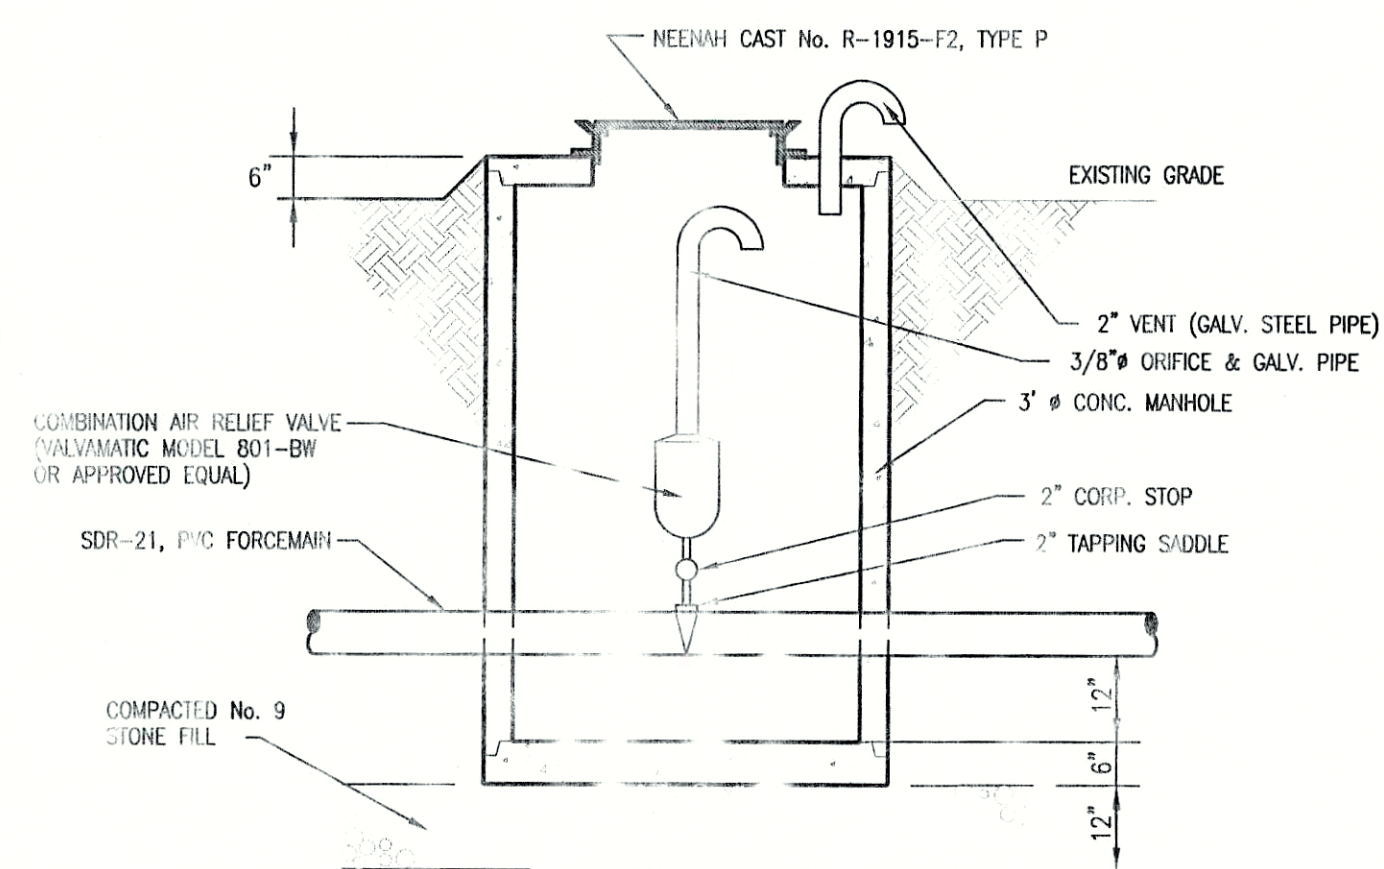


1 AIR / VAC RELIEF STRUCTURE
SCALE: N.T.S.

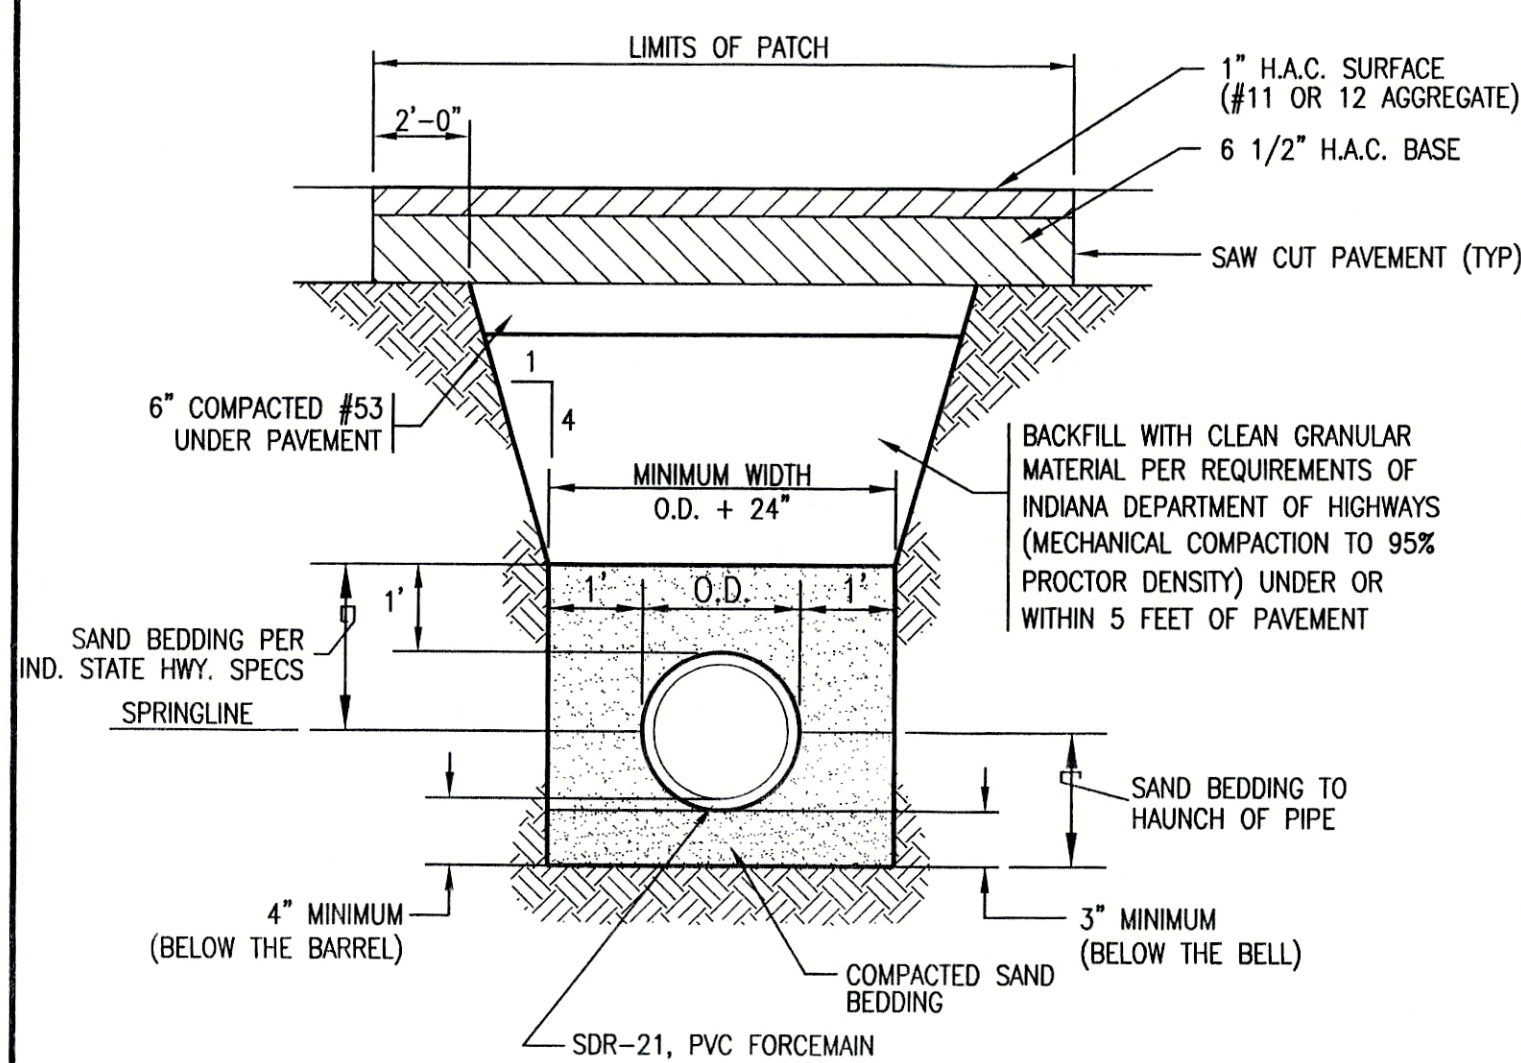


2 TYPICAL TRENCH AND PAVEMENT PATCH DETAIL
SCALE: N.T.S.

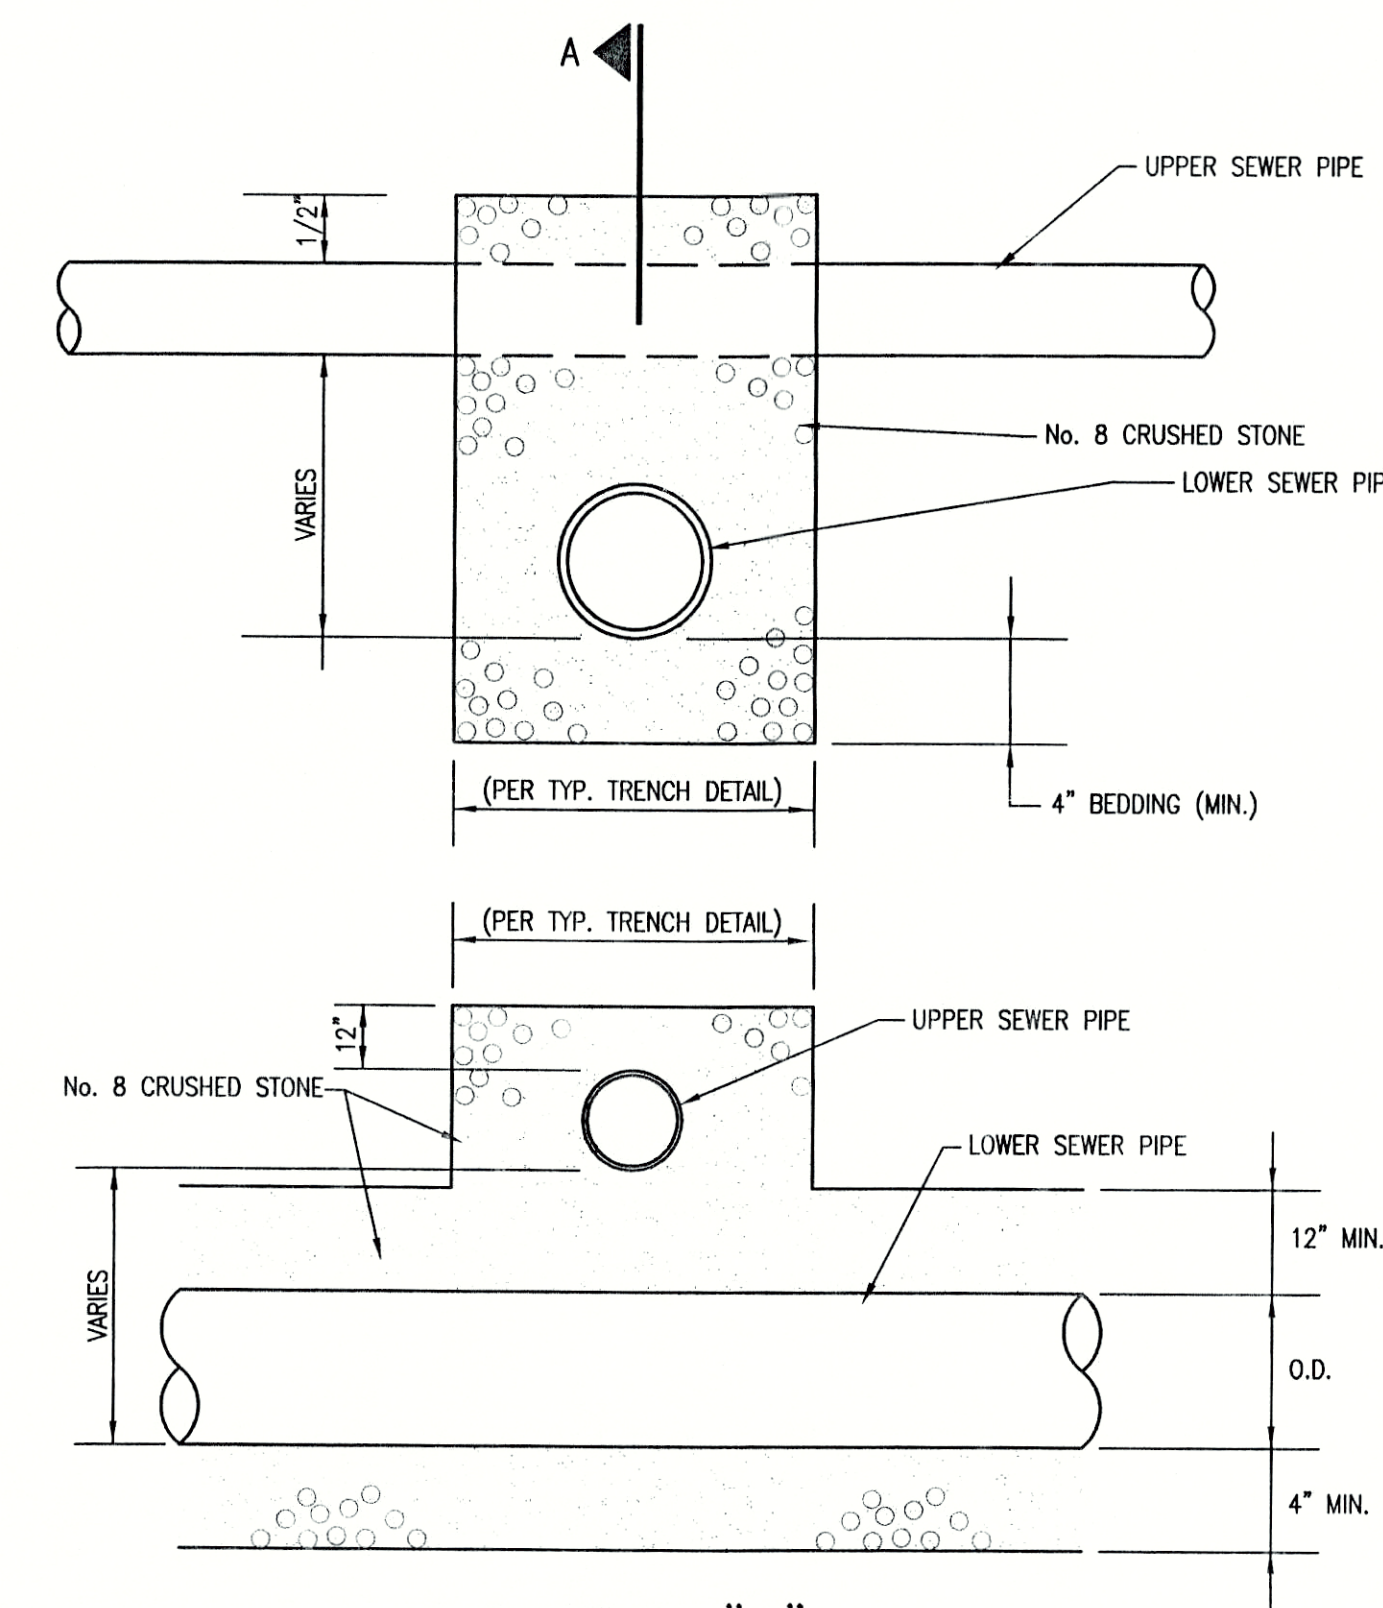


3 STORM SEWER/SANITARY SEWER CROSSING DETAIL
SCALE: N.T.S.

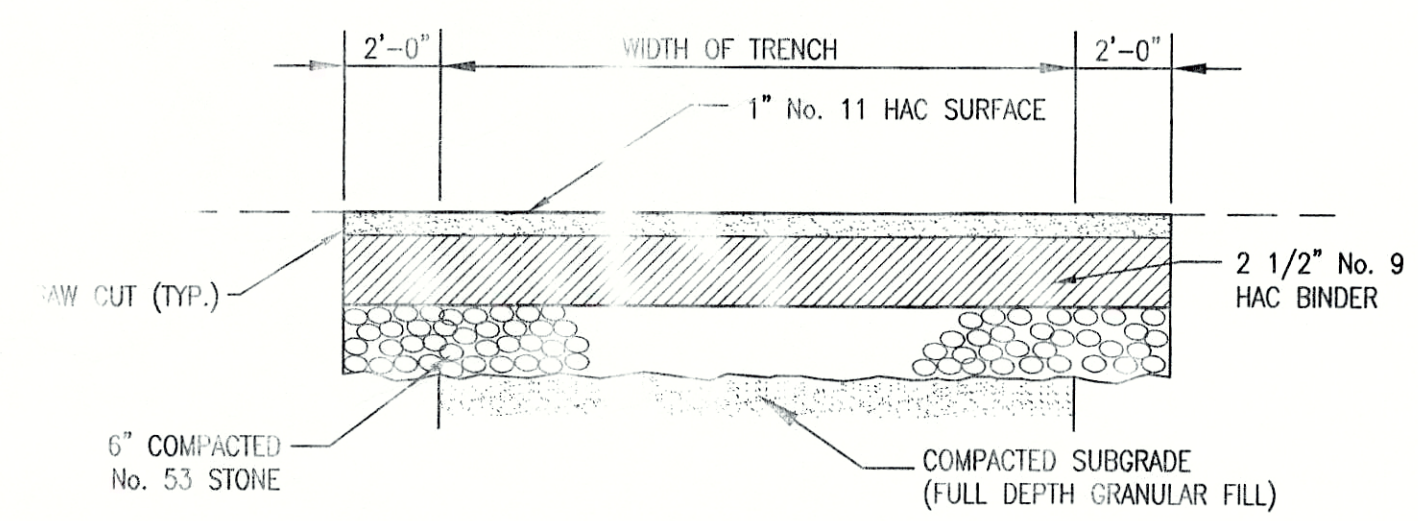


5 ASPHALT DRIVE REPAIR DETAIL
SCALE: N.T.S.

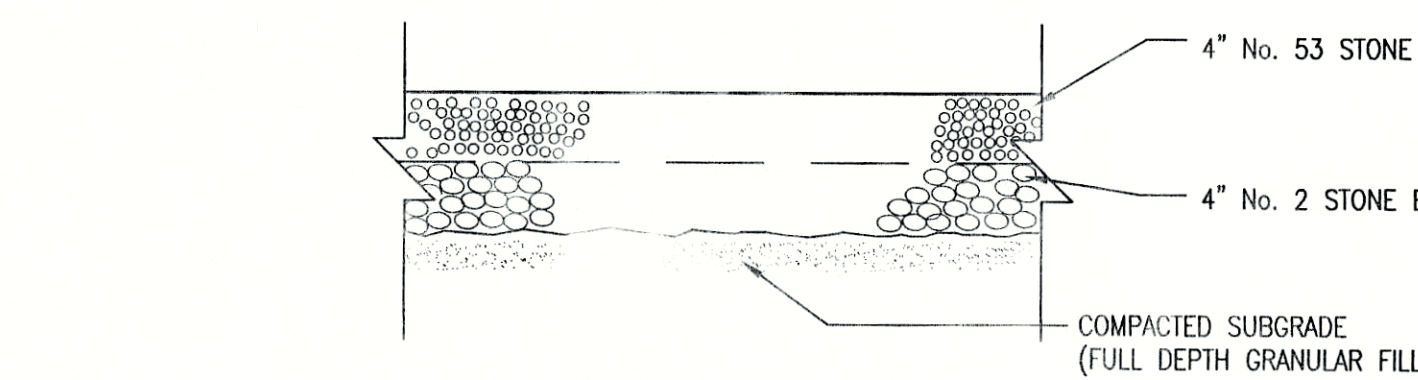


6 STONE DRIVE REPAIR DETAIL
SCALE: N.T.S.

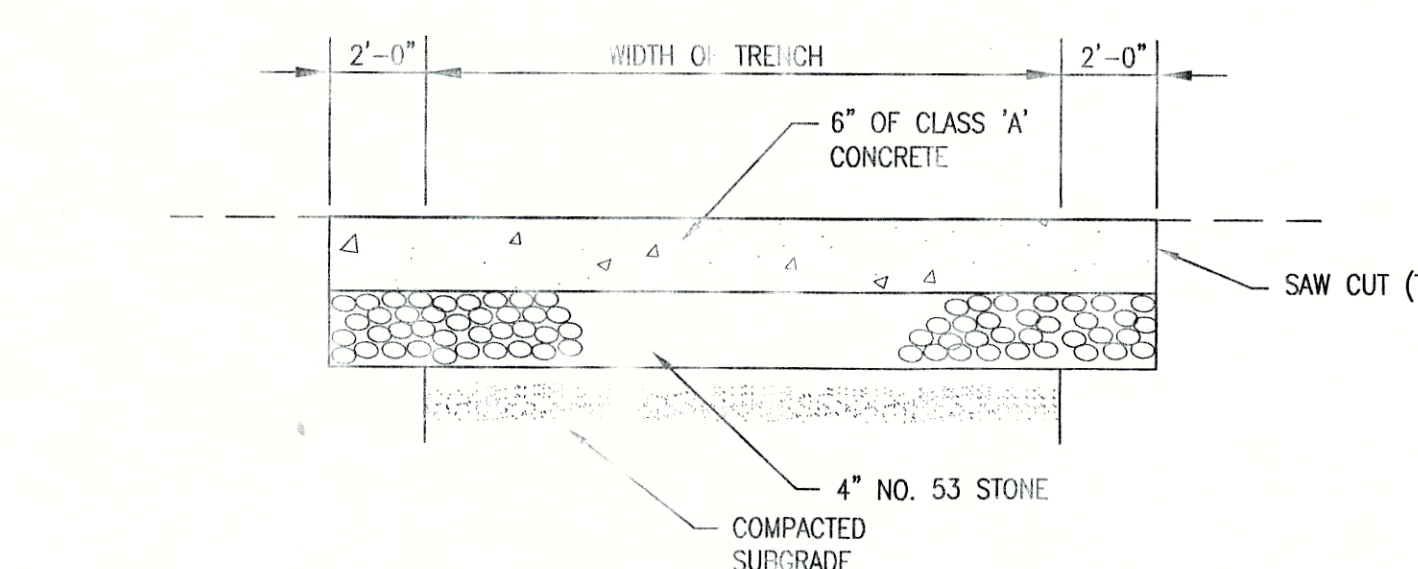


7 CONCRETE DRIVE REPAIR DETAIL
SCALE: N.T.S.

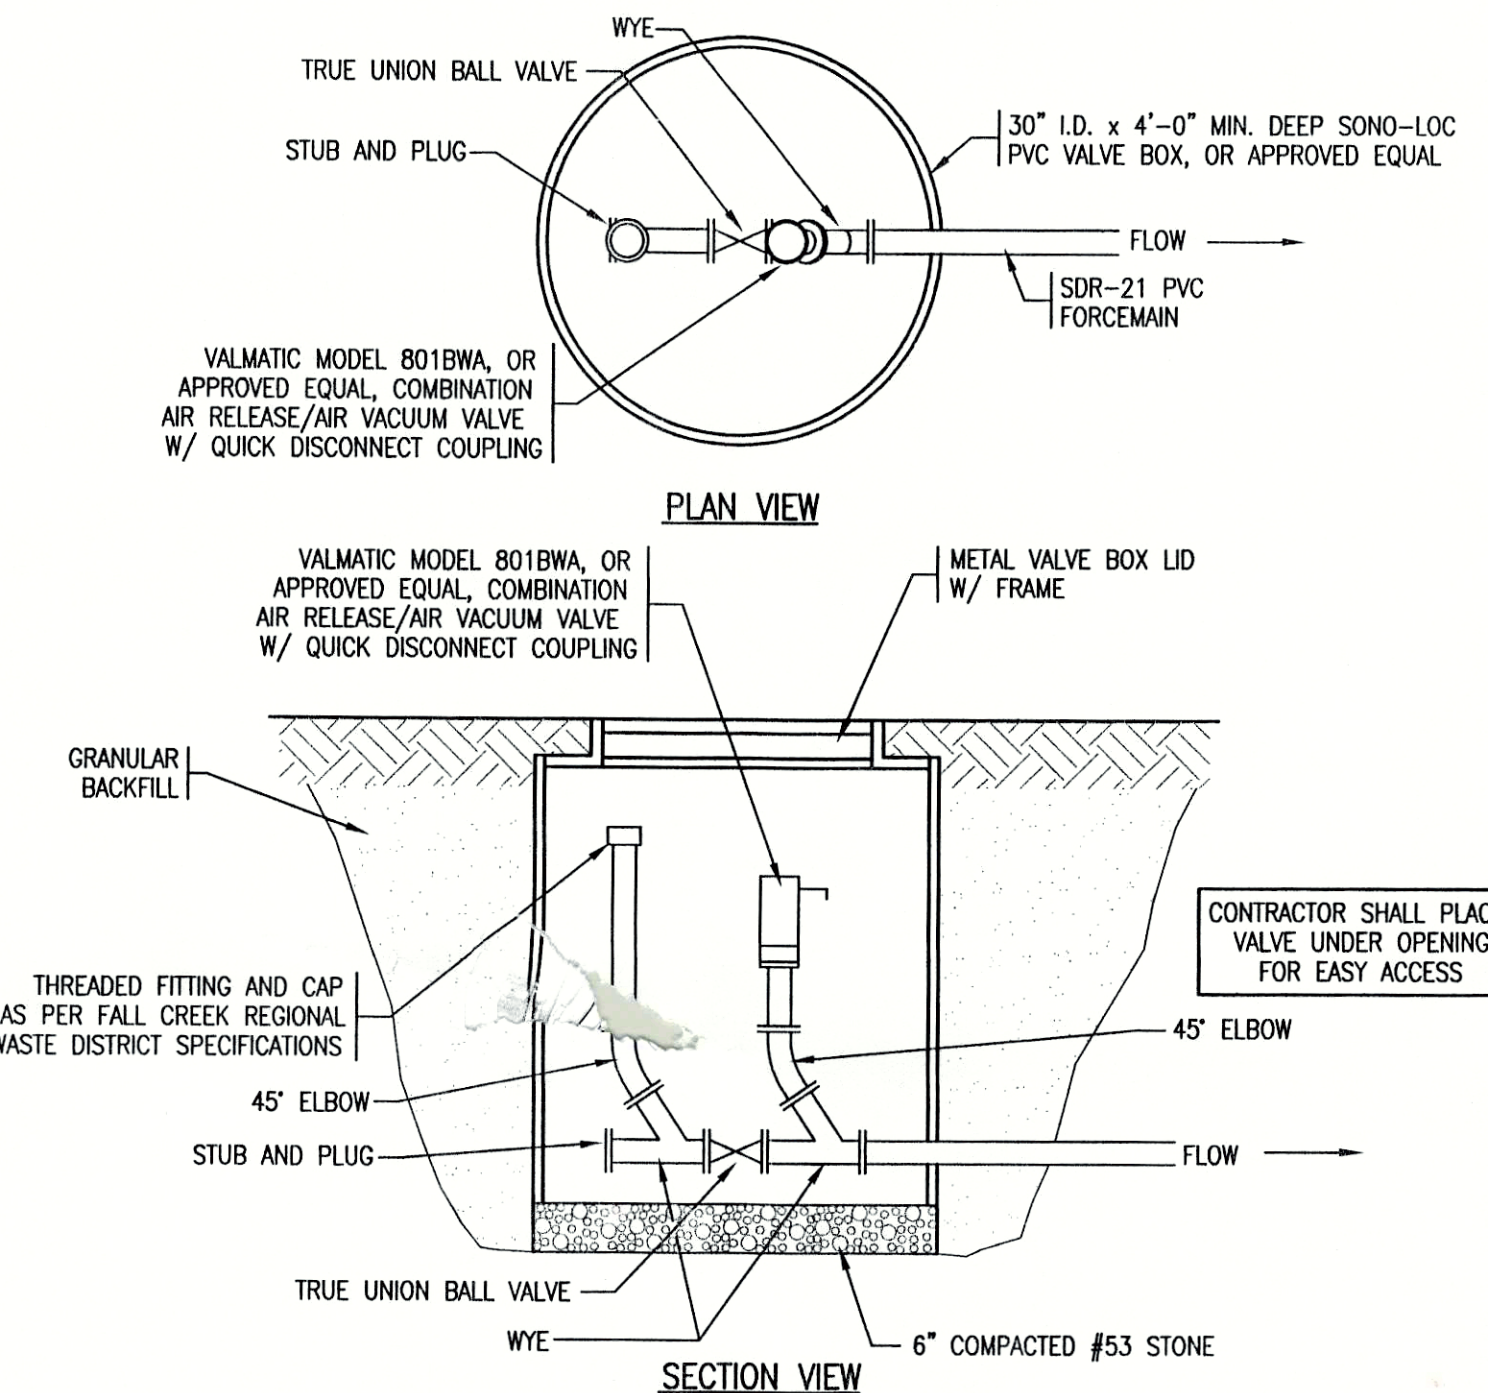


8 TERMINAL VALVE VAULT w/ AIR/VAC RELEASE STRUCTURE
NOT TO SCALE

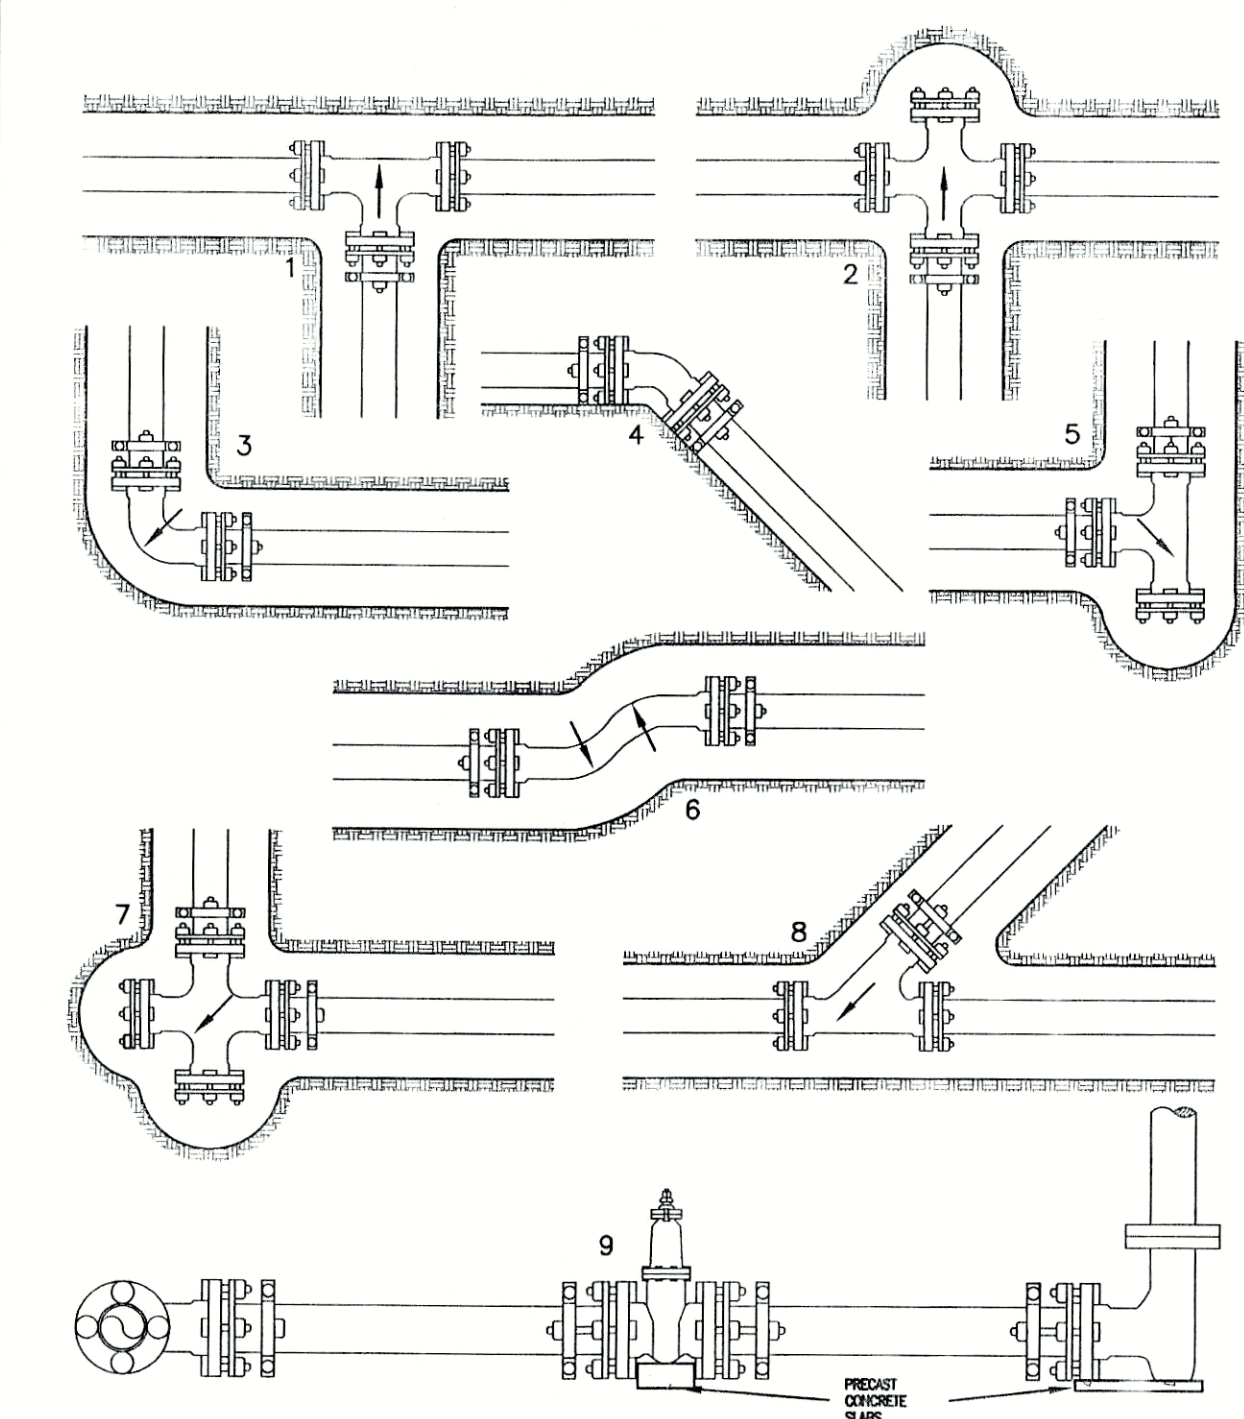


9 TYPES OF JOINT RESTRAINING
SCALE: N.T.S.

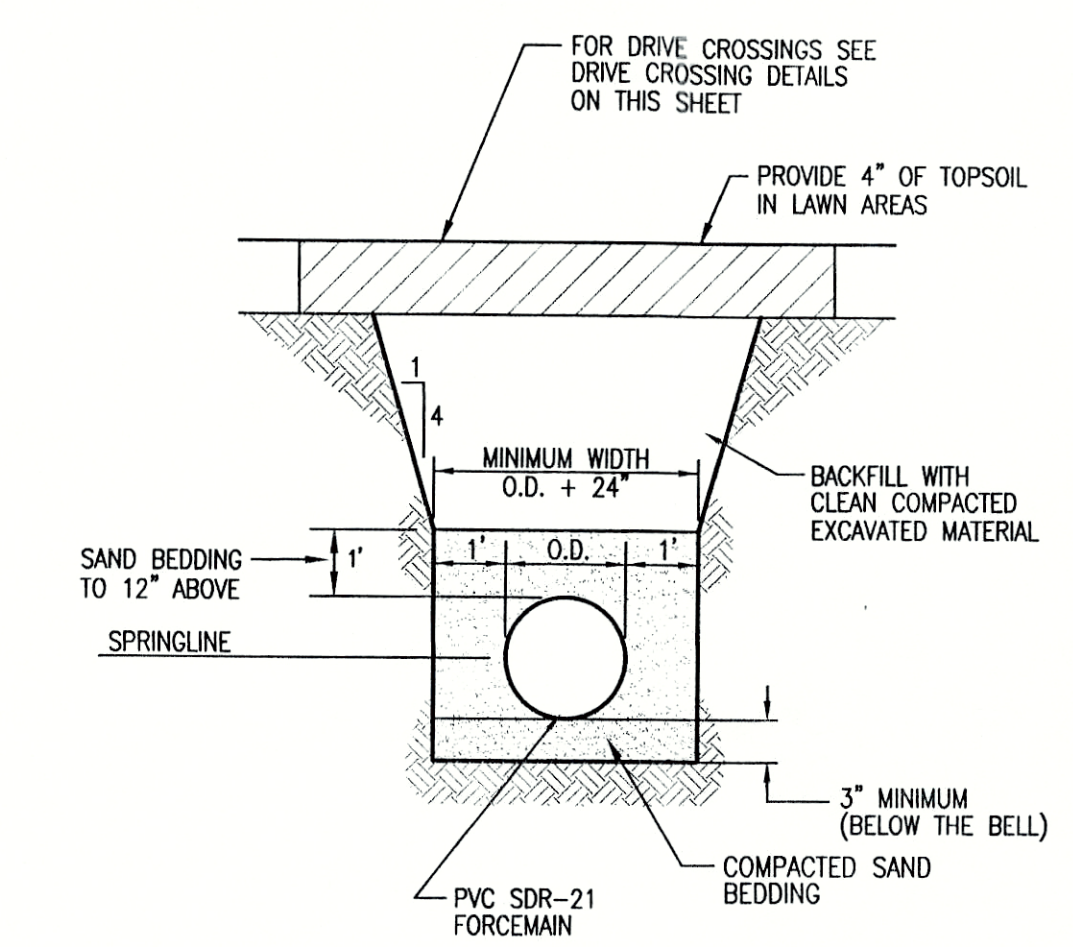

4 TYPICAL FORCEMAIN SEWER TRENCH DETAIL (LAWN AREA)
SCALE: N.T.S.

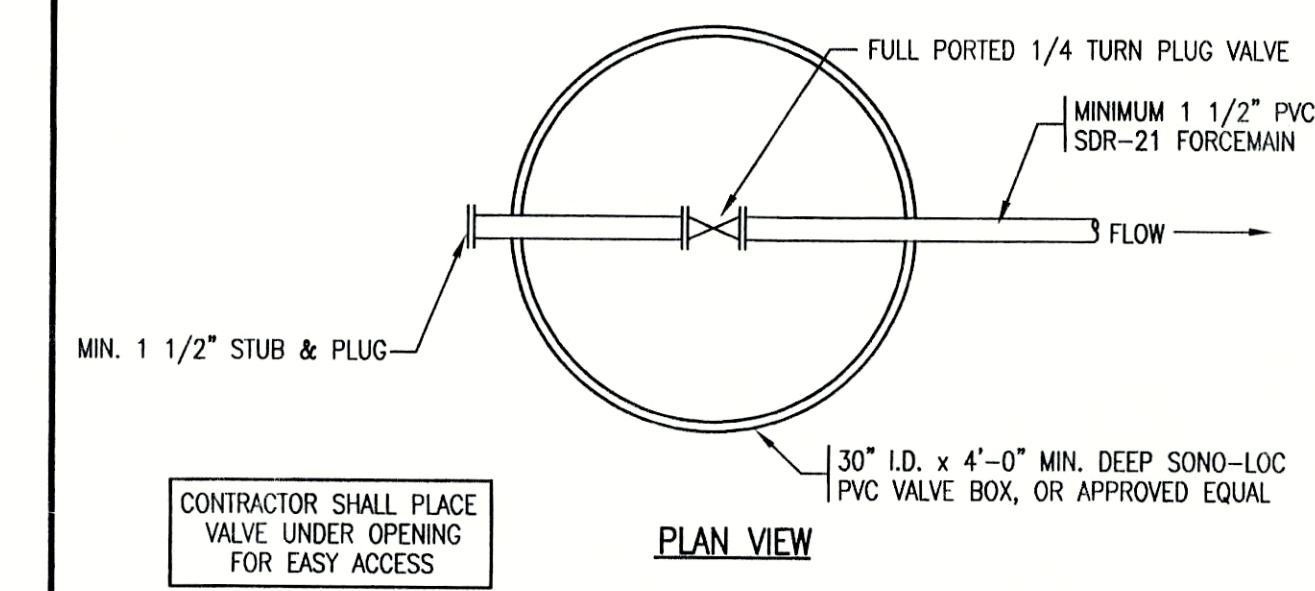

10 STANDARD SERVICE CONNECTION VALVE VAULT
NOT TO SCALE

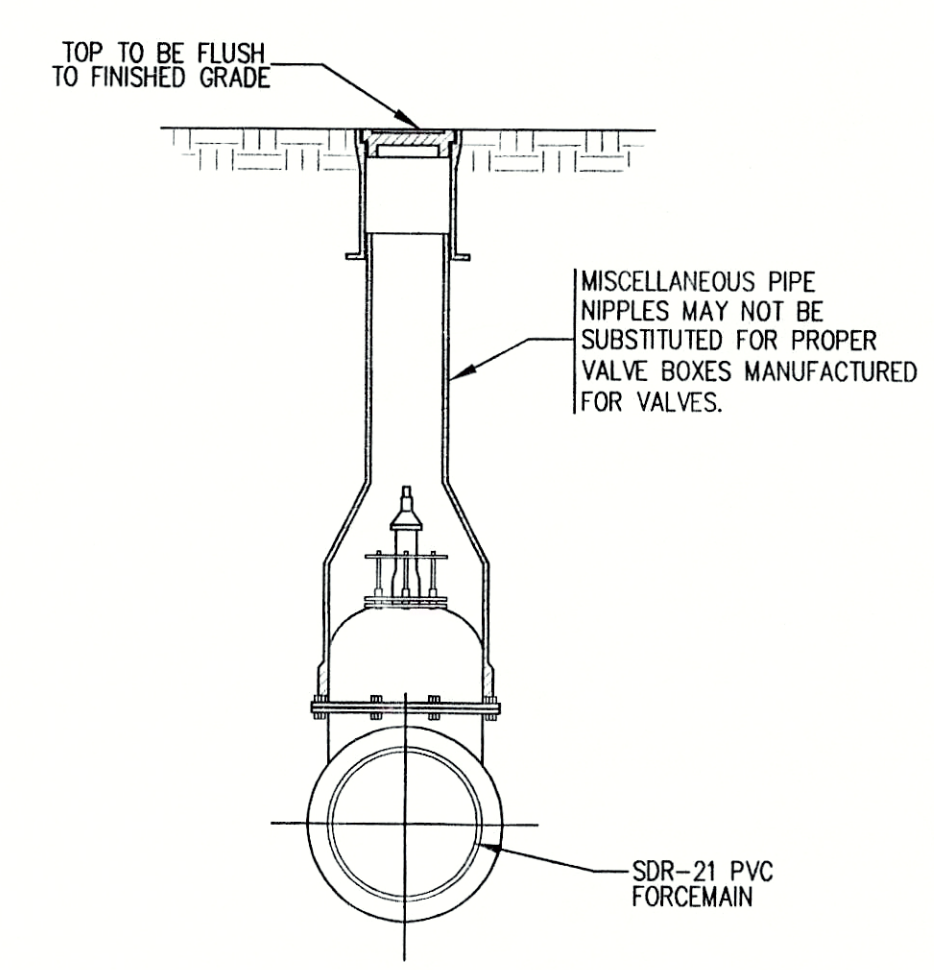



11 VALVE BOX SECTION
SCALE: N.T.S.

CONSULTANT:

REVISIONS:

DATE	DESCRIPTION	BY

APPROVED BY:

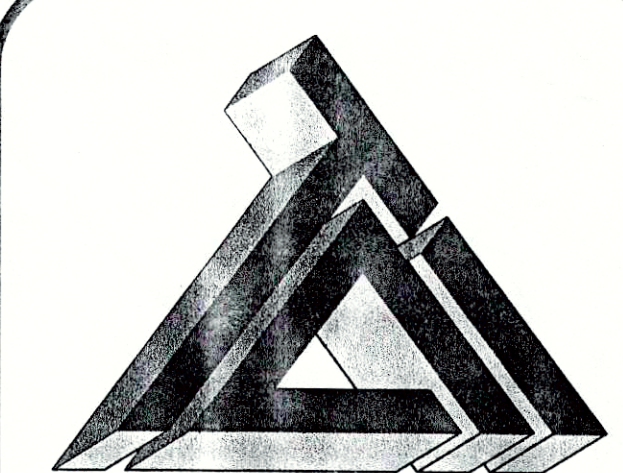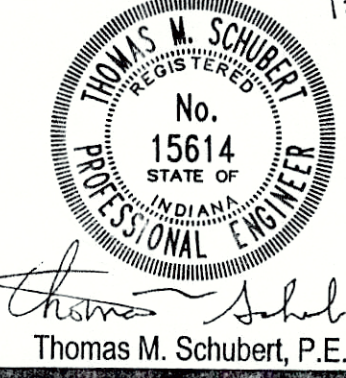

TRIAD ASSOCIATES INC.
5835 LAWTON LOOP EAST DRIVE
INDIANAPOLIS, INDIANA 46216
PHONE: 317-377-5230 FAX: 317-377-5241

DESIGNED FOR:

SADDLE BROOK ADDITION
OWNER: MR. LARRY KEESLING

SHEET TITLE:
SANITARY SEWER COLLECTION SYSTEM STANDARD DETAILS

JOB NUMBER: 980021	CHECKED BY: J.W.F.
SCALE: AS NOTED	DATE: 12/22/99
PLOT SCALE: 1"=1'	DATE: 04/12/98
DRAWN BY: D.A.P.	
DESIGNED BY: D.A. Pauling	
DRAWING NAME: CR25E D1	

SHEET No.

08

OF 08