
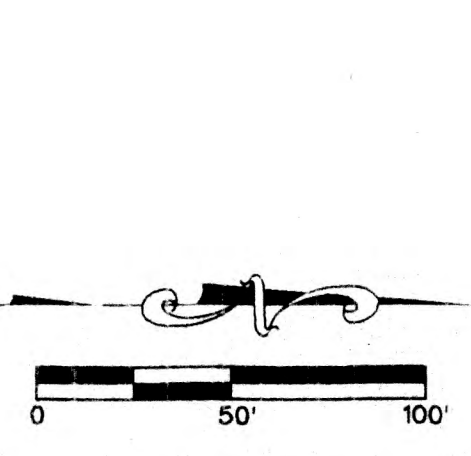
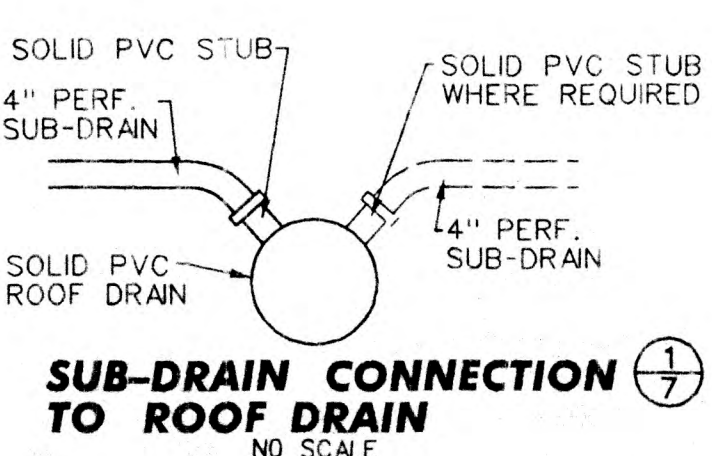
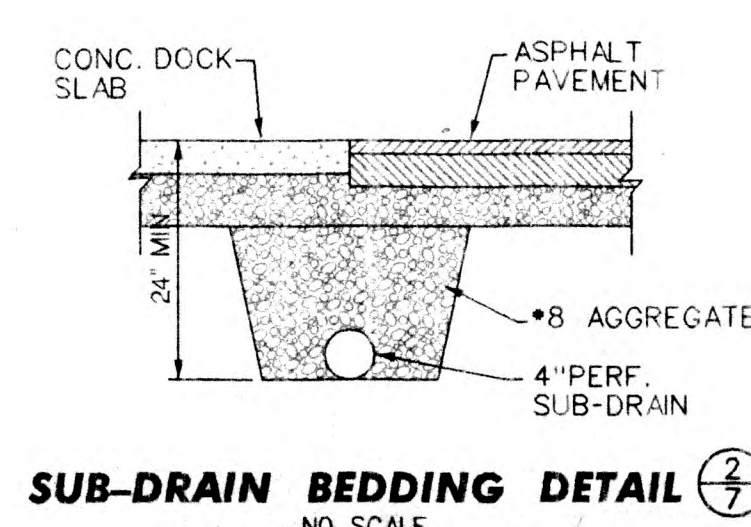


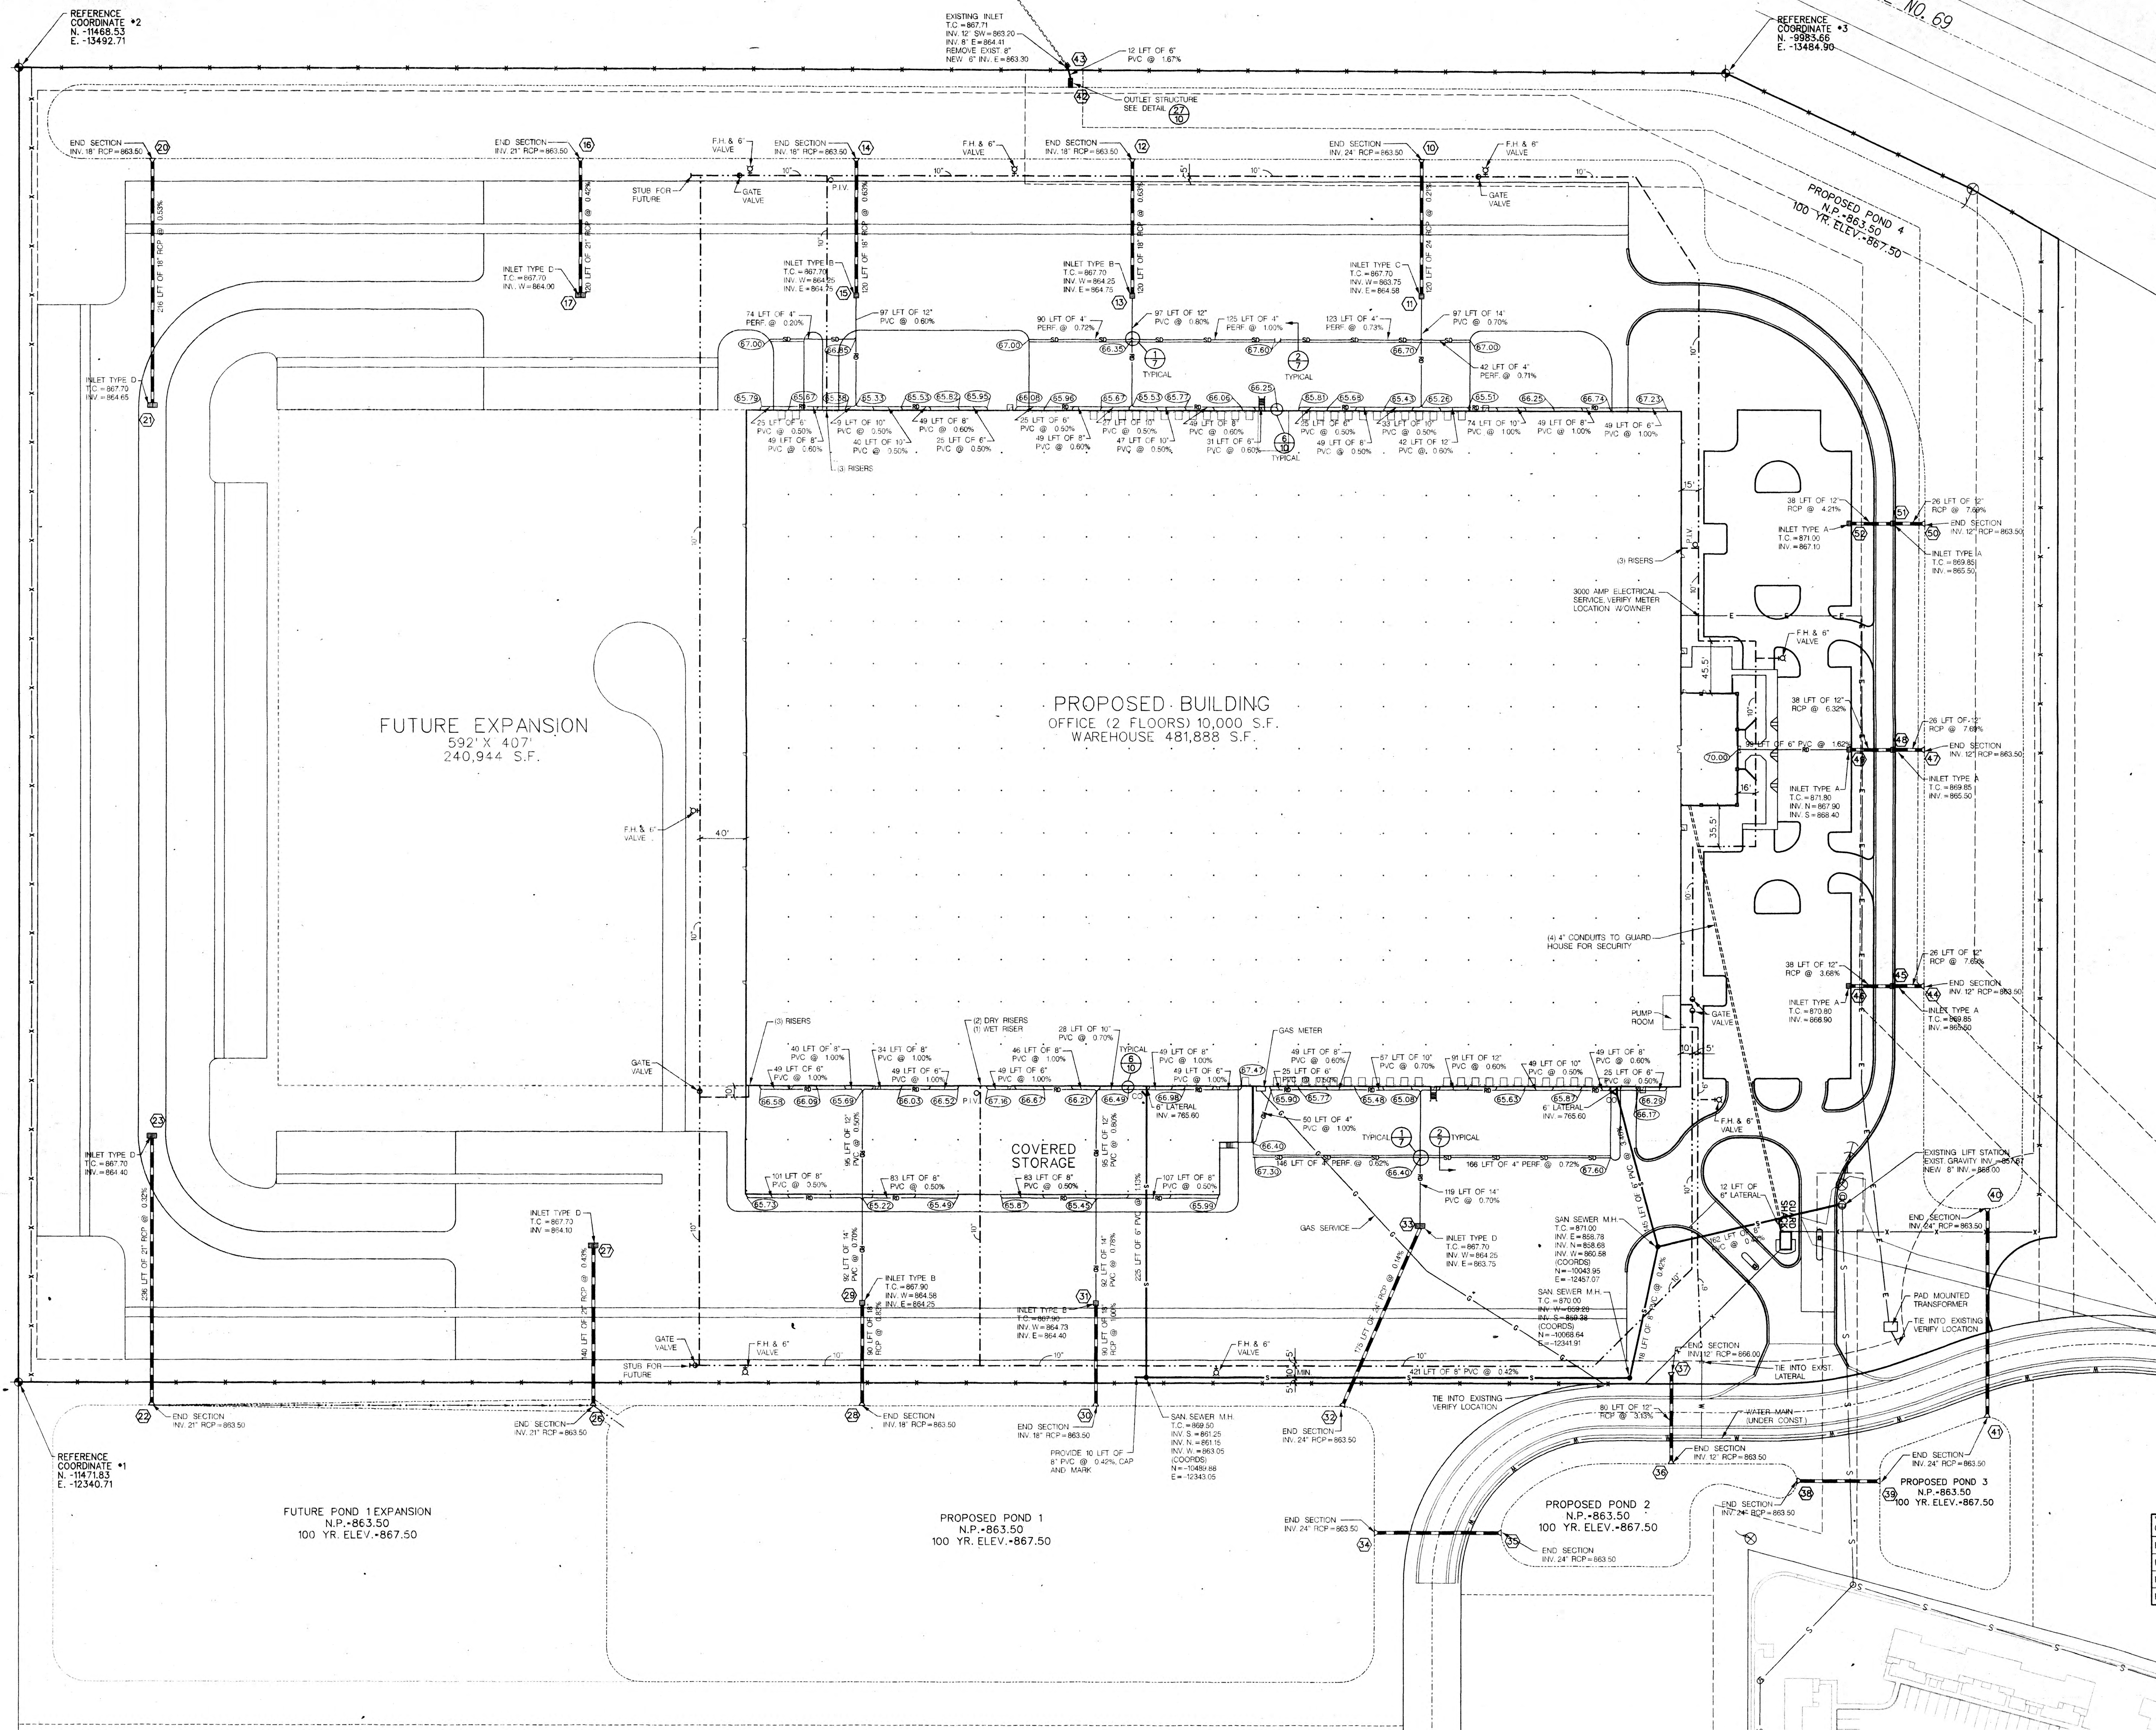

"DON'T DIG BLIND"

1-800-382-5544
CALL BEFORE YOU DIG
IUPPS REF. #


Sym.	Revisions	Date	Designed: RRL
			Drawn: RRL
			Checked: J.W.H.
			Scale: 1"=50'
			Date: 7-12-99

UTILITY PLAN

TSC DISTRIBUTION FACILITY

FALL CREEK T'SHIP, MADISON COUNTY

PENDLETON, INDIANA

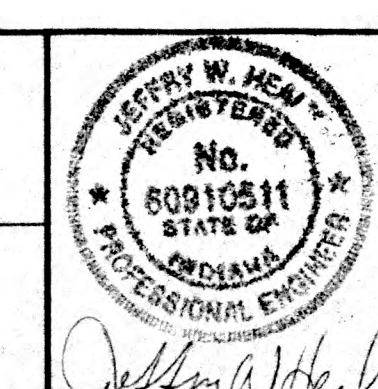

BANNING ENGINEERING, P.C.

CIVIL ENGINEERING ~ LAND SURVEYING

698 TOWER ROAD SUITE #100, PLAINFIELD, INDIANA 46168

BUS. (317) 839-2581, FAX (317) 838-9171, E-MAIL: banning@banning-eng.com

Project No: 99-207

Sheet No: 7 of 10