

WHITE OAKS ADDITION SANITARY SEWER PROJECT

PROJECT FOR THE FALL CREEK REGIONAL WASTE DISTRICT MADISON CO., IN.

1999

SRF PROJECT NO. CS 18207701

DIVISION II

CONTRACT 'A-1'

JOE ROWLETT - GENERAL MANAGER

FALL CREEK REGIONAL WASTE DISTRICT BOARD

Mr. Morris McCurdy - President
Mr. Doug McGee - Member
Mr. Mark Jablonski - Member
Mr. Agon Tolbert - Member
Mr. Dallas Foster - Member
Mr. Jack Kasdorf - Member
Mr. Timothy Green - Member
Mr. John Ellingwood - Member
Mr. Ed Stergar - Member
Mr. Joe Rowlett - General Manager

ATTORNEY

Mr. Chris Janak

MADISON COUNTY COMMISSIONERS

Mr. Paul Wilson
Mr. Otis E. Cox
Ms. Sandra S. Huntzinger

AUDITOR

Ms. Patricia Dillion


ATTORNEY

Mr. Gerald Shine

SHEET INDEX


<u>SHEET NO.</u>	<u>DESCRIPTION</u>
1	TITLE SHEET AND INDEX
2	PROJECT BASE MAP
3-9	PLAN AND PROFILE SHEETS
10-11	SANITARY SEWER DETAILS

AREA MAP

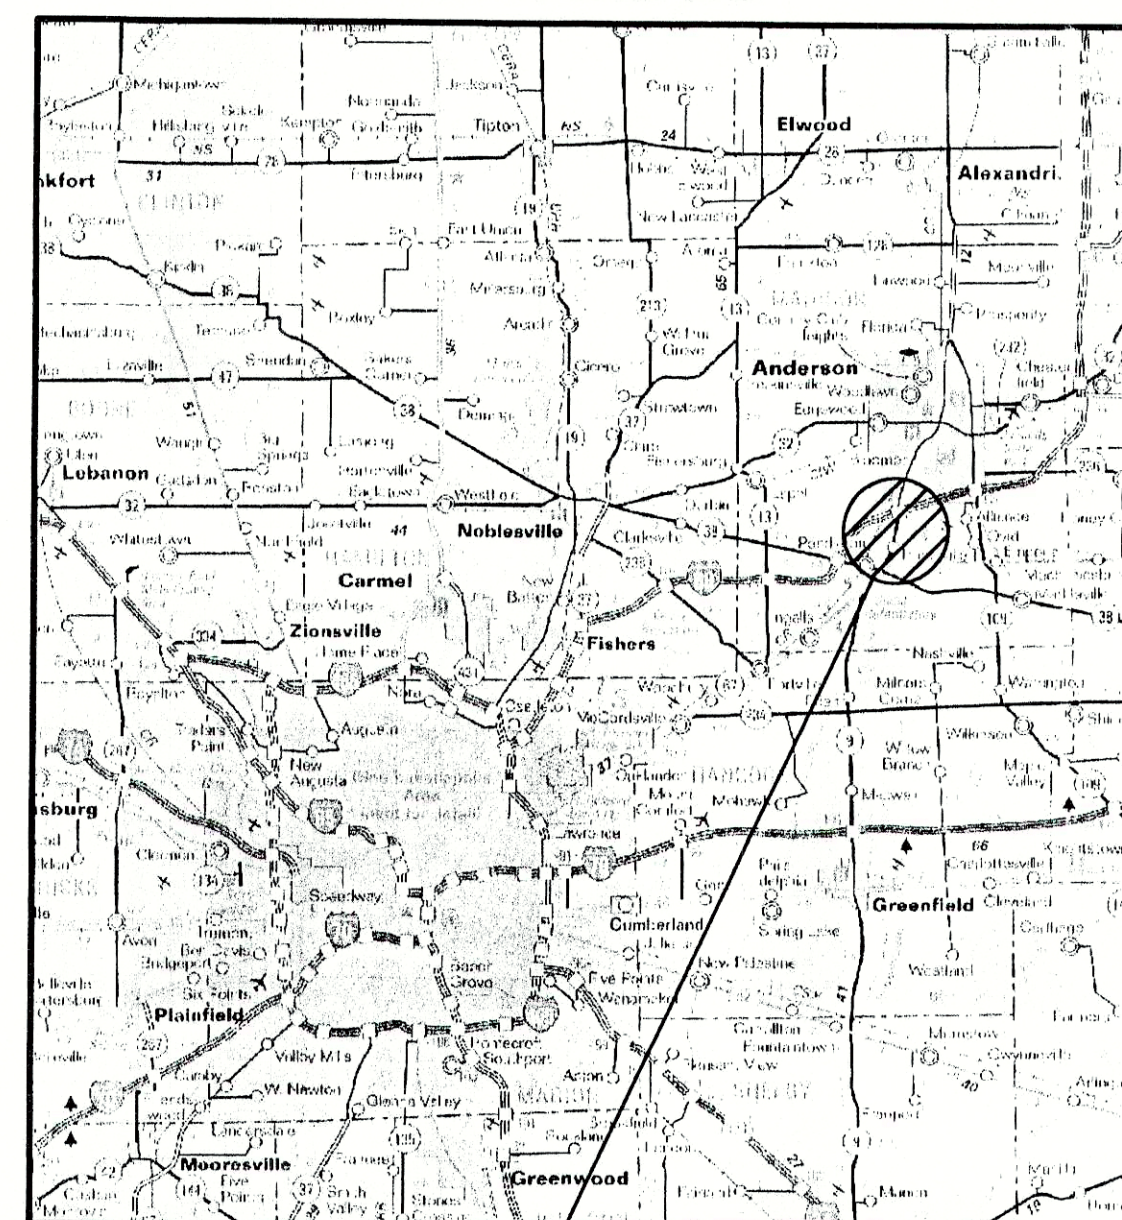


AREA
LOCATION

LOCATION MAP

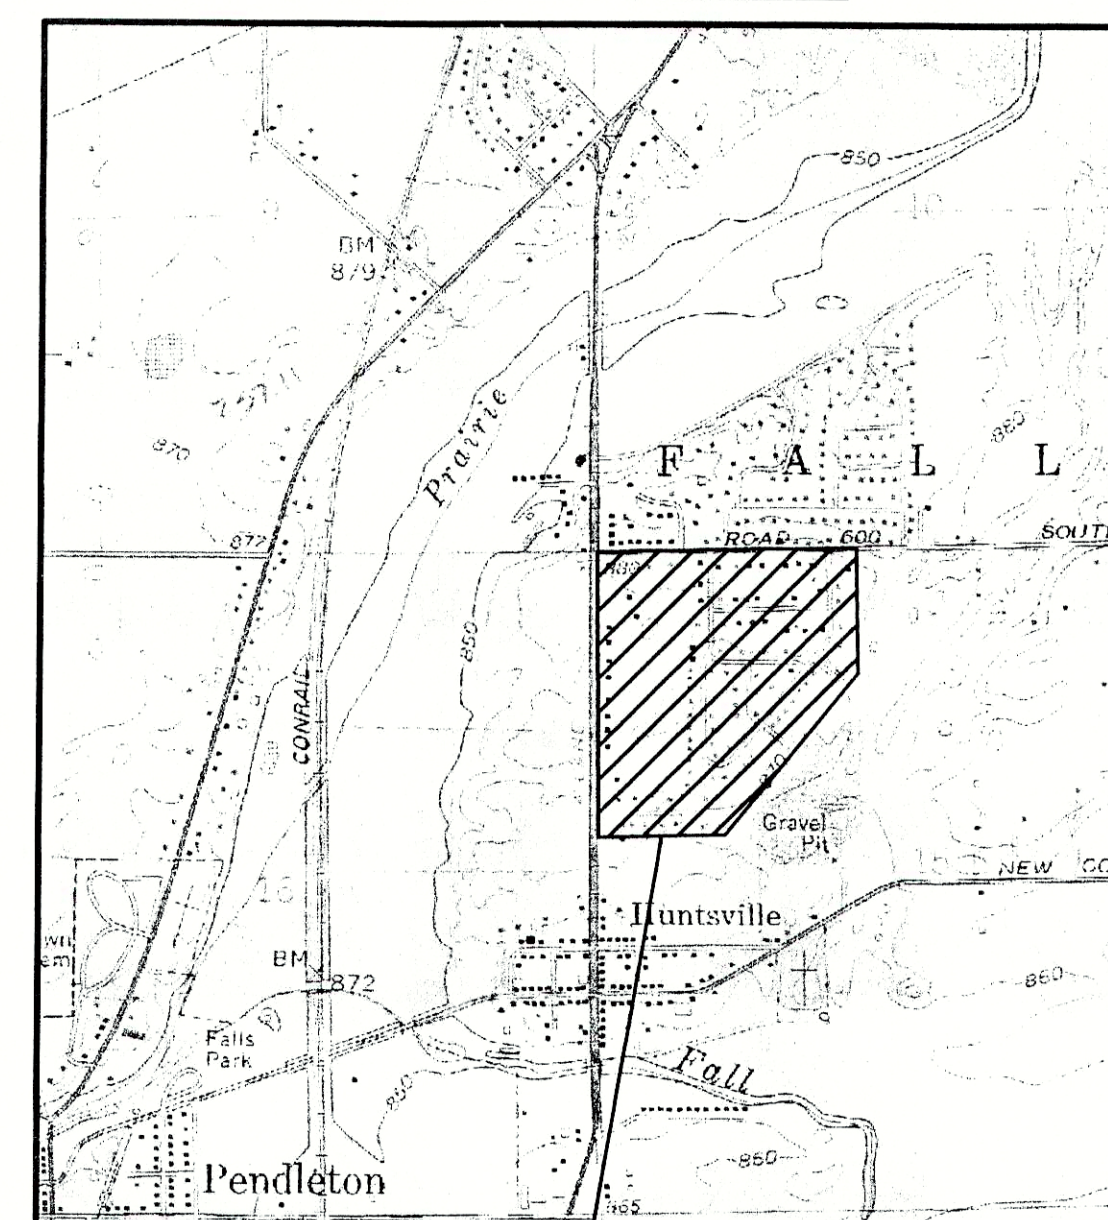

PROJECT
LOCATION

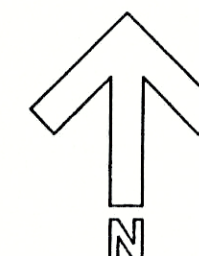

PLANS PREPARED BY:

**TRIAD
ASSOCIATES
INC.**
INDIANAPOLIS, INDIANA

NOTE:
ADDITIONAL RIGHT-OF-WAY OR EASEMENTS MAY
NEED TO BE ACQUIRED FOR INSTALLATION OF SEWER.



DON'T DIG BLIND
CALL BEFORE YOU DIG
1-800-362-5544
1-800-428-5200

PER INDIANA STATE LAW IS-69-1991, IT IS
AGAINST THE LAW TO EXCAVATE WITHOUT
NOTIFYING THE UNDERGROUND LOCATION SERVICE
TWO (2) WORKING DAYS BEFORE COMMENCING WORK.

NOTE: CONTRACTOR TO VERIFY ALL UTILITY LOCATIONS
PRIOR TO THE START OF CONSTRUCTION



THESE PLANS CERTIFIED BY:

James W. Frazell, Professional Engineer

RECORD DRAWING

February 15, 2001

Thomas M. Schubert, Professional Engineer

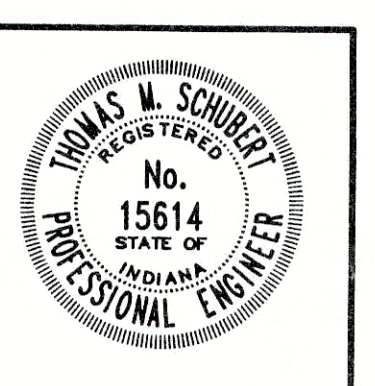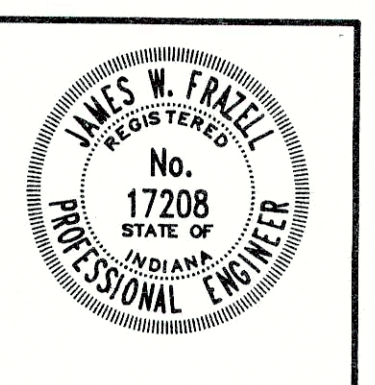

NOTE:
ADDITIONAL RIGHT-OF-WAY OR EASEMENTS MAY
NEED TO BE ACQUIRED FOR INSTALLATION OF SEWER.



DON'T DIG BLIND
CALL BEFORE YOU DIG
1-800-382-5544
1-800-428-5200

PER INDIANA STATE LAW IS-69-1991, IT IS
AGAINST THE LAW TO EXCAVATE WITHOUT
NOTIFYING THE UNDERGROUND LOCATION SERVICE
TWO (2) WORKING DAYS BEFORE COMMENCING WORK.
NOTE: CONTRACTOR TO VERIFY ALL UTILITY LOCATIONS
PRIOR TO THE START OF CONSTRUCTION

TBM INFORMATION

WO-TBM #1 - FIRE HYDRANT IN FRONT OF LACO IN HUNTSVILLE
FIRE HYDRANT BOLT UNDER LETTER "Y"
IN KENNEDY ELEV. - 871.16

WO-TBM #2 - EAST SIDE OF POWERPOLE #1916570 AT 150 EAST
ROAD INTERCHANGE OF CHESTNUT DRIVE AND
CANDLEWOOD DRIVE ELEV. - 875.36

UTILITIES

ANDERSON LIGHT AND POWER
550 BAXTER ROAD
ANDERSON, INDIANA 46016
1 (765) 648-6187

GTE
P.O. BOX 1406
RICHMOND, INDIANA 47375
1 (800) 483-5600


CYNERGY/PSI
100 S. MILL CREEK ROAD
NOBLESVILLE, INDIANA 46060
1 (800) 521-2232

INDIANA GAS COMPANY, INC.
2001 LOUISE STREET
ANDERSON, INDIANA 46016
1 (800) 777-2060

PENDLETON MUNICIPAL WATER UTILITY
P.O. BOX 230
PENDLETON, INDIANA 46064
1 (765) 778-2173

TCI OF CENTRAL INDIANA
335 E. 10th STREET
ANDERSON, INDIANA 46016
1 (765) 649-0407

36
39
43
11/8

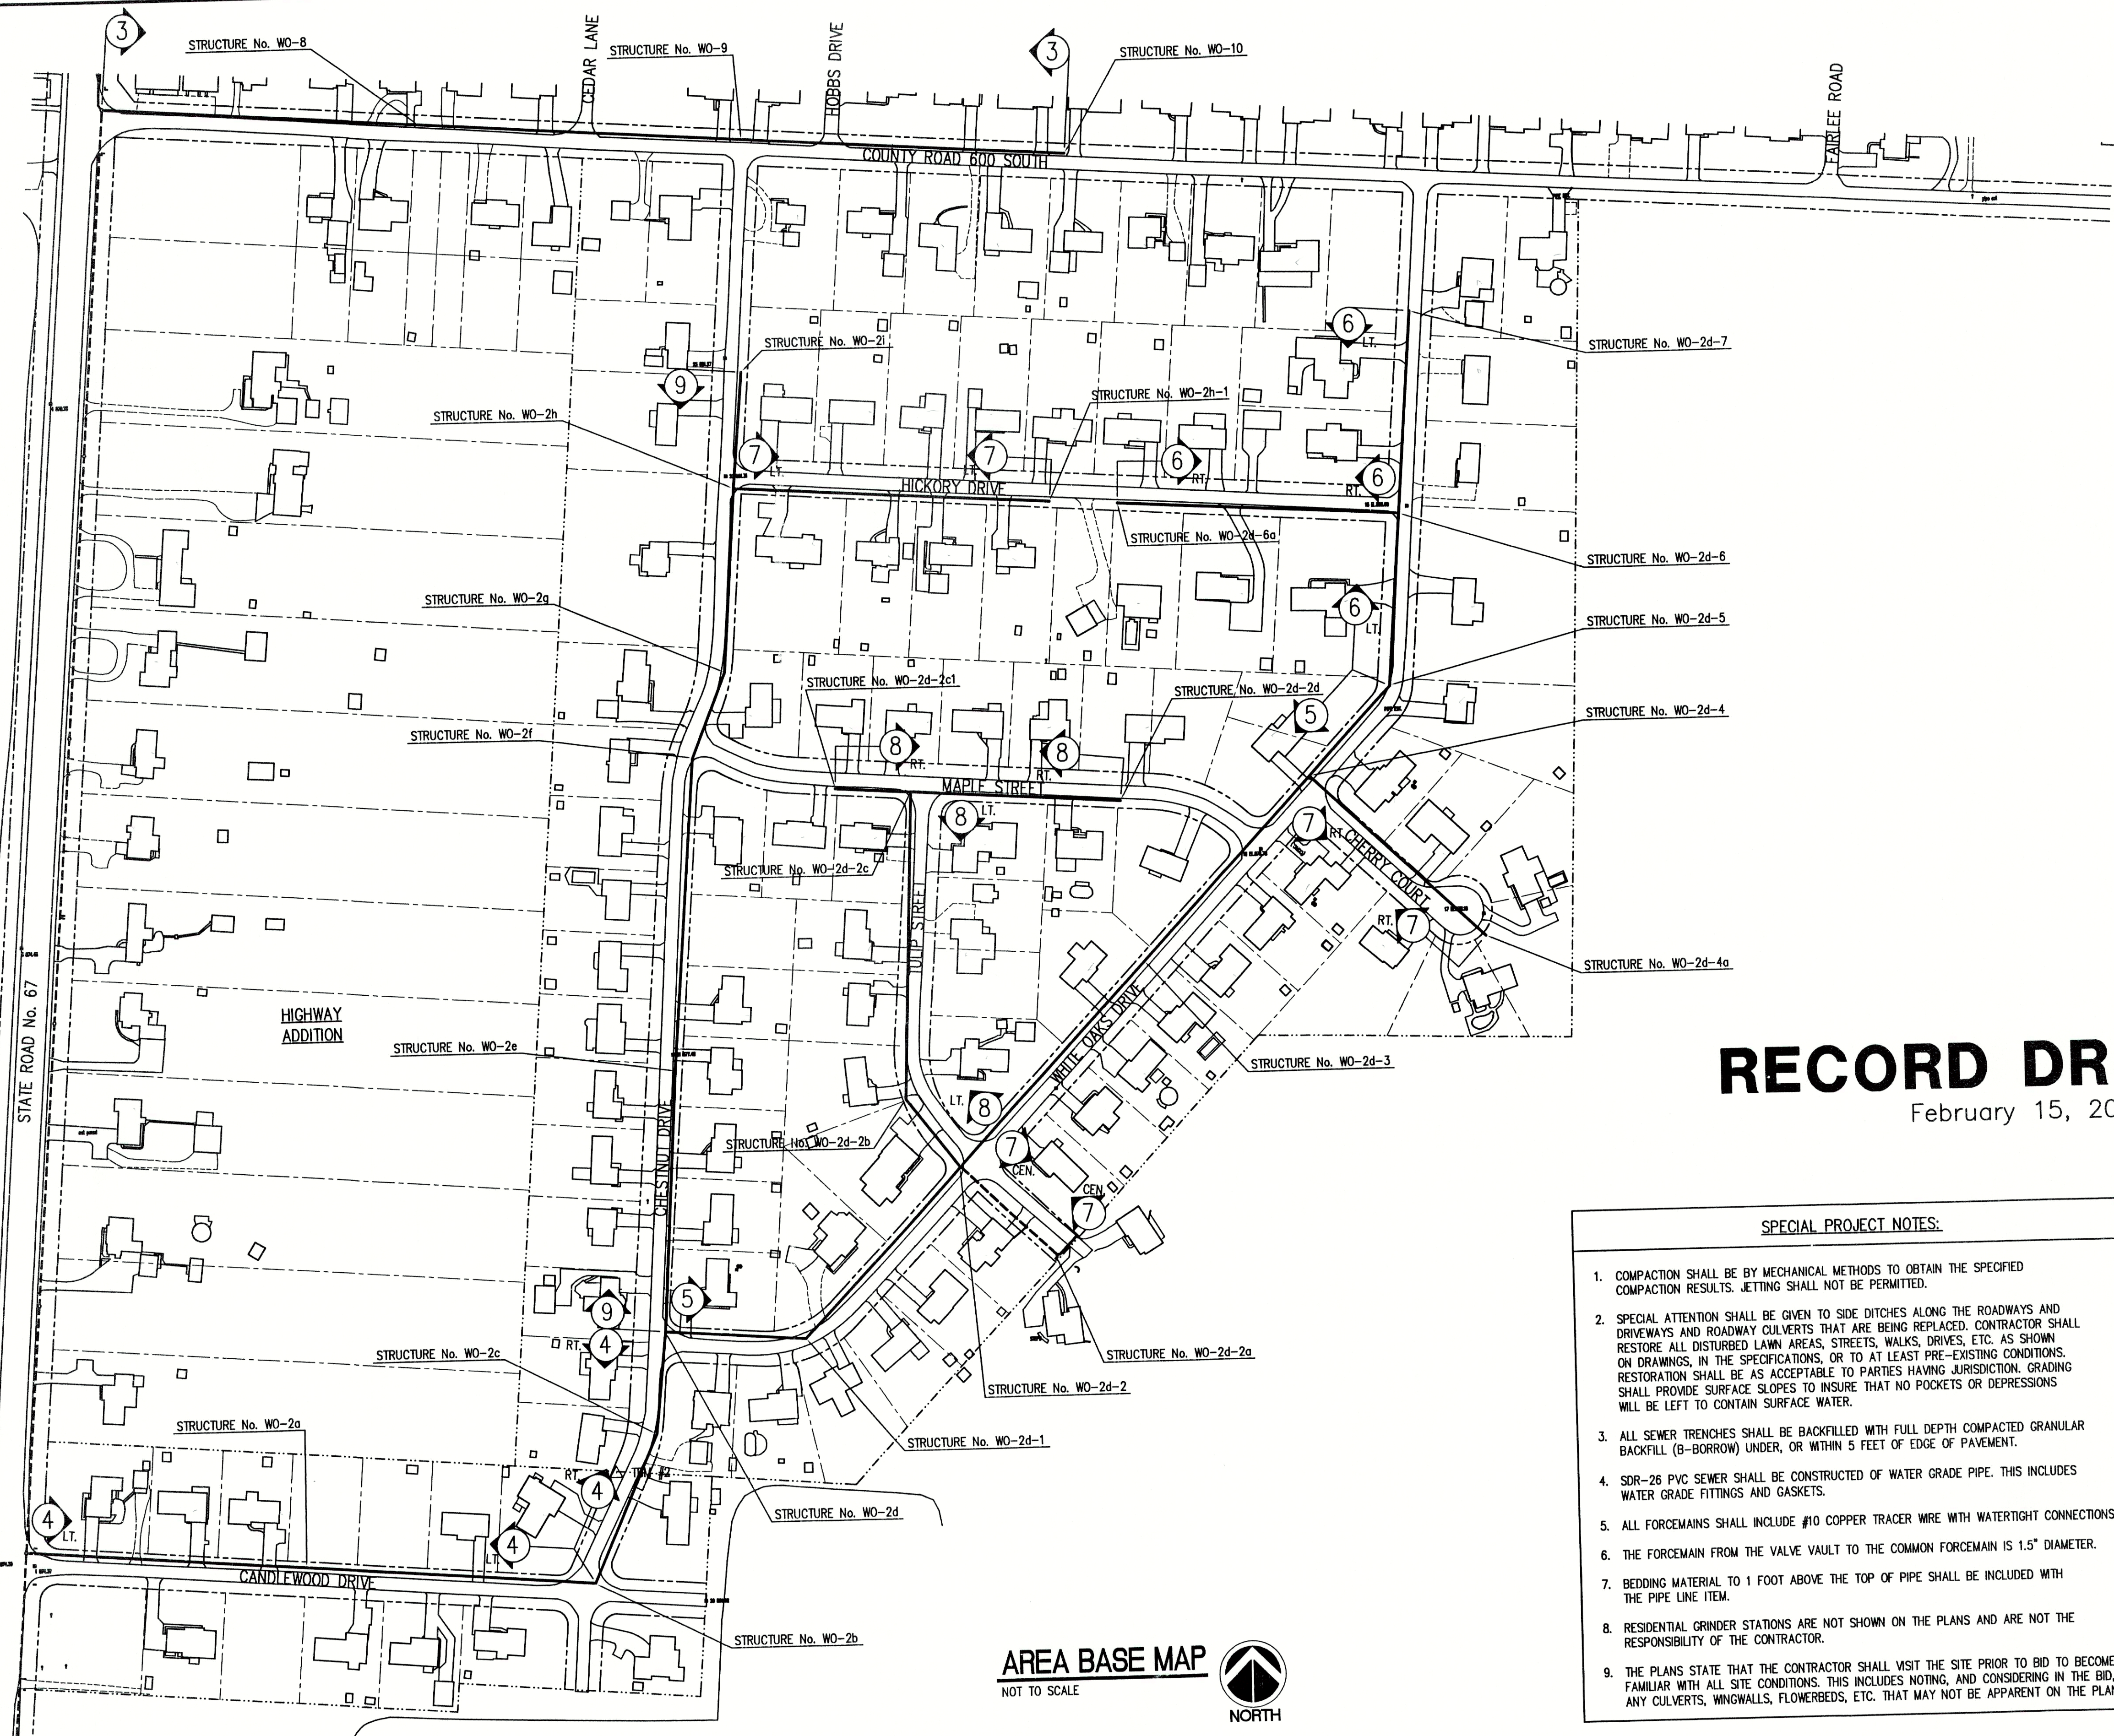

RECORD DRAWING

February 15, 2001

SPECIAL PROJECT NOTES:

1. COMPACTION SHALL BE BY MECHANICAL METHODS TO OBTAIN THE SPECIFIED COMPACTION RESULTS. JETTING SHALL NOT BE PERMITTED.
2. SPECIAL ATTENTION SHALL BE GIVEN TO SIDE DITCHES ALONG THE ROADWAYS AND DRIVEWAYS AND ROADWAY CULVERTS THAT ARE BEING REPLACED. CONTRACTOR SHALL RESTORE ALL DISTURBED LAWN AREAS, STREETS, WALKS, DRIVES, ETC. AS SHOWN ON DRAWINGS, IN THE SPECIFICATIONS, OR TO AT LEAST PRE-EXISTING CONDITIONS. RESTORATION SHALL BE AS ACCEPTABLE TO PARTIES HAVING JURISDICTION. GRADING SHALL PROVIDE SURFACE SLOPES TO INSURE THAT NO POCKETS OR DEPRESSIONS WILL BE LEFT TO CONTAIN SURFACE WATER.
3. ALL SEWER TRENCHES SHALL BE BACKFILLED WITH FULL DEPTH COMPACTED GRANULAR BACKFILL (B-BORROW) UNDER, OR WITHIN 5 FEET OF EDGE OF PAVEMENT.
4. SDR-26 PVC SEWER SHALL BE CONSTRUCTED OF WATER GRADE PIPE. THIS INCLUDES WATER GRADE FITTINGS AND GASKETS.
5. ALL FORCEMAINS SHALL INCLUDE #10 COPPER TRACER WIRE WITH WATERTIGHT CONNECTIONS.
6. THE FORCEMAIN FROM THE VALVE VAULT TO THE COMMON FORCEMAIN IS 1.5" DIAMETER.
7. BEDDING MATERIAL TO 1 FOOT ABOVE THE TOP OF PIPE SHALL BE INCLUDED WITH THE PIPE LINE ITEM.
8. RESIDENTIAL GRINDER STATIONS ARE NOT SHOWN ON THE PLANS AND ARE NOT THE RESPONSIBILITY OF THE CONTRACTOR.
9. THE PLANS STATE THAT THE CONTRACTOR SHALL VISIT THE SITE PRIOR TO BID TO BECOME FAMILIAR WITH ALL SITE CONDITIONS. THIS INCLUDES NOTING, AND CONSIDERING IN THE BID, ANY CULVERTS, WINGWALLS, FLOWERBEDS, ETC. THAT MAY NOT BE APPARENT ON THE PLANS.

AREA BASE MAP
NOT TO SCALE



LEGEND

4 - SHEET DESIGNATION

NOTE:
10" SANITARY SEWER GRAVITY SEWER LINE ALONG
STATE ROAD 67 SHALL BE CONSTRUCTED ALONG WITH
THE WOODED RIDGE ADDITION PROJECT (CONTRACT "A-2")

△ TBM #1 - IN HUNTSVILLE

NO.	DATE	DESCRIPTION	BY

TRIAD ASSOCIATES INC.
INDIANAPOLIS, INDIANA

APPROVED BY:

Thomas M. Schubert, P.E.

WHITE OAKS SUBDIVISION
FALL CREEK REGIONAL WASTE DISTRICT
PROJECT BASE MAP
DRAWN BY: DAP
SCALE: AS NOTED
DESIGNED BY: D.A. Pauling
CHECKED BY: James W. Frazell, P.E.
PROJECT No. 98008A
SHEET No. 2 OF 11

NOTE:
ADDITIONAL RIGHT-OF-WAY OR EASEMENTS MAY
NEED TO BE ACQUIRED FOR INSTALLATION OF SEWER.



DON'T DIG BLIND
CALL BEFORE YOU DIG
1-800-382-5544
1-800-428-5200

PER INDIANA STATE LAW IS-69-1991, IT IS
AGAINST THE LAW TO EXCAVATE WITHOUT
NOTIFYING THE UNDERGROUND LOCATION SERVICE
TWO (2) WORKING DAYS BEFORE COMMENCING WORK.
NOTE: CONTRACTOR TO VERIFY ALL UTILITY LOCATIONS
PRIOR TO THE START OF CONSTRUCTION

GRAVITY SEWER IS PART OF
THE WHITE OAKS ADDITION
CONTRACT "A-1"

STRUCTURE No. WR-OS7
STANDARD MANHOLE
T.C. = 679.34 879.83
INV.(N) = 674.73 871.67
INV.(S) = 674.74 871.66

FOR CONTINUATION
SEE SHEET No. 12

STRUCTURE No. WR-OS6
STANDARD MANHOLE
T.C. = 678.24 878.71
INV.(N) = 670.34 870.32
INV.(S) = 870.29

STRUCTURE No. WR-OS5
STANDARD MANHOLE
T.C. = 674.24 873.67
INV.(N) = 669.47 869.19
INV.(S) = 669.15 869.17

STRUCTURE No. WR-OS4
(SEE SHEET No. 3)

RECORD DRAWING

February 15, 2001

GENERAL NOTES:


- ALL UTILITY LOCATIONS ARE APPROXIMATE. THE CONTRACTOR SHALL HAVE ALL UTILITIES FIELD VERIFIED AND MARKED PRIOR TO CONSTRUCTION.
- CONTRACTOR SHALL MAINTAIN A MINIMUM 10'-0" HORIZONTAL AND 18" VERTICAL SEPARATION BETWEEN SEWER AND WATER MAINS.
- ALL PROPOSED TOP OF CASTING ELEVATIONS ARE APPROXIMATE. THE CONTRACTOR SHALL ADJUST FINAL ELEVATIONS AS REQUIRED TO BE FLUSH WITH PAVEMENT.
- ALL SEWER TRENCHES SHALL BE BACKFILLED WITH FULL DEPTH COMPACTED GRANULAR BACKFILL ("B" BORROW) UNDER OR WITHIN 5' OF EDGE OF PAVEMENT.
- THE CONTRACTOR SHALL VISIT THE SITE PRIOR TO BID TO BECOME FAMILIAR WITH ALL SITE CONDITIONS.
- THE CONTRACTOR SHALL PROVIDE THE REQUIRED MEANS FOR MAINTAINING SAFE TRAFFIC AT ALL TIMES.
- CONTRACTOR SHALL RESTORE ALL DISTURBED LAWN AREAS, STREETS, WALKS, DRIVES, ETC. AS SHOWN ON DRAWINGS, IN THE SPECIFICATIONS, OR TO AT LEAST PRE-EXISTING CONDITIONS.
- ALL UTILITY CROSSINGS SHALL BE PROTECTED AND SUPPORTED WITH GRANULAR FILL OR CONCRETE AS REQUIRED PER THE DETAIL SHEET.

LEGEND:

- TREE
- POWER POLE
- GUY WIRE
- FIRE HYDRANT
- MAILBOX
- FLAGPOLE
- SPOT SHOT
- CONTOUR
- FENCE
- EXIST. SANITARY SEWER w/ MANHOLE
- EXISTING WATER WELL
- EXISTING SEPTIC TANK
- NEW SANITARY SEWER w/ MANHOLE
- NEW SANITARY SERVICE CONNECTION
- 4" W WATER LINE
- 2" G GAS LINE
- UNDERGROUND ELECTRIC LINE
- UNDERGROUND TELEPHONE LINE
- APPROX. RIGHT-OF-WAY
- APPROX. CORPORATE LIMITS
- APPROX. PROPERTY LINE



SCALE:
HORIZONTAL 1" = 50'
VERTICAL 1" = 5'

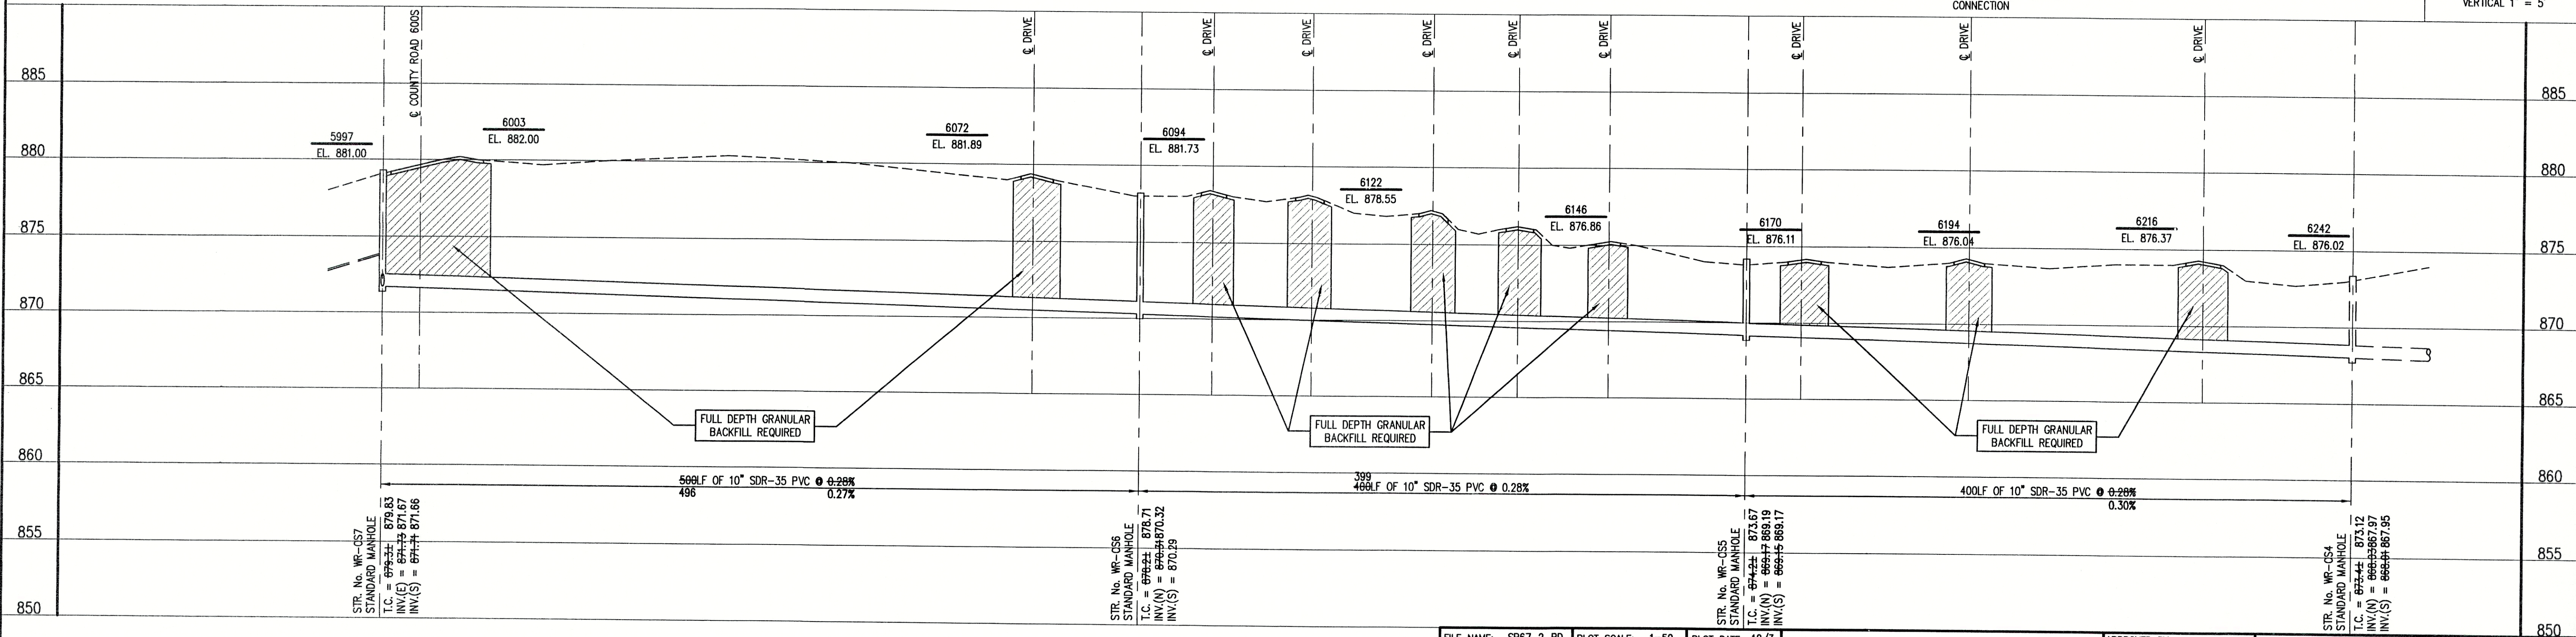

NOTE:


THE CONTRACTOR SHALL INCLUDE IN THE COSTS FOR SANITARY PIPE, ALL WATER SERVICE RECONNECTIONS, STORM SEWER RECONNECTION, WATER MAIN RELOCATIONS, CONCRETE RECONSTRUCTION, AND SIDEWALK RECONSTRUCTION AS REQUIRED TO INSTALL NEW WORK AS SHOWN ON THE DRAWINGS.

NO.	DATE	DESCRIPTION	BY

TRIAD ASSOCIATES INC.
INDIANAPOLIS, INDIANA

APPROVED BY:
THOMAS M. SCHUBERT
No. 15614
STATE OF INDIANA
PROFESSIONAL ENGINEER

WOODED RIDGE SUBDIVISION
FALL CREEK REGIONAL WASTE DISTRICT
PLAN AND PROFILE
DRAWN BY: DAP
DATE: 04/12/98
SCALE: AS NOTED
PROJECT No.: 98008A
SHEET No.: 4
DESIGNED BY: D.A. Paullin
CHECKED BY: James W. Frazell, P.E.

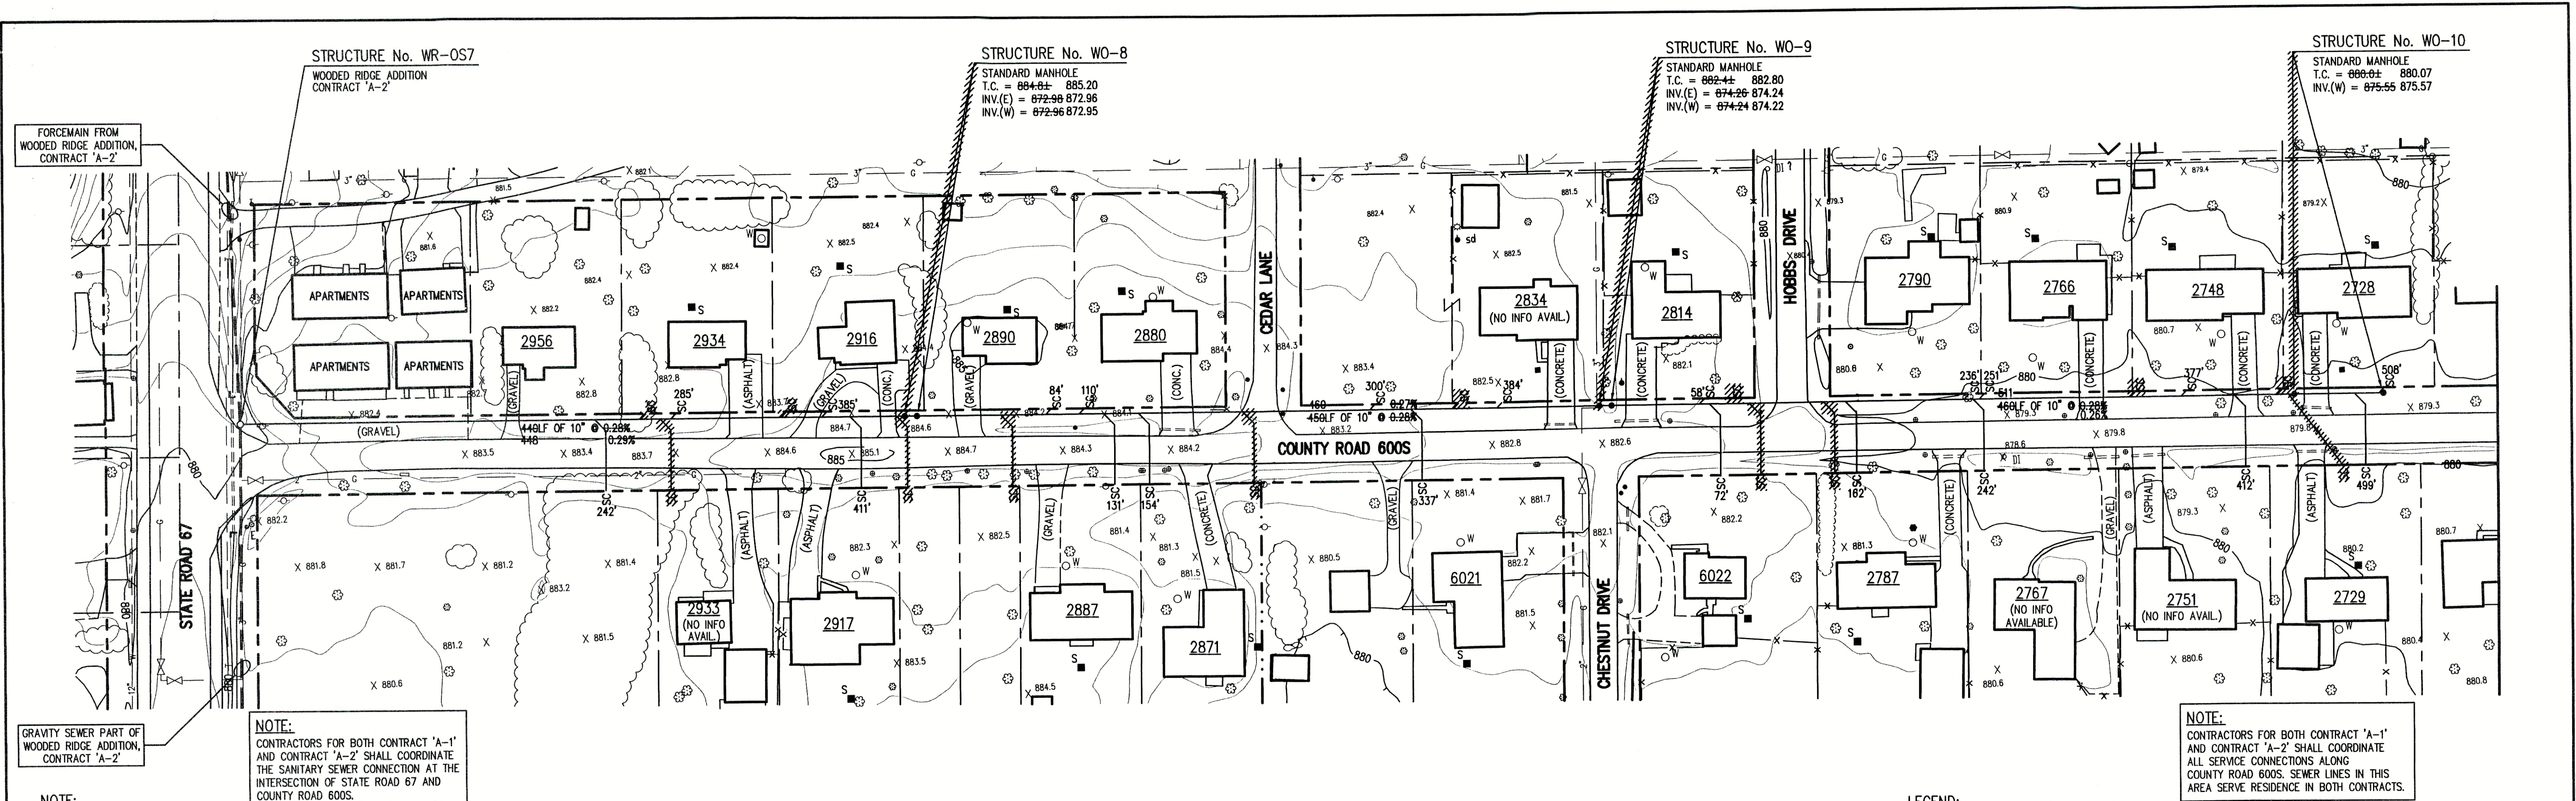

NOTE:
ADDITIONAL RIGHT-OF-WAY OR EASEMENTS MAY
NEED TO BE ACQUIRED FOR INSTALLATION OF SEWER.

NOTE:
CONTRACTORS FOR BOTH CONTRACT 'A-1'
AND CONTRACT 'A-2' SHALL COORDINATE
THE SANITARY SEWER CONNECTION AT THE
INTERSECTION OF STATE ROAD 67 AND
COUNTY ROAD 600S.


GENERAL NOTES:

- ALL UTILITY LOCATIONS ARE APPROXIMATE. THE CONTRACTOR SHALL HAVE ALL UTILITIES FIELD VERIFIED AND MARKED PRIOR TO CONSTRUCTION.
- CONTRACTOR SHALL MAINTAIN A MINIMUM 10'-0" HORIZONTAL AND 18" VERTICAL SEPARATION BETWEEN SEWER AND WATER MAINS.
- ALL PROPOSED TOP OF CASTING ELEVATIONS ARE APPROXIMATE. THE CONTRACTOR SHALL ADJUST FINAL ELEVATIONS AS REQUIRED TO BE FLUSH WITH PAVEMENT.
- ALL SEWER TRENCHES SHALL BE BACKFILLED WITH FULL DEPTH COMPACTED GRANULAR BACKFILL ("B" BORROW) UNDER OR WITHIN 5' OF EDGE OF PAVEMENT.
- THE CONTRACTOR SHALL VISIT THE SITE PRIOR TO BID TO BECOME FAMILIAR WITH ALL SITE CONDITIONS.
- THE CONTRACTOR SHALL PROVIDE THE REQUIRED MEANS FOR MAINTAINING SAFE TRAFFIC AT ALL TIMES.
- CONTRACTOR SHALL RESTORE ALL DISTURBED LAWN AREAS, STREETS, WALKS, DRIVES, ETC. AS SHOWN ON DRAWINGS, IN THE SPECIFICATIONS, OR TO AT LEAST PRE-EXISTING CONDITIONS.
- ALL UTILITY CROSSINGS SHALL BE PROTECTED AND SUPPORTED WITH GRANULAR FILL OR CONCRETE AS REQUIRED PER THE DETAIL SHEET.

LEGEND:

- TREE
- POWER POLE
- GUY WIRE
- FIRE HYDRANT
- MAILBOX
- FLAGPOLE
- SPOT SHOT
- CONTOUR
- FENCE
- EXIST. SANITARY SEWER w/ MANHOLE
- NEW SANITARY SEWER w/ MANHOLE
- NEW SANITARY SERVICE CONNECTION
- WATER LINE
- GAS LINE
- UNDERGROUND ELECTRIC LINE
- UNDERGROUND TELEPHONE LINE
- APPROX. RIGHT-OF-WAY
- APPROX. CORPORATE LIMITS
- APPROX. PROPERTY LINE
- EXISTING WATER WELL
- EXISTING SEPTIC TANK

SCALE:
HORIZONTAL 1" = 50'
VERTICAL 1" = 5'

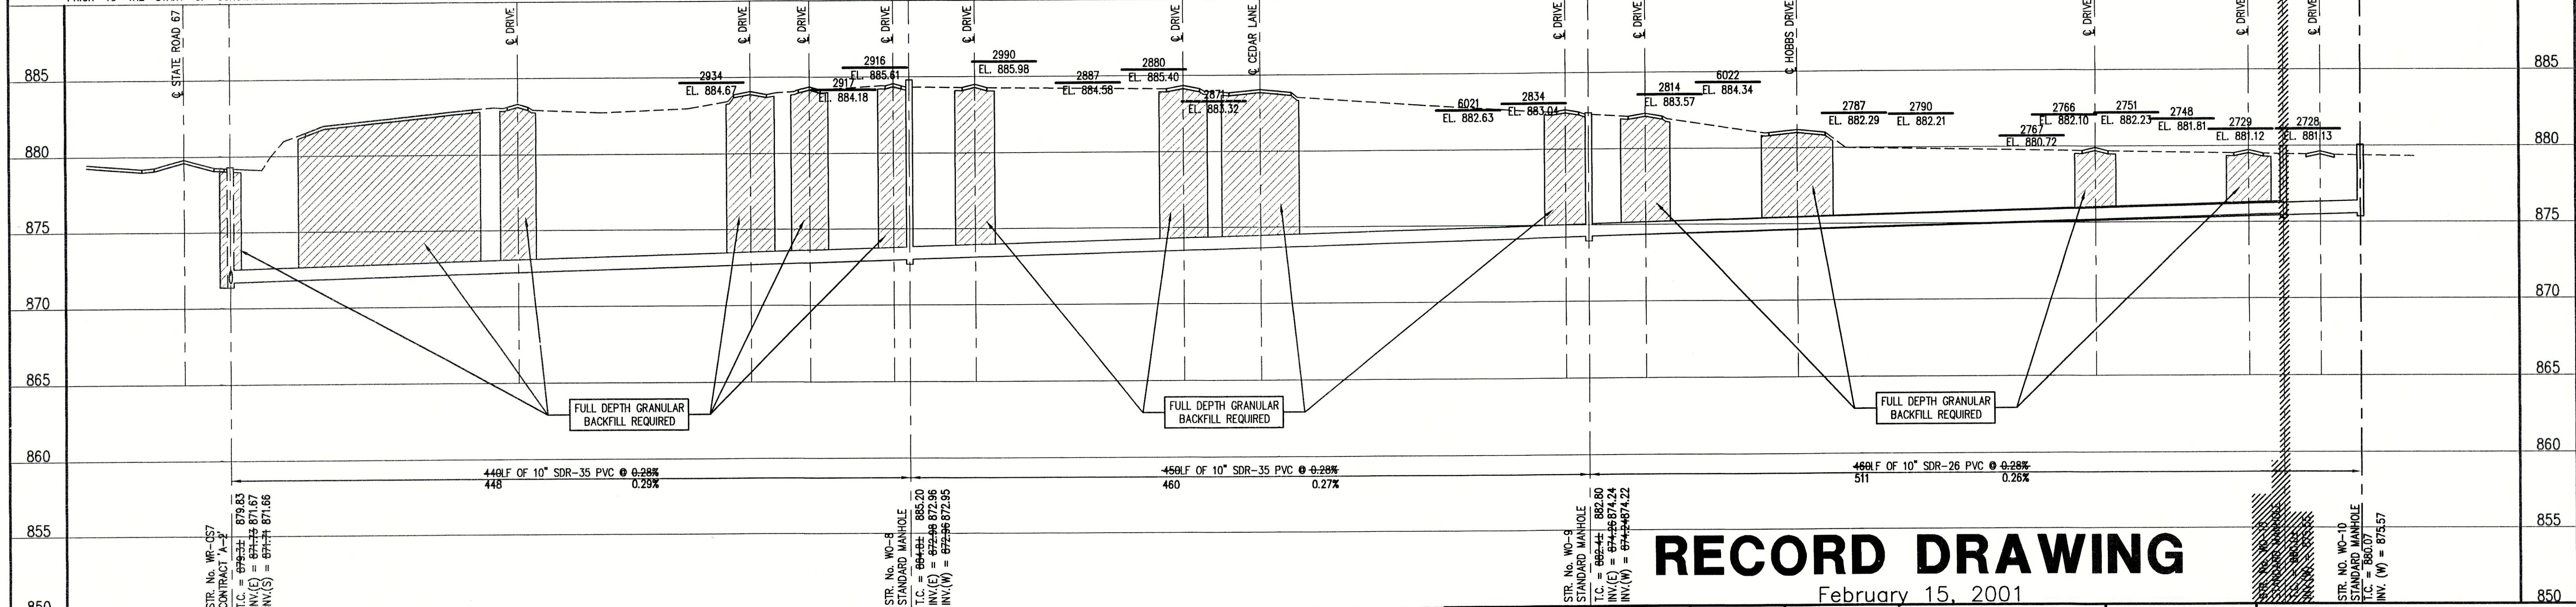

RECORD DRAWING
February 15, 2001

FILE NAME: WHOK_8-RD PLOT SCALE: 1=50 PLOT DATE: 12/3

NO. DATE DESCRIPTION BY

TRIAD ASSOCIATES INC.
INDIANAPOLIS, INDIANA

APPROVED BY: Thomas M. Schubert, P.E.

WHITE OAKS SUBDIVISION
FALL CREEK REGIONAL WASTE DISTRICT


PLAN AND PROFILE

DRAWN BY: DAP DATE: 04/12/98 PROJECT No. 98008A SHEET No. 3 OF 11

DESIGNED BY: D.A. Pauling

CHECKED BY: James W. Frazell, P.E.

NOTE:
THE CONTRACTOR SHALL INCLUDE IN THE COSTS FOR SANITARY PIPE,
ALL WATER SERVICE RECONNECTIONS, STORM SEWER RECONNECTION,
WATER MAIN RELOCATIONS, CONCRETE RECONSTRUCTION, AND
SIDEWALK RECONSTRUCTION AS REQUIRED TO INSTALL NEW WORK
AS SHOWN ON THE DRAWINGS.


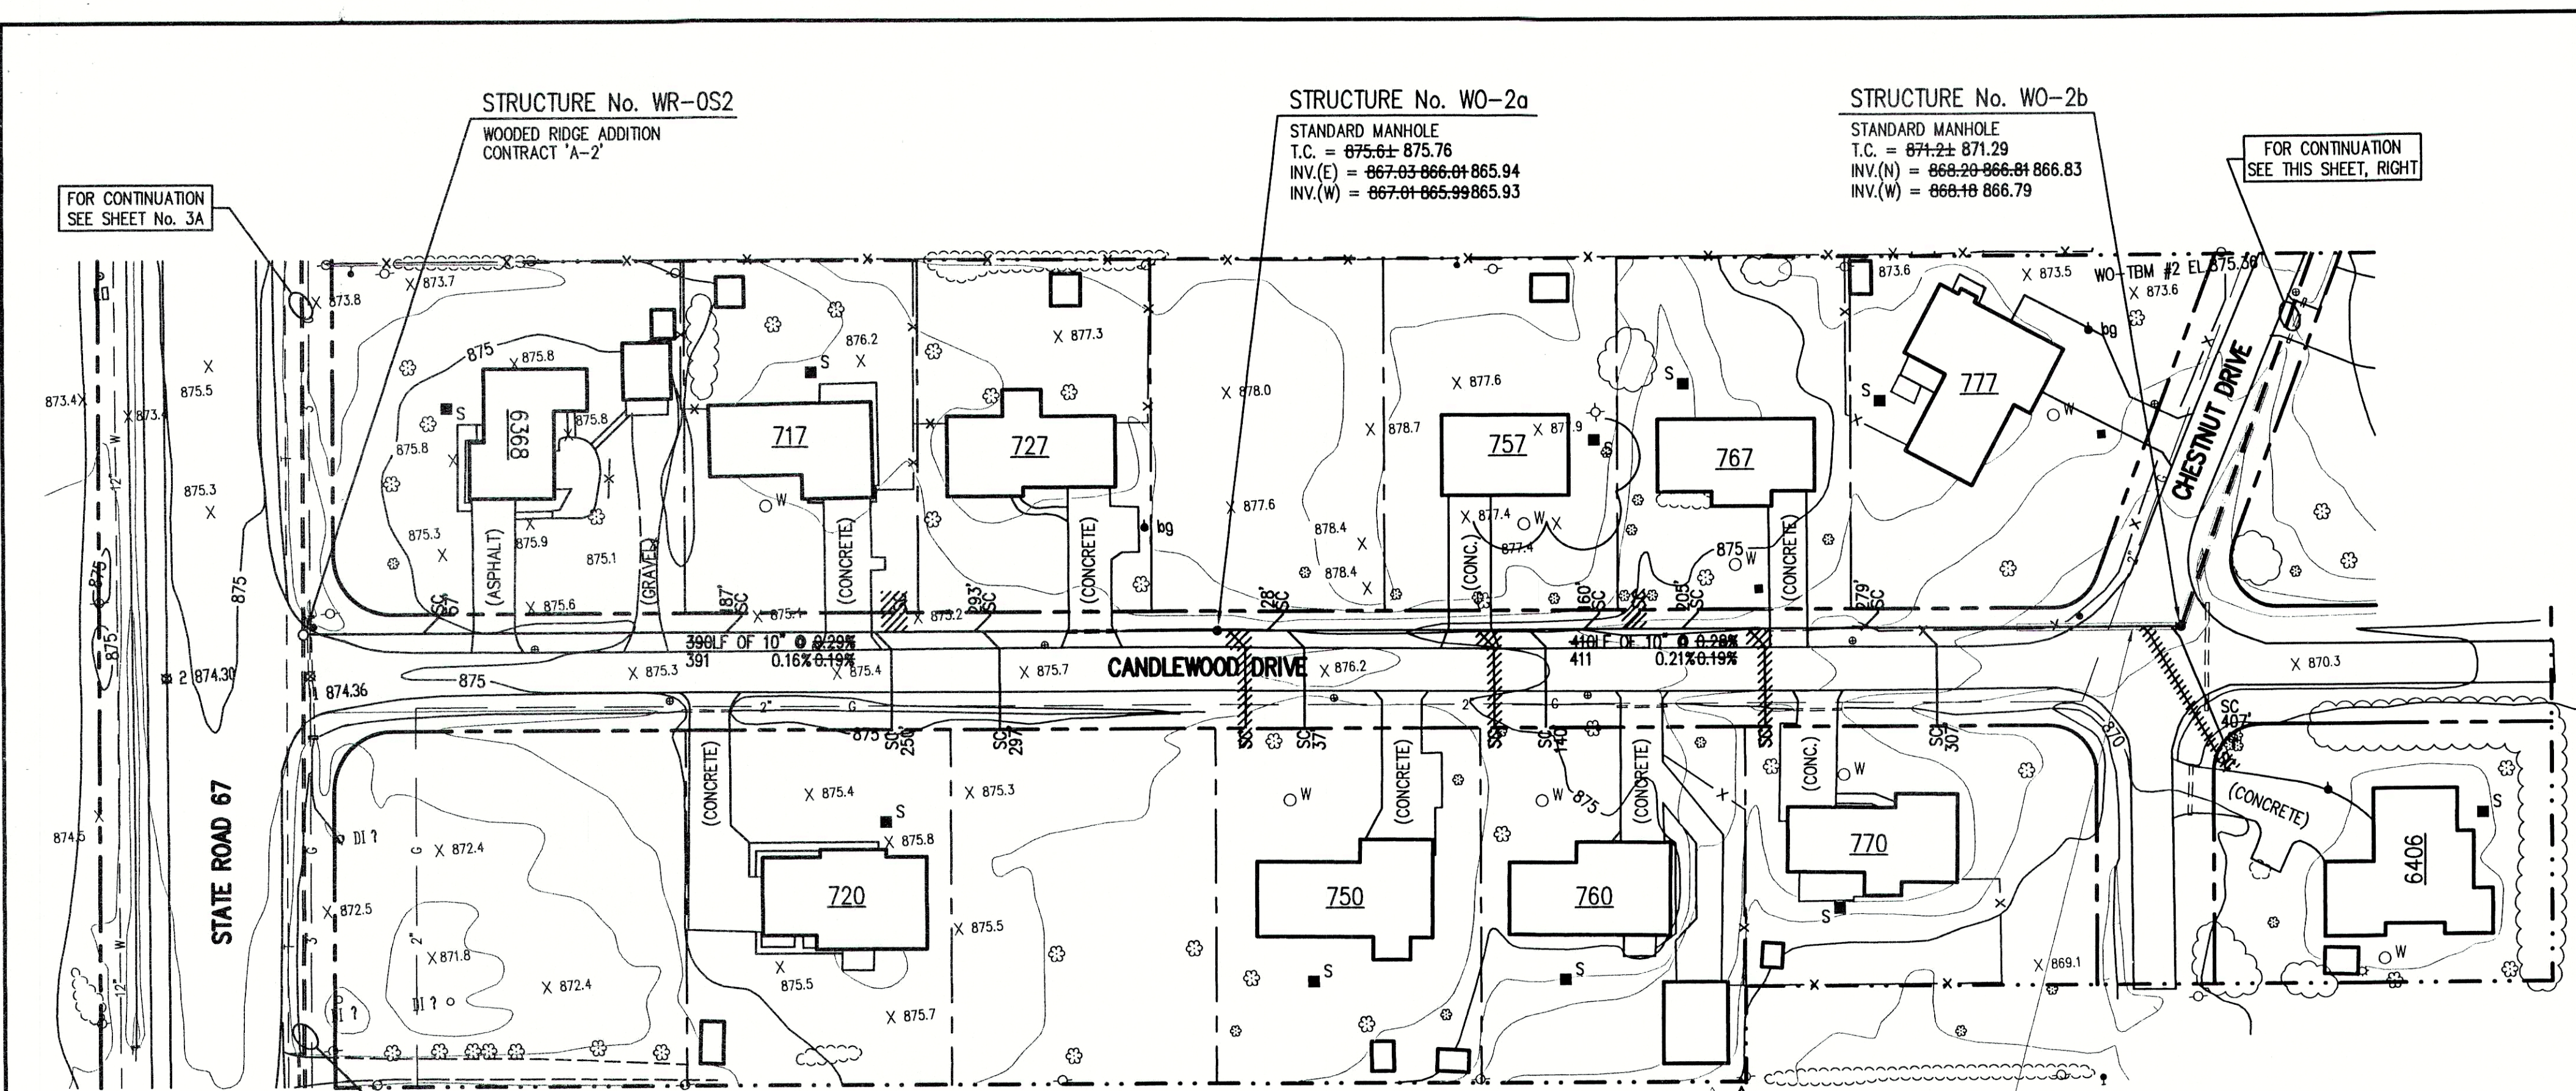


NOTE:
ADDITIONAL RIGHT-OF-WAY OR EASEMENTS MAY
NEED TO BE ACQUIRED FOR INSTALLATION OF SEWER.

NOTE:
CONTRACTORS FOR BOTH CONTRACT 'A-1'
AND CONTRACT 'A-2' SHALL COORDINATE
THE SANITARY SEWER CONNECTION AT THE
INTERSECTION OF STATE ROAD 67 AND
CANDLEWOOD DRIVE.

GENERAL NOTES:


- ALL UTILITY LOCATIONS ARE APPROXIMATE. THE CONTRACTOR SHALL HAVE ALL UTILITIES FIELD VERIFIED AND MARKED PRIOR TO CONSTRUCTION.
- CONTRACTOR SHALL MAINTAIN A MINIMUM 10'-0" HORIZONTAL AND 18" VERTICAL SEPARATION BETWEEN SEWER AND WATER MAINS.
- ALL PROPOSED TOP OF CASTING ELEVATIONS ARE APPROXIMATE. THE CONTRACTOR SHALL ADJUST FINAL ELEVATIONS AS REQUIRED TO BE FLUSH WITH PAVEMENT.
- ALL SEWER TRENCHES SHALL BE BACKFILLED WITH FULL DEPTH COMPACTED GRANULAR BACKFILL ("B" BORROW) UNDER OR WITHIN 5' OF EDGE OF PAVEMENT.
- THE CONTRACTOR SHALL VISIT THE SITE PRIOR TO BID TO BECOME FAMILIAR WITH ALL SITE CONDITIONS.
- THE CONTRACTOR SHALL PROVIDE THE REQUIRED MEANS FOR MAINTAINING SAFE TRAFFIC AT ALL TIMES.
- CONTRACTOR SHALL RESTORE ALL DISTURBED LAWN AREAS, STREETS, WALKS, DRIVES, ETC. AS SHOWN ON DRAWINGS, IN THE SPECIFICATIONS, OR TO AT LEAST PRE-EXISTING CONDITIONS.
- ALL UTILITY CROSSINGS SHALL BE PROTECTED AND SUPPORTED WITH GRANULAR FILL OR CONCRETE AS REQUIRED PER THE DETAIL SHEET.

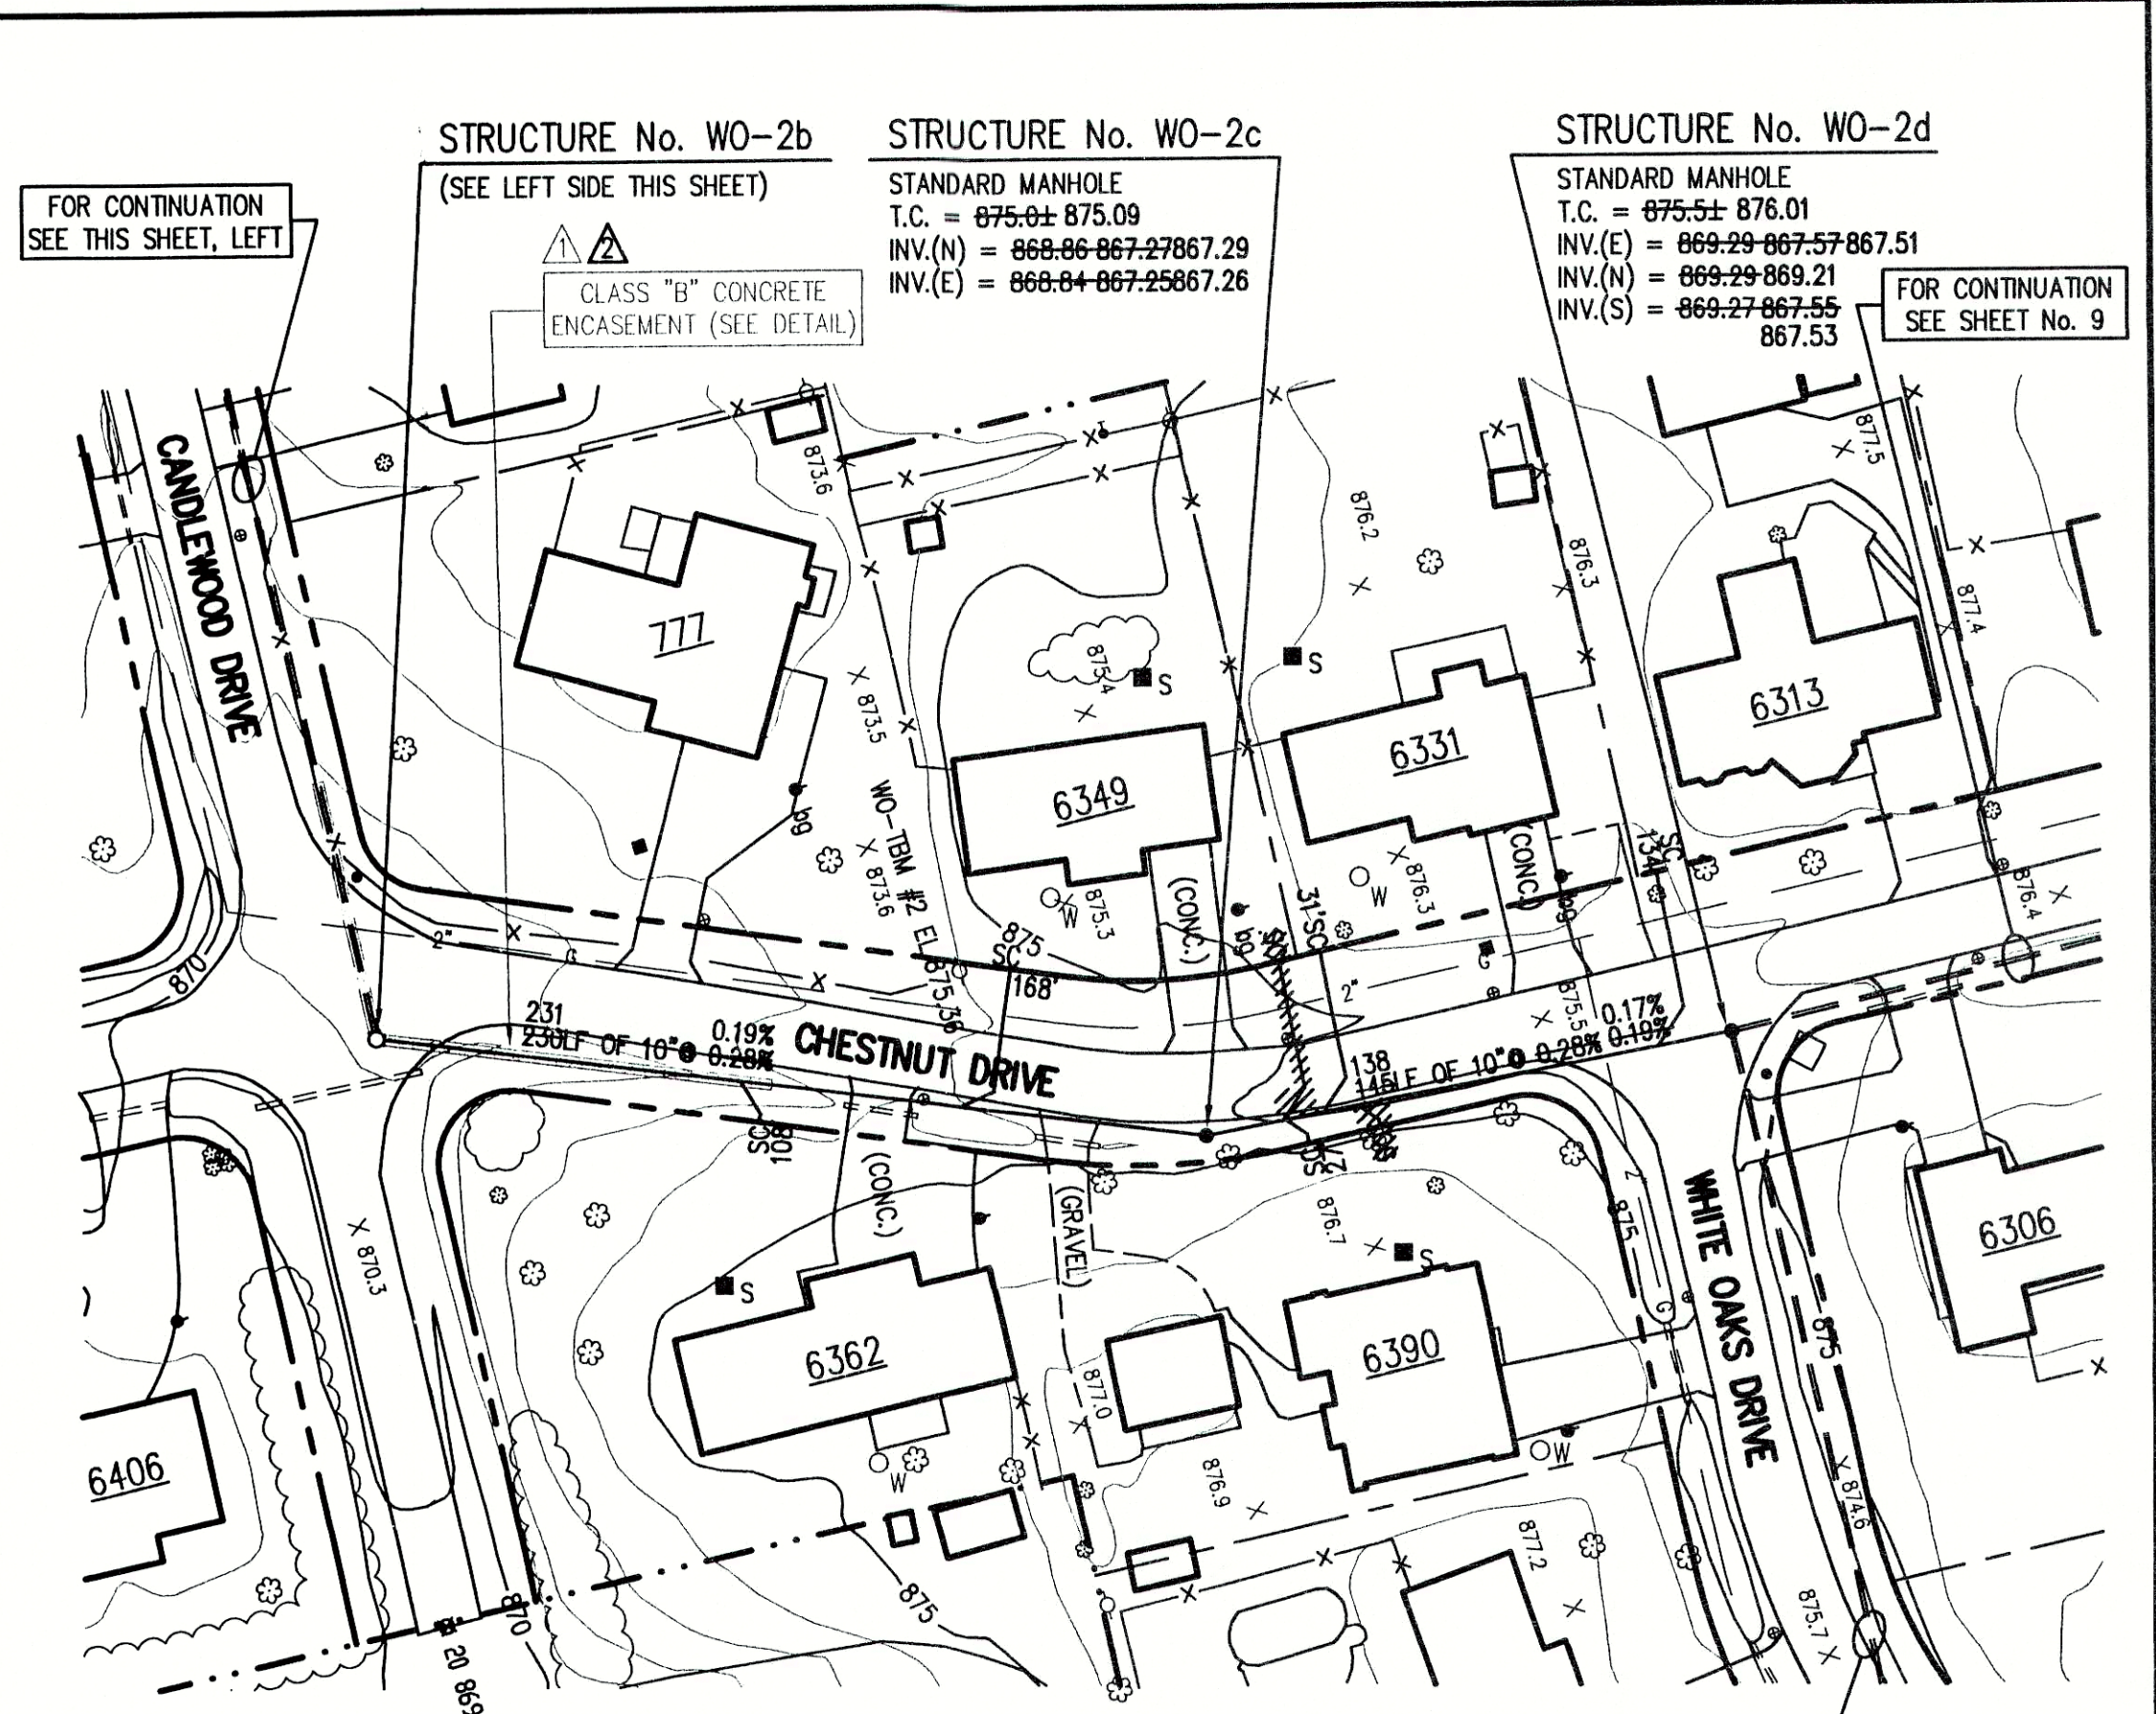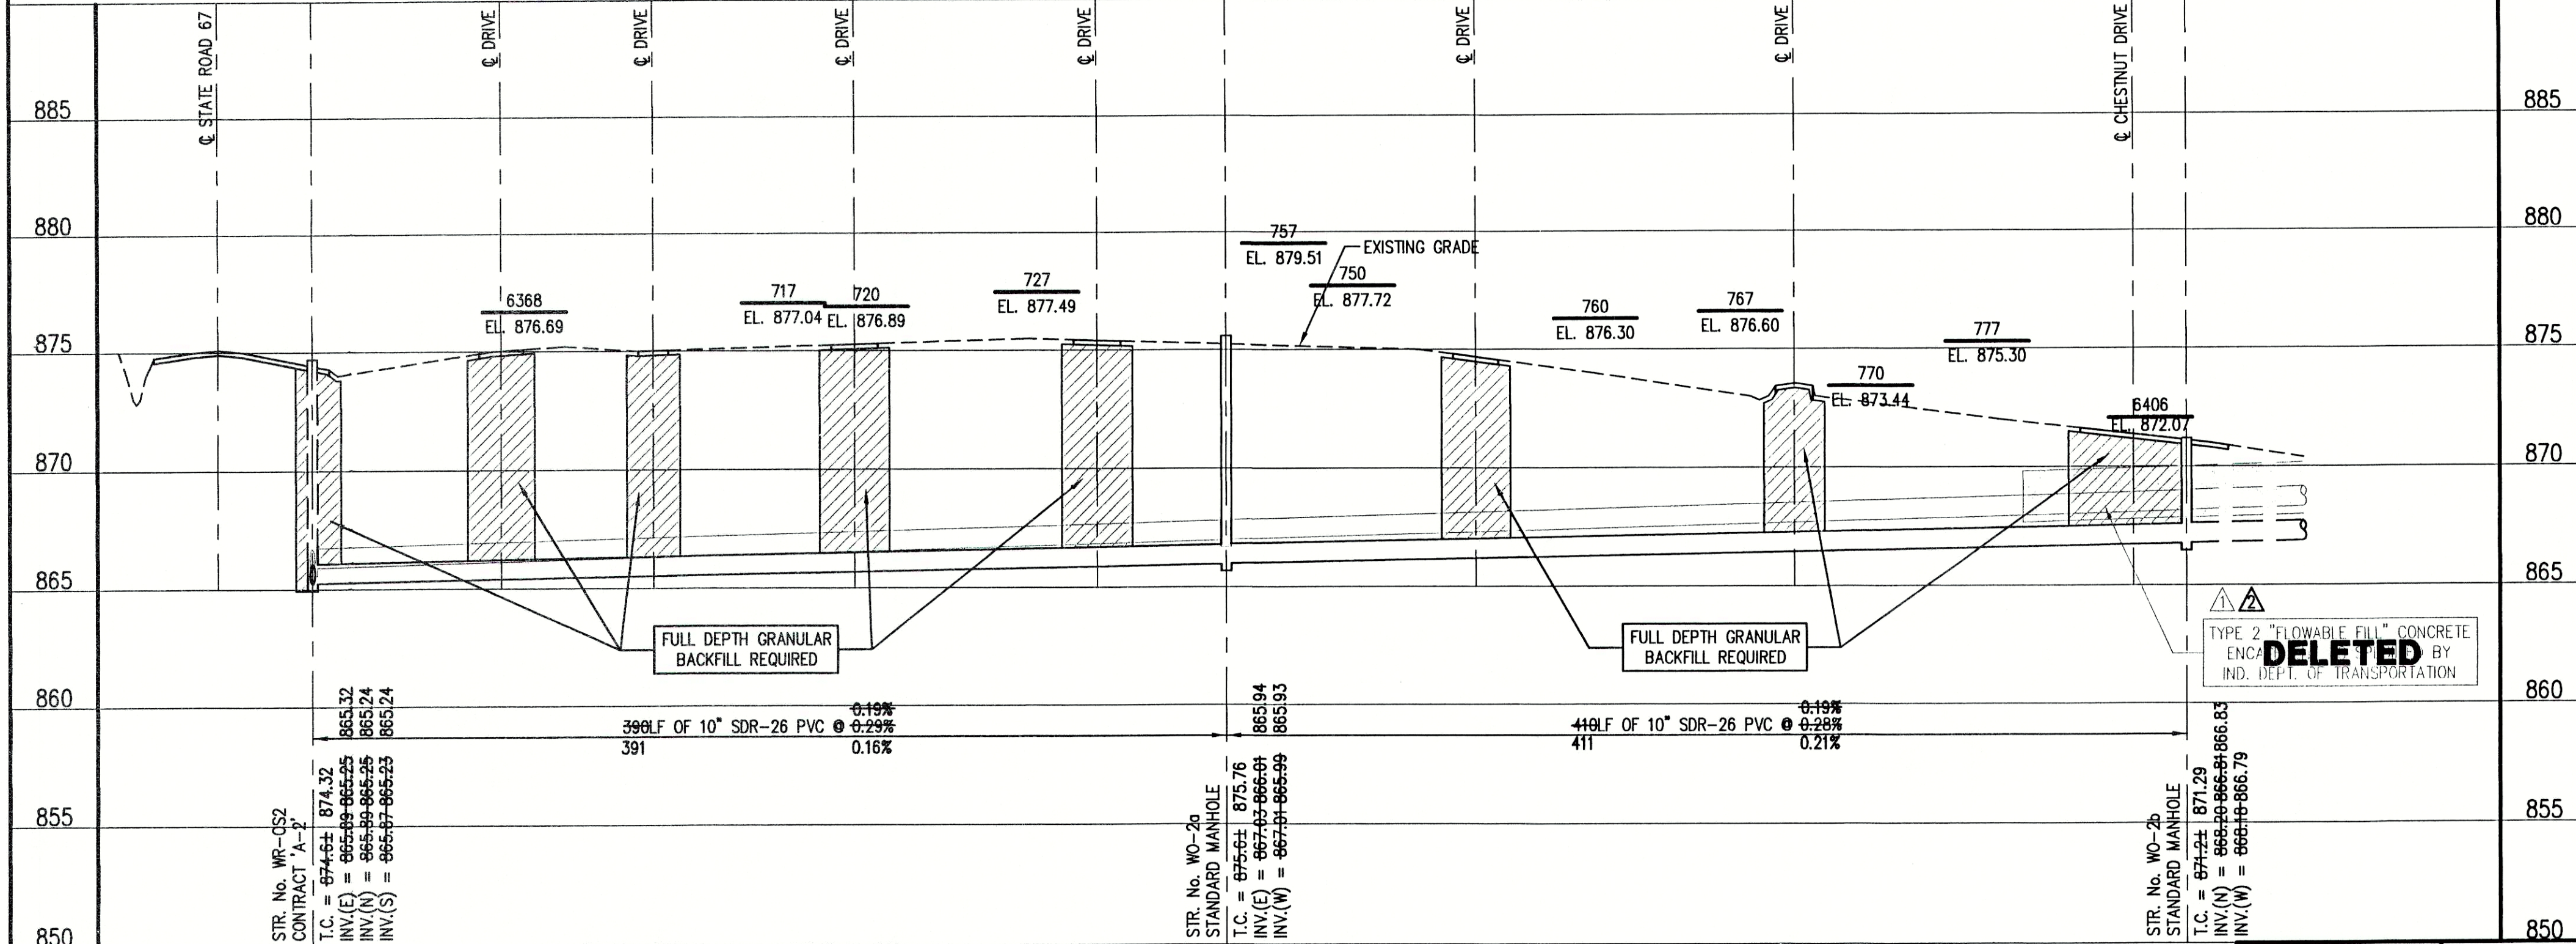

LEGEND:

- TREE
- POWER POLE
- GUY WIRE
- FIRE HYDRANT
- MAILBOX
- FLAGPOLE
- SPOT SHOT
- CONTOUR
- FENCE
- EXIST. SANITARY SEWER w/ MANHOLE
- NEW SANITARY SEWER w/ MANHOLE
- NEW SANITARY SERVICE CONNECTION
- WATER LINE
- GAS LINE
- UNDERGROUND ELECTRIC LINE
- UNDERGROUND TELEPHONE LINE
- APPROX. RIGHT-OF-WAY
- APPROX. CORPORATE LIMITS
- APPROX. PROPERTY LINE
- EXISTING WATER WELL
- EXISTING SEPTIC TANK

SCALE:
HORIZONTAL 1" = 50'
VERTICAL 1" = 5'

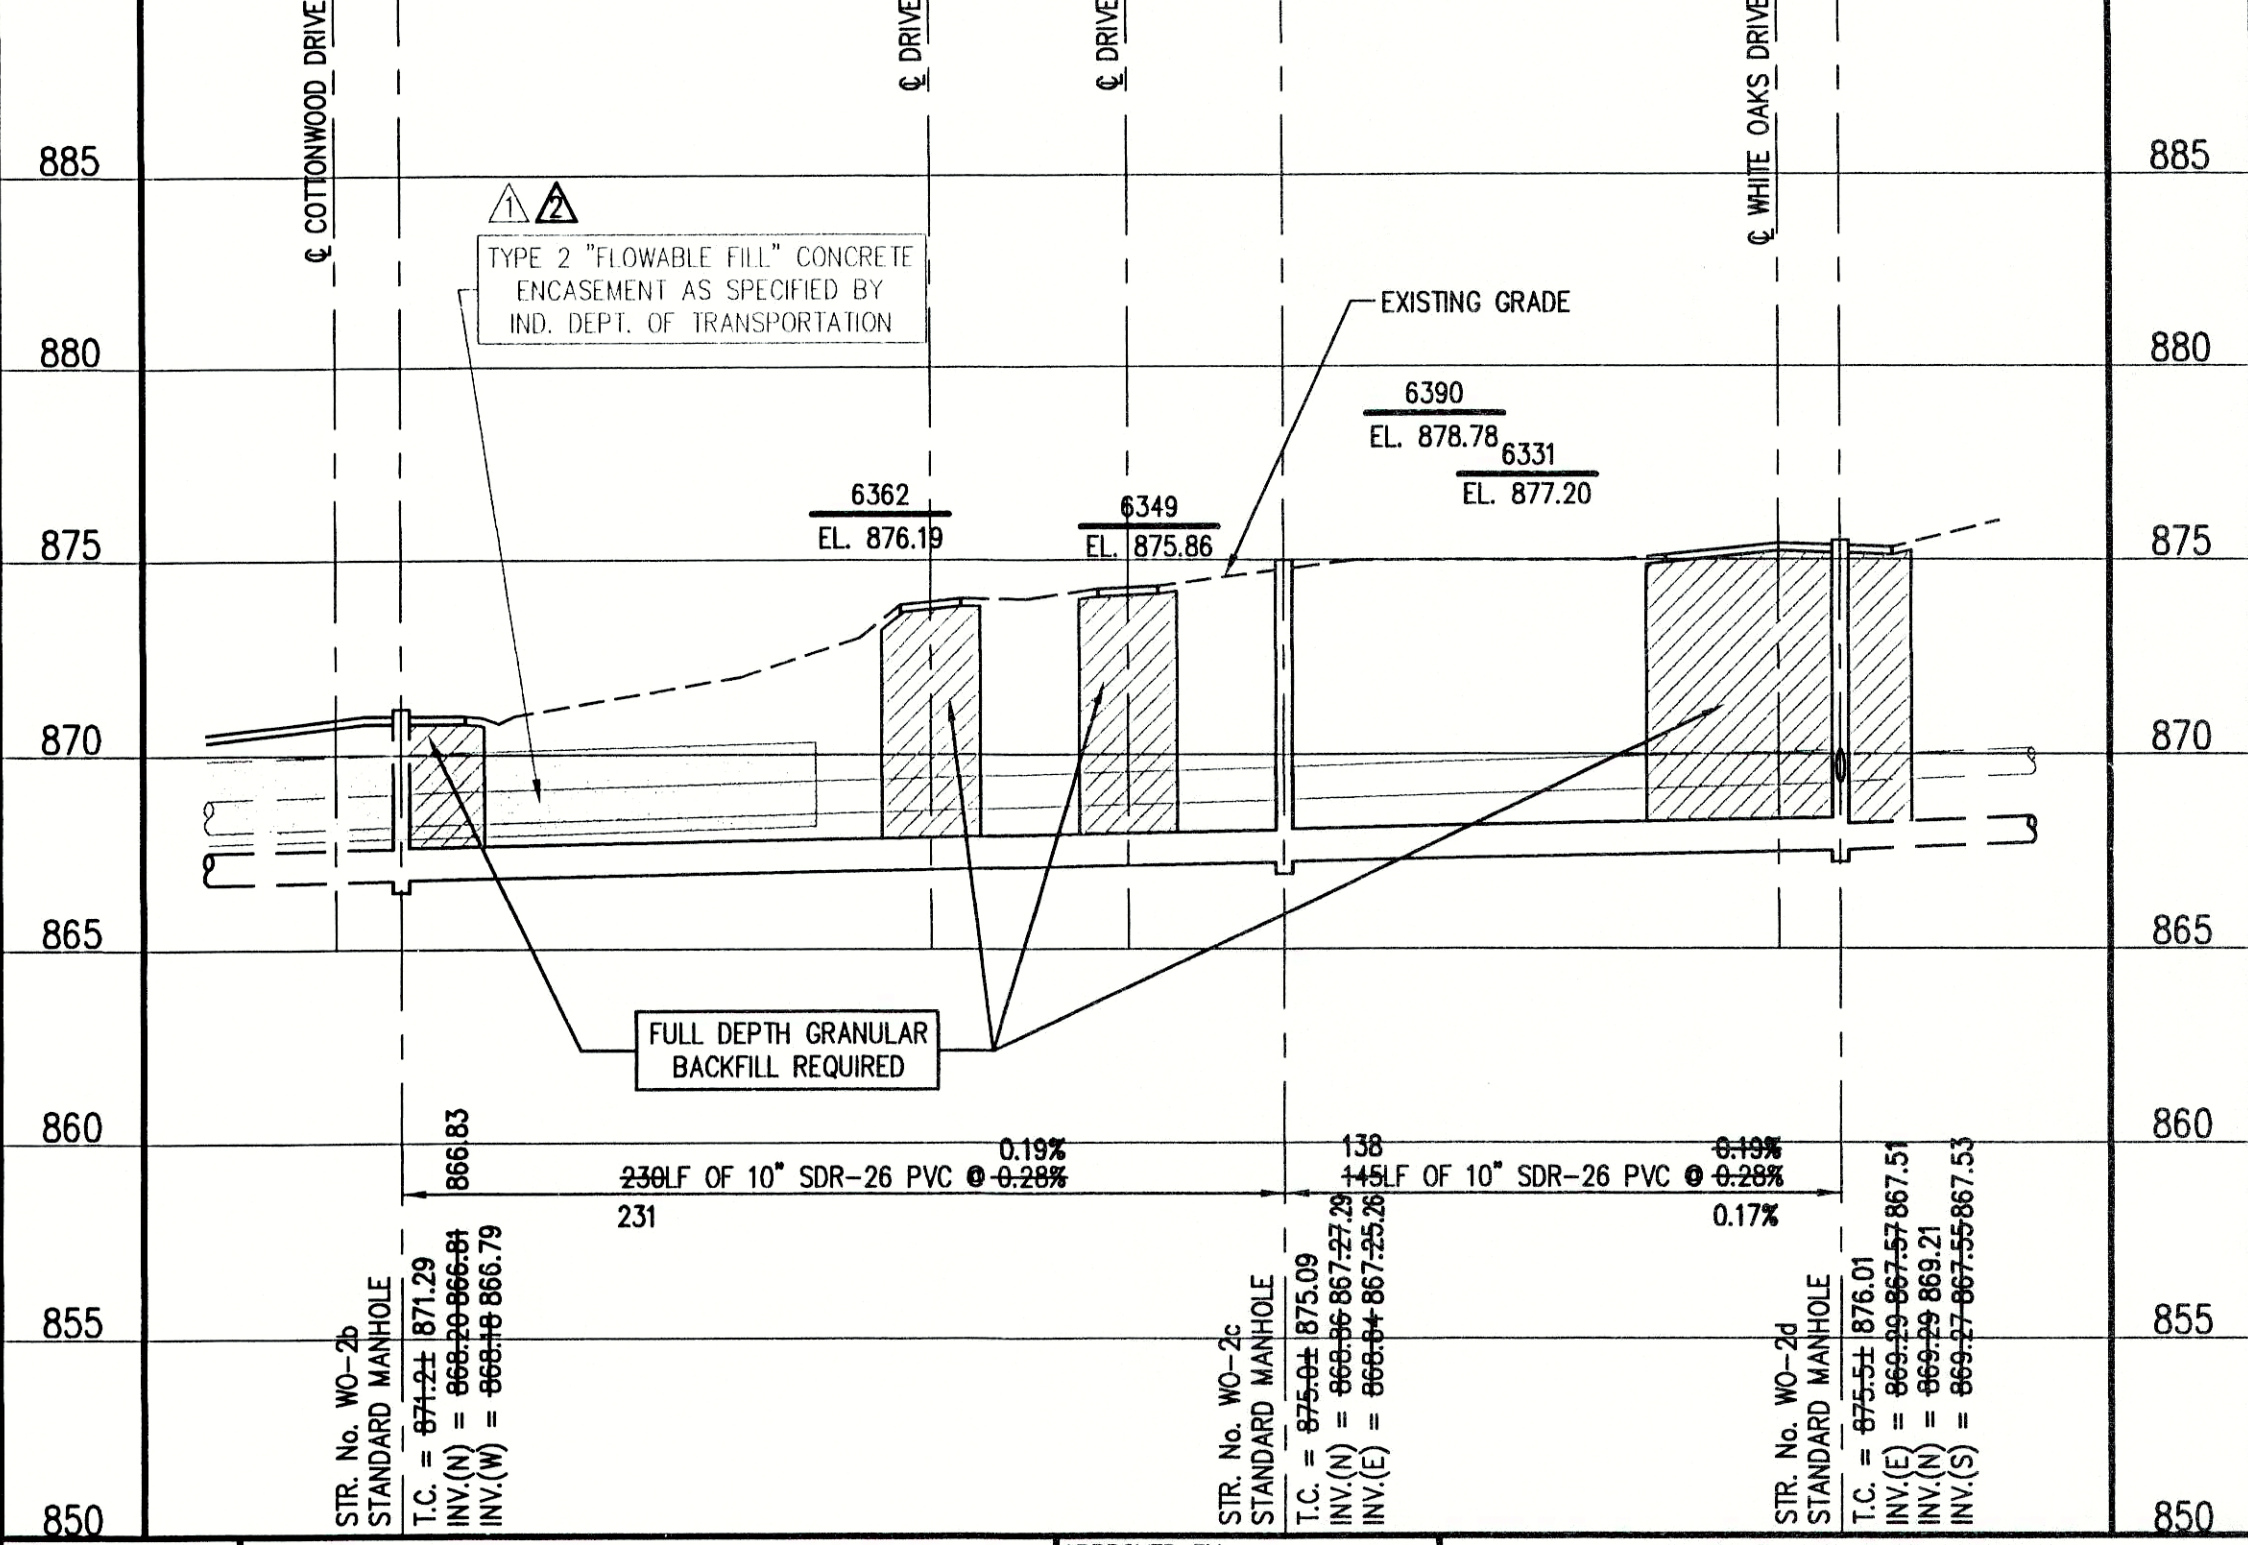

RECORD DRAWING

February 15, 2001

NOTE:
THE CONTRACTOR SHALL INCLUDE IN THE COSTS FOR SANITARY PIPE,
ALL WATER SERVICE RECONNECTIONS, STORM SEWER RECONNECTION,
WATER MAIN RELOCATIONS, CONCRETE RECONSTRUCTION, AND
SIDEWALK RECONSTRUCTION AS REQUIRED TO INSTALL NEW WORK
AS SHOWN ON THE DRAWINGS.


NO.	DATE	DESCRIPTION	BY
1	12/29/99	ADDED CONCRETE ENCASUREMENT	D.A.P.
2	07/25/00	REMOVED CONCRETE ENCASUREMENT	D.A.P.

TRIAD ASSOCIATES INC.
INDIANAPOLIS, INDIANA

APPROVED BY
THOMAS M. SCHUBERT, P.E.
15614
PROFESSIONAL ENGINEER

WHITE OAKS SUBDIVISION
FALL CREEK REGIONAL WASTE DISTRICT
PLAN AND PROFILE
DRAWN BY: DATE 04/12/98 PROJECT No. SHEET No.
DAP SCALE AS NOTED 98008A 4
DESIGNED BY: D.A. Pauling
CHECKED BY: James W. Frazell, P.E.



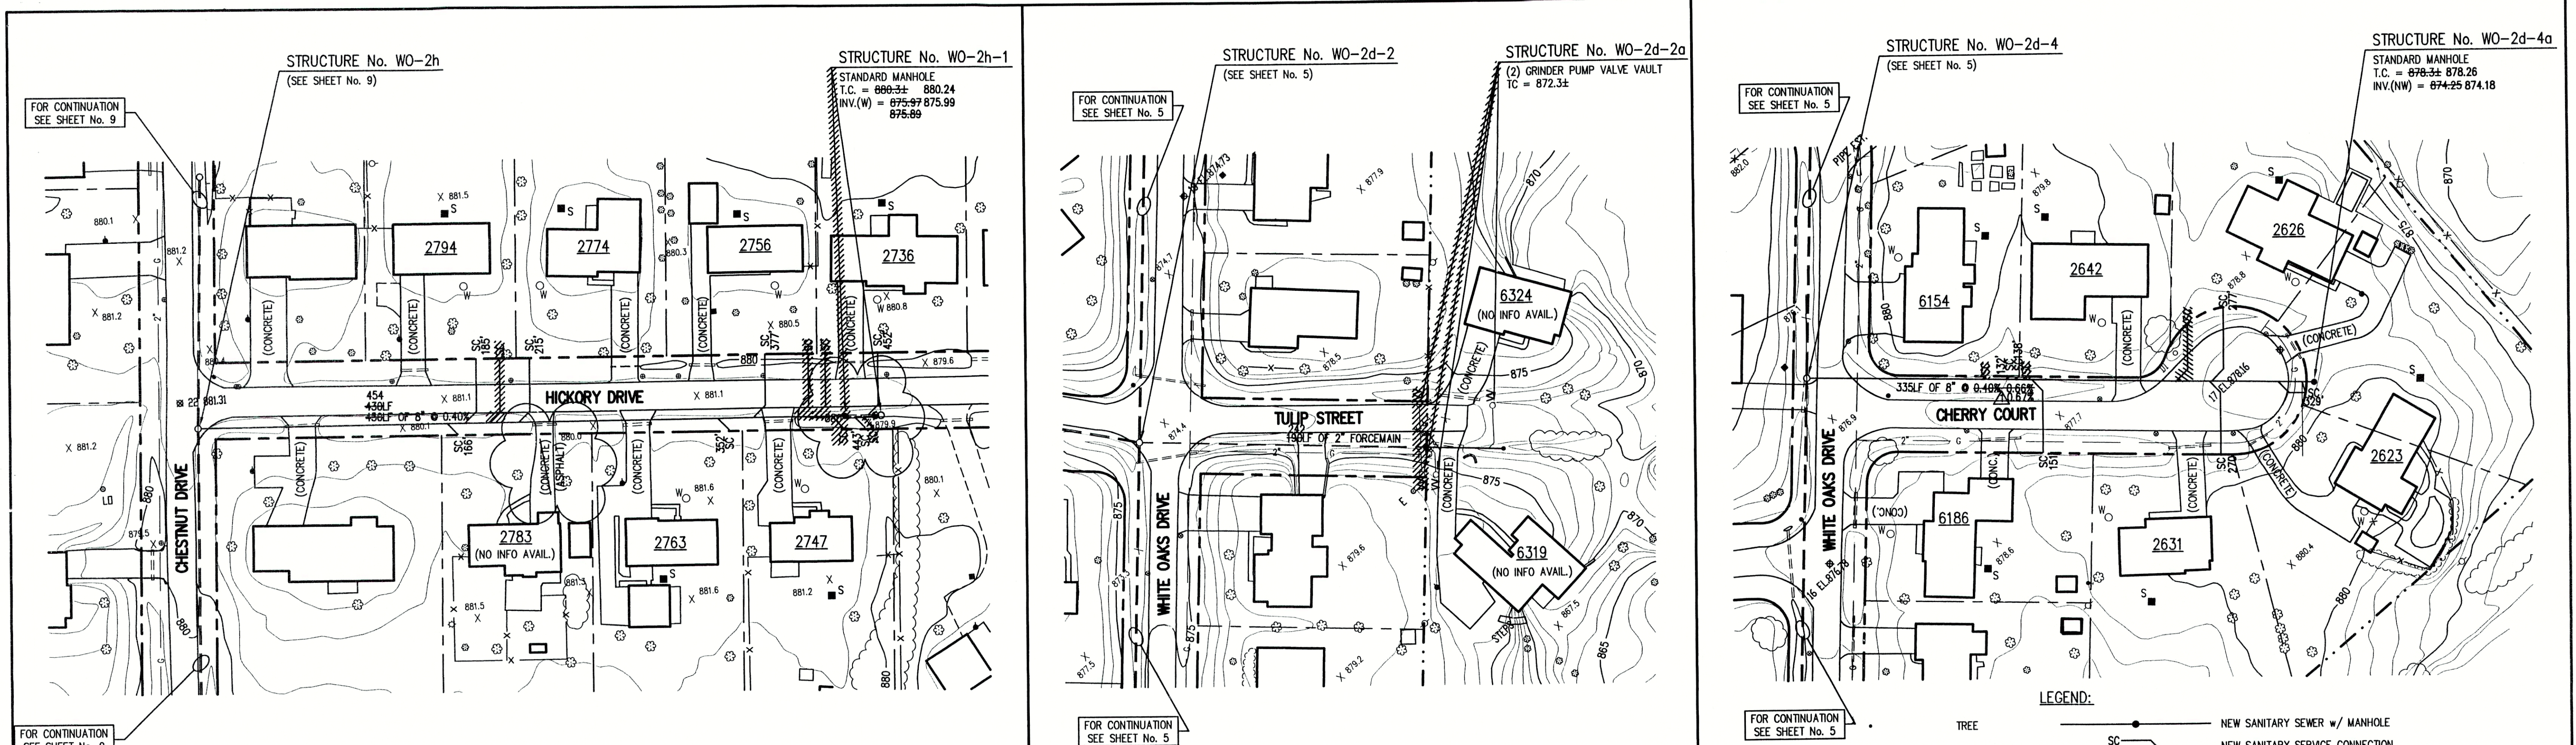

GENERAL NOTES:

- ALL UTILITY LOCATIONS ARE APPROXIMATE. THE CONTRACTOR SHALL HAVE ALL UTILITIES FIELD VERIFIED AND MARKED PRIOR TO CONSTRUCTION.
- CONTRACTOR SHALL MAINTAIN A MINIMUM 10'-0" HORIZONTAL AND 18" VERTICAL SEPARATION BETWEEN SEWER AND WATER MAINS.
- ALL PROPOSED TOP OF CASTING ELEVATIONS ARE APPROXIMATE. THE CONTRACTOR SHALL ADJUST FINAL ELEVATIONS AS REQUIRED TO BE FLUSH WITH PAVEMENT.
- ALL SEWER TRENCHES SHALL BE BACKFILLED WITH FULL DEPTH COMPACTED GRANULAR BACKFILL ("B" BORROW) UNDER OR WITHIN 5' OF EDGE OF PAVEMENT.
- THE CONTRACTOR SHALL VISIT THE SITE PRIOR TO BID TO BECOME FAMILIAR WITH ALL SITE CONDITIONS.
- THE CONTRACTOR SHALL PROVIDE THE REQUIRED MEANS FOR MAINTAINING SAFE TRAFFIC AT ALL TIMES.
- CONTRACTOR SHALL RESTORE ALL DISTURBED LAWN AREAS, STREETS, WALKS, DRIVES, ETC. AS SHOWN ON DRAWINGS, IN THE SPECIFICATIONS, OR TO AT LEAST PRE-EXISTING CONDITIONS.
- ALL UTILITY CROSSINGS SHALL BE PROTECTED AND SUPPORTED WITH GRANULAR FILL OR CONCRETE AS REQUIRED PER THE DETAIL SHEET.

NOTE:
ADDITIONAL RIGHT-OF-WAY OR EASEMENTS MAY NEED TO BE ACQUIRED FOR INSTALLATION OF SEWER.


PER INDIANA STATE LAW IS-69-1991, IT IS AGAINST THE LAW TO EXCAVATE WITHOUT NOTIFYING THE UNDERGROUND LOCATION SERVICE TWO (2) WORKING DAYS BEFORE COMMENCING WORK.

NOTE: CONTRACTOR TO VERIFY ALL UTILITY LOCATIONS PRIOR TO THE START OF CONSTRUCTION

LEGEND:

- TREE
- POWER POLE
- GUY WIRE
- FIRE HYDRANT
- MAILBOX
- FLAGPOLE
- SPOT SHOT
- CONTOUR
- FENCE
- EXIST. SANITARY SEWER w/ MANHOLE
- NEW SANITARY SEWER w/ MANHOLE
- NEW SANITARY SERVICE CONNECTION
- WATER LINE
- GAS LINE
- UNDERGROUND ELECTRIC LINE
- UNDERGROUND TELEPHONE LINE
- APPROX. RIGHT-OF-WAY
- APPROX. CORPORATE LIMITS
- APPROX. PROPERTY LINE
- EXISTING WATER WELL
- EXISTING SEPTIC TANK
- PROPOSED GRINDER PUMP VALVE VAULT

SCALE:
HORIZONTAL 1" = 50'
VERTICAL 1" = 5'

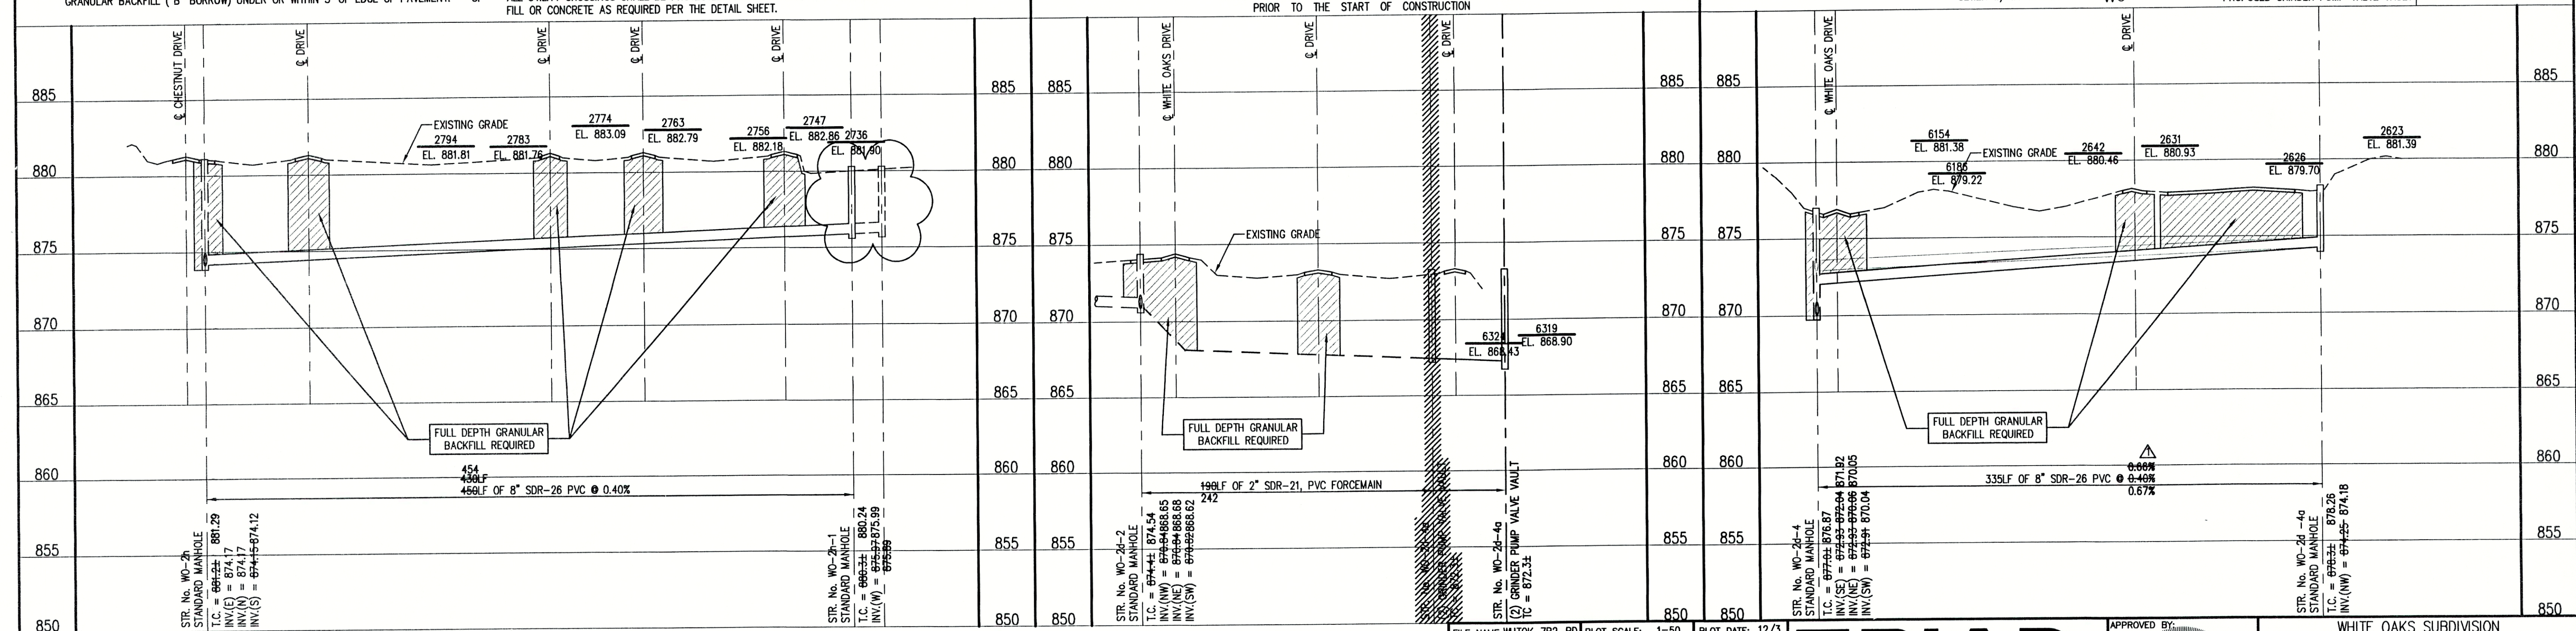

RECORD DRAWING

February 15, 2001

NOTE:
THE CONTRACTOR SHALL INCLUDE IN THE COSTS FOR SANITARY PIPE, ALL WATER SERVICE RECONNECTIONS, STORM SEWER RECONNECTION, WATER MAIN RELOCATIONS, CONCRETE RECONSTRUCTION, AND SIDEWALK RECONSTRUCTION AS REQUIRED TO INSTALL NEW WORK AS SHOWN ON THE DRAWINGS.

NO.	DATE	DESCRIPTION	BY
07/26/00	CHANGED SLOPE		D.A.P.

TRIAD ASSOCIATES INC.
INDIANAPOLIS, INDIANA

APPROVED BY: **THOMAS M. SCHUBERT**
REGISTERED PROFESSIONAL ENGINEER
No. 15614
STATE OF INDIANA


WHITE OAKS SUBDIVISION
FALL CREEK REGIONAL WASTE DISTRICT

PLAN AND PROFILE

DRAWN BY:	DATE:	PROJECT No.	SHEET No.
DAP	04/12/98	98008A	7

DESIGNED BY: D.A. Pauling
CHECKED BY: James W. Frazell, P.E.

C:\Drawing\DWG\Records\White_Oaks\750-40.dwg, 12/03/01, 10:43:17 AM, T:\d\dwg\dwg.plt

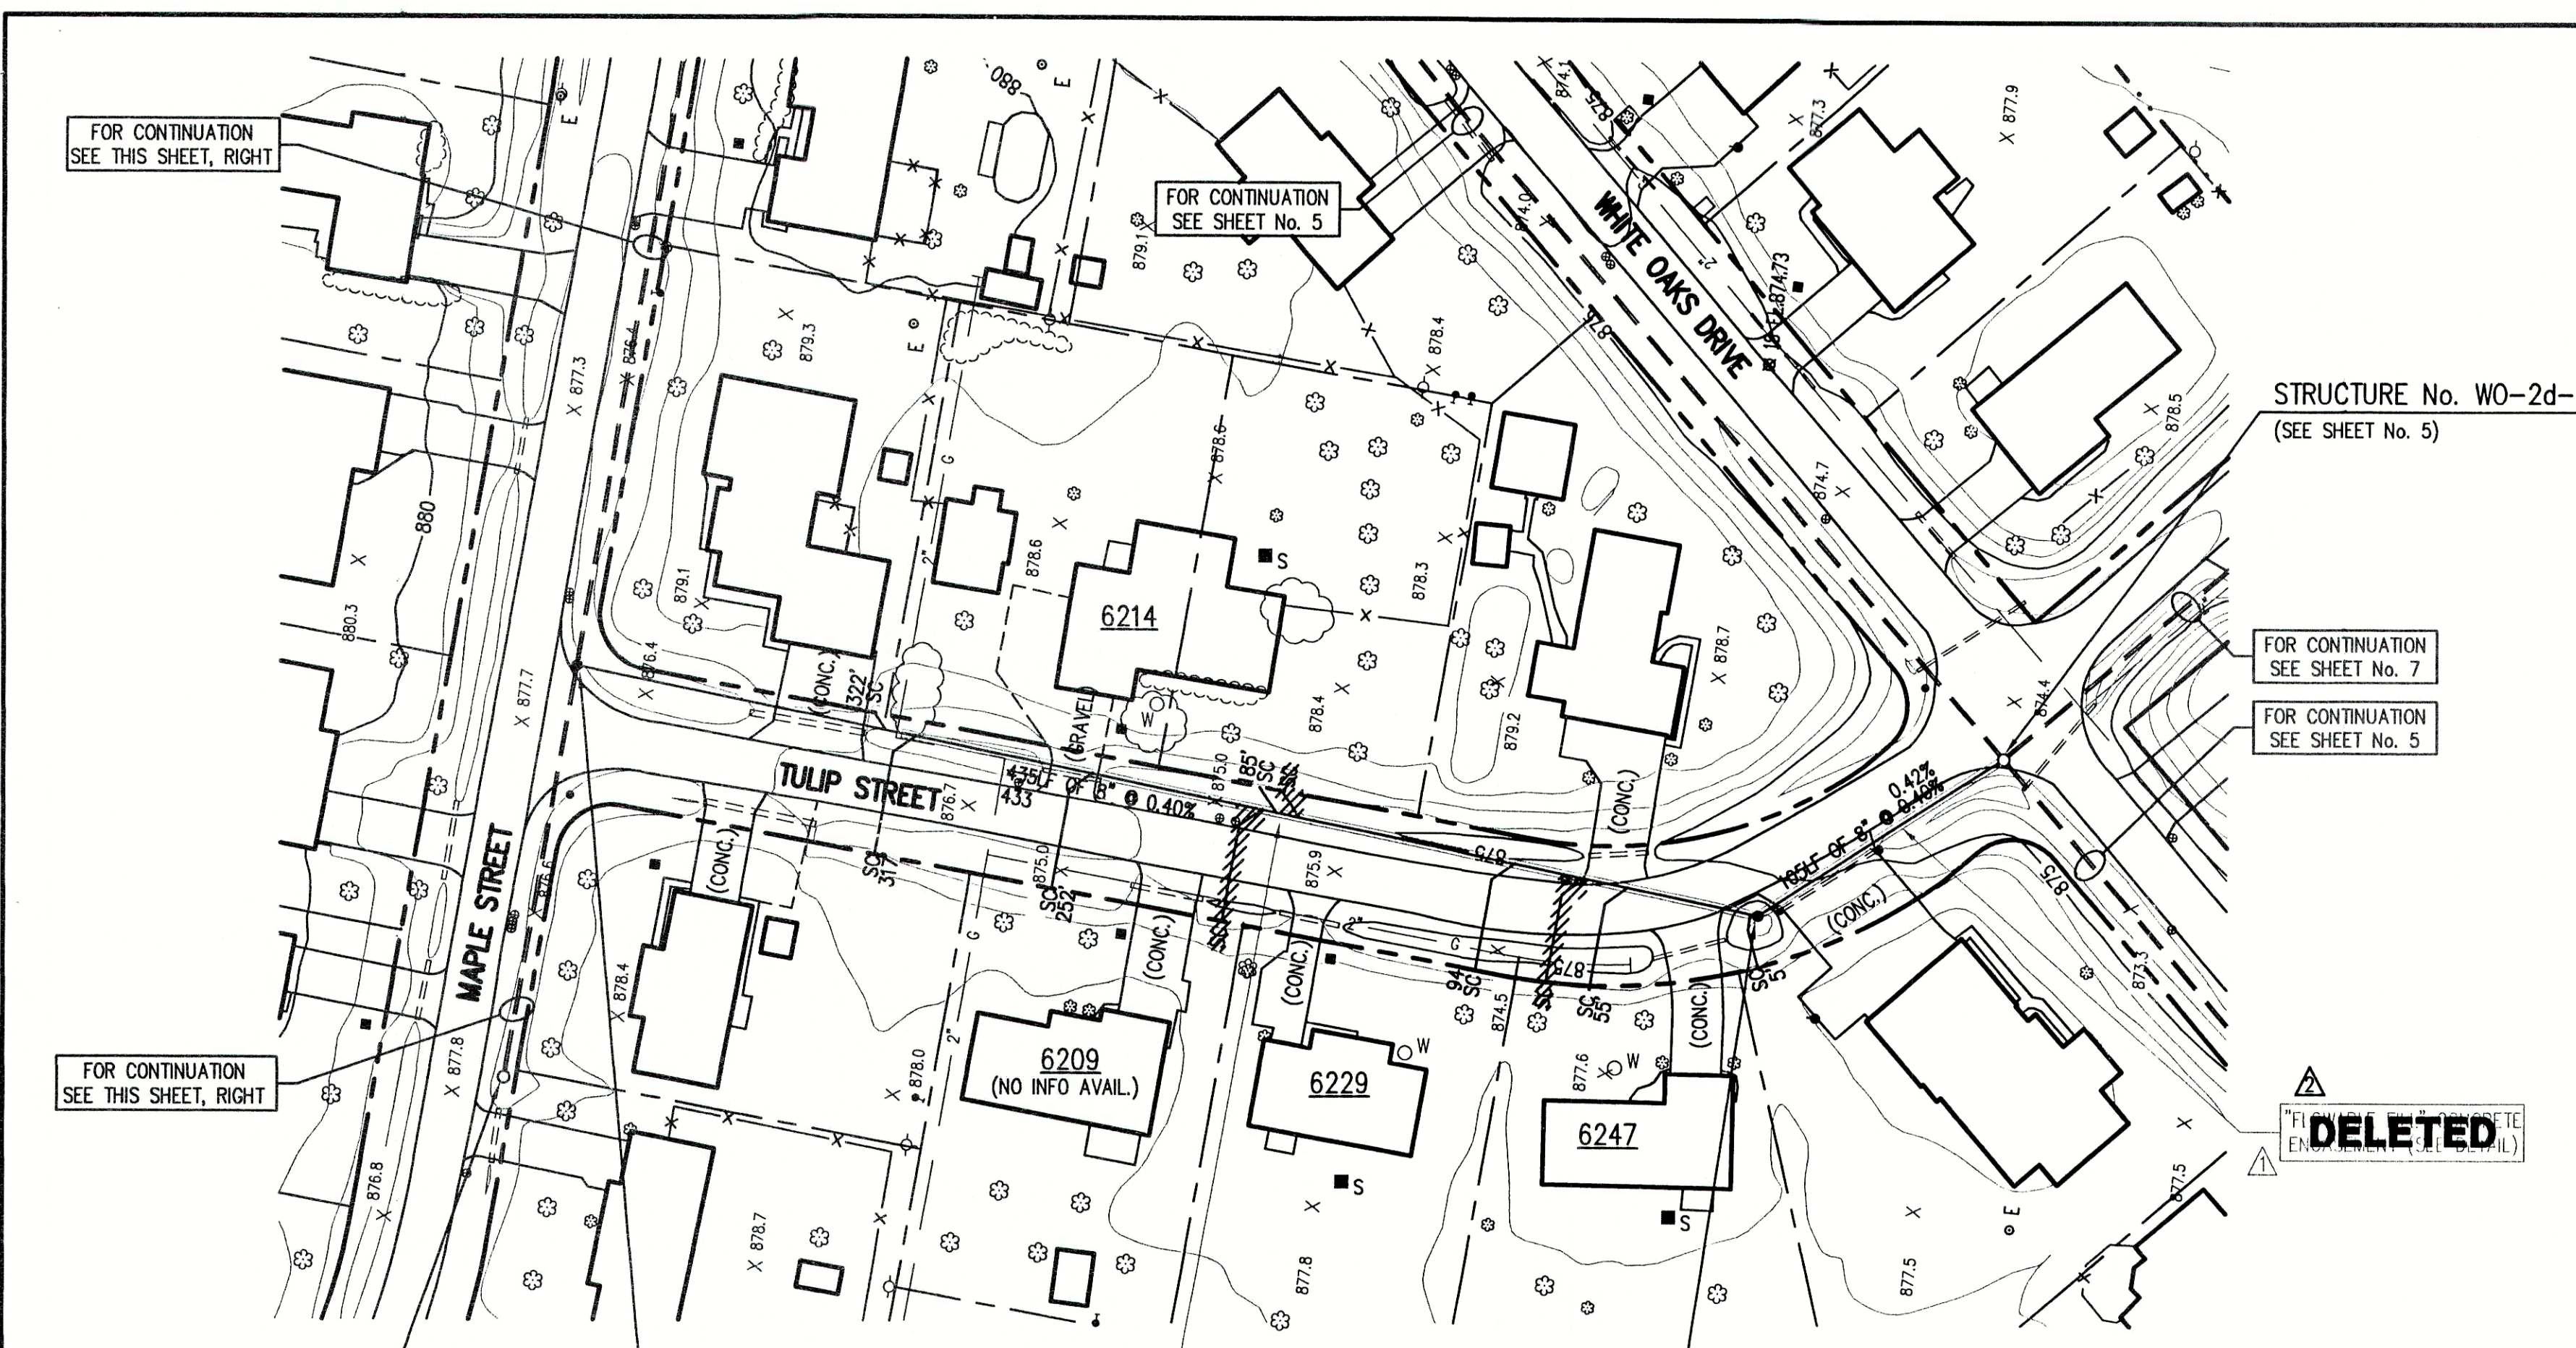

STRUCTURE No. WO-2d-2c1
STANDARD MANHOLE
T.C. = 877.54 877.50
INV.(E) = 873.63 871.55 871.58

STRUCTURE No. WO-2d-2c
STANDARD MANHOLE
T.C. = 875.44 874.84
INV.(N) = 871.20 869.20 869.19
INV.(SE) = 871.20 869.10 869.09

STRUCTURE No. WO-2d-2b
STANDARD MANHOLE
T.C. = 875.44 874.84
INV.(N) = 871.20 869.20 869.19
INV.(SE) = 871.20 869.10 869.09

STRUCTURE No. WO-2d-2
(SEE SHEET No. 5)


GENERAL NOTES:

- ALL UTILITY LOCATIONS ARE APPROXIMATE. THE CONTRACTOR SHALL HAVE ALL UTILITIES FIELD VERIFIED AND MARKED PRIOR TO CONSTRUCTION.
- CONTRACTOR SHALL MAINTAIN A MINIMUM 10'-0" HORIZONTAL AND 18" VERTICAL SEPARATION BETWEEN SEWER AND WATER MAINS.
- ALL PROPOSED TOP OF CASTING ELEVATIONS ARE APPROXIMATE. THE CONTRACTOR SHALL ADJUST FINAL ELEVATIONS AS REQUIRED TO BE FLUSH WITH PAVEMENT.
- ALL SEWER TRENCHES SHALL BE BACKFILLED WITH FULL DEPTH COMPACTED GRANULAR BACKFILL ("B" BORROW) UNDER OR WITHIN 5' OF EDGE OF PAVEMENT.
- THE CONTRACTOR SHALL VISIT THE SITE PRIOR TO BID TO BECOME FAMILIAR WITH ALL SITE CONDITIONS.
- THE CONTRACTOR SHALL PROVIDE THE REQUIRED MEANS FOR MAINTAINING SAFE TRAFFIC AT ALL TIMES.
- CONTRACTOR SHALL RESTORE ALL DISTURBED LAWN AREAS, STREETS, WALKS, DRIVES, ETC. AS SHOWN ON DRAWINGS, IN THE SPECIFICATIONS, OR TO AT LEAST PRE-EXISTING CONDITIONS.
- ALL UTILITY CROSSINGS SHALL BE PROTECTED AND SUPPORTED WITH GRANULAR FILL OR CONCRETE AS REQUIRED PER THE DETAIL SHEET.

NOTE: CONTRACTOR TO VERIFY ALL UTILITY LOCATIONS PRIOR TO THE START OF CONSTRUCTION

PER INDIANA STATE LAW IS-69-1991, IT IS AGAINST THE LAW TO EXCAVATE WITHOUT NOTIFYING THE UNDERGROUND LOCATION SERVICE TWO (2) WORKING DAYS BEFORE COMMENCING WORK.


NOTE: CONTRACTOR TO VERIFY ALL UTILITY LOCATIONS PRIOR TO THE START OF CONSTRUCTION

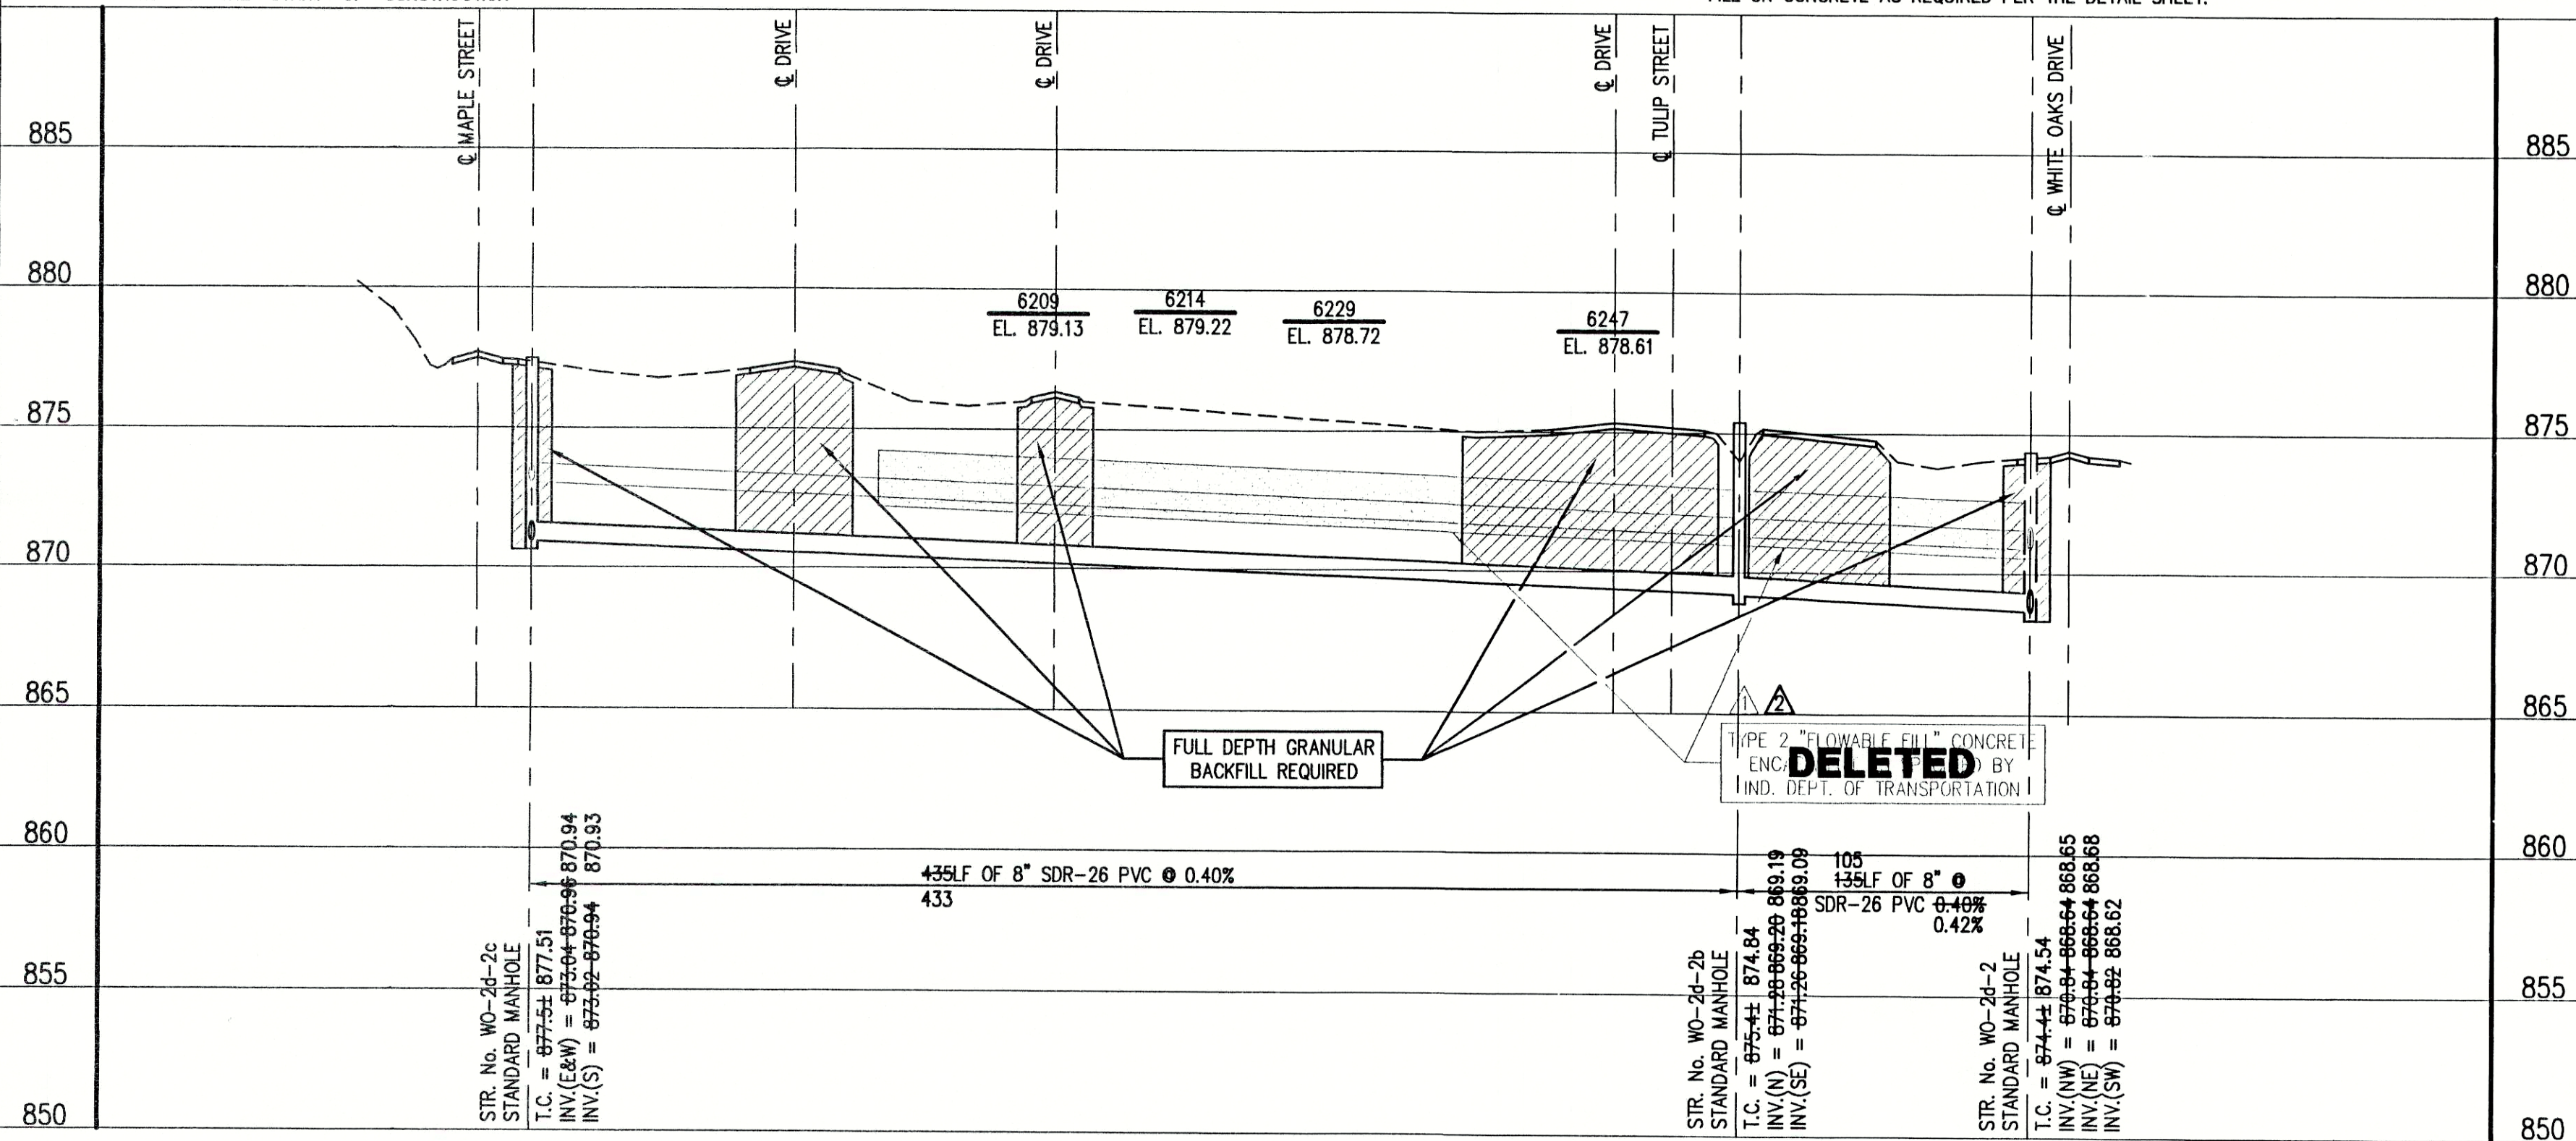

RECORD DRAWING

February 15, 2001

NOTE:
THE CONTRACTOR SHALL INCLUDE IN THE COSTS FOR SANITARY PIPE, ALL WATER SERVICE RECONNECTIONS, STORM SEWER RECONNECTION, WATER MAIN RELOCATIONS, CONCRETE RECONSTRUCTION, AND SIDEWALK RECONSTRUCTION AS REQUIRED TO INSTALL NEW WORK AS SHOWN ON THE DRAWINGS.

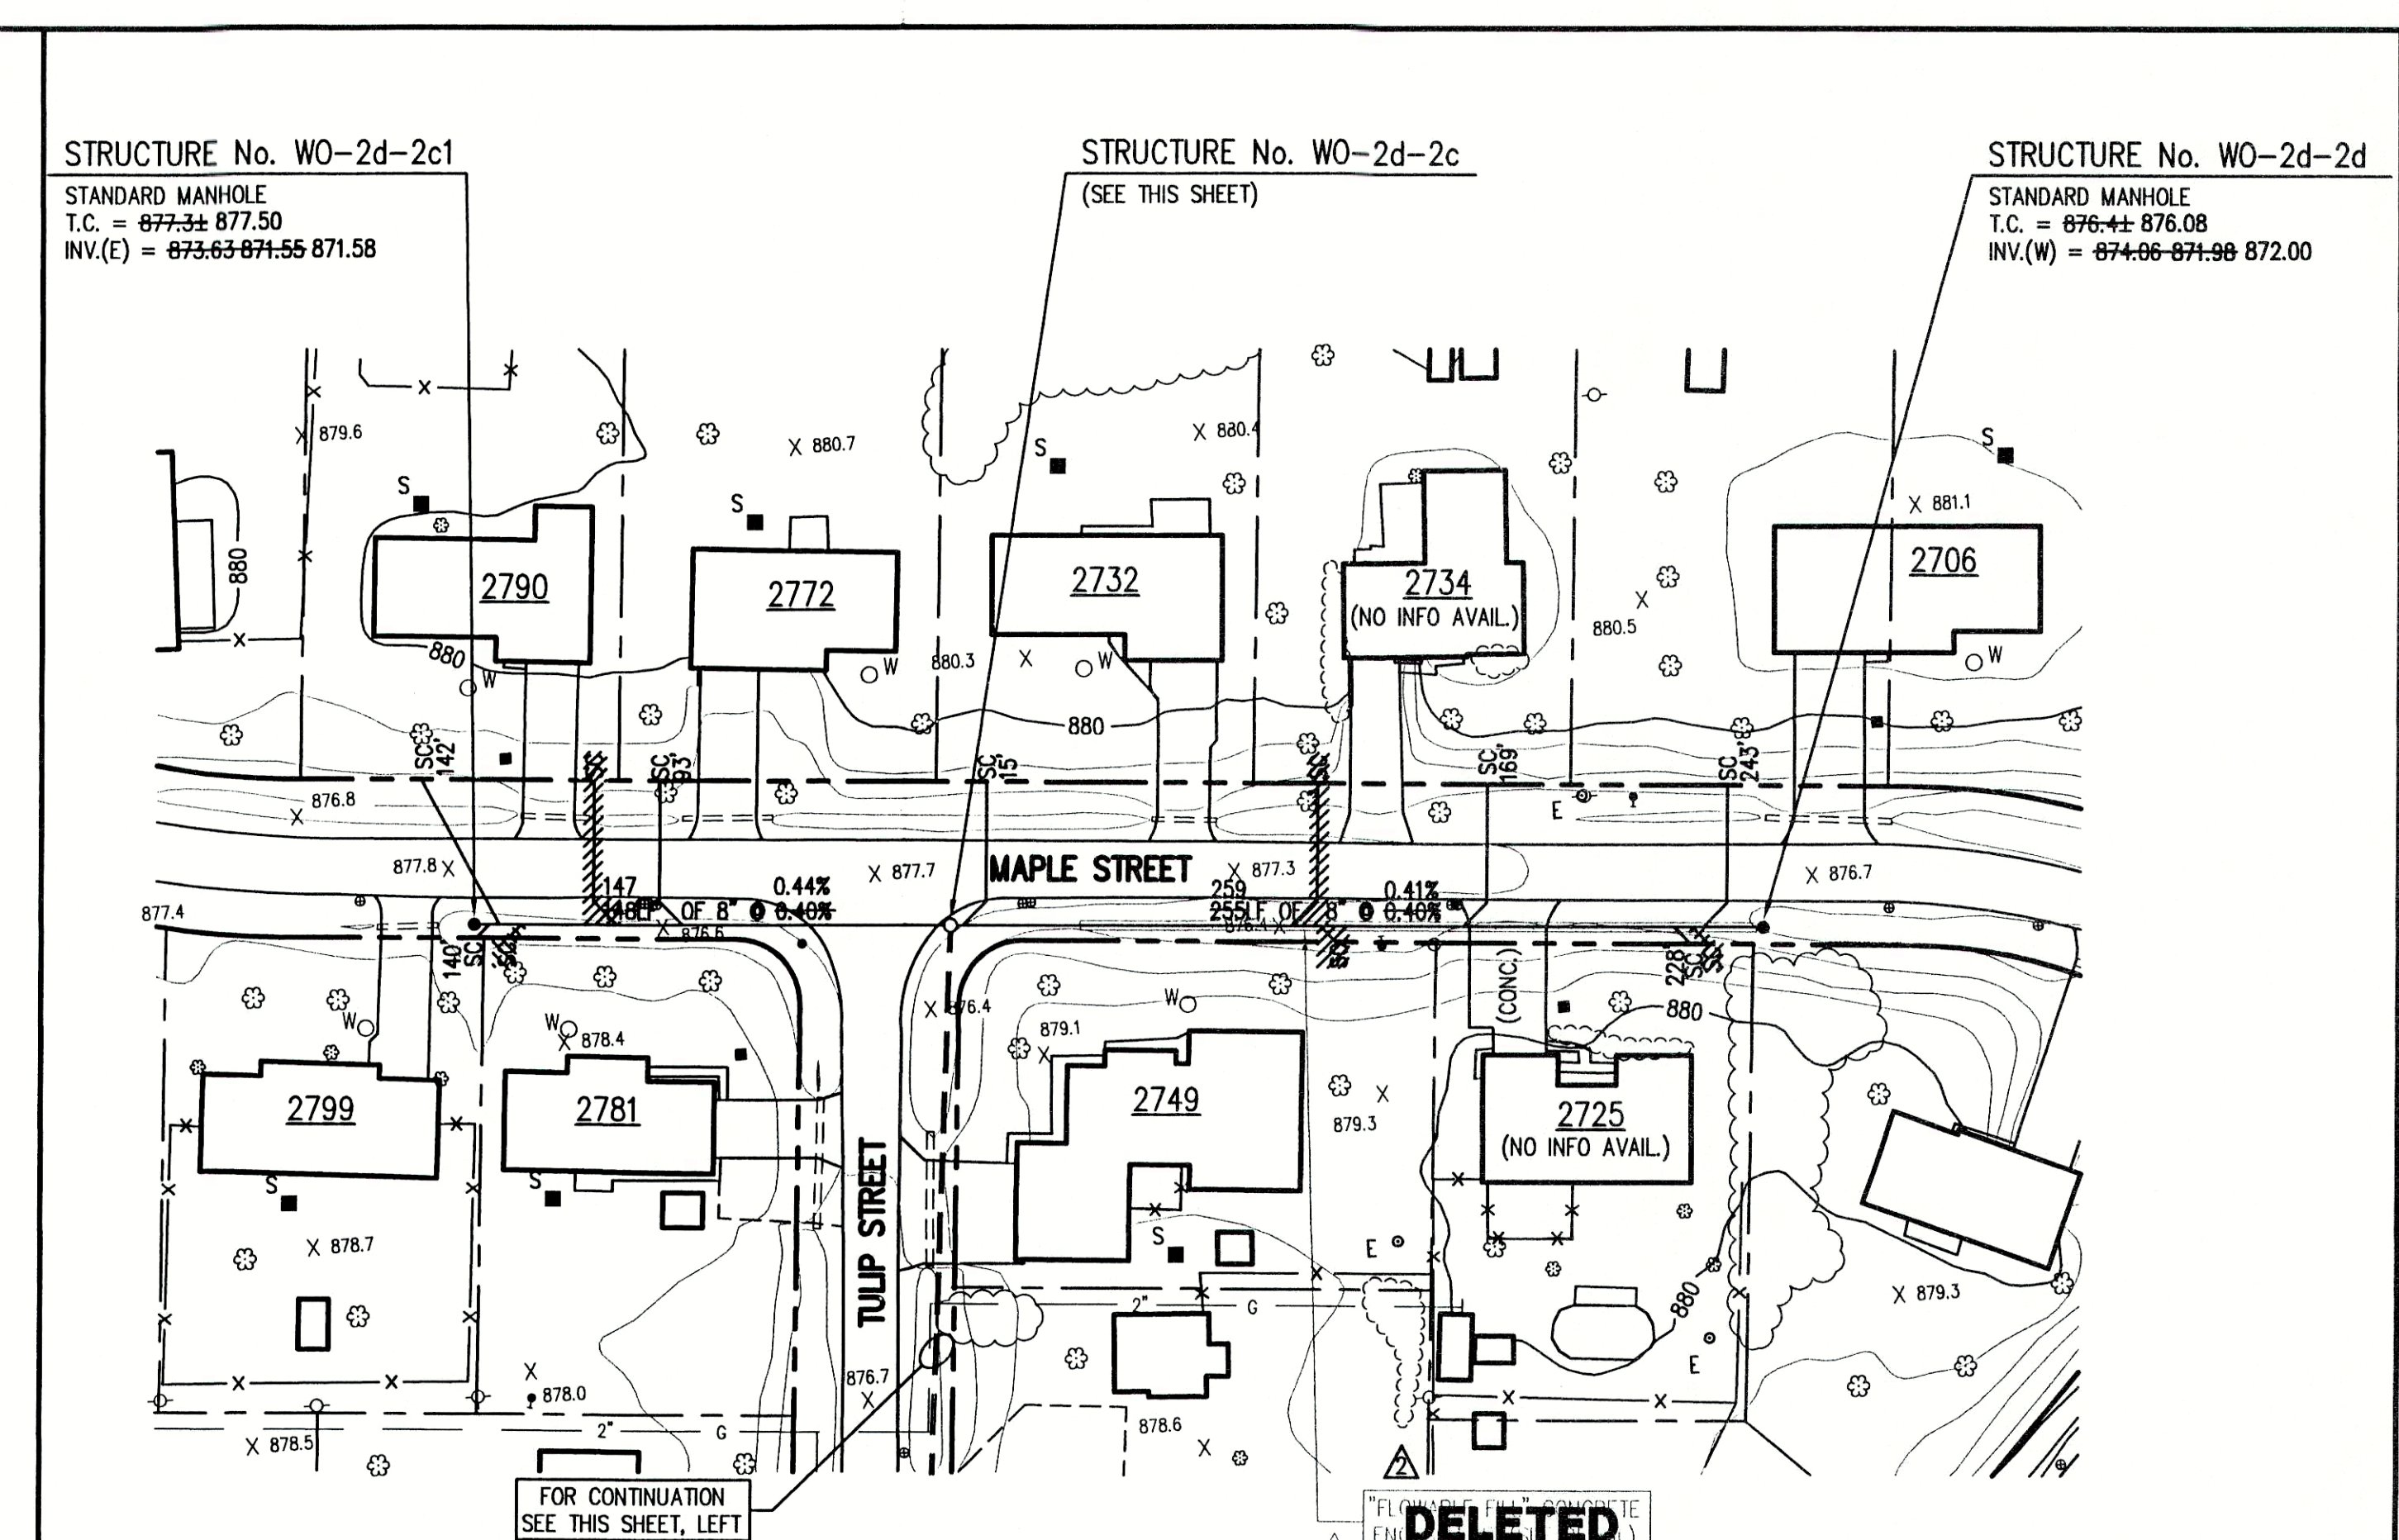

STRUCTURE No. WO-2d-2c1
STANDARD MANHOLE
T.C. = 877.54 877.50
INV.(E) = 873.63 871.55 871.58


STRUCTURE No. WO-2d-2c
(SEE THIS SHEET)

STRUCTURE No. WO-2d-2d
STANDARD MANHOLE
T.C. = 876.44 876.08
INV.(W) = 874.06 871.98 872.00

LEGEND:

- TREE
- POWER POLE
- GUY WIRE
- FIRE HYDRANT
- MAILBOX
- FLAGPOLE
- SPOT SHOT
- CONTOUR
- FENCE
- EXIST. SANITARY SEWER w/ MANHOLE
- NEW SANITARY SEWER w/ MANHOLE
- NEW SANITARY SERVICE CONNECTION
- WATER LINE
- GAS LINE
- UNDERGROUND ELECTRIC LINE
- UNDERGROUND TELEPHONE LINE
- APPROX. RIGHT-OF-WAY
- APPROX. CORPORATE LIMITS
- APPROX. PROPERTY LINE
- EXISTING WATER WELL
- EXISTING SEPTIC TANK

SCALE:
HORIZONTAL 1" = 50'
VERTICAL 1" = 5'

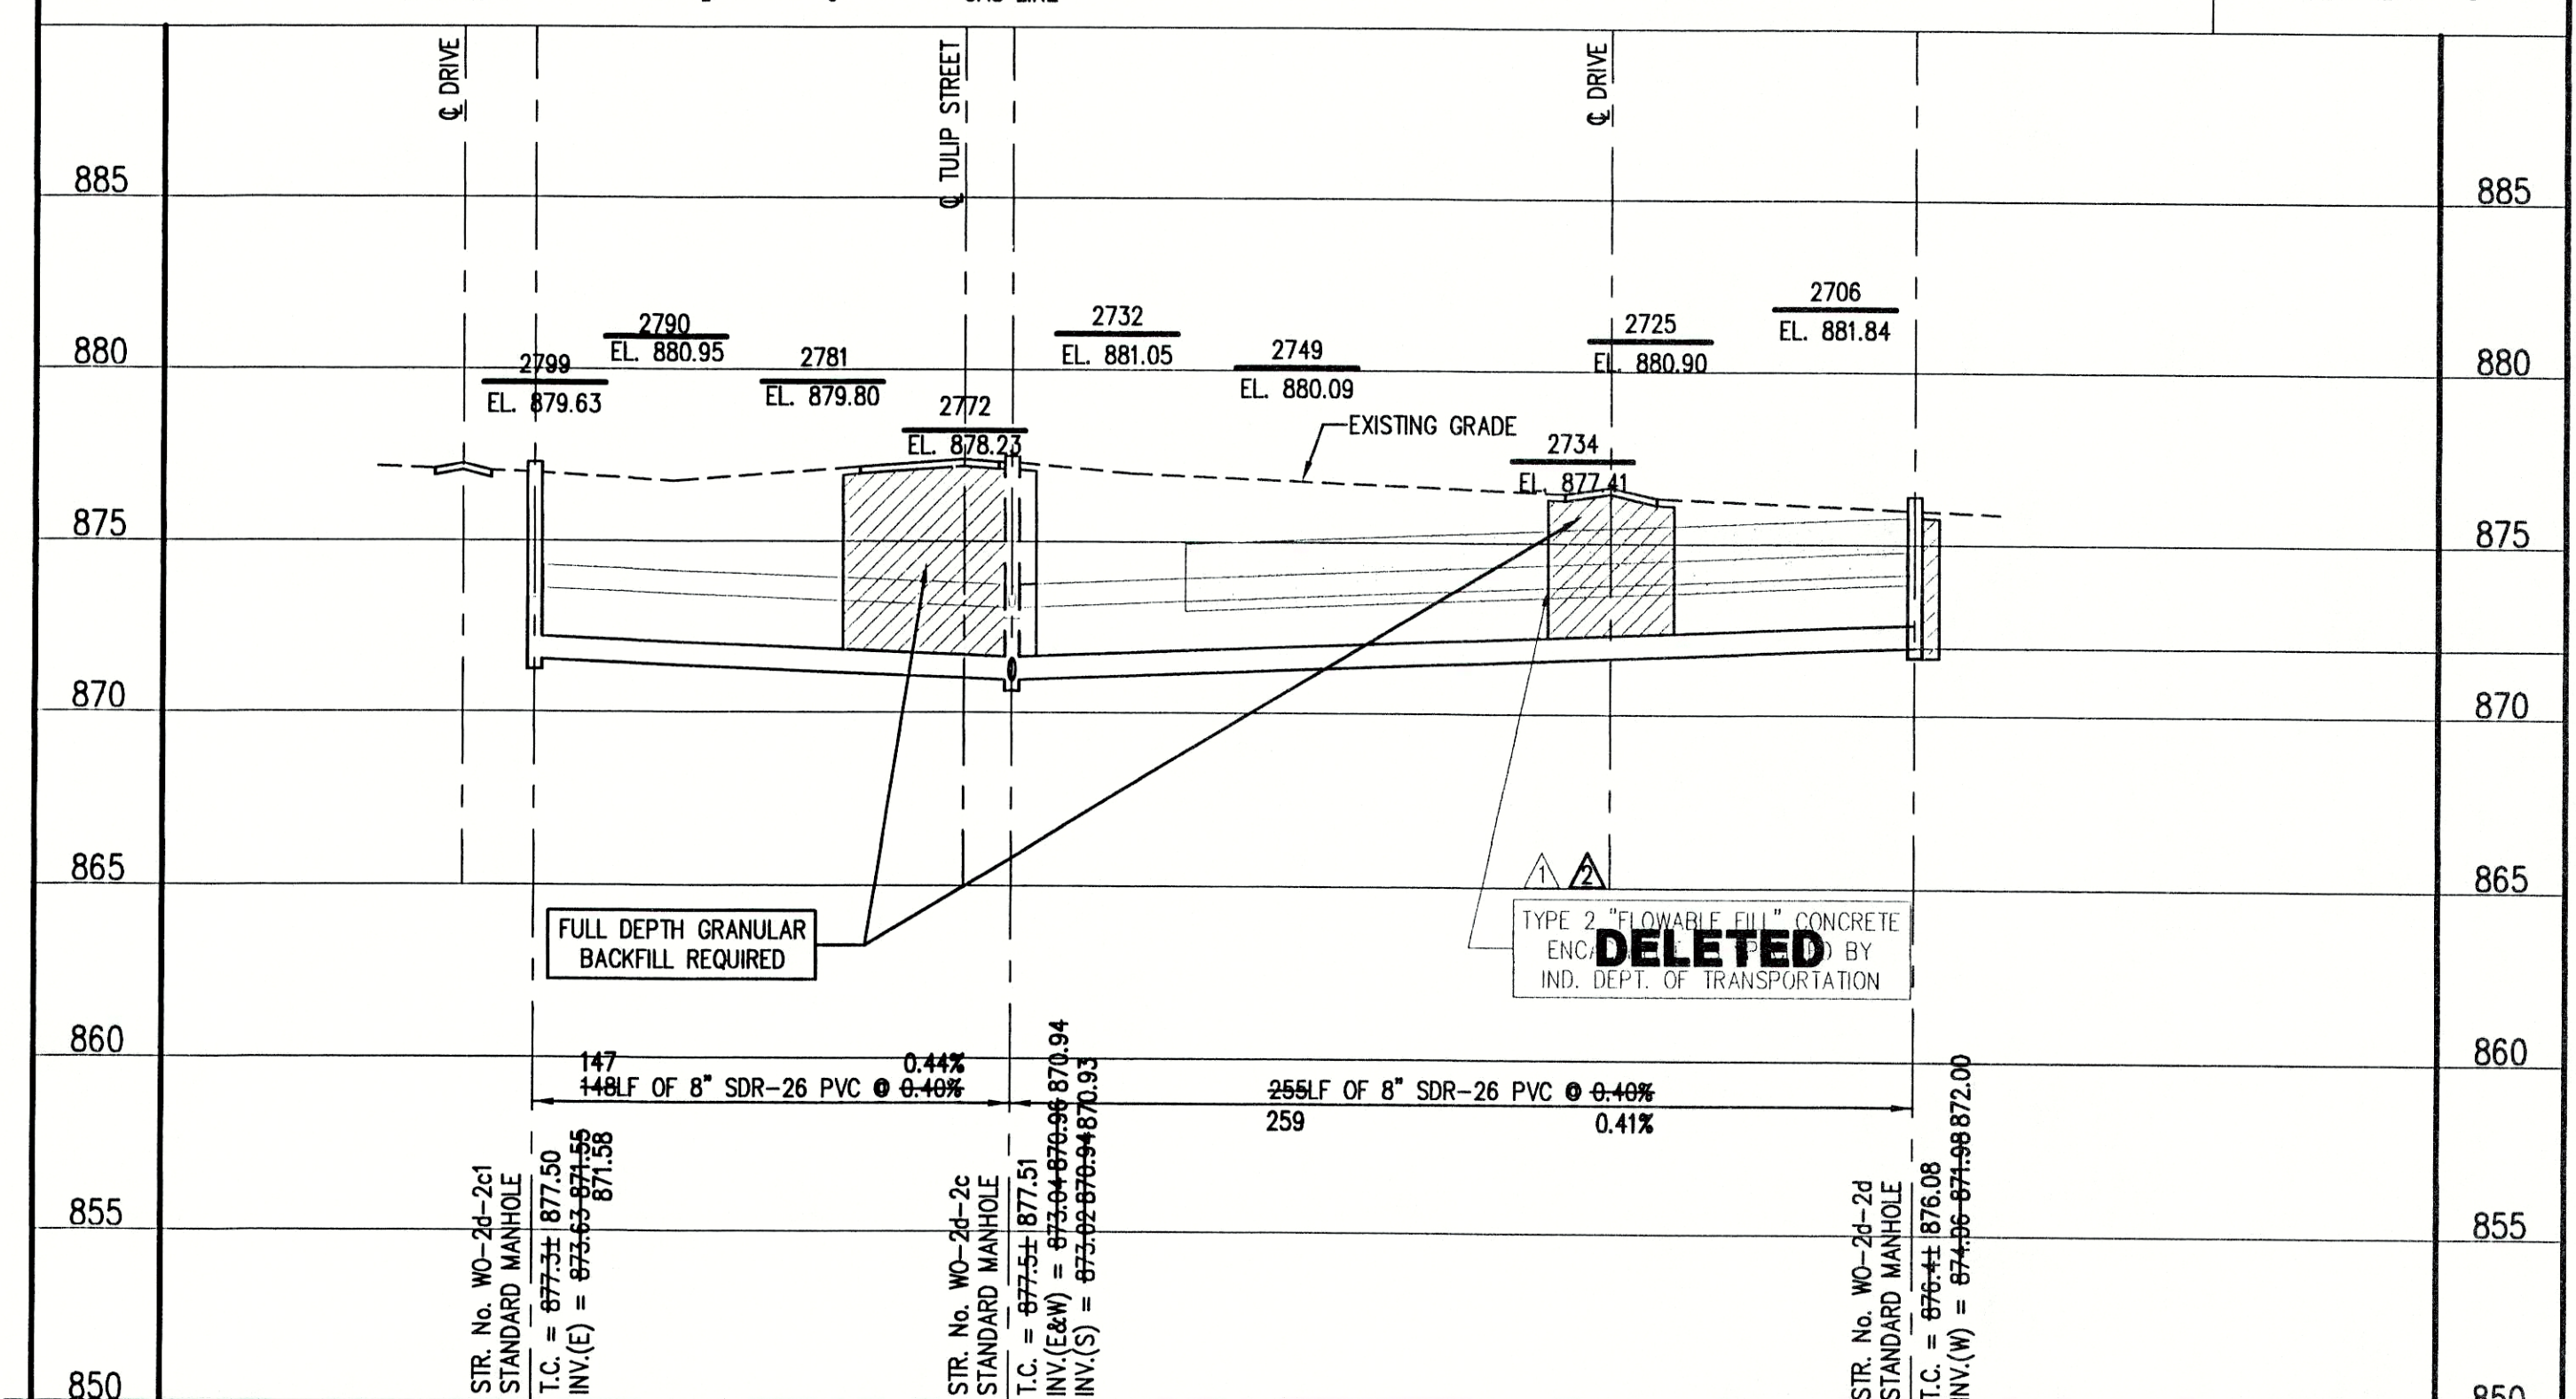

FILE NAME: WHITOK_9R2-RD PLOT SCALE: 1"=50' PLOT DATE: 12/3		TRIAD ASSOCIATES INC. INDIANAPOLIS, INDIANA	APPROVED BY: Thomas M. Schubert, P.E.	WHITE OAKS SUBDIVISION FALL CREEK REGIONAL WASTE DISTRICT		
12/29/99	ADDED CONCRETE ENCASUREMENT			D.A.P.	PLAN AND PROFILE	
07/26/00	REMOVED CONCRETE ENCASUREMENT			D.A.P.	DRAWN BY: DAP DATE: 04/12/98 PROJECT No. 98008A SHEET No. 8	
				DESIGNED BY: D.A. Pauling CHECKED BY: James W. Frazell, P.E.		

STRUCTURE No. WO-2i
STANDARD MANHOLE
T.C. = 880.22 881.02
INV.(S) = 874.83 874.77


STRUCTURE No. WO-2h
STANDARD MANHOLE
T.C. = 880.22 881.29
INV.(E) = 874.17
INV.(N) = 874.17
INV.(S) = 874.15 874.12

STRUCTURE No. WO-2g
STANDARD MANHOLE
T.C. = 878.02 878.54
INV.(E) = 873.11 873.09
INV.(N) = 873.09 873.04
INV.(S) = 873.09 873.04

STRUCTURE No. WO-2f
STANDARD MANHOLE
T.C. = 878.02 878.34
INV.(N) = 872.54 872.46
INV.(S) = 872.49 872.45

STRUCTURE No. WO-2e
STANDARD MANHOLE
T.C. = 877.61 877.49
INV.(N) = 876.79 870.78
INV.(S) = 876.77 870.74

STRUCTURE No. WO-2d
(SEE SHEET No. 4)

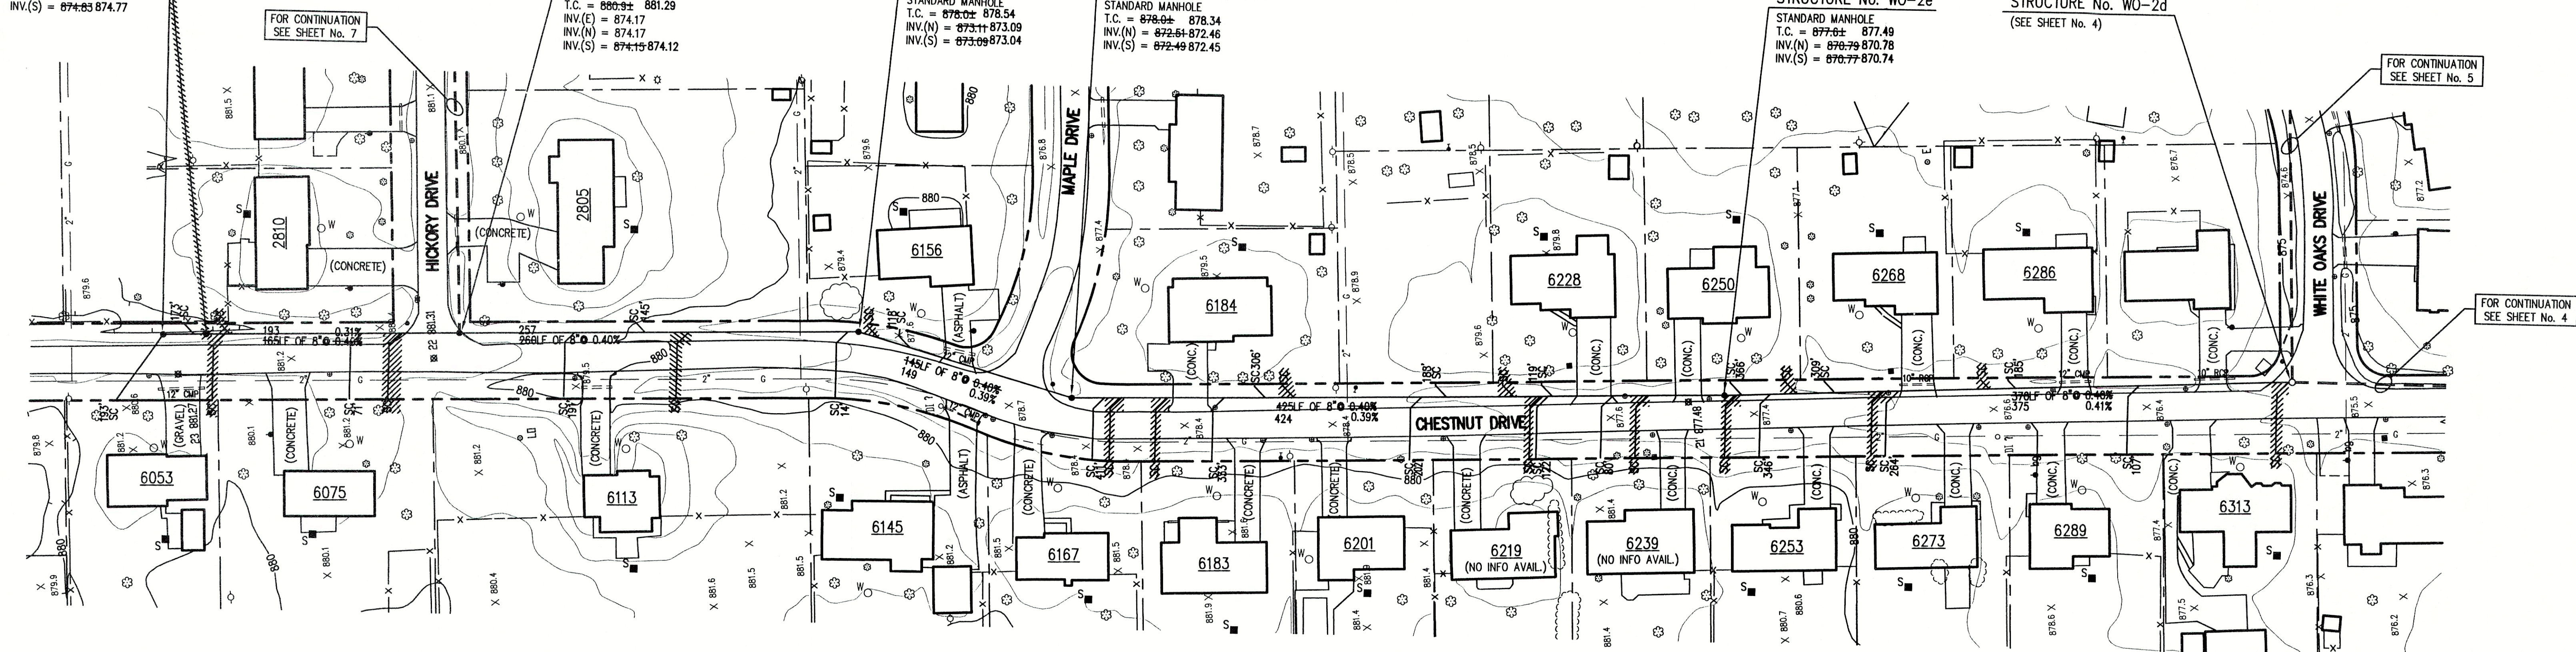

NOTE:
ADDITIONAL RIGHT-OF-WAY OR EASEMENTS MAY
NEED TO BE ACQUIRED FOR INSTALLATION OF SEWER.



DON'T DIG BLIND
CALL BEFORE YOU DIG
1-800-382-5544
1-800-428-5200

PER INDIANA STATE LAW 15-89-1981, IT IS
AGAINST THE LAW TO EXCAVATE WITHOUT
NOTIFYING THE UNDERGROUND LOCATION SERVICE
TWO (2) WORKING DAYS BEFORE COMMENCING WORK.

NOTE: CONTRACTOR TO VERIFY ALL UTILITY LOCATIONS
PRIOR TO THE START OF CONSTRUCTION

GENERAL NOTES:


- ALL UTILITY LOCATIONS ARE APPROXIMATE. THE CONTRACTOR SHALL HAVE ALL UTILITIES FIELD VERIFIED AND MARKED PRIOR TO CONSTRUCTION.
- CONTRACTOR SHALL MAINTAIN A MINIMUM 10'-0" HORIZONTAL AND 18" VERTICAL SEPARATION BETWEEN SEWER AND WATER MAINS.
- ALL PROPOSED TOP OF CASTING ELEVATIONS ARE APPROXIMATE. THE CONTRACTOR SHALL ADJUST FINAL ELEVATIONS AS REQUIRED TO BE FLUSH WITH PAVEMENT.
- ALL SEWER TRENCHES SHALL BE BACKFILLED WITH FULL DEPTH COMPACTED GRANULAR BACKFILL ("B" BORROW) UNDER OR WITHIN 5' OF EDGE OF PAVEMENT.
- THE CONTRACTOR SHALL VISIT THE SITE PRIOR TO BID TO BECOME FAMILIAR WITH ALL SITE CONDITIONS.
- THE CONTRACTOR SHALL PROVIDE THE REQUIRED MEANS FOR MAINTAINING SAFE TRAFFIC AT ALL TIMES.
- CONTRACTOR SHALL RESTORE ALL DISTURBED LAWN AREAS, STREETS, WALKS, DRIVES, ETC. AS SHOWN ON DRAWINGS, IN THE SPECIFICATIONS, OR TO AT LEAST PRE-EXISTING CONDITIONS.
- ALL UTILITY CROSSINGS SHALL BE PROTECTED AND SUPPORTED WITH GRANULAR FILL OR CONCRETE AS REQUIRED PER THE DETAIL SHEET.

LEGEND:

- TREE
- POWER POLE
- GUY WIRE
- FIRE HYDRANT
- MAILBOX
- FLAGPOLE
- SPOT SHOT
- CONTOUR
- FENCE
- EXIST. SANITARY SEWER w/ MANHOLE
- NEW SANITARY SEWER w/ MANHOLE
- NEW SANITARY SERVICE CONNECTION
- WATER LINE
- GAS LINE
- UNDERGROUND ELECTRIC LINE
- UNDERGROUND TELEPHONE LINE
- APPROX. RIGHT-OF-WAY
- APPROX. CORPORATE LIMITS
- APPROX. PROPERTY LINE
- EXISTING WATER WELL
- EXISTING SEPTIC TANK



SCALE:
HORIZONTAL 1" = 50'
VERTICAL 1" = 5'

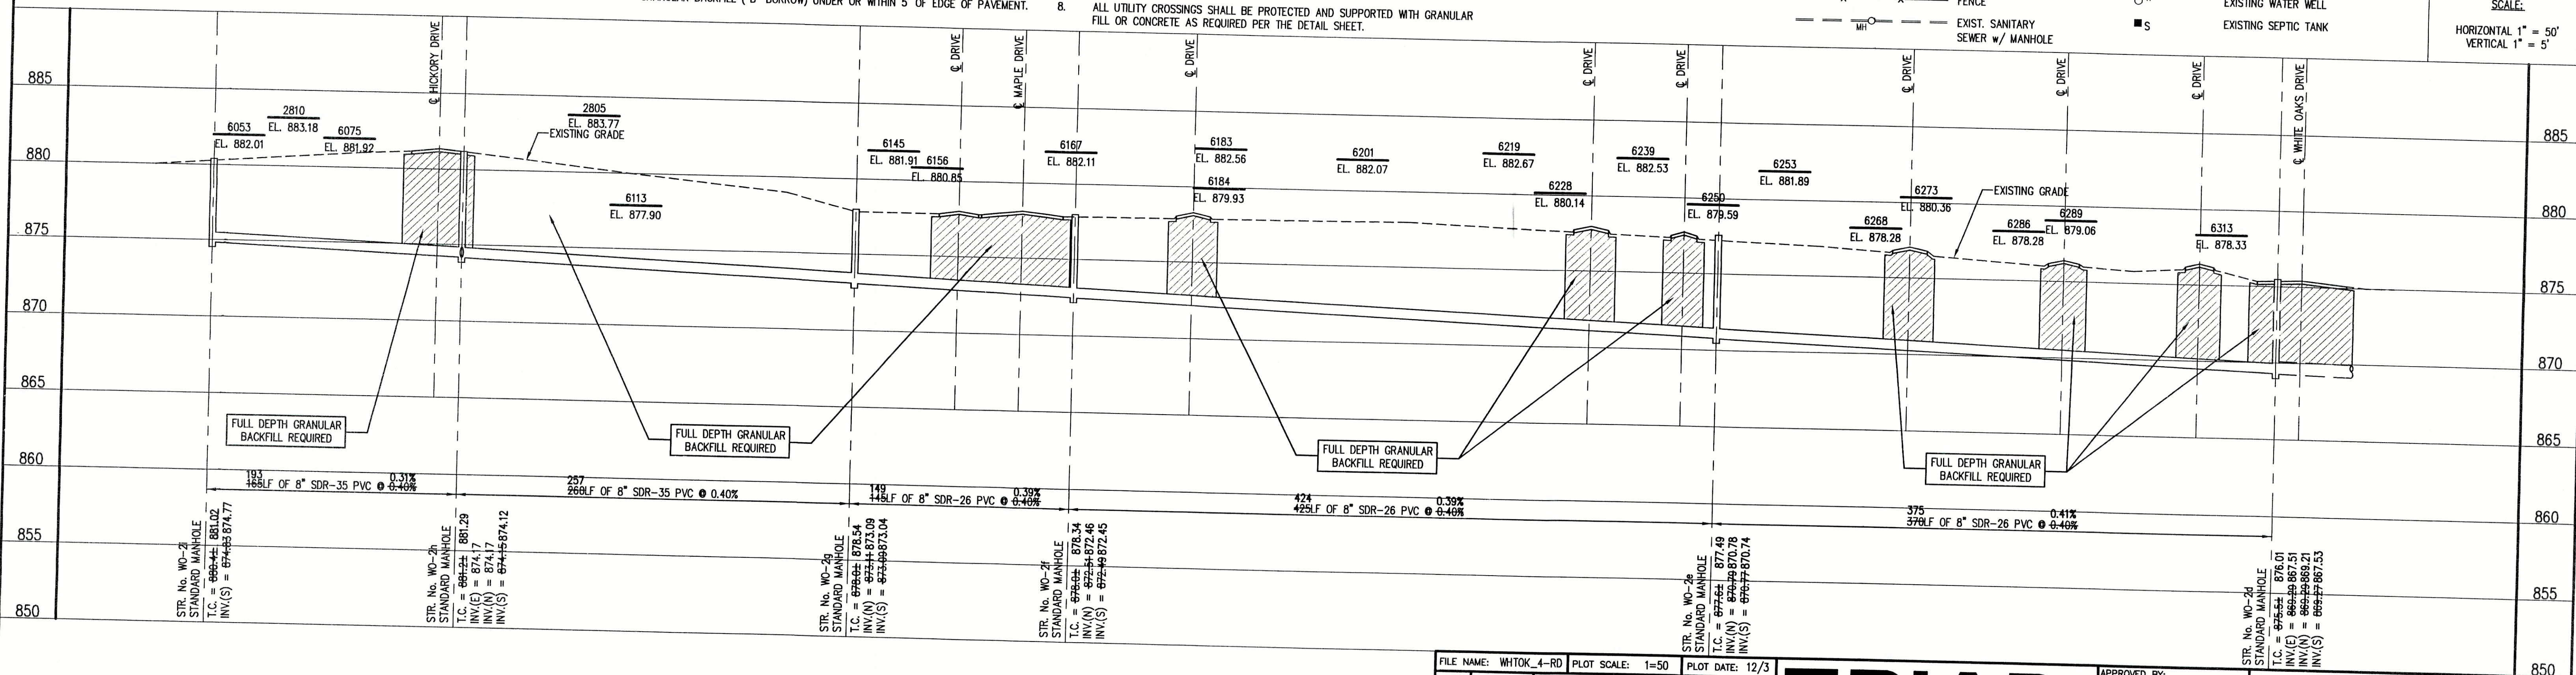

RECORD DRAWING


February 15, 2001

NOTE:


THE CONTRACTOR SHALL INCLUDE IN THE COSTS FOR SANITARY PIPE, ALL WATER SERVICE RECONNECTIONS, STORM SEWER RECONNECTION, WATER MAIN RELOCATIONS, CONCRETE RECONSTRUCTION, AND SIDEWALK RECONSTRUCTION AS REQUIRED TO INSTALL NEW WORK AS SHOWN ON THE DRAWINGS.

NO.	DATE	DESCRIPTION	BY


TRIAD ASSOCIATES INC.
INDIANAPOLIS, INDIANA

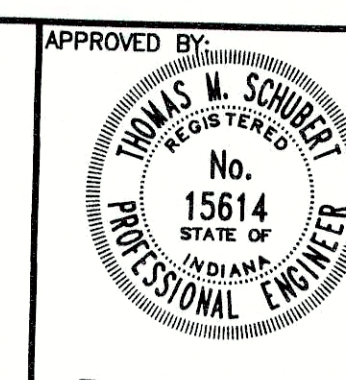


WHITE OAKS SUBDIVISION
FALL CREEK REGIONAL WASTE DISTRICT
PLAN AND PROFILE
DRAWN BY: DAP
DATE: 04/12/98
SCALE: AS NOTED
PROJECT No.: 98008A
SHEET No.: 9
DESIGNED BY: D.A. Pauling
CHECKED BY: James W. Frazell, P.E.

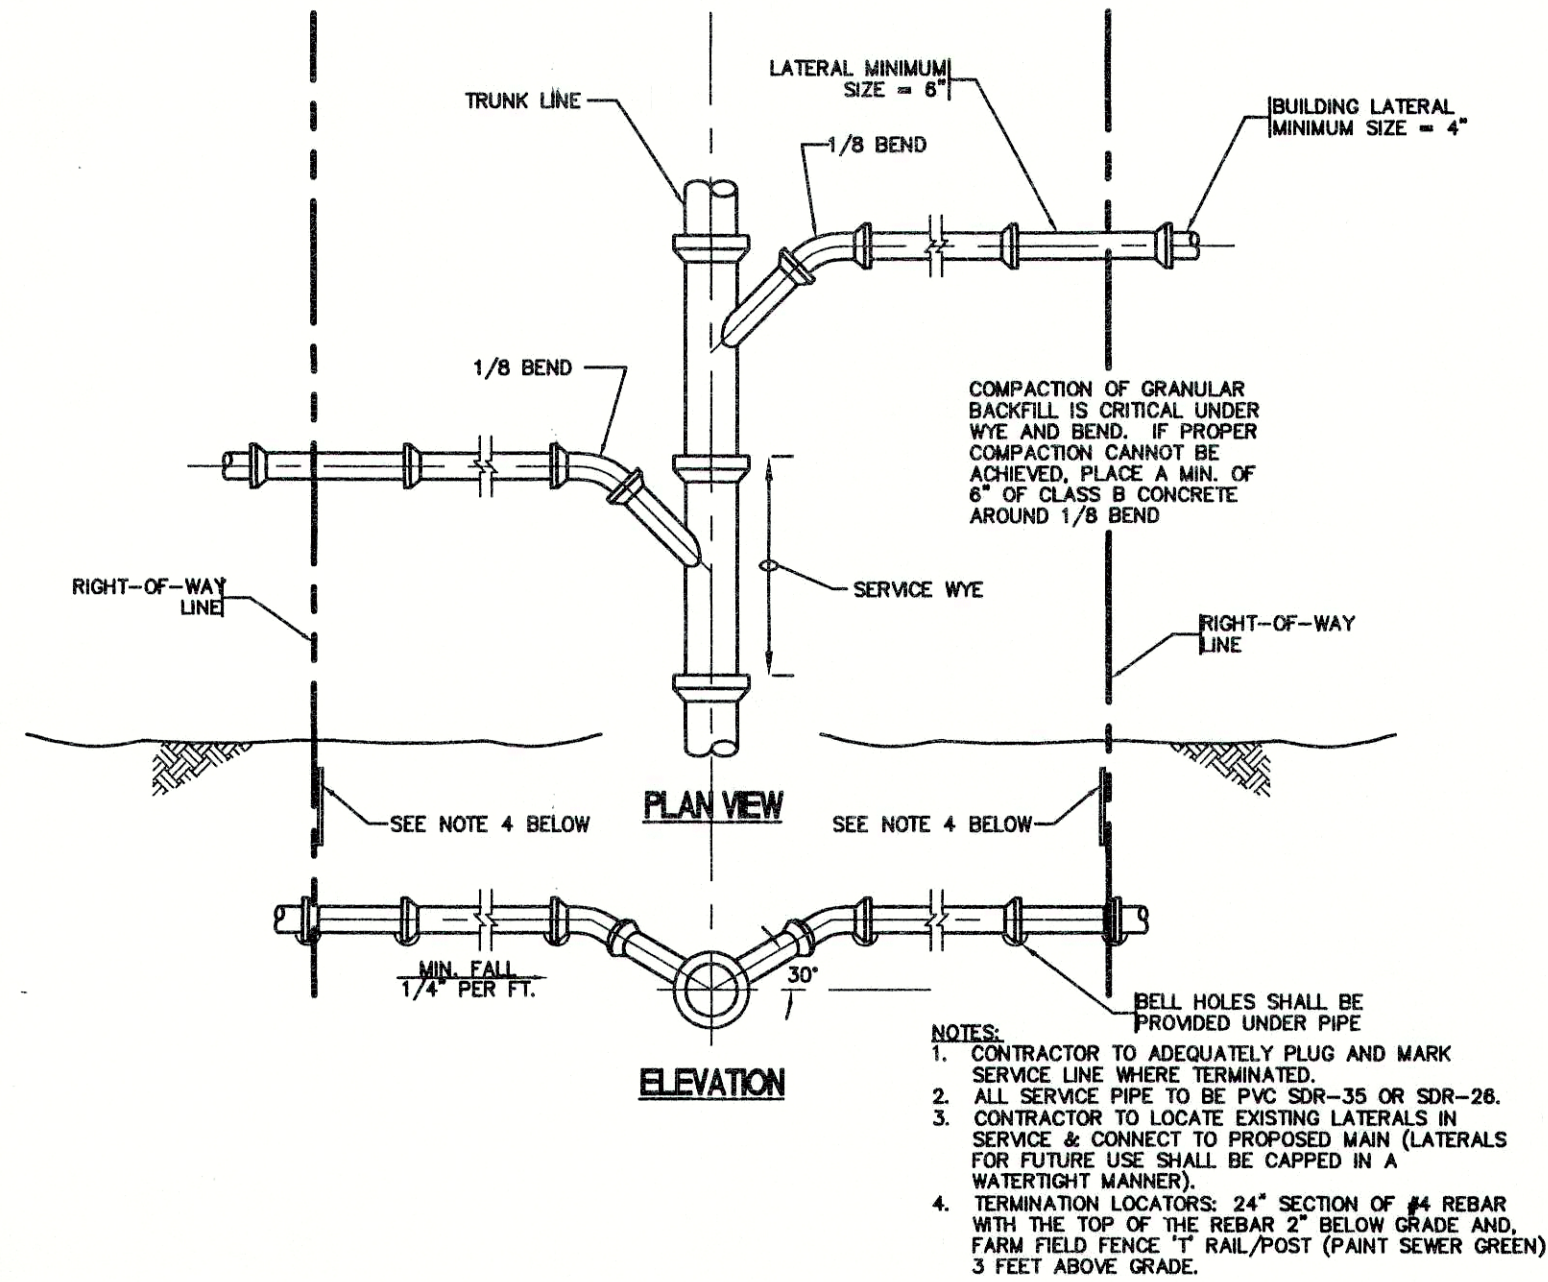


1 SERVICE CONNECTION DETAIL
SCALE: N.T.S.

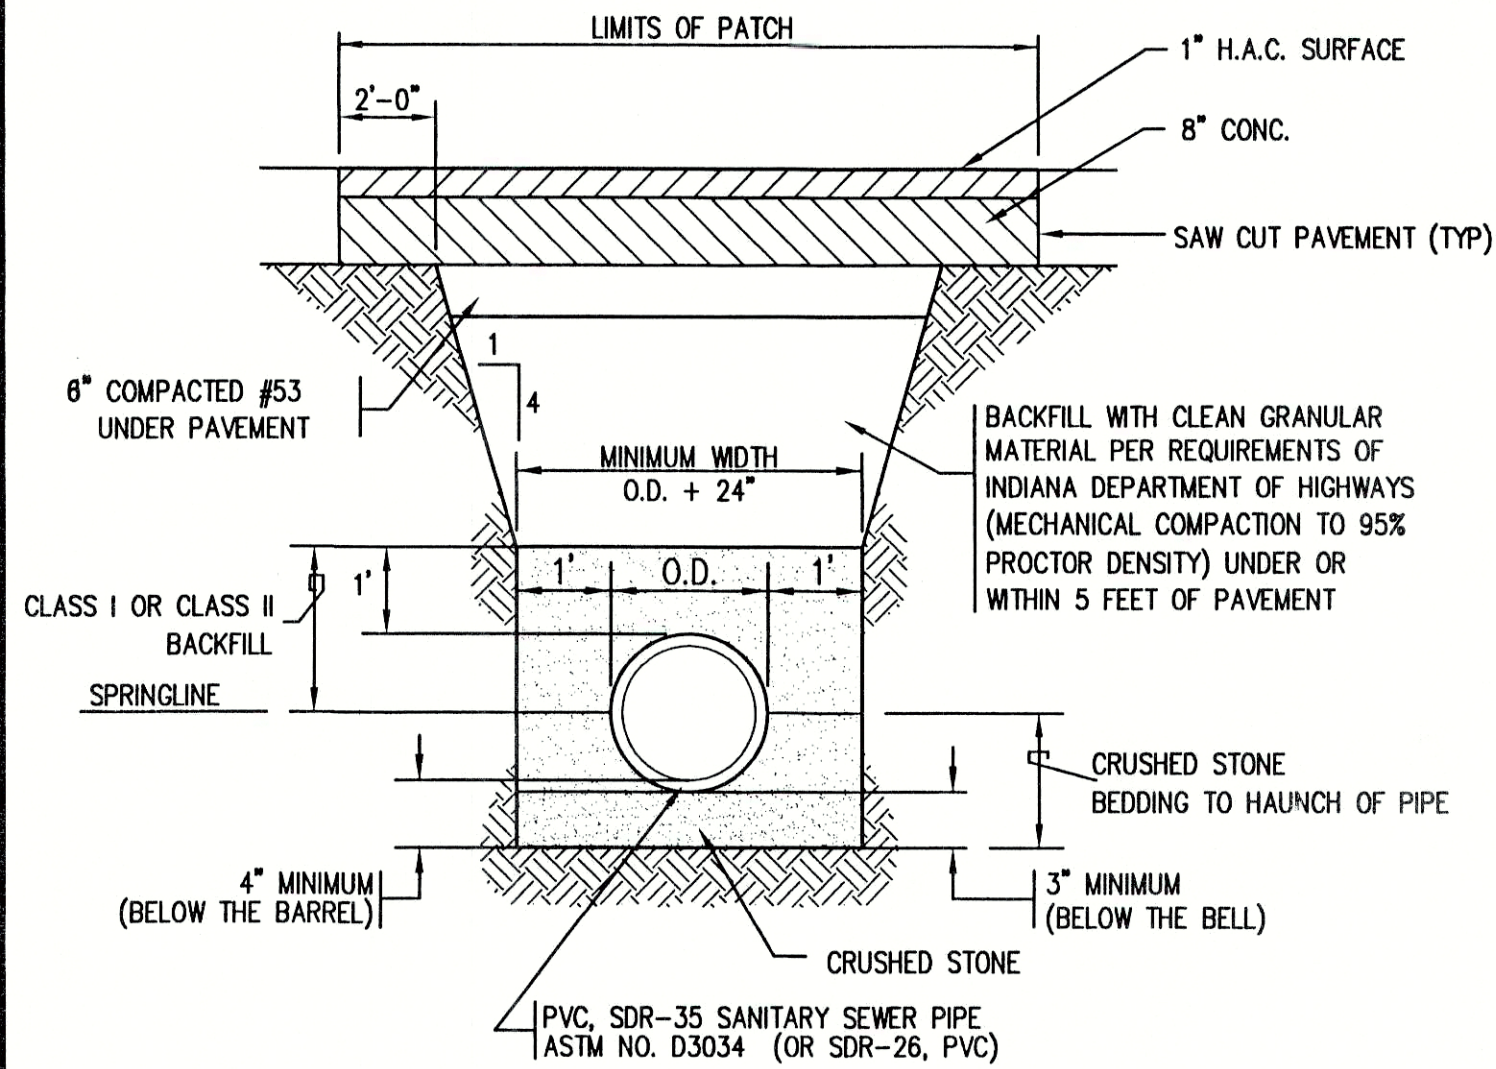

2 TYPICAL TRENCH AND PAVEMENT PATCH DETAIL
SCALE: N.T.S.

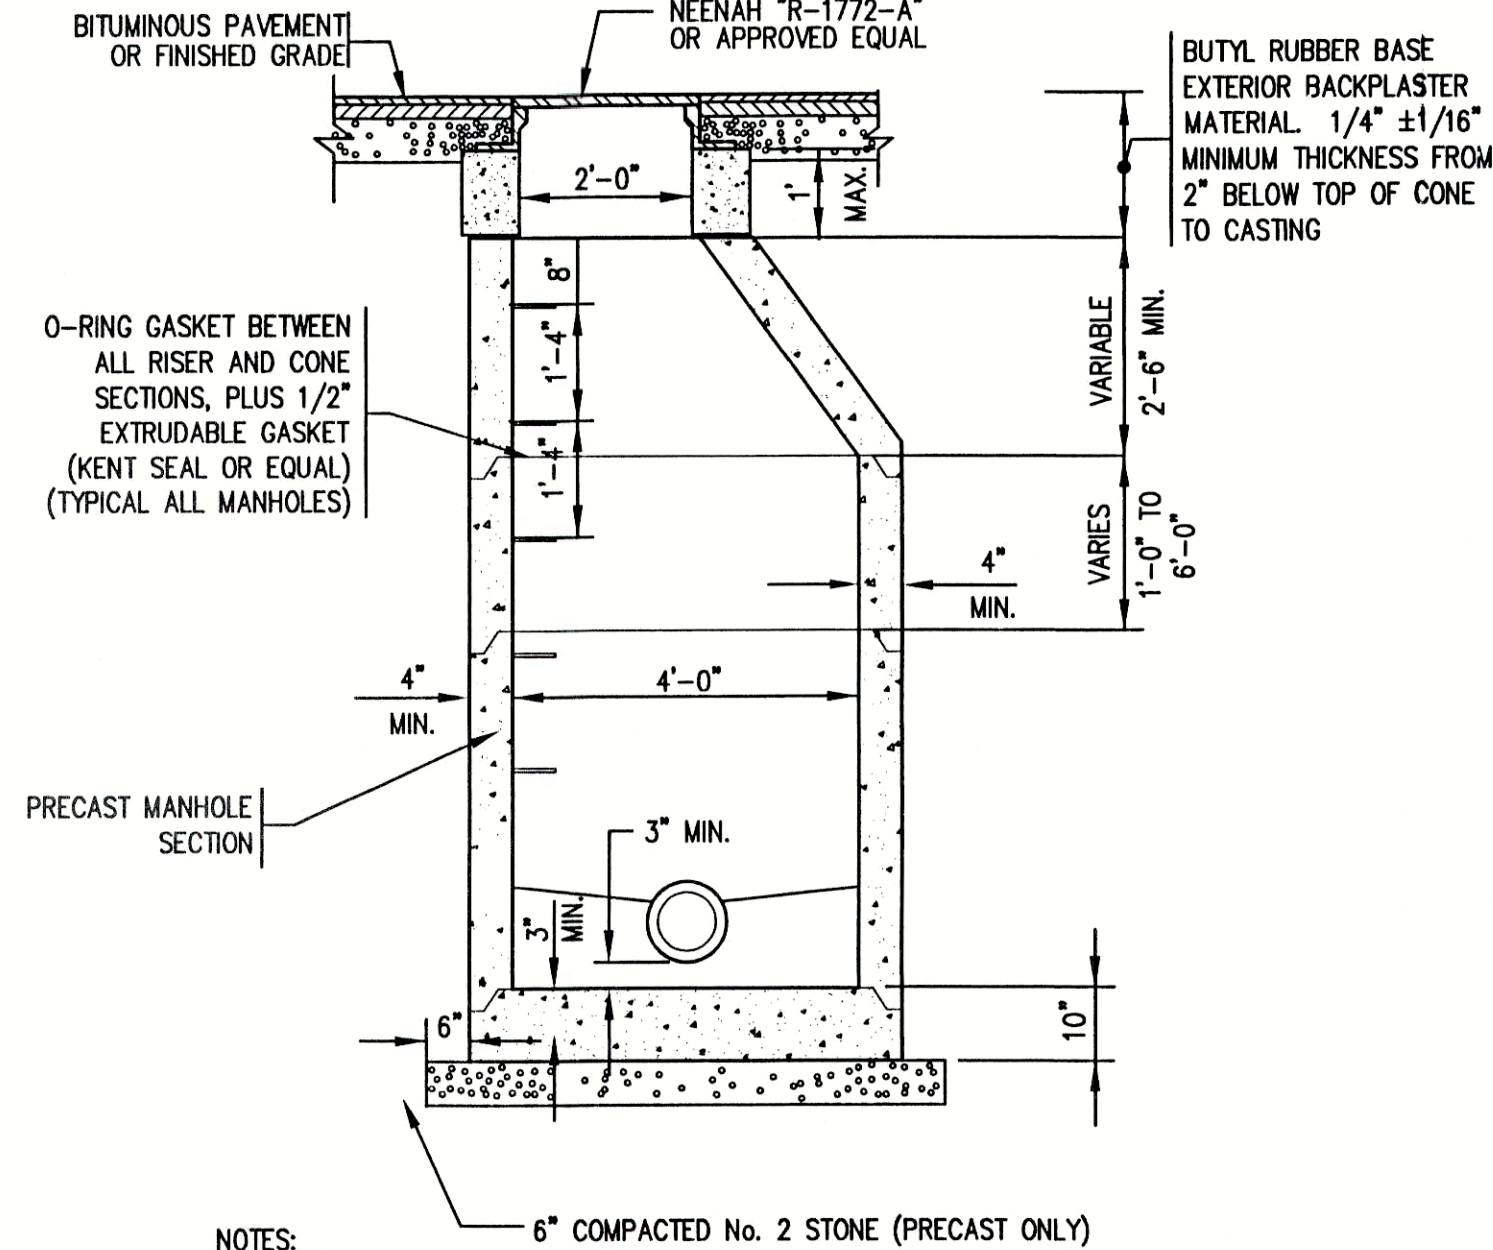


3 SANITARY MANHOLE
SCALE: N.T.S.

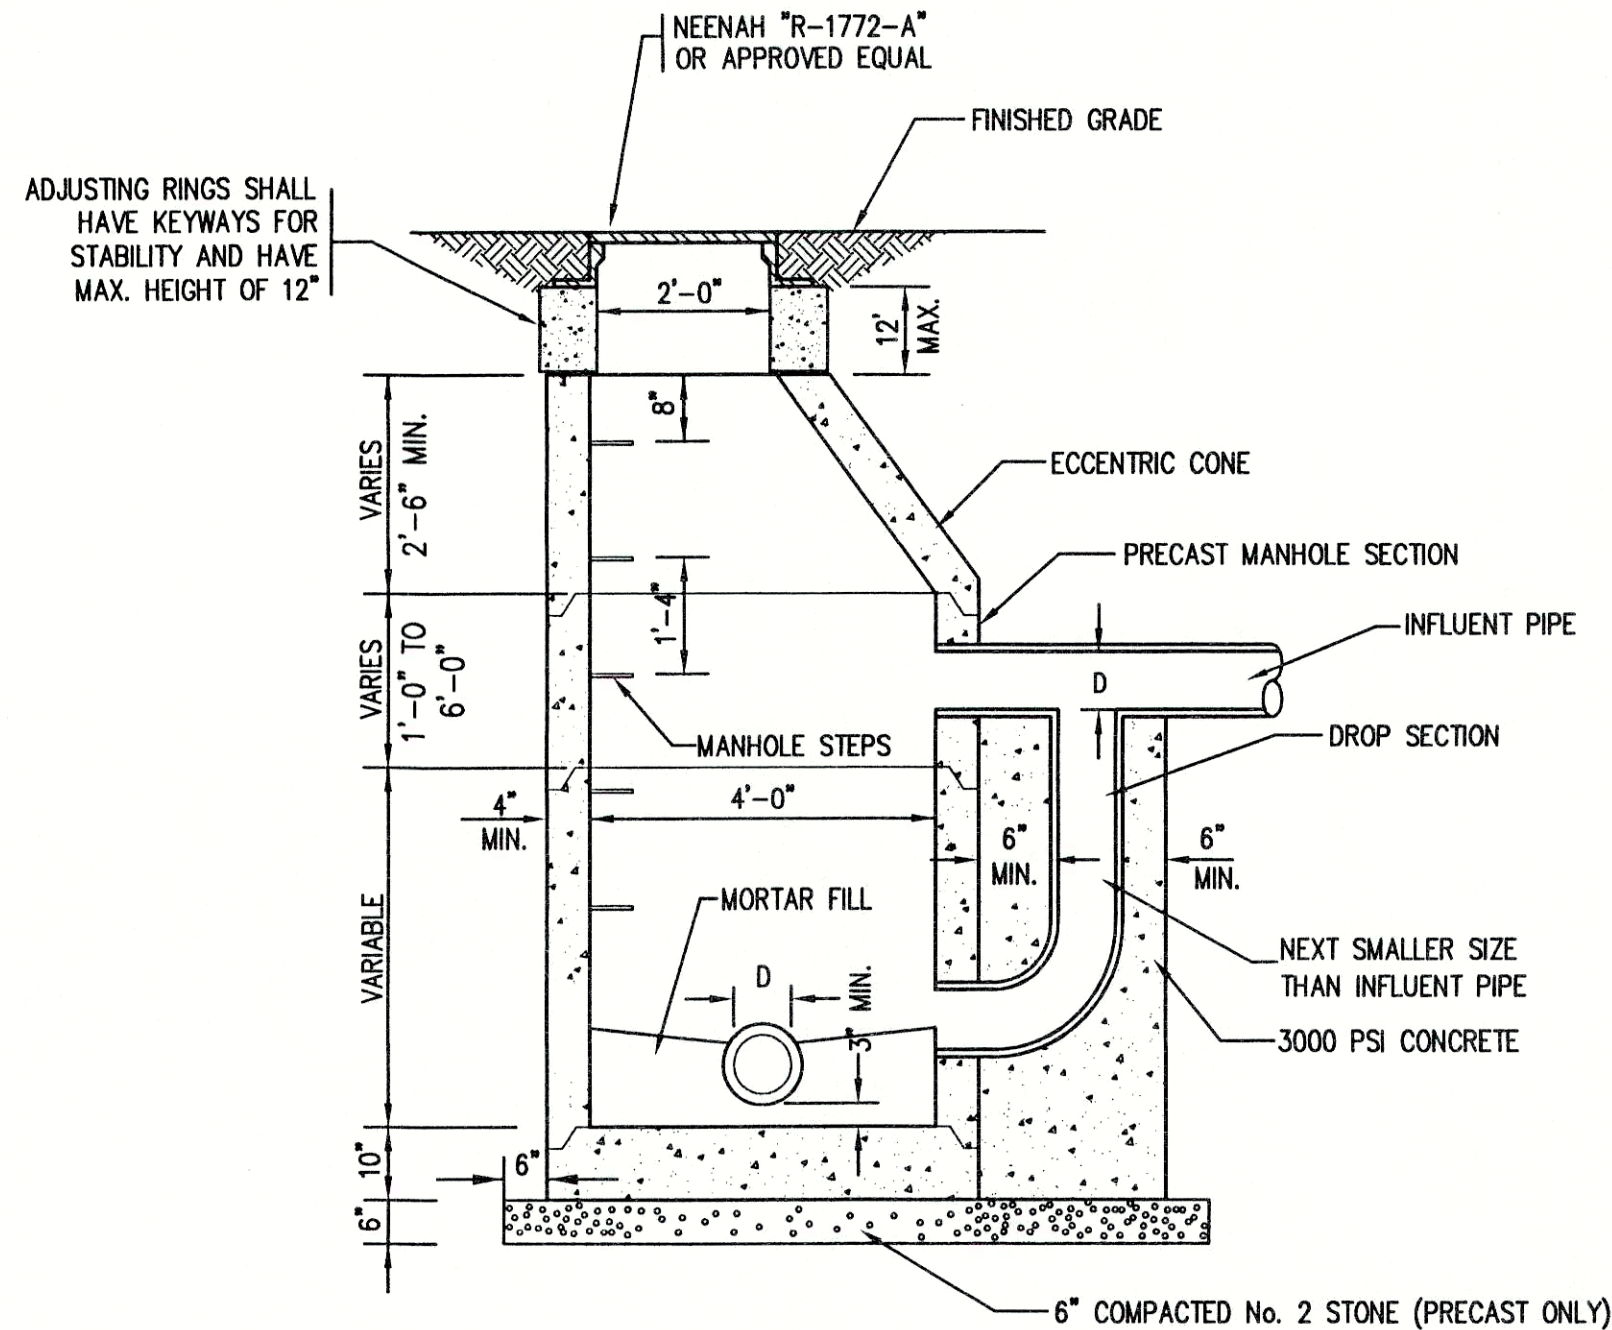


4 DROP MANHOLE
SCALE: N.T.S.

RECORD DRAWING


February 15, 2001

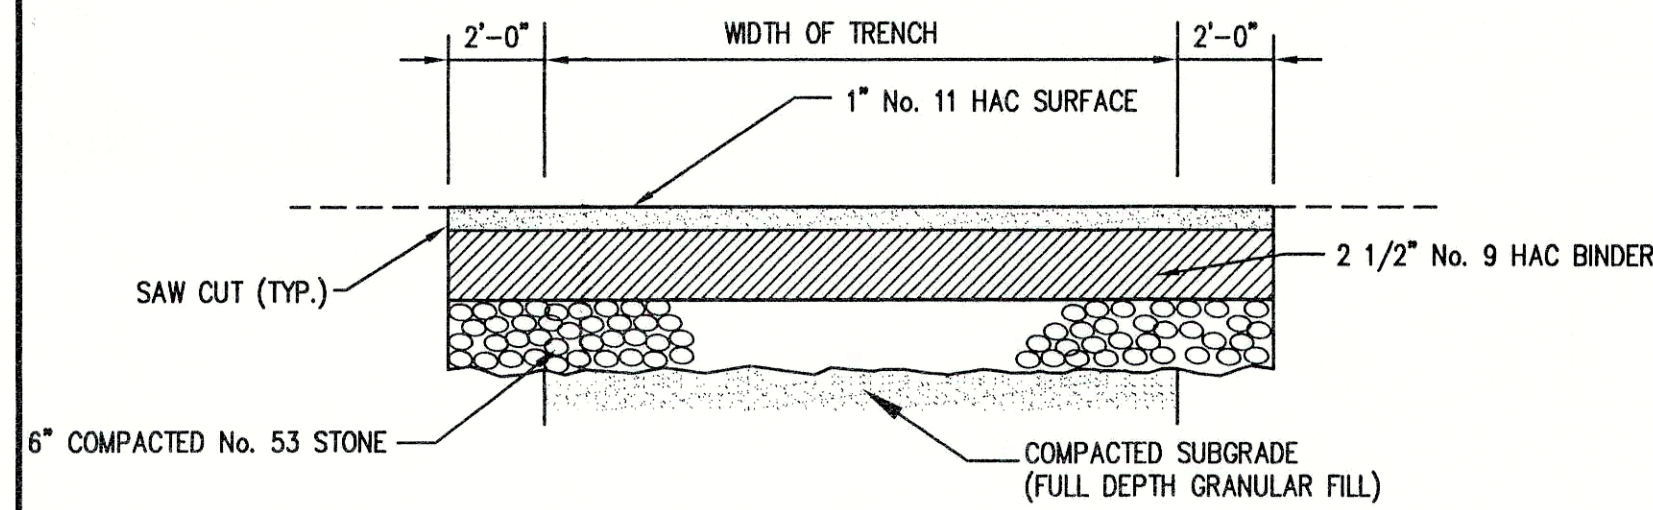


5 ASPHALT DRIVE REPAIR DETAIL
SCALE: N.T.S.

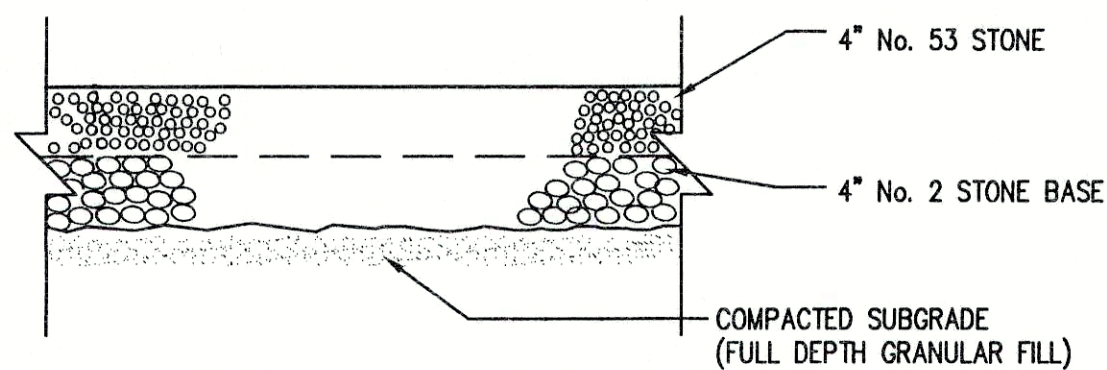


6 STONE DRIVE REPAIR DETAIL
SCALE: N.T.S.

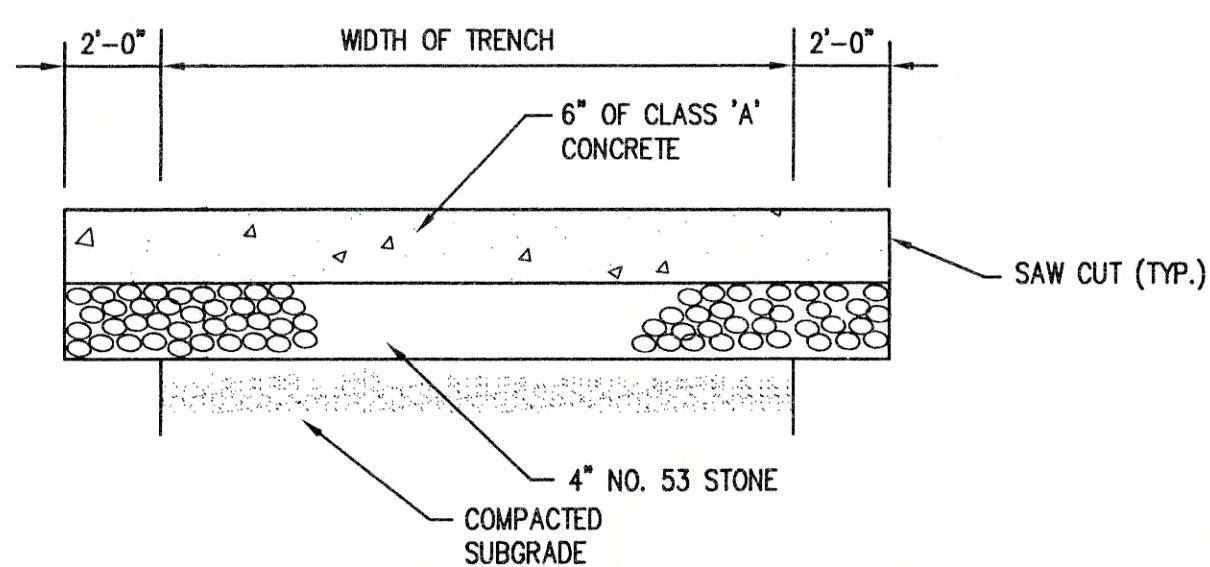


7 CONCRETE DRIVE REPAIR DETAIL
SCALE: N.T.S.

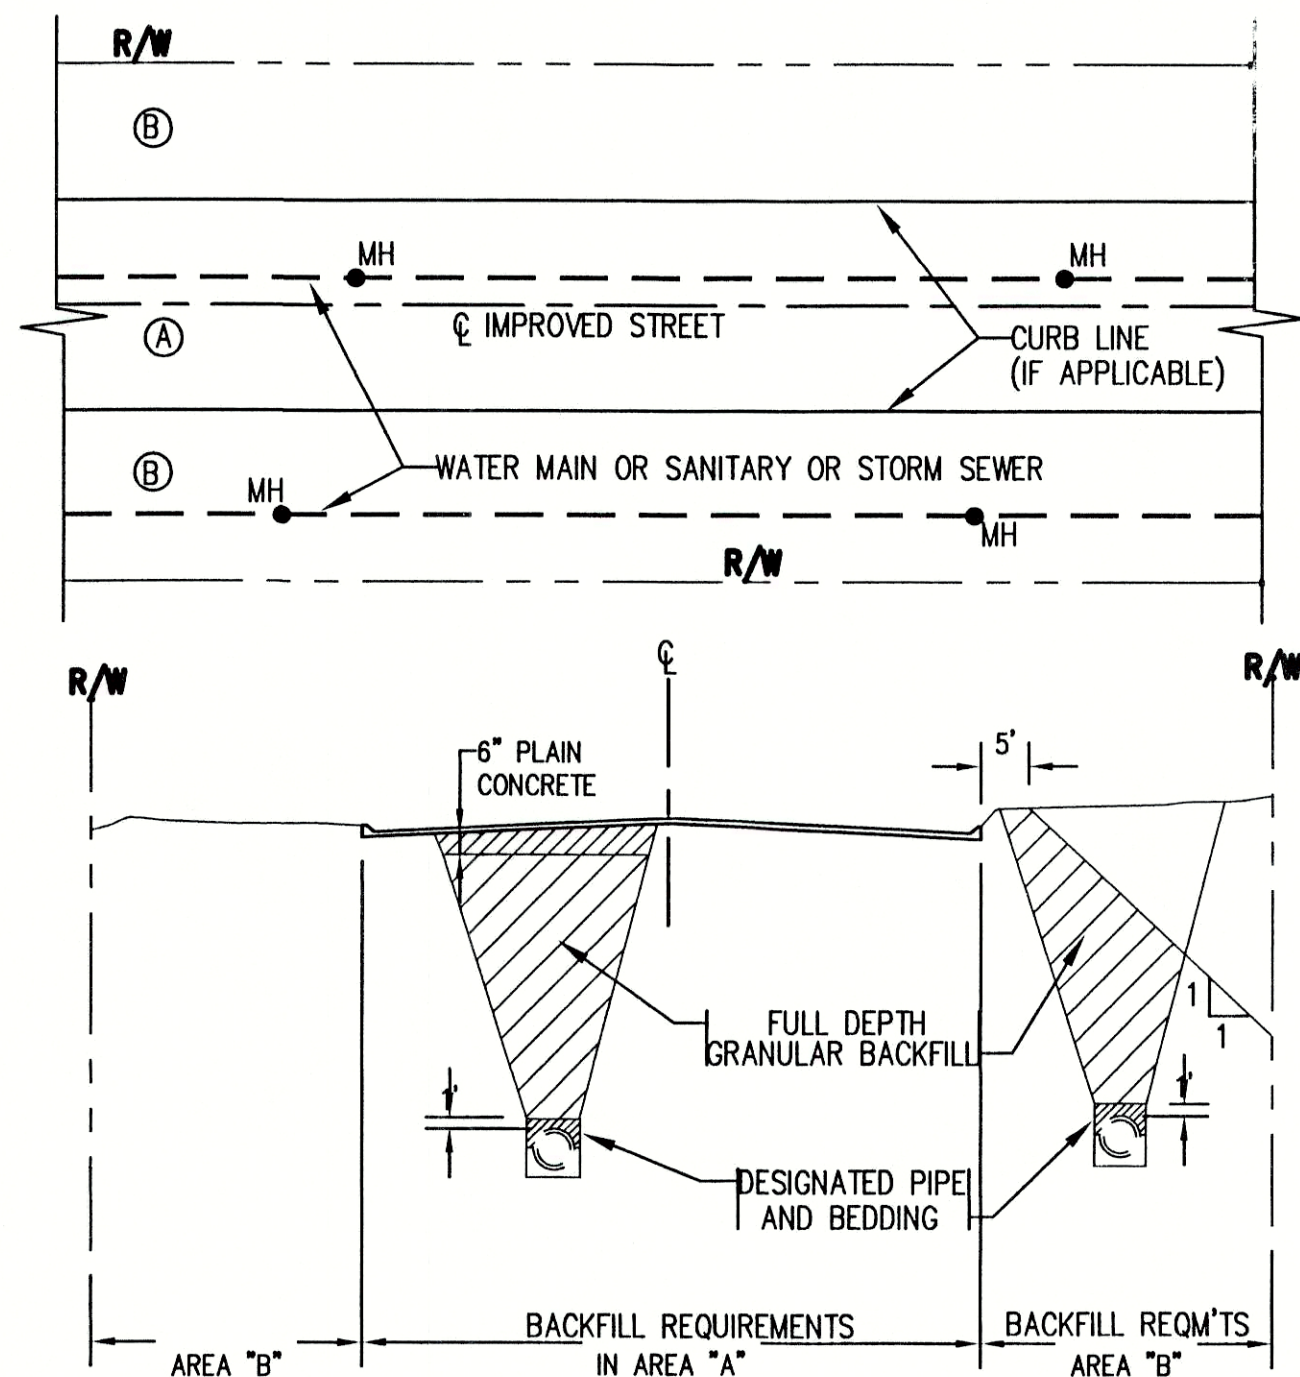

8 BACKFILL REQUIREMENTS
(FOR PIPELINES WITHIN RIGHT-OF-WAY FOR IMPROVED STREETS)

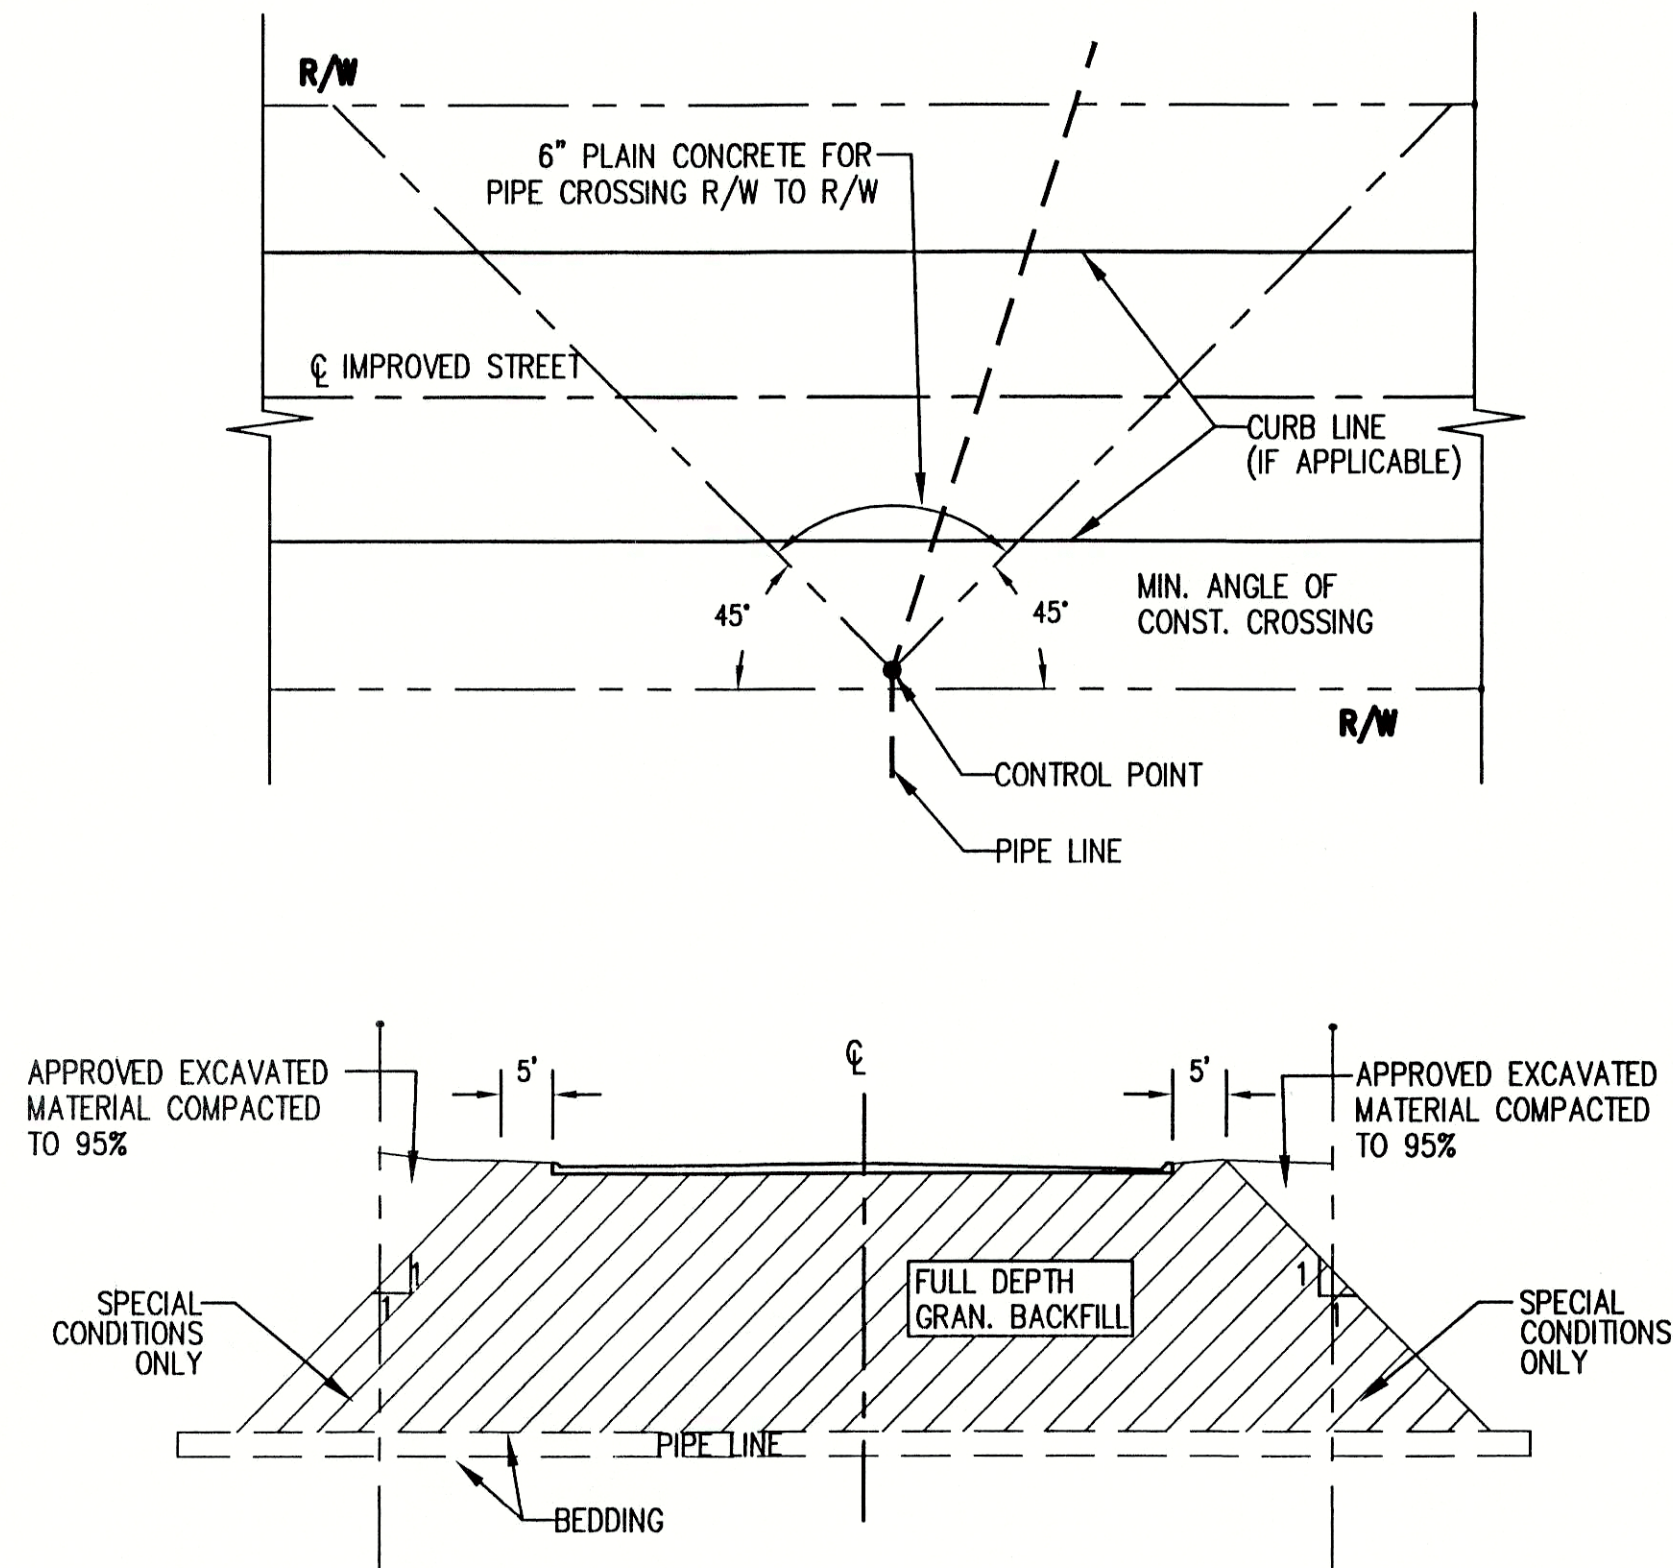

9 BACKFILL REQUIREMENTS
(FOR PIPELINES CROSSING RIGHT-OF-WAY FOR IMPROVED STREETS)

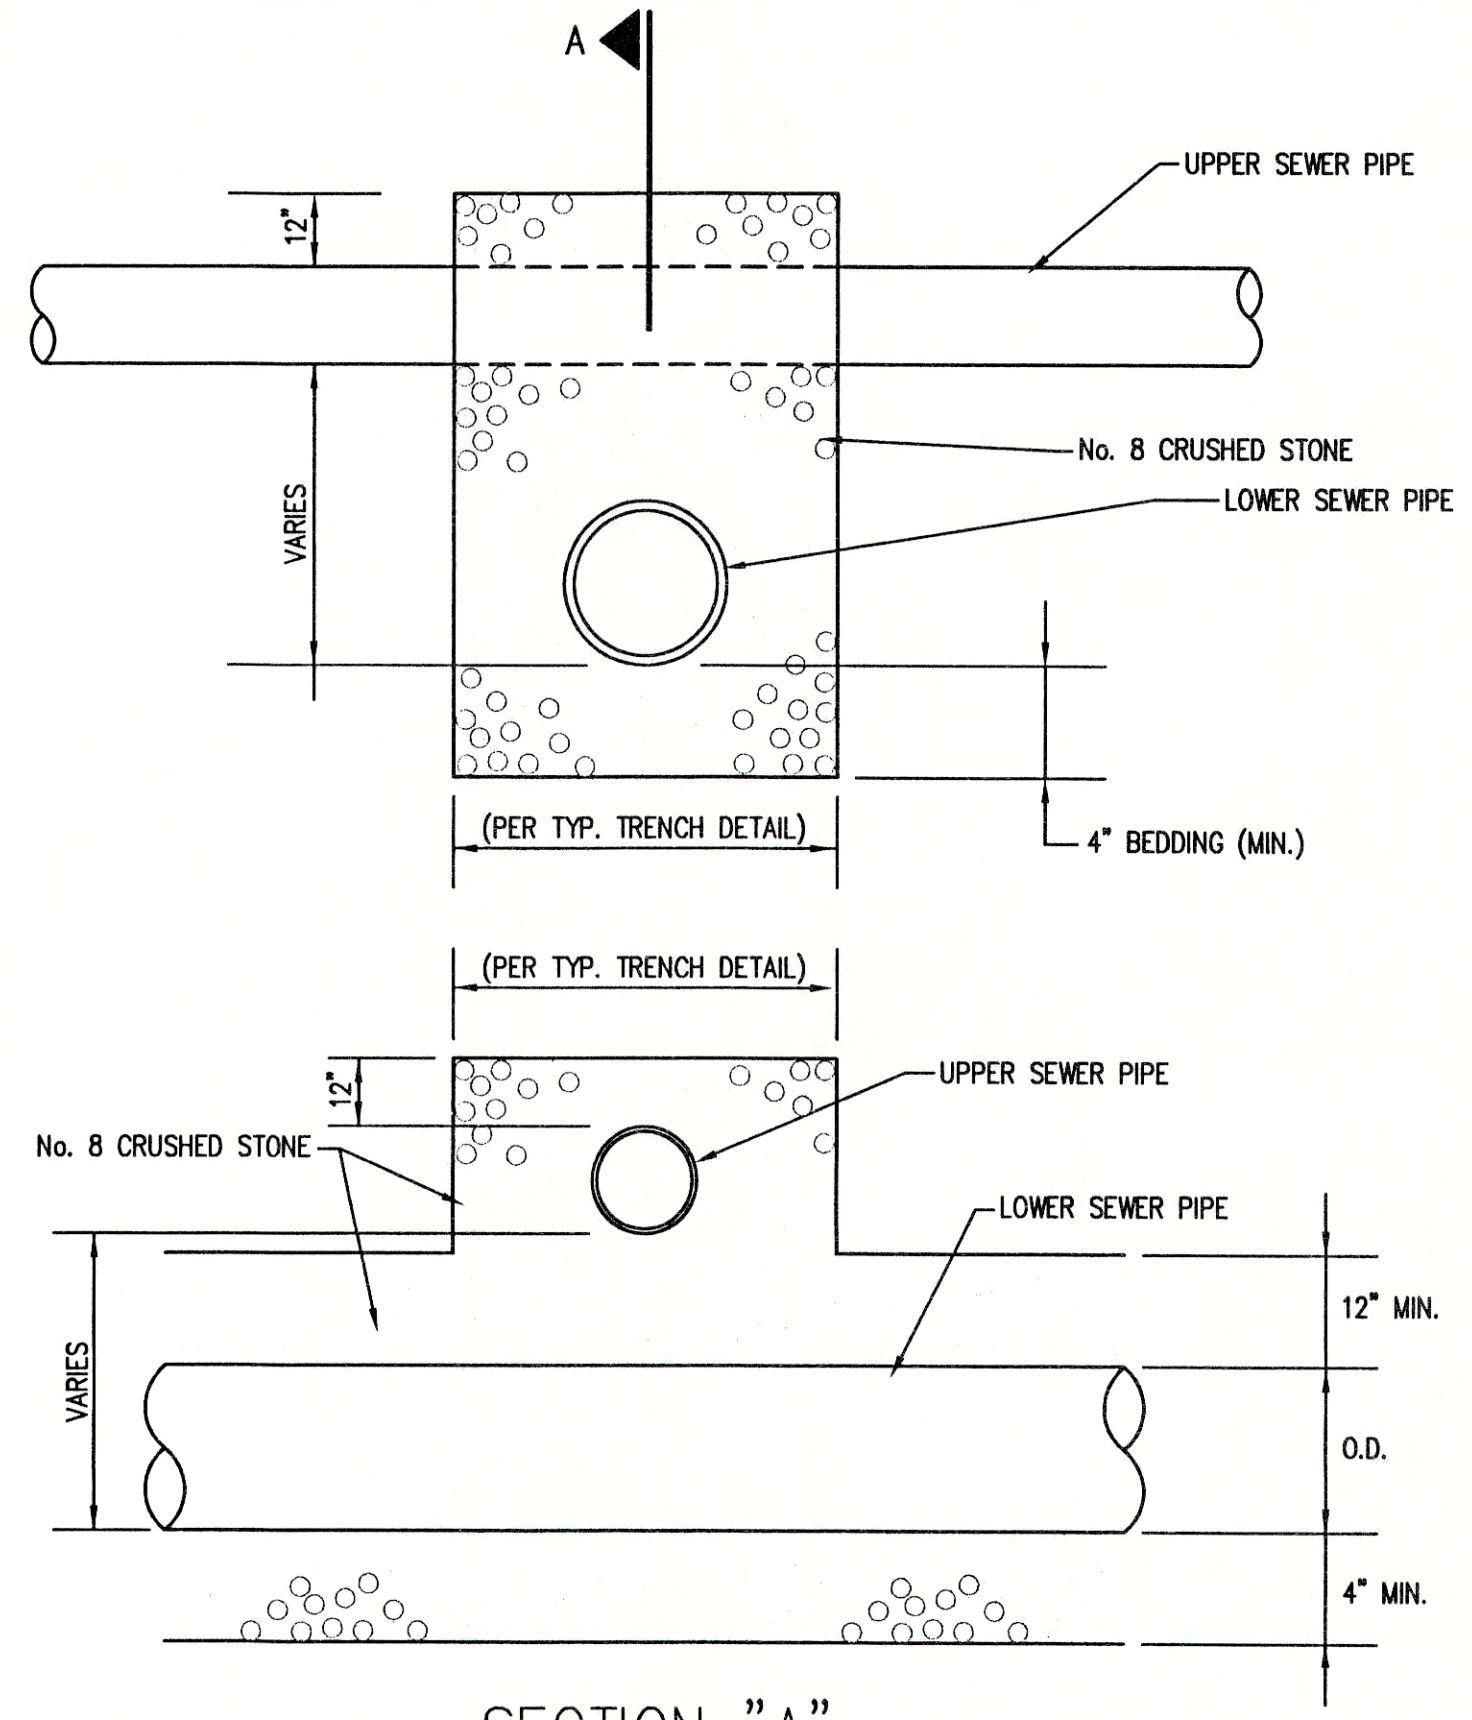

10 STORM SEWER/SANITARY SEWER CROSSING DETAIL
SCALE: N.T.S.



FILE NAME: WHTOK_D1-RD		PLOT SCALE: 1=1	PLOT DATE: 11/15
NO.	DATE	DESCRIPTION	BY

TRIAD ASSOCIATES INC.
INDIANAPOLIS, INDIANA

APPROVED BY
THOMAS M. SCHUBERT
No. 15614
STATE OF INDIANA
PROFESSIONAL ENGINEER
Thomas M. Schubert, P.E.


WHITE OAKS SUBDIVISION
FALL CREEK REGIONAL WASTE DISTRICT
STANDARD SANITARY SEWER DETAILS
DRAWN BY: DATE 04/12/98 PROJECT No. SHEET No.
DAP SCALE AS NOTED 98008A 10
DESIGNED BY: D.A. Pauling
CHECKED BY: James W. Frazell, P.E.
OF 11

RECORD DRAWING
February 15, 2001

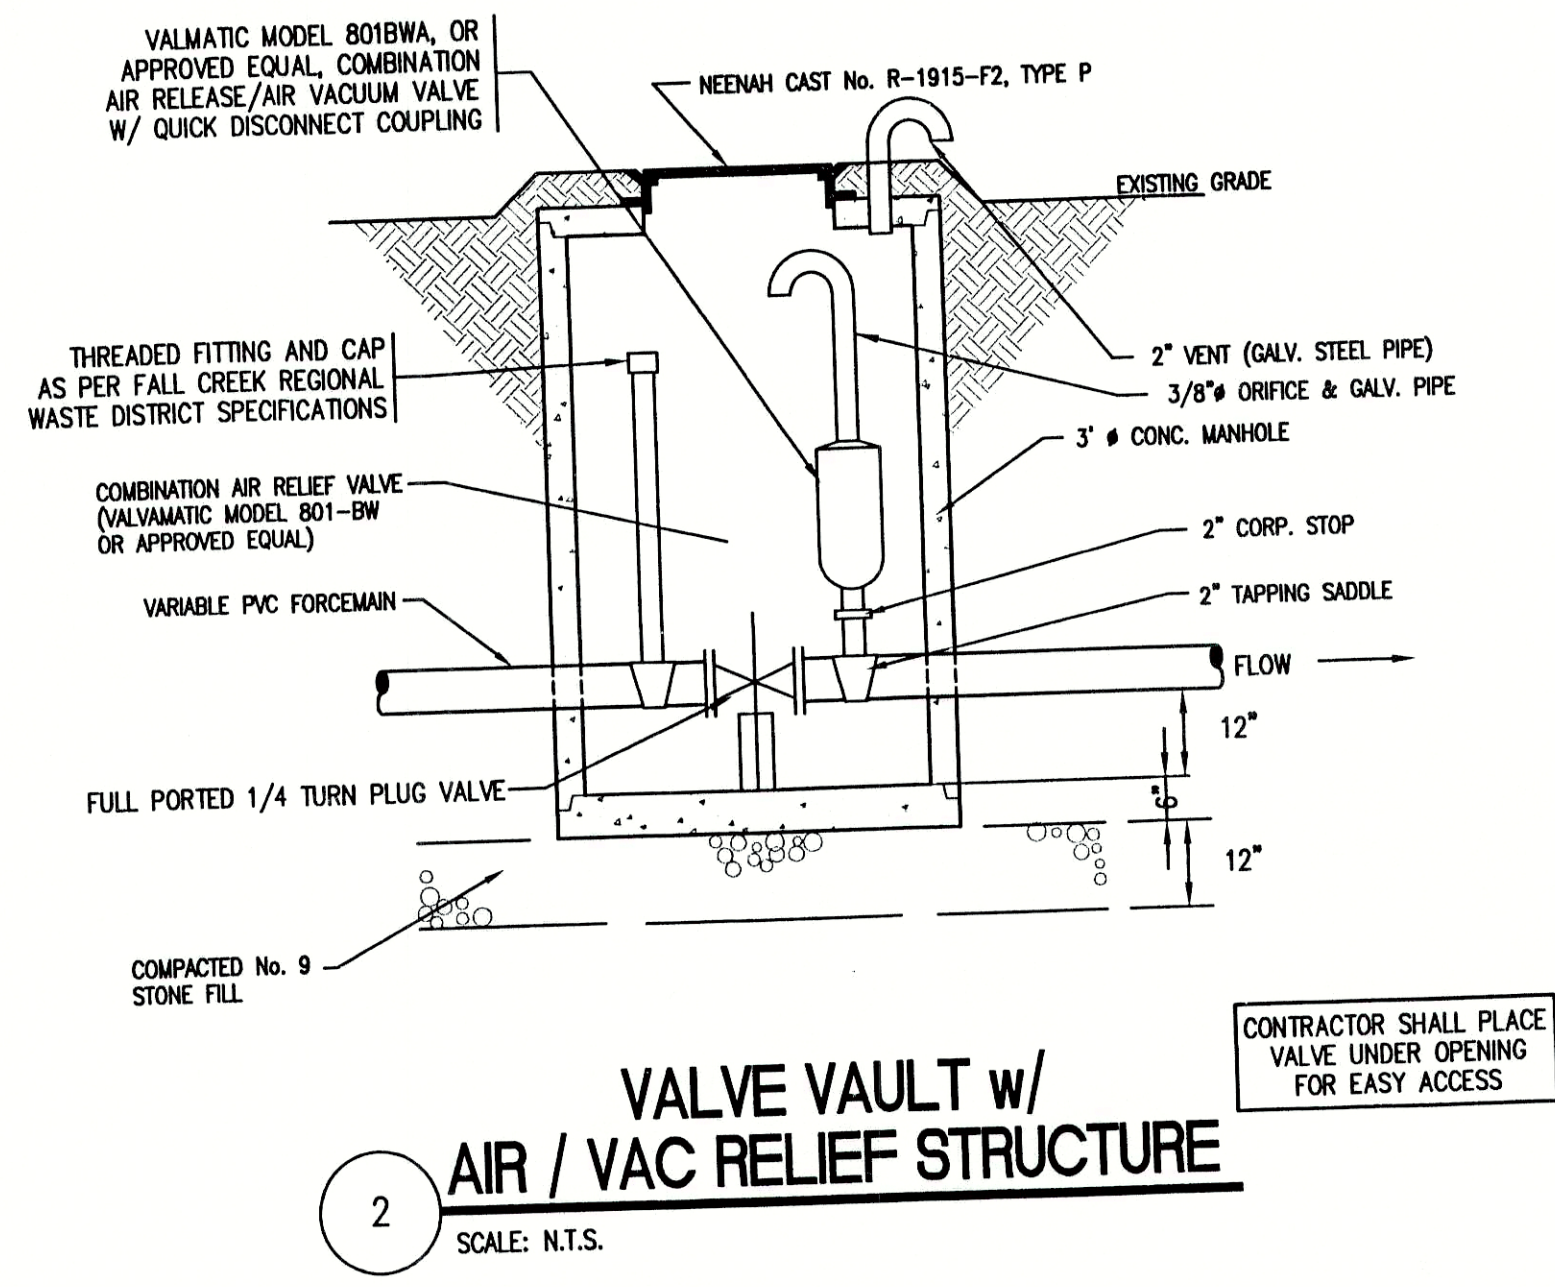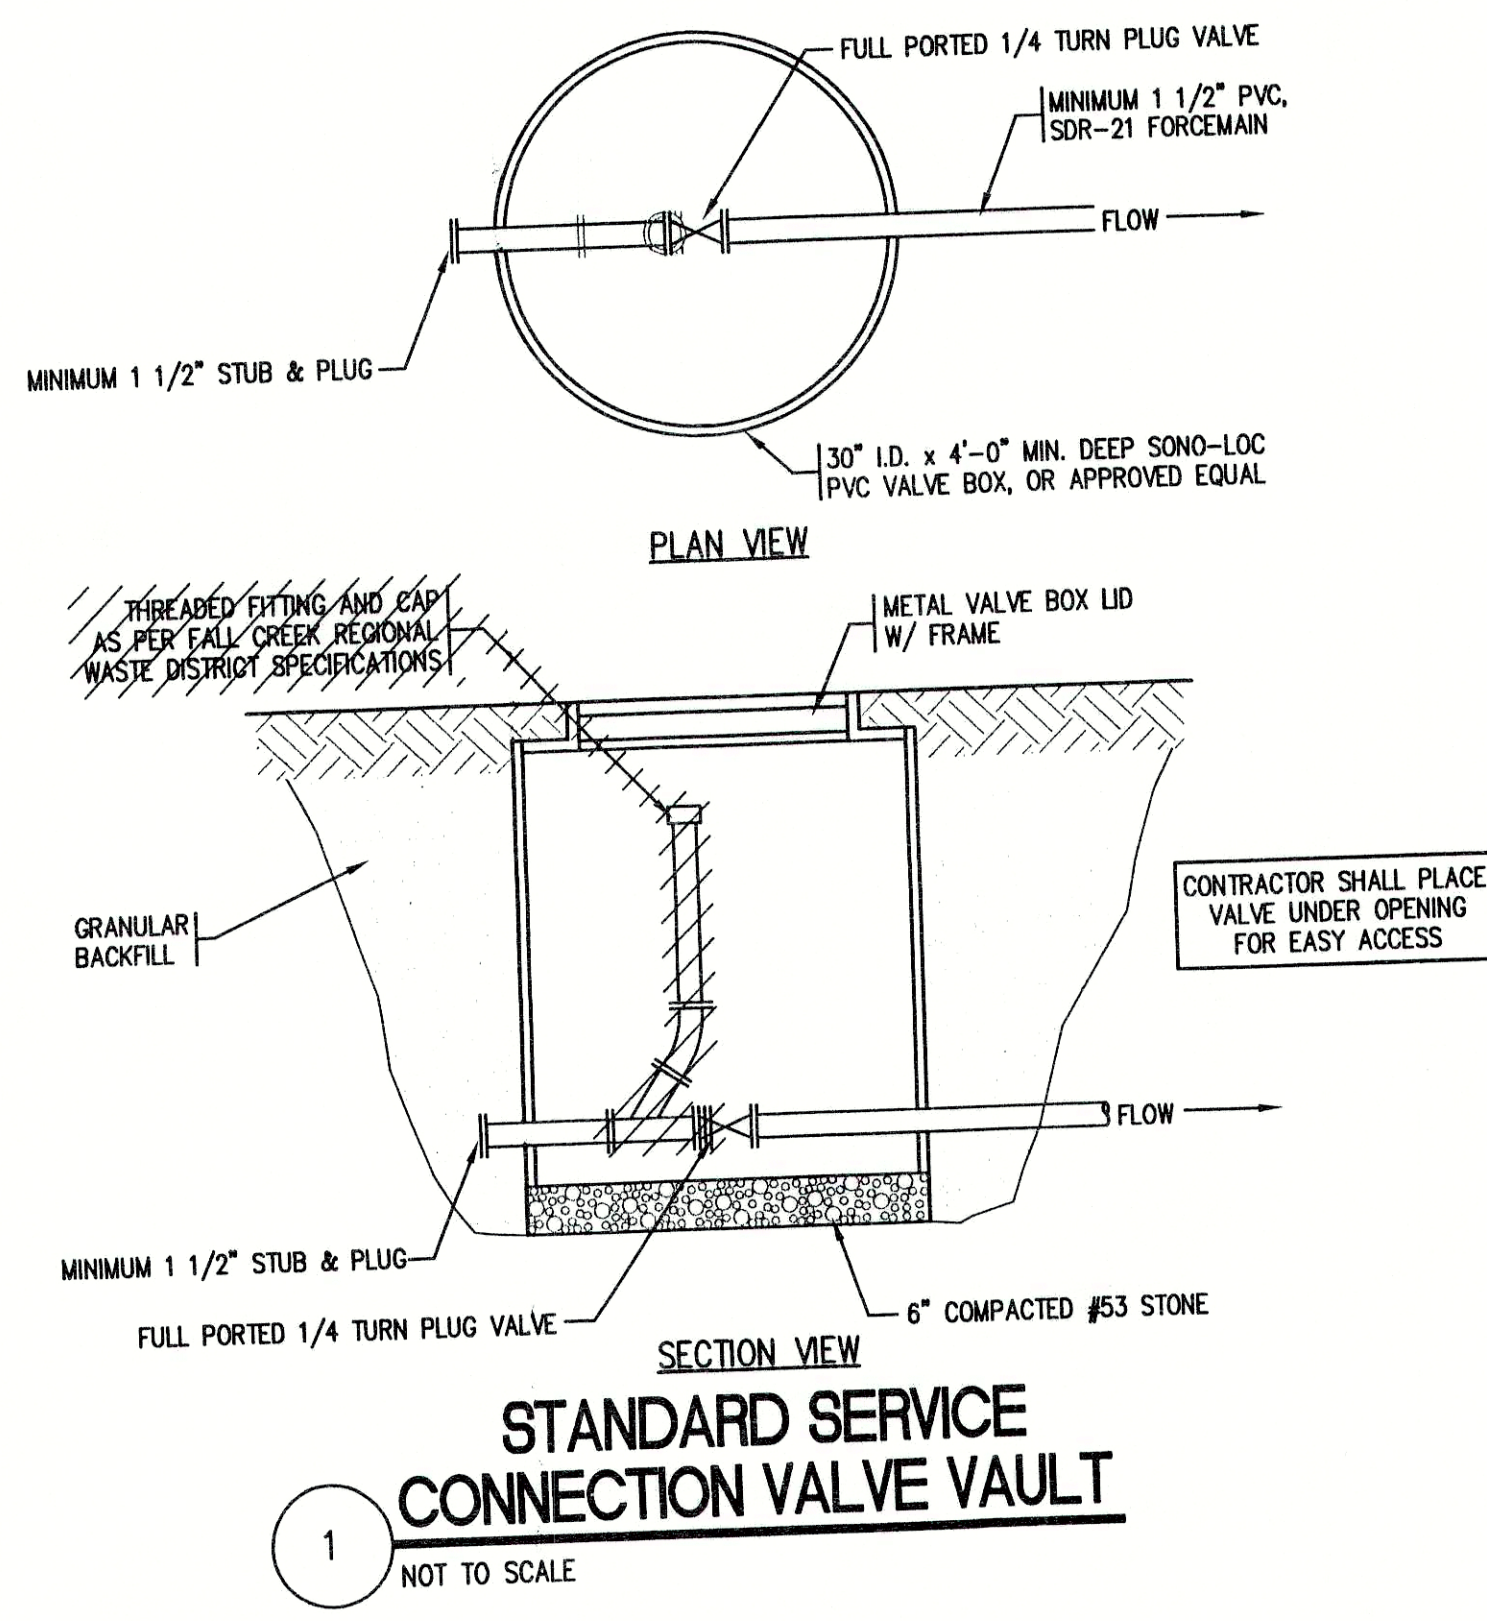

FILE NAME: WHTOK_D2-RD		PLOT SCALE: 1=1	PLOT DATE: 11/15

TRIAD ASSOCIATES INC.
INDIANAPOLIS, INDIANA

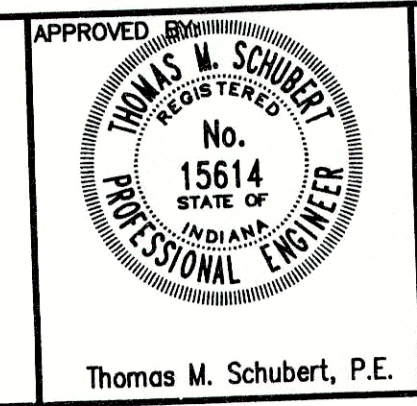

WHITE OAKS SUBDIVISION FALL CREEK REGIONAL WASTE DISTRICT			
STANDARD SANITARY SEWER DETAILS			
DRAWN BY: DAP	DATE: 04/12/96 SCALE: AS NOTED	PROJECT No.: 98008A	SHEET No.: 11 OF 11
DESIGNED BY: D.A. Pauling		CHECKED BY: James W. Frazell, P.E.	