

WOODED RIDGE ADDITION SANITARY SEWER PROJECT

FOR THE FALL CREEK REGIONAL WASTE DISTRICT MADISON CO., IN.

1999

SRF PROJECT NO. CS 18207701


DIVISION II

CONTRACT 'A-2'

JOE ROWLETT - GENERAL MANAGER


SHEET INDEX

SHEET NO.	DESCRIPTION
1	TITLE SHEET AND INDEX
2	PROJECT BASE MAPS
3-15	PLAN AND PROFILES SHEETS
16	LIFT STATION DETAIL
17-18	STANDARD SANITARY DETAILS

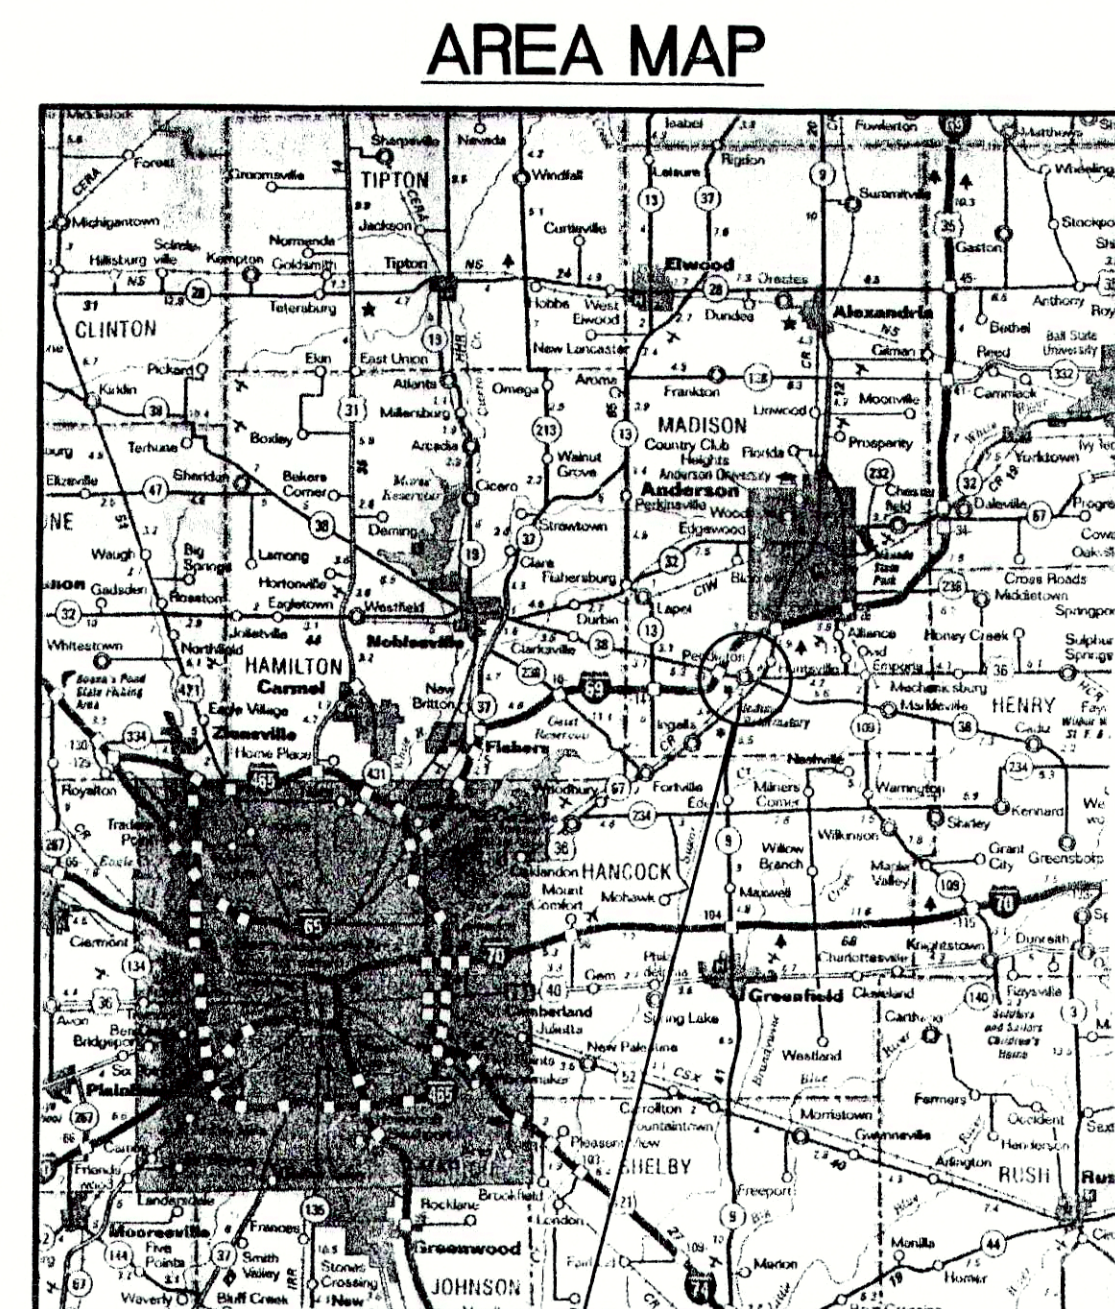

AREA
LOCATION

LOCATION MAP

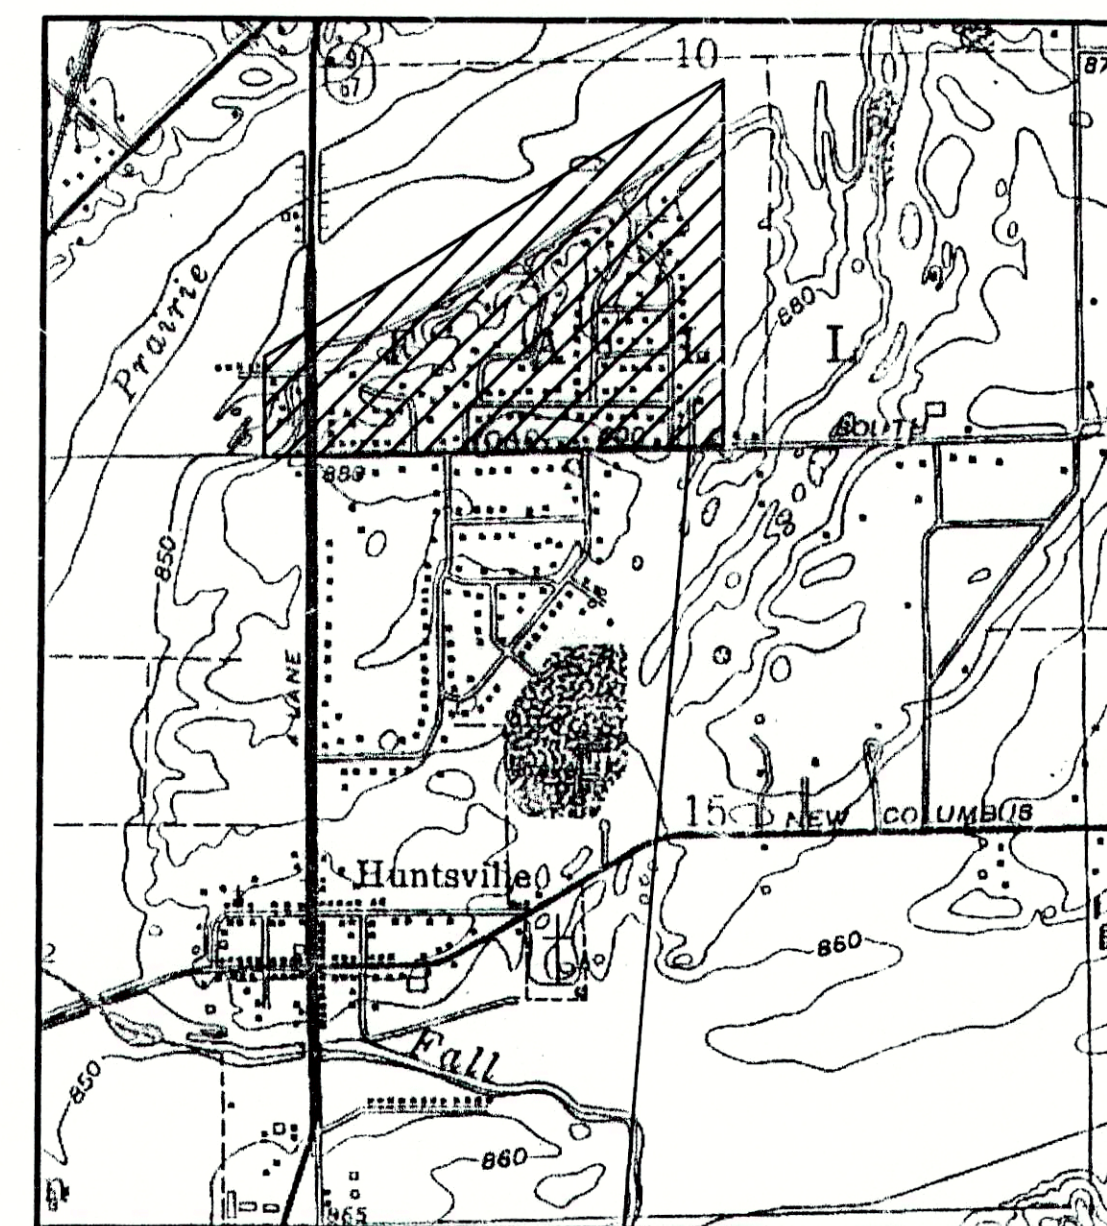

PROJECT
LOCATION

FALL CREEK REGIONAL WASTE DISTRICT BOARD

Mr. William Clark - President
Mr. Morris McCurdy - Member
Mr. Doug McGee - Member
Mr. Mark Jablonski - Member
Mr. Agon Tolbert - Member
Mr. Dallas Foster - Member
Mr. Jack Kasdorf - Member
Mr. Timothy Green - Member
Mr. John Ellingwood - Member
Mr. Joe Rowlett - General Manager

ATTORNEY

Mr. Randall Sorrell

PLANS PREPARED BY:

TRIAD
ASSOCIATES
INC.
INDIANAPOLIS, INDIANA

NOTE:
ADDITIONAL RIGHT-OF-WAY OR EASEMENTS MAY
NEED TO BE ACQUIRED FOR INSTALLATION OF SEWER.



DON'T DIG BLIND
CALL BEFORE YOU DIG
STATE OF INDIANA
1-800-382-5544
OTHER STATES
1-800-428-5200

PER INDIANA STATE L.I.W. 15-69-1991, IT IS
AGAINST THE LAW TO EXCAVATE WITHOUT
NOTIFYING THE UNDERGROUND LOCATION SERVICE
TWO (2) WORKING DAYS BEFORE COMMENCING WORK.
NOTE: CONTRACTOR TO VERIFY ALL UTILITY LOCATIONS
PRIOR TO THE START OF CONSTRUCTION


THESE PLANS CERTIFIED BY:

James W. Frazell, Professional Engineer

RECORD DRAWING

February 15, 2001

Thomas M. Schubert, Professional Engineer

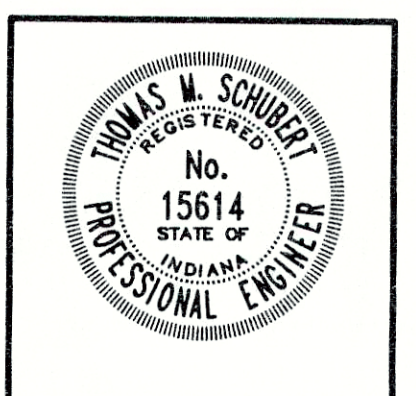

STRUCTURE No. WR-057

MATCH LINE - SEE BOTTOM RIGHT

STRUCTURE No. WR-056

STRUCTURE No. WR-055

STRUCTURE No. WR-054

STRUCTURE No. WR-053

STRUCTURE No. WR-052

STRUCTURE No. WR-051

TBM INFORMATION

WO-TBM #1 - FIRE HYDRANT IN FRONT OF LACO IN HUNTSVILLE
FIRE HYDRANT BOLT UNDER LETTER "Y"
IN KENNEDY ELEV. - 871.16

WR-TBM #1a - NORTHWEST CORNER OF HEADWALL AT THE NORTH
SIDE OF THE ROAD AT RIDGE LANE AND
STATE ROAD No. 9 ELEV. - 851.81

WR-TBM #2 - NORTHWEST CORNER OF WINGWALL AT
DOUGLASS AVENUE AND RIDGE LANE
ELEV. - 855.35

UTILITIES

ANDERSON LIGHT AND POWER
550 BAXTER ROAD
ANDERSON, INDIANA 46016
1 (765) 648-6187

CYNERGY/PSI
100 S. MILL CREEK ROAD
NOBLESVILLE, INDIANA 46060
1 (800) 521-2232

PENDLETON MUNICIPAL WATER UTILITY
P.O. BOX 230
PENDLETON, INDIANA 46064
1 (765) 778-2173

GTE
P.O. BOX 1406
RICHMOND, INDIANA 47375
1 (800) 483-5600

INDIANA GAS COMPANY, INC.
2001 LOUISE STREET
ANDERSON, INDIANA 46016
1 (800) 777-2060

TCI OF CENTRAL INDIANA
335 E. 10th STREET
ANDERSON, INDIANA 46016
1 (765) 649-0407

LEGEND

4 - SHEET DESIGNATION

NOTE:


ADDITIONAL RIGHT-OF-WAY OR EASEMENTS MAY
NEED TO BE ACQUIRED FOR INSTALLATION OF SEWER.



DON'T DIG BLIND
CALL BEFORE YOU DIG
800-382-5544
1-800-428-5200

PER INDIANA STATE LAW IS-69-1991, IT IS
AGAINST THE LAW TO EXCAVATE WITHOUT
NOTIFYING THE UNDERGROUND LOCATION SERVICE
TWO (2) WORKING DAYS BEFORE COMMENCING WORK.

NOTE: CONTRACTOR TO VERIFY ALL UTILITY LOCATIONS
PRIOR TO THE START OF CONSTRUCTION

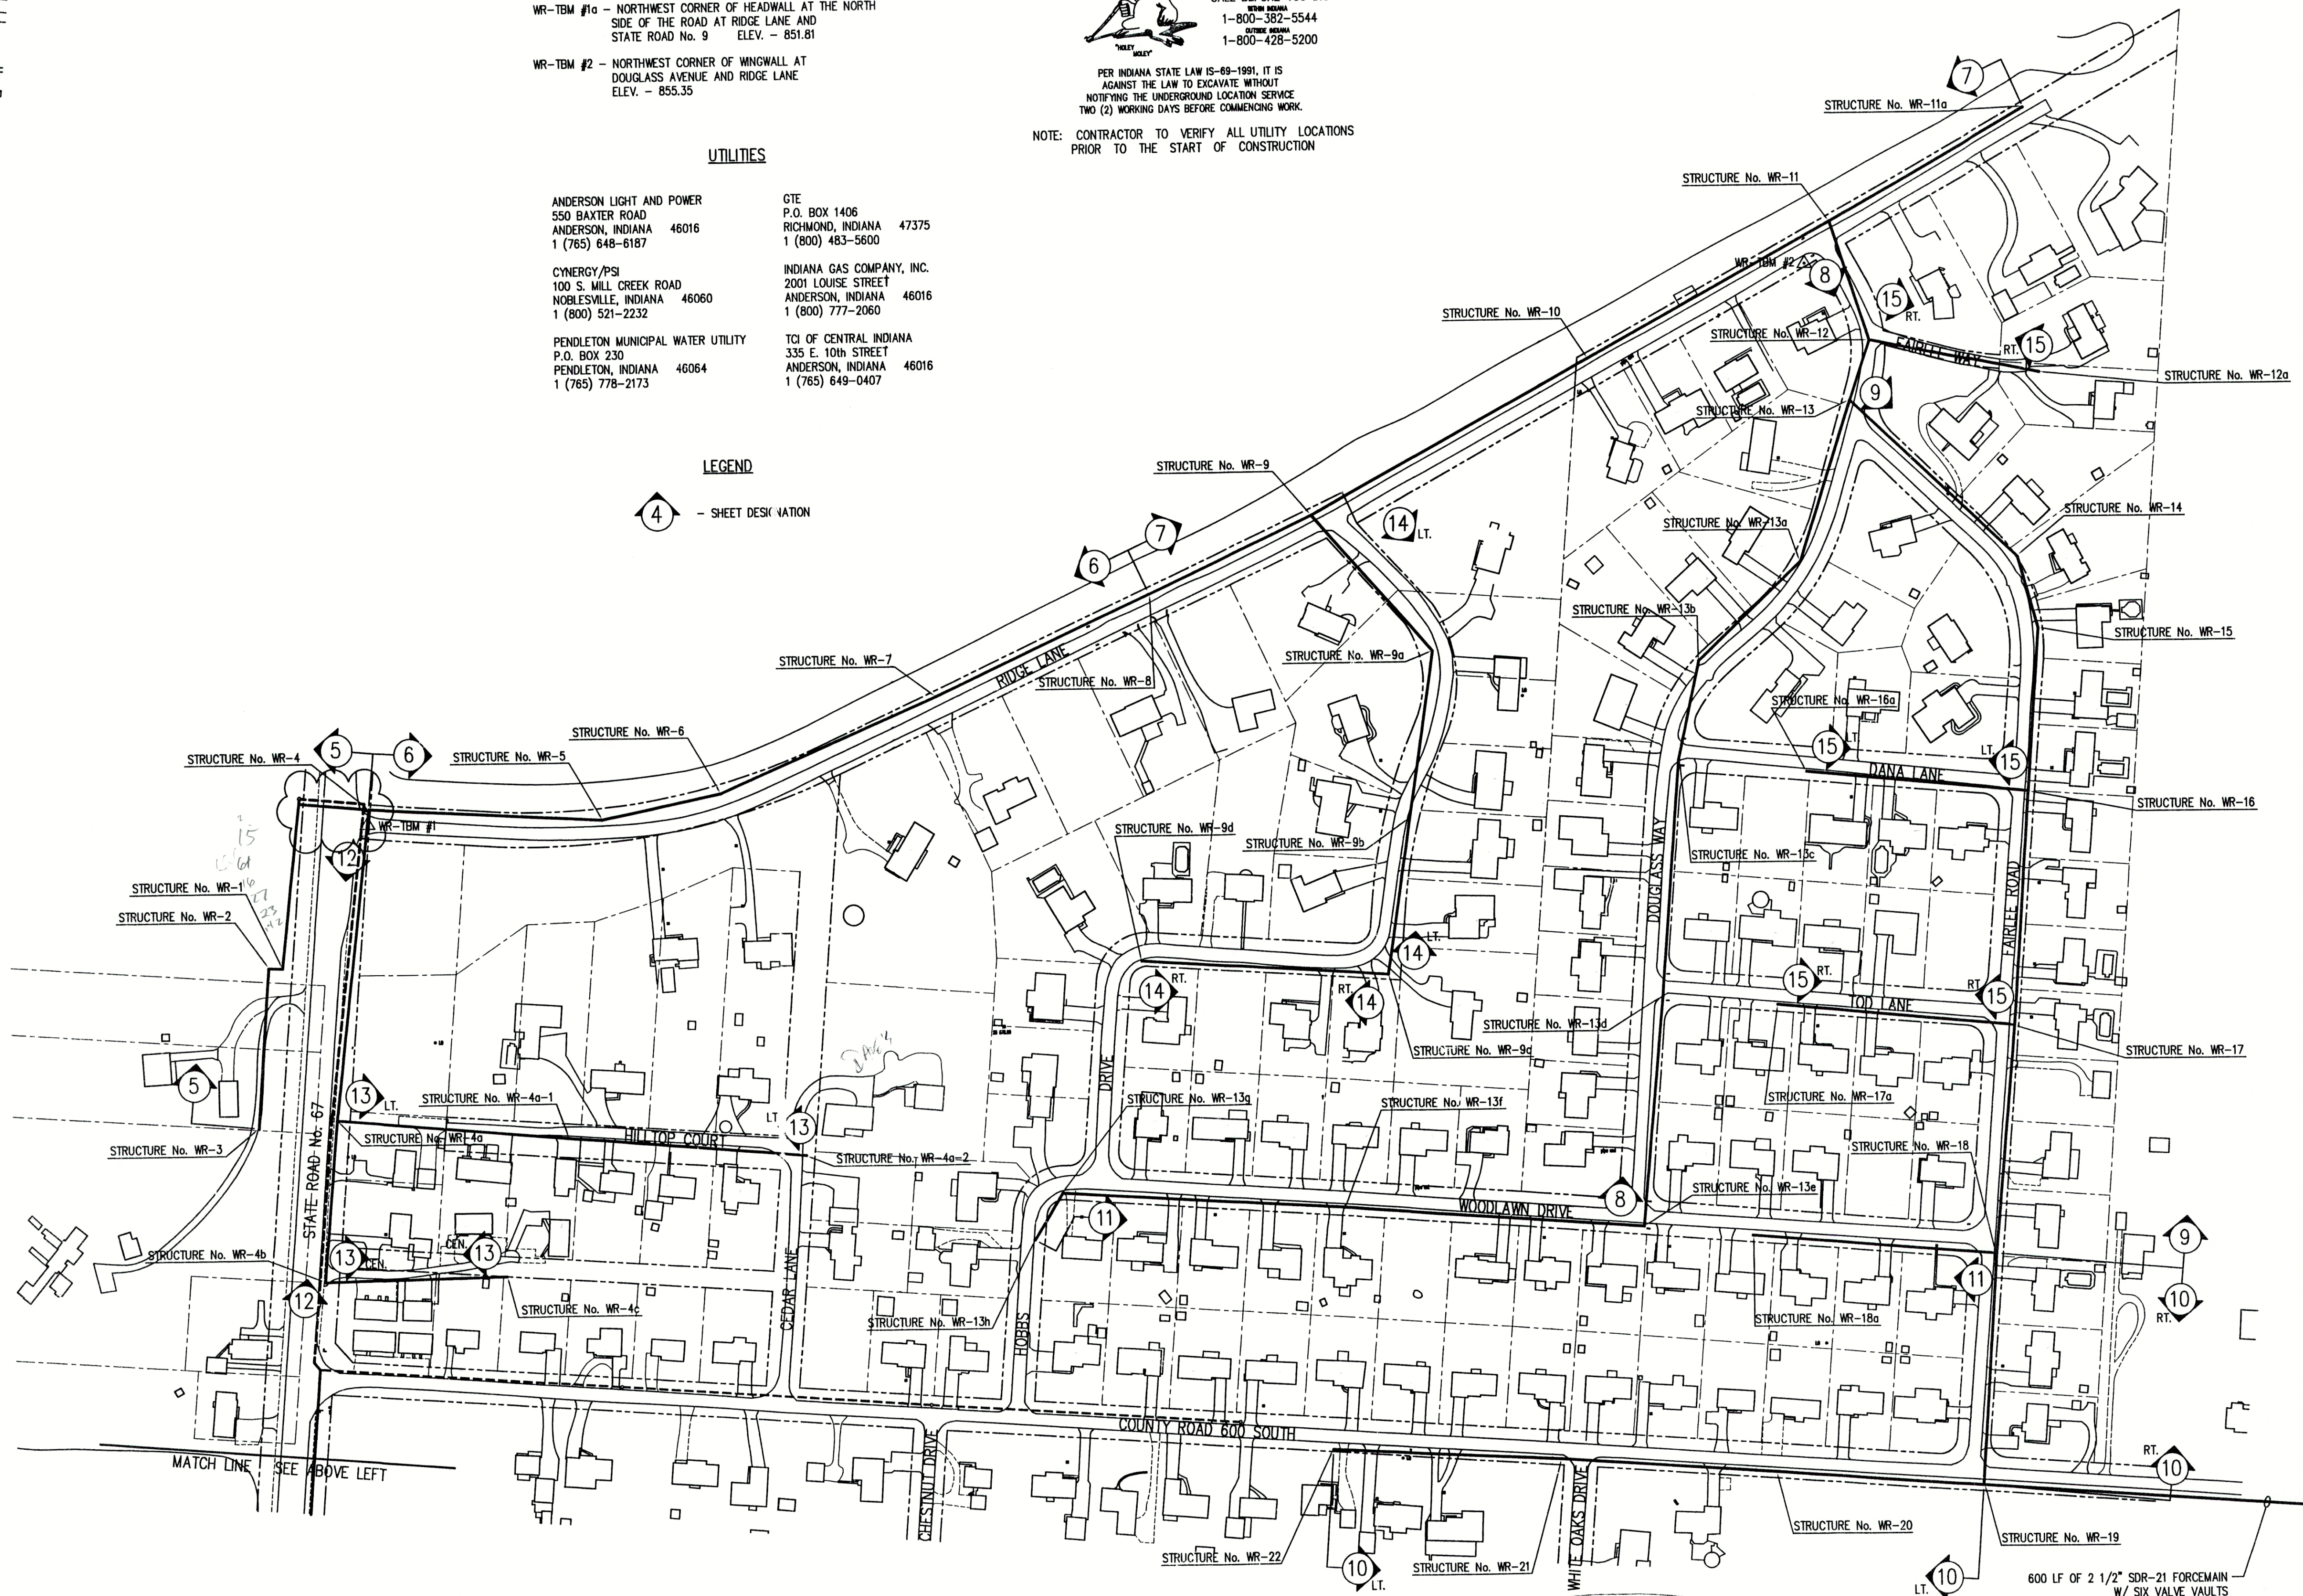

RECORD DRAWING

February 15, 2001

AREA BASE MAP

NOT TO SCALE




FILE NAME: WORDGBAS-RD PLOT SCALE: 1=125 PLOT DATE: 12/6

NO.	DATE	DESCRIPTION	BY

TRIAD
ASSOCIATES
INC.
INDIANAPOLIS, INDIANA

APPROVED BY:
THOMAS W. SCHUBERT
REGISTERED
No. 15614
STATE OF INDIANA
PROFESSIONAL ENGINEER
Thomas M. Schubert, P.E.

WOODED RIDGE SUBDIVISION
FALL CREEK REGIONAL WASTE DISTRICT
PROJECT BASE MAP
DRAWN BY: DATE 04/12/98 PROJECT No. SHEET No.
DAP SCALE AS NOTED 98008A 2
DESIGNED BY: D.A. Pauling
CHECKED BY: James W. Frazell, P.E.
18

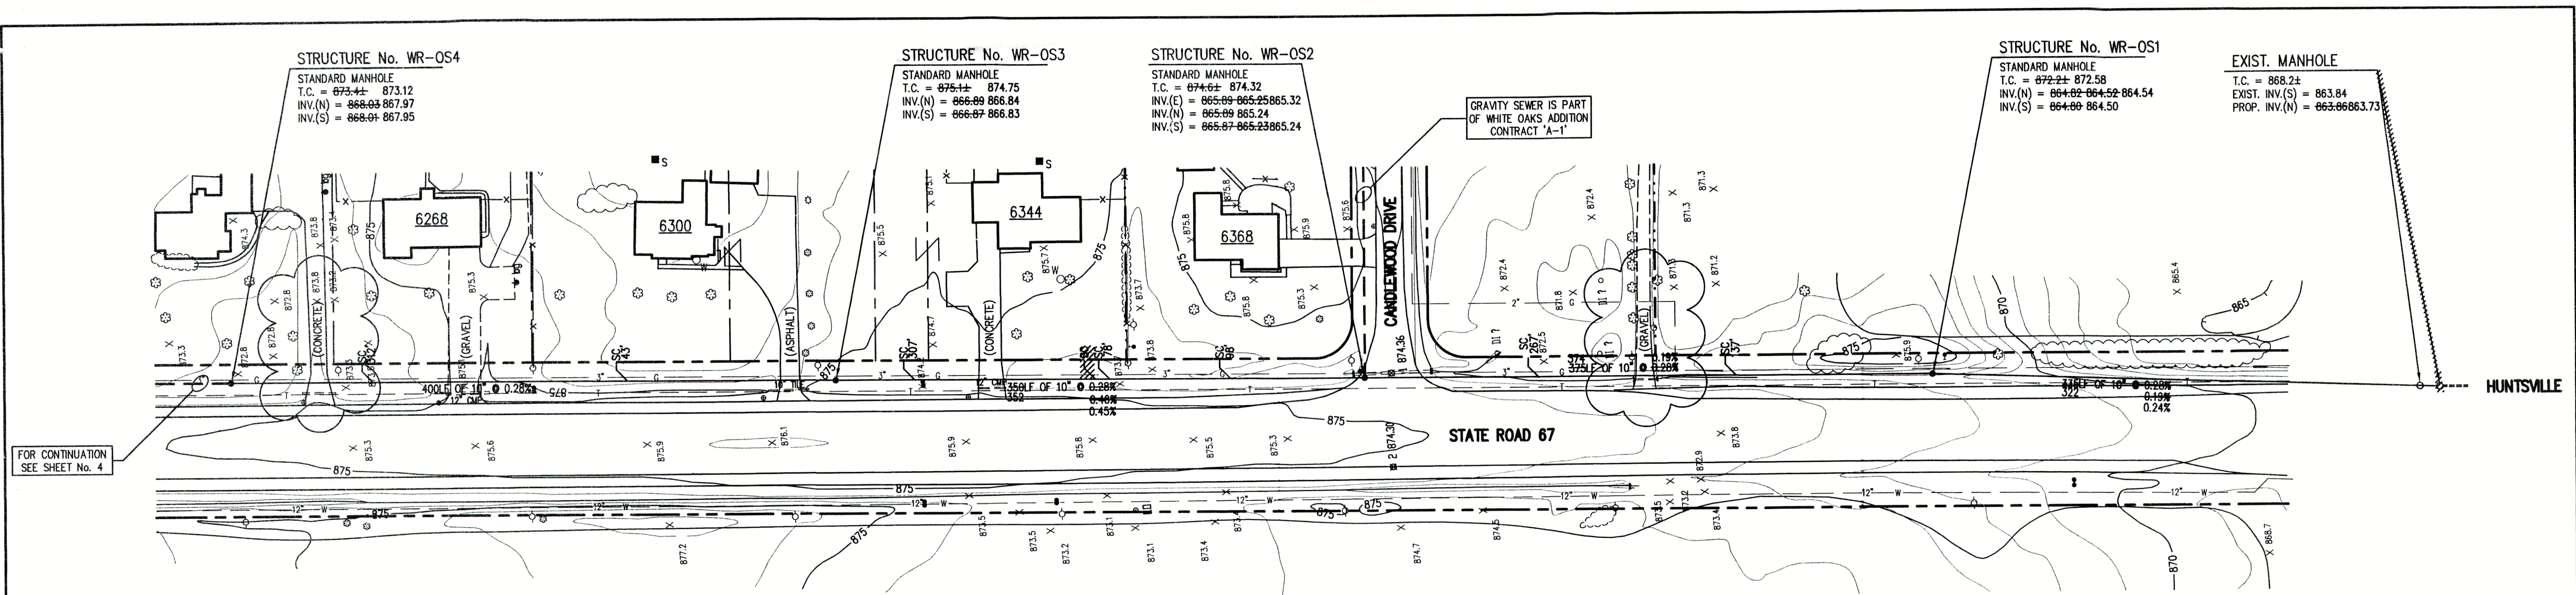

RECORD DRAWING

February 15, 2001

NOTE:
ADDITIONAL RIGHT-OF-WAY OR EASEMENTS MAY
NEED TO BE ACQUIRED FOR INSTALLATION OF SEWER.



PER INDIANA STATE LAW (S-69-1991), IT IS
AGAINST THE LAW TO EXCAVATE WITHOUT
NOTIFYING THE UNDERGROUND LOCATION SERVICE
TWO (2) WORKING DAYS BEFORE COMMENCING WORK.

NOTE: CONTRACTOR TO VERIFY ALL UTILITY LOCATIONS
PRIOR TO THE START OF CONSTRUCTION


GENERAL NOTES:

- ALL UTILITY LOCATIONS ARE APPROXIMATE. THE CONTRACTOR SHALL HAVE ALL UTILITIES FIELD VERIFIED AND MARKED PRIOR TO CONSTRUCTION.
- CONTRACTOR SHALL MAINTAIN A MINIMUM 10'-0" HORIZONTAL AND 18" VERTICAL SEPARATION BETWEEN SEWER AND WATER MAINS.
- ALL PROPOSED TOP OF CASTING ELEVATIONS ARE APPROXIMATE. THE CONTRACTOR SHALL ADJUST FINAL ELEVATIONS AS REQUIRED TO BE FLUSH WITH PAVEMENT.
- ALL SEWER TRENCHES SHALL BE BACKFILLED WITH FULL DEPTH COMPACTED GRANULAR BACKFILL ("B" BORROW) UNDER OR WITHIN 5' OF EDGE OF PAVEMENT.
- THE CONTRACTOR SHALL VISIT THE SITE PRIOR TO BID TO BECOME FAMILIAR WITH ALL SITE CONDITIONS.
- THE CONTRACTOR SHALL PROVIDE THE REQUIRED MEANS FOR MAINTAINING SAFE TRAFFIC AT ALL TIMES.
- CONTRACTOR SHALL RESTORE ALL DISTURBED LAWN AREAS, STREETS, WALKS, DRIVES, ETC. AS SHOWN ON DRAWINGS, IN THE SPECIFICATIONS, OR TO AT LEAST PRE-EXISTING CONDITIONS.
- ALL UTILITY CROSSINGS SHALL BE PROTECTED AND SUPPORTED WITH GRANULAR FILL OR CONCRETE AS REQUIRED PER THE DETAIL SHEET.

LEGEND:	
•	TREE
○	POWER POLE
—	GUY WIRE
—	FIRE HYDRANT
—	MAILBOX
—	FLAGPOLE
—	SPOT SHOT
—	CONTOUR
—	FENCE
—	EXIST. SANITARY SEWER w/ MANHOLE
—	NEW SANITARY SEWER w/ MANHOLE
—	NEW SANITARY SERVICE CONNECTION
—	WATER LINE
—	GAS LINE
—	UNDERGROUND ELECTRIC LINE
—	UNDERGROUND TELEPHONE LINE
—	APPROX. RIGHT-OF-WAY
—	APPROX. CORPORATE LIMITS
—	APPROX. PROPERTY LINE
○ W	EXISTING WATER WELL
■ S	EXISTING SEPTIC TANK



SCALE:
HORIZONTAL 1" = 50'
VERTICAL 1" = 5'

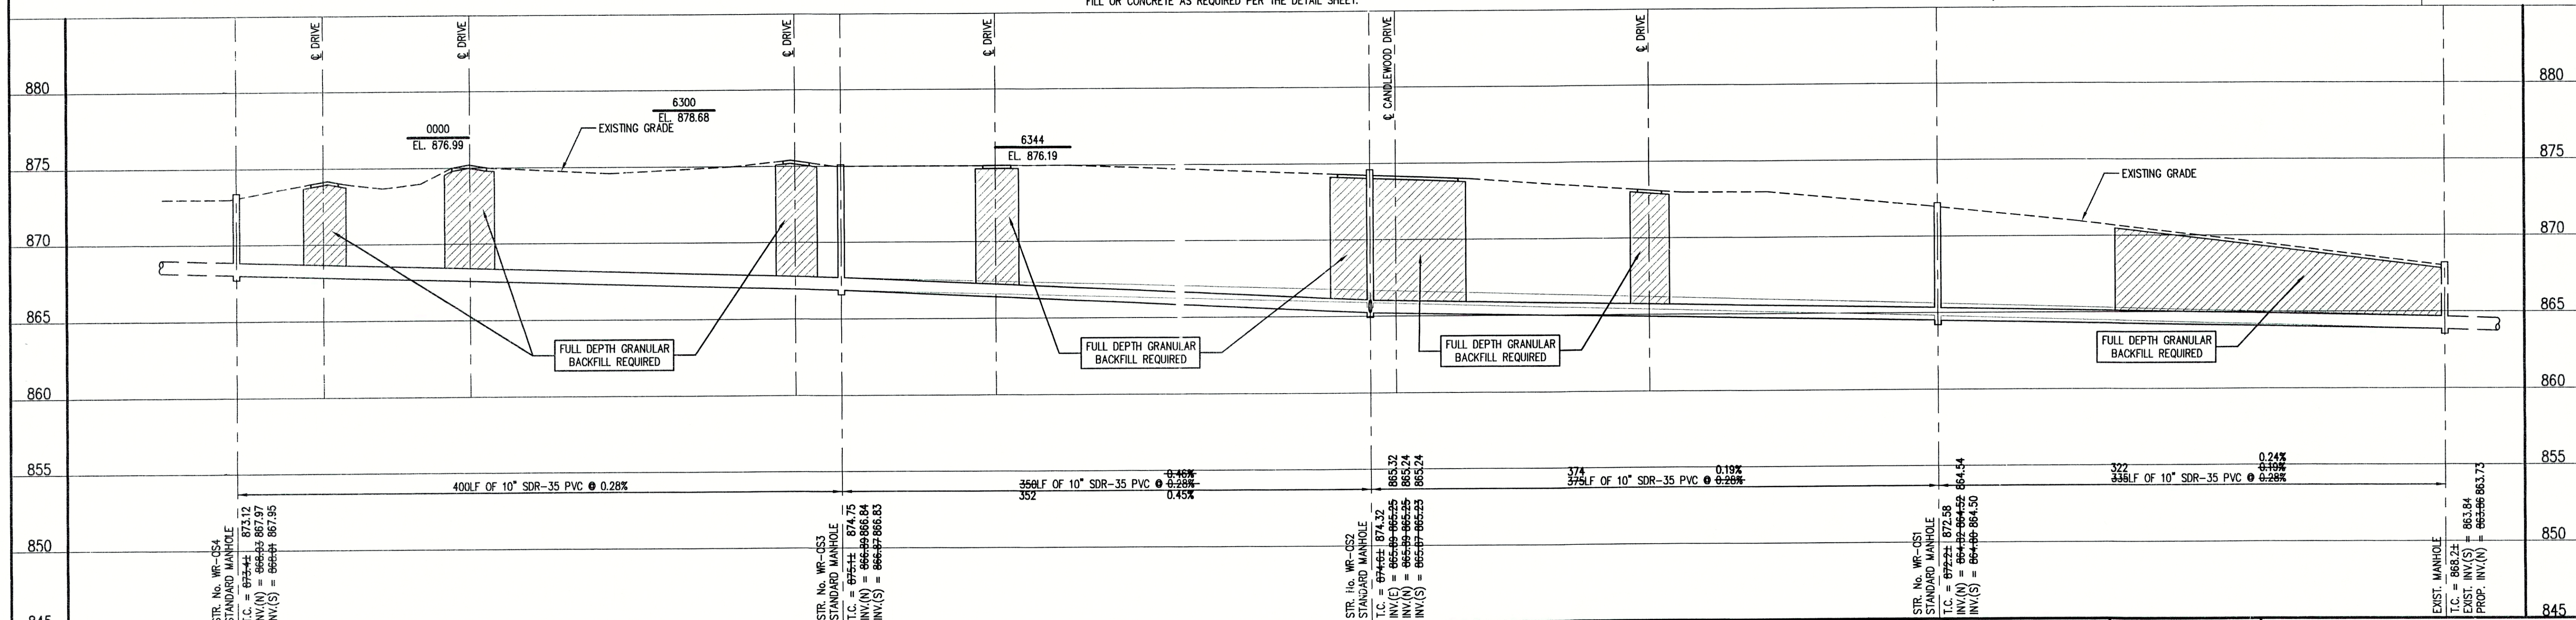

NOTE:
THE CONTRACTOR SHALL INCLUDE IN THE COSTS FOR SANITARY PIPE,
ALL WATER SERVICE RECONNECTIONS, STORM SEWER RECONNECTION,
WATER MAIN RELOCATIONS, CONCRETE RECONSTRUCTION, AND
SIDEWALK RECONSTRUCTION AS REQUIRED TO INSTALL NEW WORK
AS SHOWN ON THE DRAWINGS.

FILE NAME: SR67_1-RD		PLOT SCALE: 1=50	PLOT DATE: 12/3
N/O	DATE	DESCRIPTION	BY

TRIAD ASSOCIATES INC.
INDIANAPOLIS, INDIANA

APPROVED BY:
THOMAS M. SCHUBERT
No. 15614
STATE OF INDIANA
PROFESSIONAL ENGINEER
Thomas M. Schubert, P.E.

WOODED RIDGE SUBDIVISION
FALL CREEK REGIONAL WASTE DISTRICT
PLAN AND PROFILE
DRAWN BY: DATE 04/12/98 PROJECT No. SHEET No.
DAP SCALE AS NOTED 98008A 3
DESIGNED BY: D.A. Paulling
CHECKED BY: James W. Frazell, P.E.
OF 13

NOTE:
ADDITIONAL RIGHT-OF-WAY OR EASEMENTS MAY
NEED TO BE ACQUIRED FOR INSTALLATION OF SEWER.



DON'T DIG BLIND
CALL BEFORE YOU DIG
TOLL FREE
1-800-382-5544
OUTLINE SERVICE
1-800-428-5200

PER INDIANA STATE LAW IS-69-1991, IT IS
AGAINST THE LAW TO EXCAVATE WITHOUT
NOTIFYING THE UNDERGROUND LOCATION SERVICE
TWO (2) WORKING DAYS BEFORE COMMENCING WORK.

NOTE: CONTRACTOR TO VERIFY ALL UTILITY LOCATIONS
PRIOR TO THE START OF CONSTRUCTION

GRAVITY SEWER IS PART OF
THE WHITE OAKS ADDITION
CONTRACT 'A-1'

STRUCTURE No. WR-OS7

STANDARD MANHOLE
T.C. = 879.31 879.83
INV.(N) = 871.73 871.67
INV.(S) = 871.71 871.66

FOR CONTINUATION
SEE SHEET No. 12

STRUCTURE No. WR-OS6

STANDARD MANHOLE
T.C. = 878.21 878.71
INV.(N) = 870.31 870.32
INV.(S) = 870.29

STRUCTURE No. WR-OS5

STANDARD MANHOLE
T.C. = 874.21 873.67
INV.(N) = 869.17 869.19
INV.(S) = 869.15 869.17

STRUCTURE No. WR-OS4
(SEE SHEET No. 3)

- GENERAL NOTES:
- ALL UTILITY LOCATIONS ARE APPROXIMATE. THE CONTRACTOR SHALL HAVE ALL UTILITIES FIELD VERIFIED AND MARKED PRIOR TO CONSTRUCTION.
 - CONTRACTOR SHALL MAINTAIN A MINIMUM 10'-0" HORIZONTAL AND 18" VERTICAL SEPARATION BETWEEN SEWER AND WATER MAINS.
 - ALL PROPOSED TOP OF CASTING ELEVATIONS ARE APPROXIMATE. THE CONTRACTOR SHALL ADJUST FINAL ELEVATIONS AS REQUIRED TO BE FLUSH WITH PAVEMENT.
 - ALL SEWER TRENCHES SHALL BE BACKFILLED WITH FULL DEPTH COMPACTED GRANULAR BACKFILL ("B" BORROW) UNDER OR WITHIN 5' OF EDGE OF PAVEMENT.
 - THE CONTRACTOR SHALL VISIT THE SITE PRIOR TO BID TO BECOME FAMILIAR WITH ALL SITE CONDITIONS.
 - THE CONTRACTOR SHALL PROVIDE THE REQUIRED MEANS FOR MAINTAINING SAFE TRAFFIC AT ALL TIMES.
 - CONTRACTOR SHALL RESTORE ALL DISTURBED LAWN AREAS, STREETS, WALKS, DRIVES, ETC. AS SHOWN ON DRAWINGS, IN THE SPECIFICATIONS, OR TO AT LEAST PRE-EXISTING CONDITIONS.
 - ALL UTILITY CROSSINGS SHALL BE PROTECTED AND SUPPORTED WITH GRANULAR FILL OR CONCRETE AS REQUIRED PER THE DETAIL SHEET.


RECORD DRAWING

February 15, 2001

- LEGEND:
- TREE
 - POWER POLE
 - GUY WIRE
 - FIRE HYDRANT
 - MAILBOX
 - FLAGPOLE
 - SPOT SHOT
 - CONTOUR
 - FENCE
 - EXIST. SANITARY SEWER w/ MANHOLE
 - EXISTING WATER WELL
 - EXISTING SEPTIC TANK
 - NEW SANITARY SEWER w/ MANHOLE
 - NEW SANITARY SERVICE CONNECTION
 - 4" W WATER LINE
 - 2" G GAS LINE
 - E UNDERGROUND ELECTRIC LINE
 - T UNDERGROUND TELEPHONE LINE
 - APPROX. RIGHT-OF-WAY
 - APPROX. CORPORATE LIMITS
 - APPROX. PROPERTY LINE



SCALE:
HORIZONTAL 1" = 50'
VERTICAL 1" = 5'

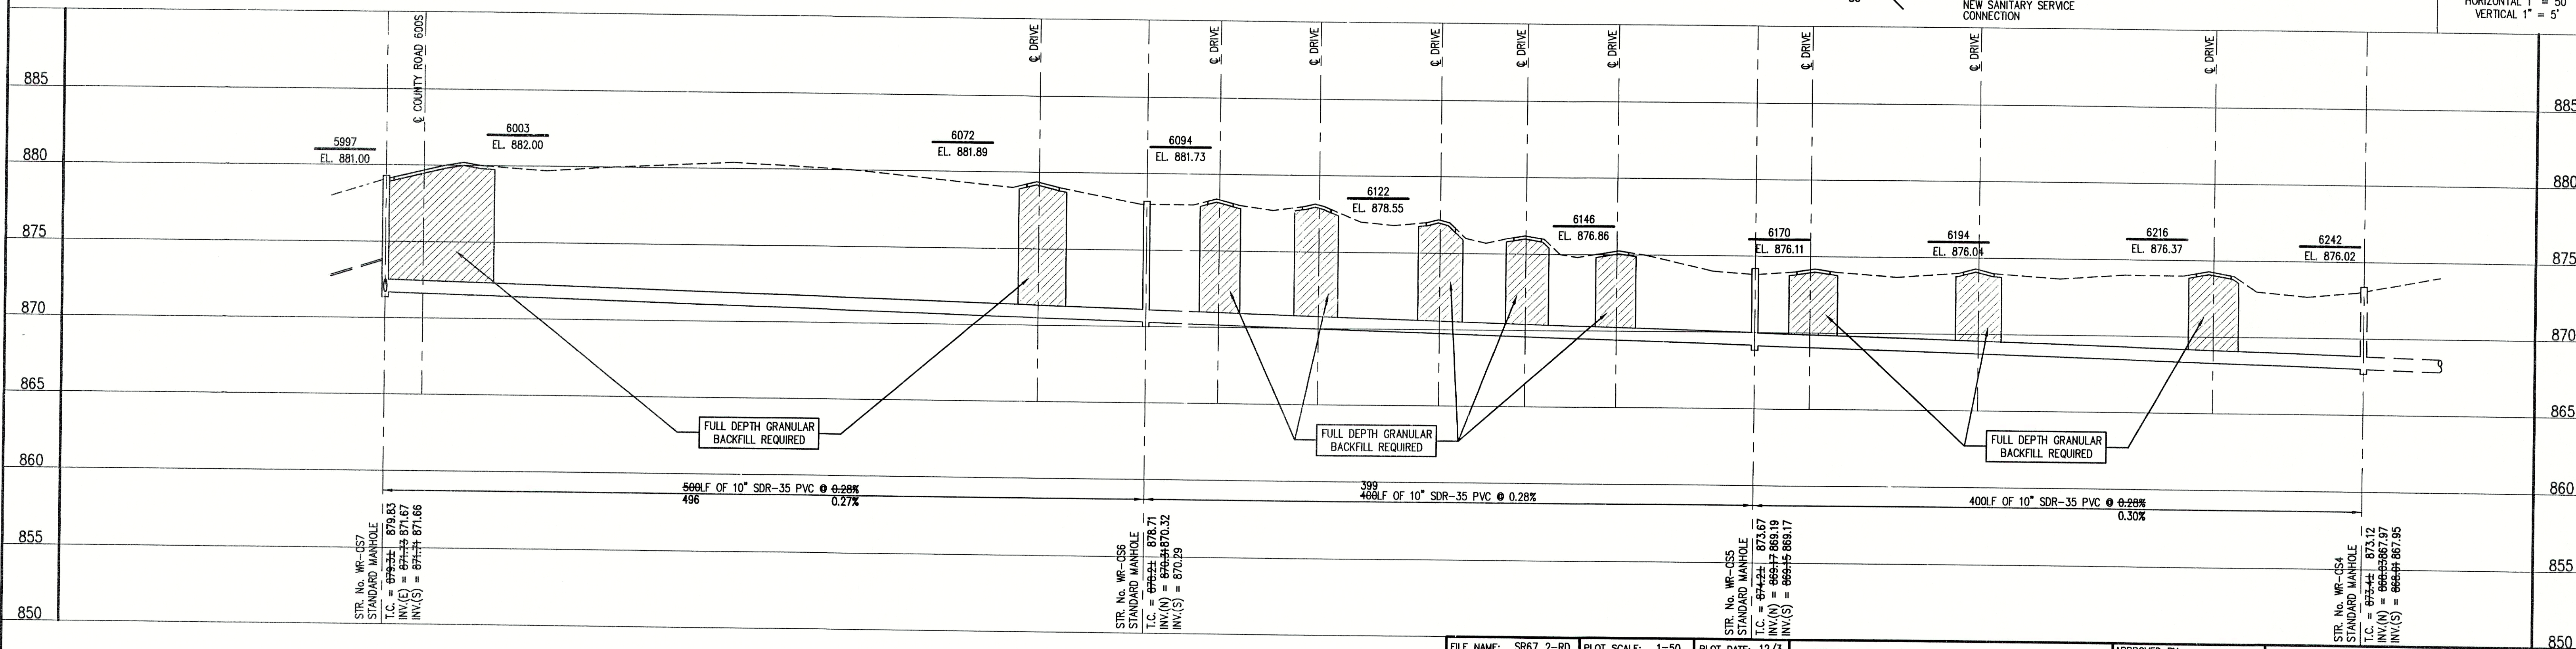


NOTE:

THE CONTRACTOR SHALL INCLUDE IN THE COSTS FOR SANITARY PIPE, ALL WATER SERVICE RECONNECTIONS, STORM SEWER RECONNECTION, WATER MAIN RELOCATIONS, CONCRETE RECONSTRUCTION, AND SIDEWALK RECONSTRUCTION AS REQUIRED TO INSTALL NEW WORK AS SHOWN ON THE DRAWINGS.

FILE NAME:	SR67_2-RD	PLOT SCALE:	1=50	PLOT DATE:	12/3
NO.	DATE	DESCRIPTION	BY		

TRIAD ASSOCIATES INC.
INDIANAPOLIS, INDIANA

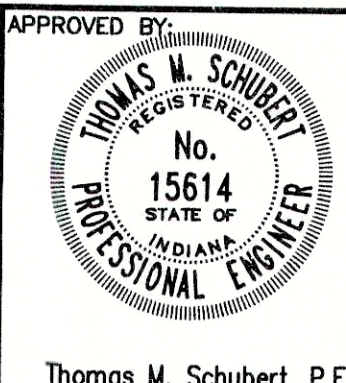

WOODED RIDGE SUBDIVISION
FALL CREEK REGIONAL WASTE DISTRICT
PLAN AND PROFILE
DRAWN BY: DAP
DATE: 04/12/98
PROJECT No.: 98008A
SHEET No.: 4
DESIGNED BY: D.A. Pauling
CHECKED BY: James W. Frazell, P.E.



FOR CONTINUATION
SEE SHEET No. 5

FOR CONTINUATION
SEE SHEET No. 12

FOR CONTINUATION
SEE SHEET No. 7

NOTE:
ADDITIONAL RIGHT-OF-WAY OR EASEMENTS MAY
NEED TO BE ACQUIRED FOR INSTALLATION OF SEWER.

DON'T DIG BLIND
CALL BEFORE YOU DIG
TOLL FREE
1-800-382-5544
OR
1-800-428-5200

PER INDIANA STATE LAW IS-69-1991, IT IS
AGAINST THE LAW TO EXCAVATE WITHOUT
NOTIFYING THE UNDERGROUND LOCATION SERVICE
TWO (2) WORKING DAYS BEFORE COMMENCING WORK.



NOTE: CONTRACTOR TO VERIFY ALL UTILITY LOCATIONS
PRIOR TO THE START OF CONSTRUCTION

- GENERAL NOTES:
- ALL UTILITY LOCATIONS ARE APPROXIMATE. THE CONTRACTOR SHALL HAVE ALL UTILITIES FIELD VERIFIED AND MARKED PRIOR TO CONSTRUCTION.
 - CONTRACTOR SHALL MAINTAIN A MINIMUM 10'-0" HORIZONTAL AND 18" VERTICAL SEPARATION BETWEEN SEWER AND WATER MAINS.
 - ALL PROPOSED TOP OF CASTING ELEVATIONS ARE APPROXIMATE. THE CONTRACTOR SHALL ADJUST FINAL ELEVATIONS AS REQUIRED TO BE FLUSH WITH PAVEMENT.
 - ALL SEWER TRENCHES SHALL BE BACKFILLED WITH FULL DEPTH COMPACTED GRANULAR BACKFILL ("B" BORROW) UNDER OR WITHIN 5' OF EDGE OF PAVEMENT.
 - THE CONTRACTOR SHALL VISIT THE SITE PRIOR TO BID TO BECOME FAMILIAR WITH ALL SITE CONDITIONS.
 - THE CONTRACTOR SHALL PROVIDE THE REQUIRED MEANS FOR MAINTAINING SAFE TRAFFIC AT ALL TIMES.
 - CONTRACTOR SHALL RESTORE ALL DISTURBED LAWN AREAS, STREETS, WALKS, DRIVES, ETC. AS SHOWN ON DRAWINGS, IN THE SPECIFICATIONS, OR TO AT LEAST PRE-EXISTING CONDITIONS.
 - ALL UTILITY CROSSINGS SHALL BE PROTECTED AND SUPPORTED WITH GRANULAR FILL OR CONCRETE AS REQUIRED PER THE DETAIL SHEET.

- LEGEND:
- 1085 TREE
 - POWER POLE
 - GUY WIRE
 - FIRE HYDRANT
 - MAILBOX
 - FLAGPOLE
 - SPOT SHOT
 - CONTOUR
 - FENCE
 - EXIST. SANITARY SEWER w/ MANHOLE
 - NEW SANITARY SEWER w/ MANHOLE
 - NEW SANITARY SERVICE CONNECTION
 - WATER LINE
 - GAS LINE
 - UNDERGROUND ELECTRIC LINE
 - UNDERGROUND TELEPHONE LINE
 - APPROX. RIGHT-OF-WAY
 - APPROX. CORPORATE LIMITS
 - APPROX. PROPERTY LINE
 - EXISTING WATER WELL
 - EXISTING SEPTIC TANK



SCALE:
HORIZONTAL 1" = 50'
VERTICAL 1" = 5'

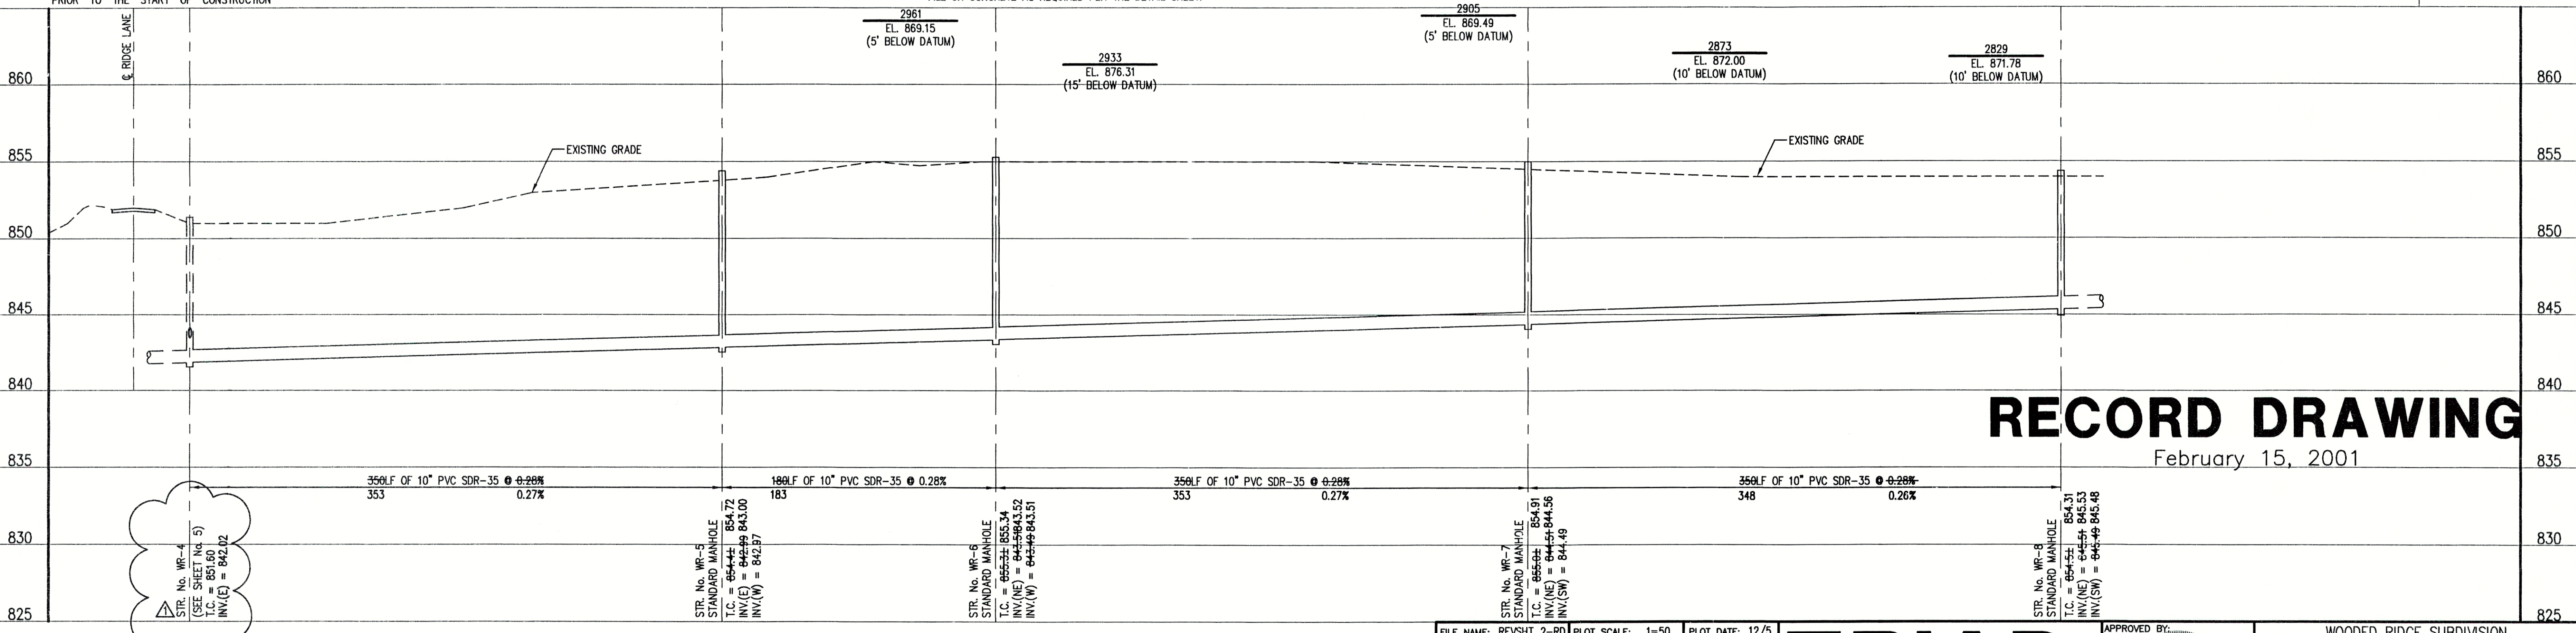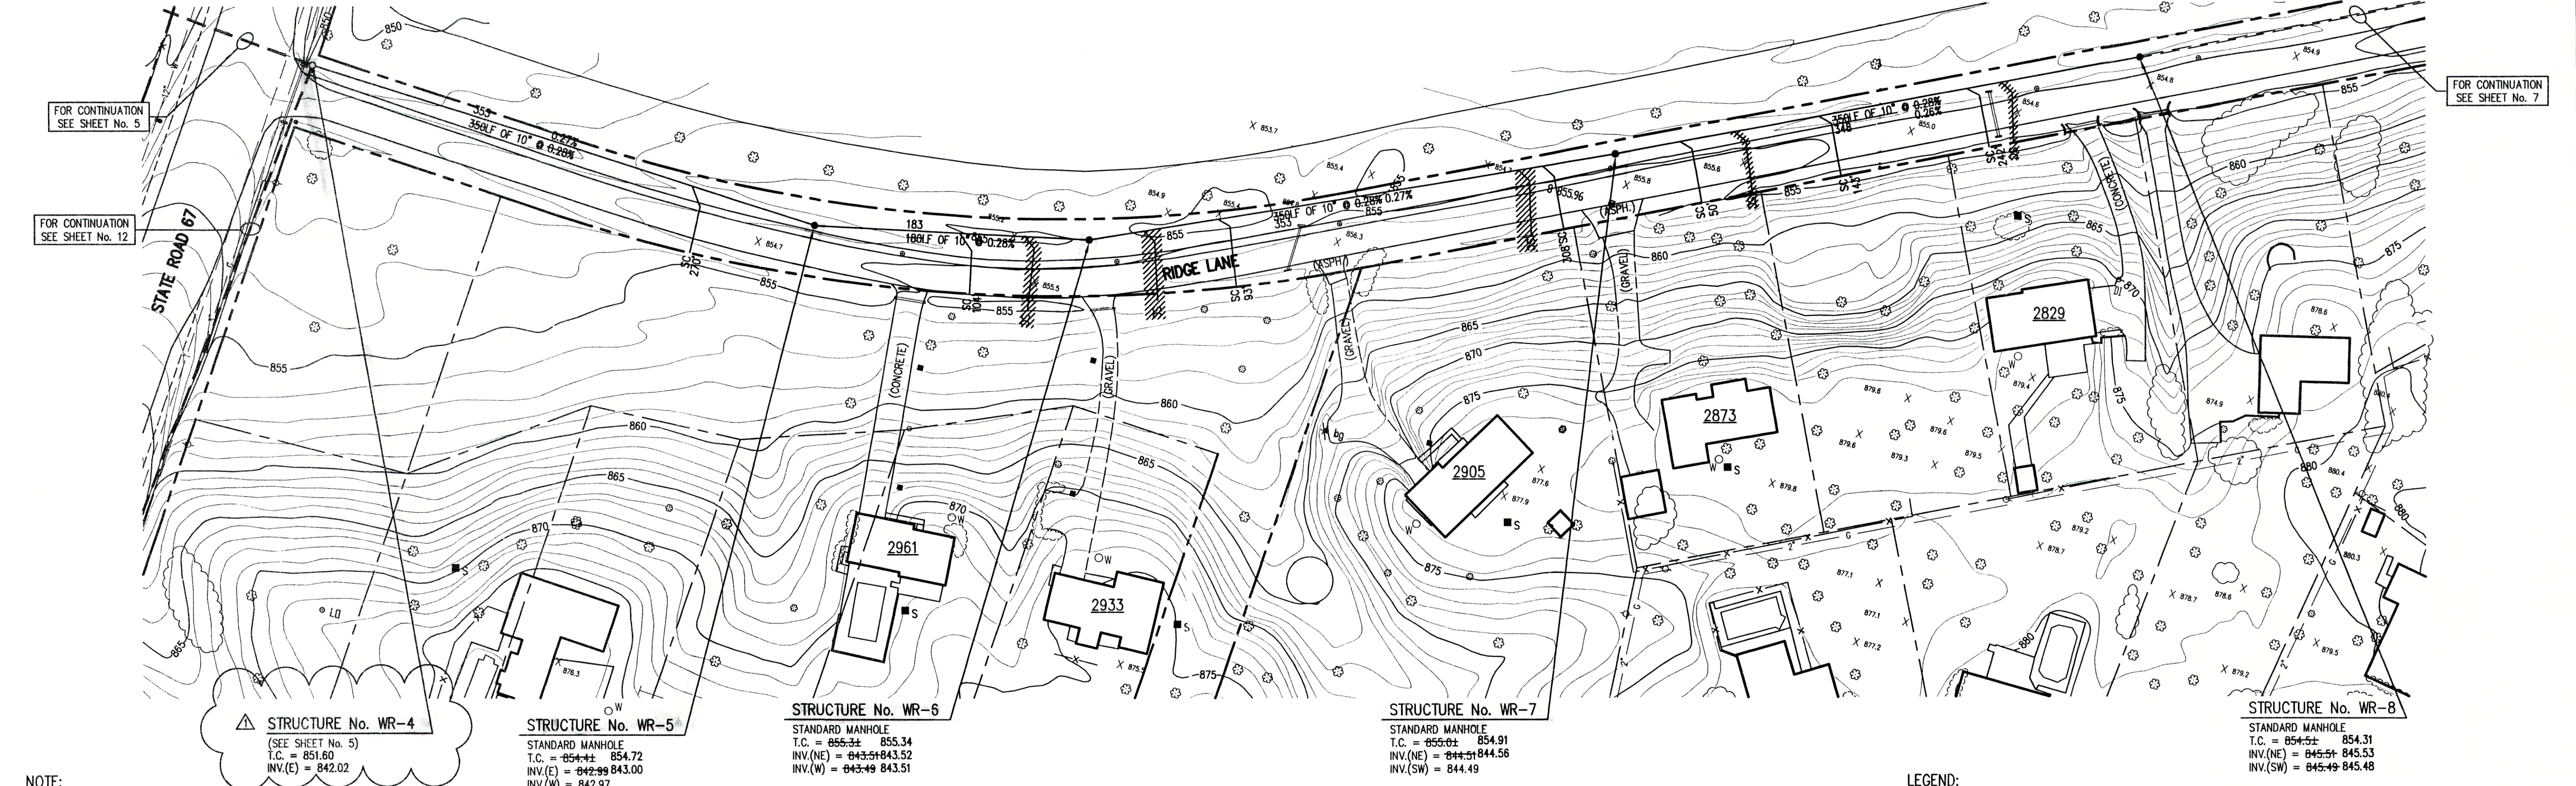

NOTE:
THE CONTRACTOR SHALL INCLUDE IN THE COSTS FOR SANITARY PIPE, ALL WATER SERVICE RECONNECTIONS, STORM SEWER RECONNECTION, WATER MAIN RELOCATIONS, CONCRETE RECONSTRUCTION, AND SIDEWALK RECONSTRUCTION AS REQUIRED TO INSTALL NEW WORK AS SHOWN ON THE DRAWINGS.


FILE NAME: REVSHIT_2-RD		PLOT SCALE: 1=50	PLOT DATE: 12/5
	04/13/99	LIFT STATION LOCATION REVISION	D.A.P.
NO.	DATE	DESCRIPTION	BY

TRIAD ASSOCIATES INC.
INDIANAPOLIS, INDIANA

APPROVED BY:

Thomas M. Schubert, P.E.

WOODED RIDGE SUBDIVISION
FALL CREEK REGIONAL WASTE DISTRICT
PLAN AND PROFILE
DRAWN BY: DATE 04/12/98 PROJECT No. 98008A
DAP SCALE AS NOTED
DESIGNED BY: D.A. Pauling
CHECKED BY: James W. Frazell, P.E.

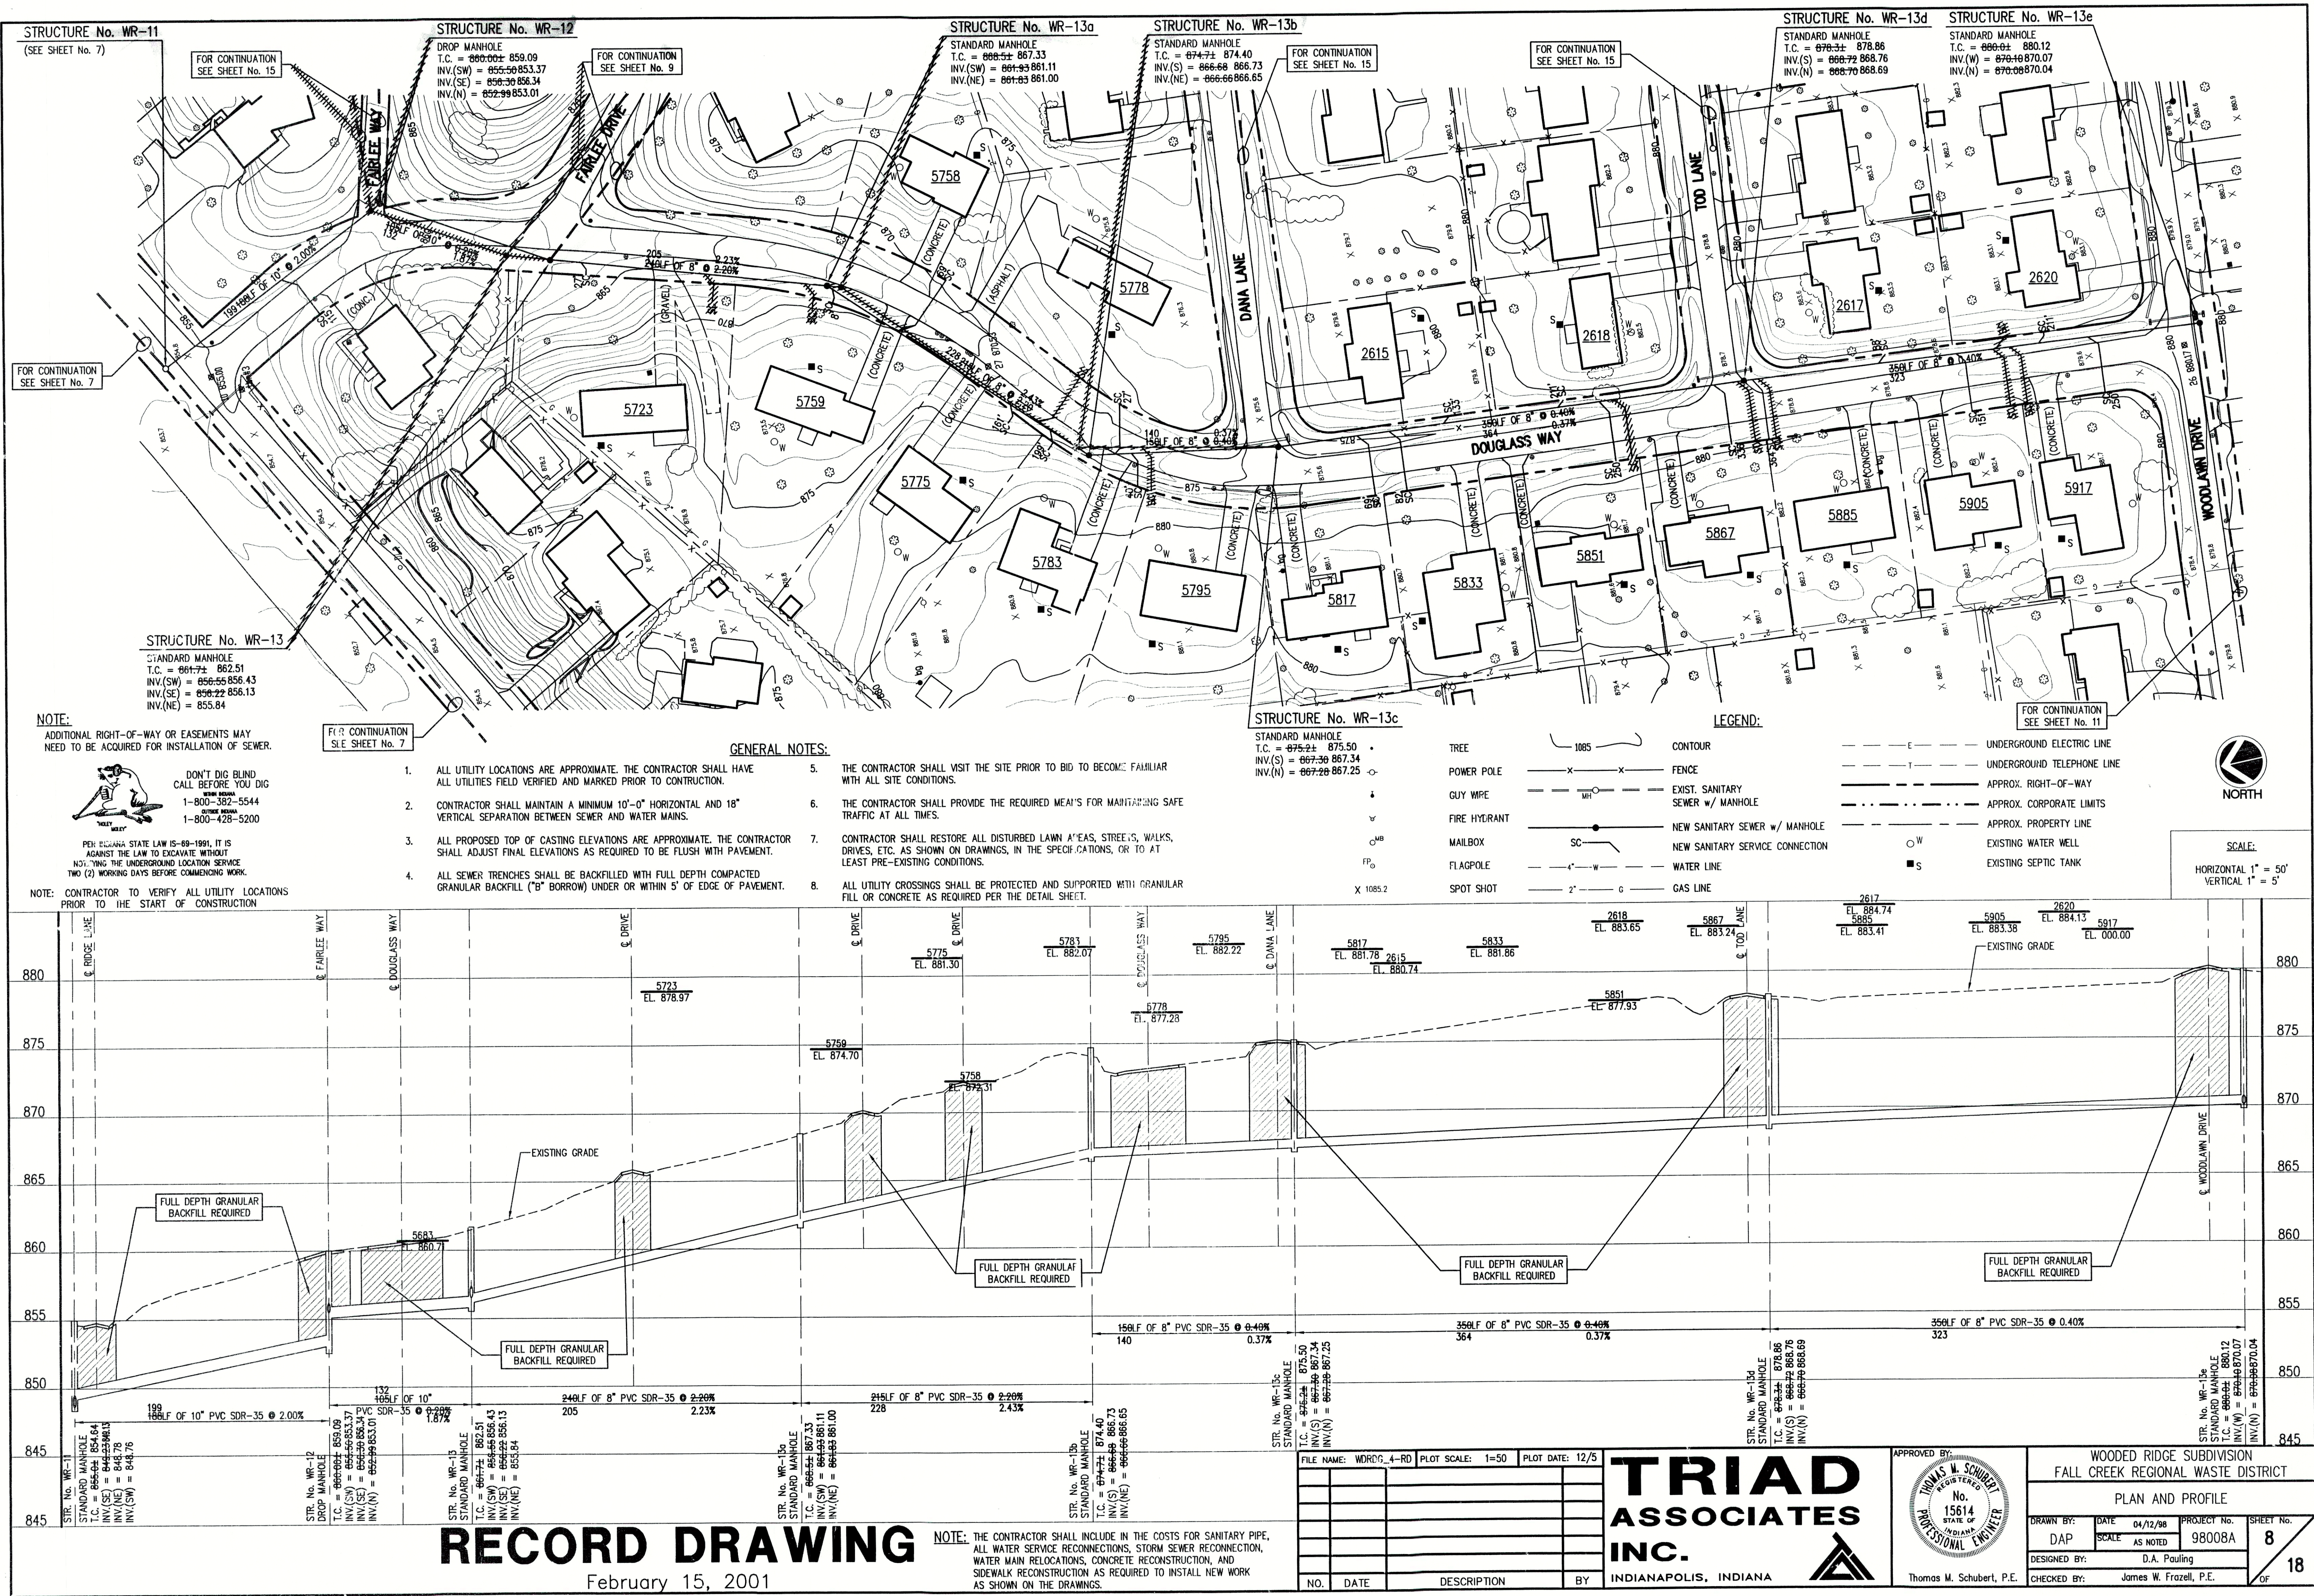

STRUCTURE No. WR-11
(SEE SHEET No. 7)
FOR CONTINUATION
SEE SHEET No. 15

STRUCTURE No. WR-12
DROP MANHOLE
T.C. = 880.00± 859.09
INV.(SW) = 855.50 853.37
INV.(SE) = 856.30 856.34
INV.(N) = 852.99 853.01
FOR CONTINUATION
SEE SHEET No. 9

STRUCTURE No. WR-13a
STANDARD MANHOLE
T.C. = 888.5± 867.33
INV.(SW) = 861.93 861.11
INV.(NE) = 861.83 861.00

STRUCTURE No. WR-13b
STANDARD MANHOLE
T.C. = 874.7± 874.40
INV.(S) = 866.66 866.73
INV.(NE) = 866.66 866.65
FOR CONTINUATION
SEE SHEET No. 15

STRUCTURE No. WR-13d
STANDARD MANHOLE
T.C. = 878.3± 878.86
INV.(S) = 868.72 868.76
INV.(N) = 868.70 868.69


STRUCTURE No. WR-13e
STANDARD MANHOLE
T.C. = 880.0± 880.12
INV.(W) = 870.40 870.07
INV.(N) = 870.08 870.04

STRUCTURE No. WR-13
STANDARD MANHOLE
T.C. = 861.7± 862.51
INV.(SW) = 856.55 856.43
INV.(SE) = 856.22 856.13
INV.(NE) = 855.84

STRUCTURE No. WR-13c
STANDARD MANHOLE
T.C. = 875.2± 875.50
INV.(S) = 867.36 867.34
INV.(N) = 867.28 867.25


- NOTE:**
ADDITIONAL RIGHT-OF-WAY OR EASEMENTS MAY
NEED TO BE ACQUIRED FOR INSTALLATION OF SEWER.
- GENERAL NOTES:**
1. ALL UTILITY LOCATIONS ARE APPROXIMATE. THE CONTRACTOR SHALL HAVE ALL UTILITIES FIELD VERIFIED AND MARKED PRIOR TO CONSTRUCTION.
 2. CONTRACTOR SHALL MAINTAIN A MINIMUM 10'-0" HORIZONTAL AND 18" VERTICAL SEPARATION BETWEEN SEWER AND WATER MAINS.
 3. ALL PROPOSED TOP OF CASTING ELEVATIONS ARE APPROXIMATE. THE CONTRACTOR SHALL ADJUST FINAL ELEVATIONS AS REQUIRED TO BE FLUSH WITH PAVEMENT.
 4. ALL SEWER TRENCHES SHALL BE BACKFILLED WITH FULL DEPTH COMPACTED GRANULAR BACKFILL ("B" BORROW) UNDER OR WITHIN 5' OF EDGE OF PAVEMENT.
 5. THE CONTRACTOR SHALL VISIT THE SITE PRIOR TO BID TO BECOME FAMILIAR WITH ALL SITE CONDITIONS.
 6. THE CONTRACTOR SHALL PROVIDE THE REQUIRED MEAS FOR MAINTAINING SAFE TRAFFIC AT ALL TIMES.
 7. CONTRACTOR SHALL RESTORE ALL DISTURBED LAWN AREAS, STREETS, WALKS, DRIVES, ETC. AS SHOWN ON DRAWINGS, IN THE SPECIFICATIONS, OR TO AT LEAST PRE-EXISTING CONDITIONS.
 8. ALL UTILITY CROSSINGS SHALL BE PROTECTED AND SUPPORTED WITH GRANULAR FILL OR CONCRETE AS REQUIRED PER THE DETAIL SHEET.
- LEGEND:**
- 1085 TREE
 - POWER POLE
 - GUY WIRE
 - FIRE HYDRANT
 - MAILBOX
 - FLAGPOLE
 - SPOT SHOT
 - CONTOUR
 - FENCE
 - EXIST. SANITARY SEWER w/ MANHOLE
 - NEW SANITARY SEWER w/ MANHOLE
 - NEW SANITARY SERVICE CONNECTION
 - WATER LINE
 - GAS LINE
 - UNDERGROUND ELECTRIC LINE
 - UNDERGROUND TELEPHONE LINE
 - APPROX. RIGHT-OF-WAY
 - APPROX. CORPORATE LIMITS
 - APPROX. PROPERTY LINE
 - EXISTING WATER WELL
 - EXISTING SEPTIC TANK
- SCALE:**
HORIZONTAL 1" = 50'
VERTICAL 1" = 5'

FILE NAME:	WDR06_4-RD	PLOT SCALE:	1=50	PLOT DATE:	12/5

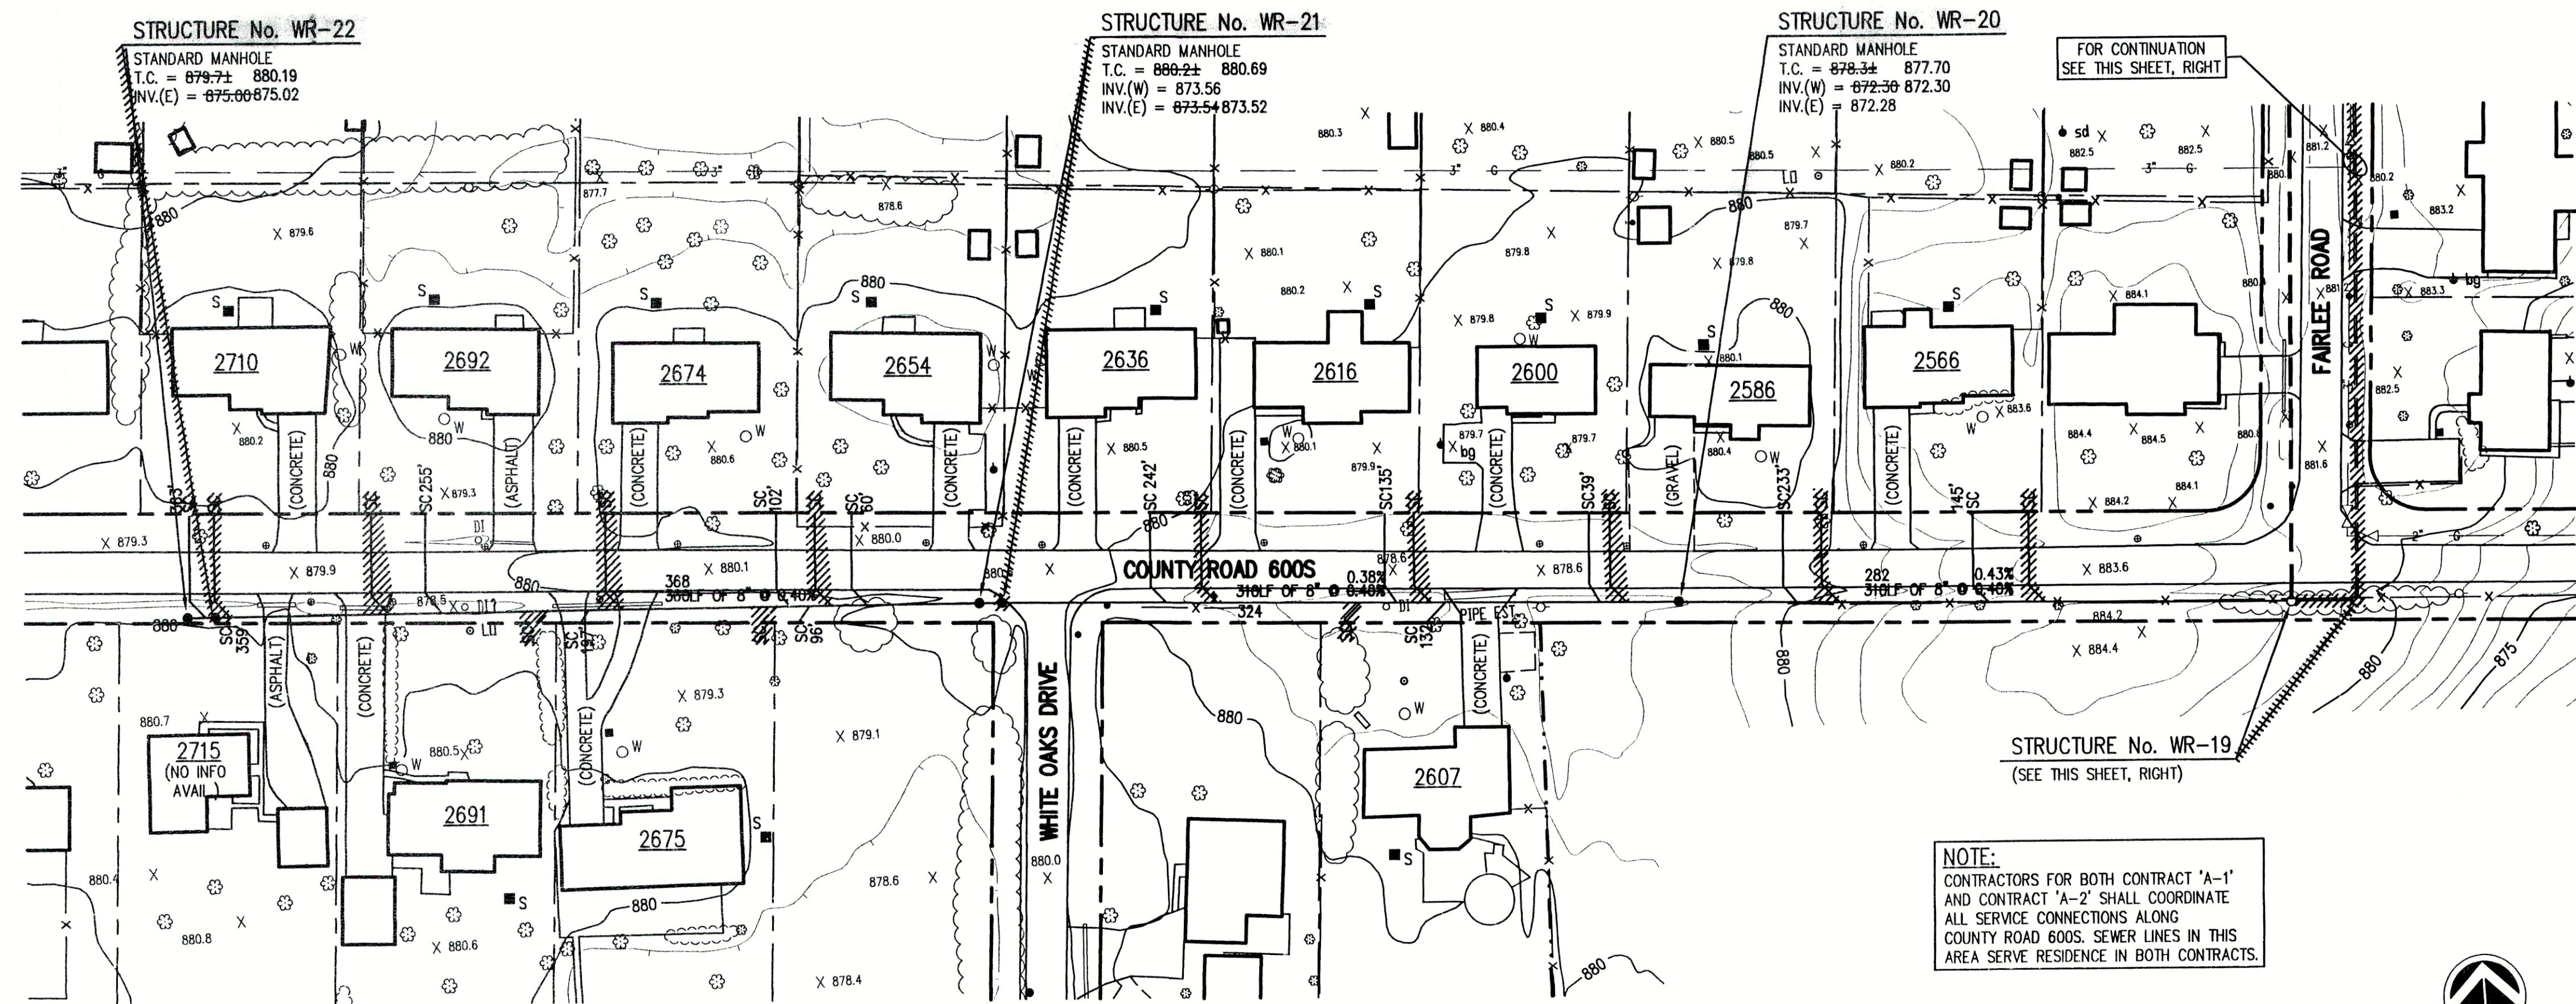

- GENERAL NOTES:**
- ALL UTILITY LOCATIONS ARE APPROXIMATE. THE CONTRACTOR SHALL HAVE ALL UTILITIES FIELD VERIFIED AND MARKED PRIOR TO CONSTRUCTION.
 - CONTRACTOR SHALL MAINTAIN A MINIMUM 10'-0" HORIZONTAL AND 18" VERTICAL SEPARATION BETWEEN SEWER AND WATER MAINS.
 - ALL PROPOSED TOP OF CASTING ELEVATIONS ARE APPROXIMATE. THE CONTRACTOR SHALL ADJUST FINAL ELEVATIONS AS REQUIRED TO BE FLUSH WITH PAVEMENT.
 - ALL SEWER TRENCHES SHALL BE BACKFILLED WITH FULL DEPTH COMPACTED GRANULAR BACKFILL ("B" BORROW) UNDER OR WITHIN 5' OF EDGE OF PAVEMENT.
 - THE CONTRACTOR SHALL VISIT THE SITE PRIOR TO BID TO BECOME FAMILIAR WITH ALL SITE CONDITIONS.
 - THE CONTRACTOR SHALL PROVIDE THE REQUIRED MEANS FOR MAINTAINING SAFE TRAFFIC AT ALL TIMES.
 - CONTRACTOR SHALL RESTORE ALL DISTURBED LAWN AREAS, STREETS, WALKS, DRIVES, ETC. AS SHOWN ON DRAWINGS, IN THE SPECIFICATIONS, OR TO AT LEAST PRE-EXISTING CONDITIONS.
 - ALL UTILITY CROSSINGS SHALL BE PROTECTED AND SUPPORTED WITH GRANULAR FILL OR CONCRETE AS REQUIRED PER THE DETAIL SHEET.

- LEGEND:**
- TREE
 - POWER POLE
 - GUY WIRE
 - FIRE HYDRANT
 - MAILBOX
 - FLAGPOLE
 - SPOT SHOT
 - CONTOUR
 - FENCE
 - EXIST. SANITARY SEWER w/ MANHOLE
 - NEW SANITARY SEWER w/ MANHOLE
 - NEW SANITARY SERVICE CONNECTION
 - WATER LINE
 - GAS LINE
 - UNDERGROUND ELECTRIC LINE
 - UNDERGROUND TELEPHONE LINE
 - APPROX. RIGHT-OF-WAY
 - APPROX. CORPORATE LIMITS
 - APPROX. PROPERTY LINE
 - EXISTING WATER WELL
 - EXISTING SEPTIC TANK

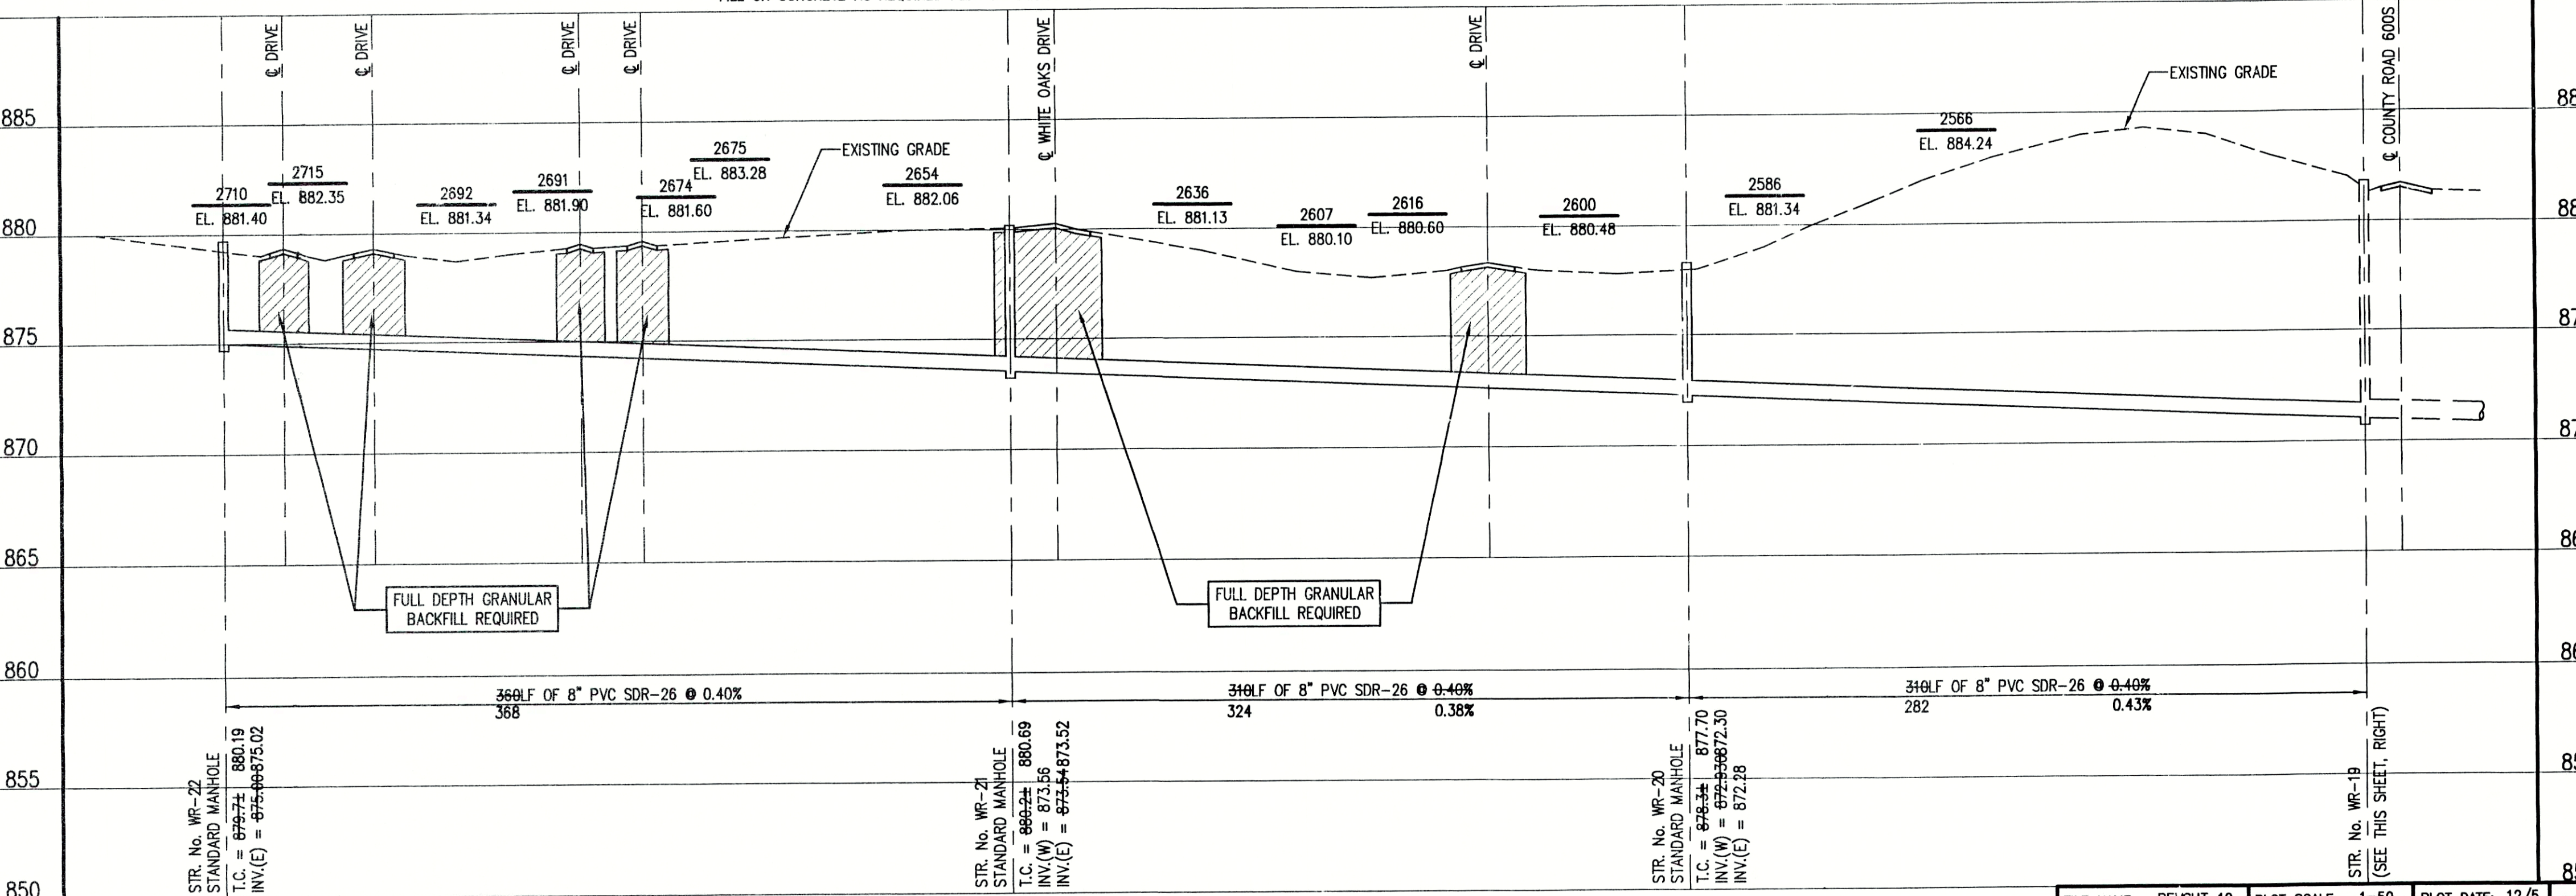

RECORD DRAWING

February 15, 2001


NOTE:

THE CONTRACTOR SHALL INCLUDE IN THE COSTS FOR SANITARY PIPE, ALL WATER SERVICE RECONNECTIONS, STORM SEWER RECONNECTION, WATER MAIN RELOCATIONS, CONCRETE RECONSTRUCTION, AND SIDEWALK RECONSTRUCTION AS REQUIRED TO INSTALL NEW WORK AS SHOWN ON THE DRAWINGS.

FILE NAME:	REVSHIT_10	PLOT SCALE:	1=50	PLOT DATE:	12/5
NO.	DATE	DESCRIPTION	BY		



TRIAD ASSOCIATES INC.


INDIANAPOLIS, INDIANA

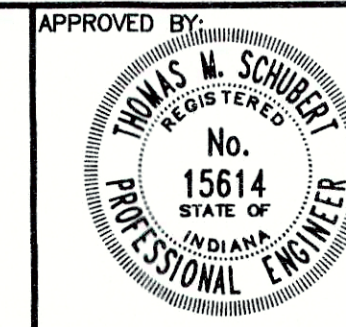

Thomas M. Schubert, P.E.

WOODED RIDGE SUBDIVISION FALL CREEK REGIONAL WASTE DISTRICT			
PLAN AND PROFILE			
DRAWN BY:	DATE	PROJECT No.	SHEET No.
DAP	04/12/98	98008A	10
DESIGNED BY:	SCALE	CHECKED BY:	OF
D.A. Pauling	AS NOTED	James W. Frazell, P.E.	18

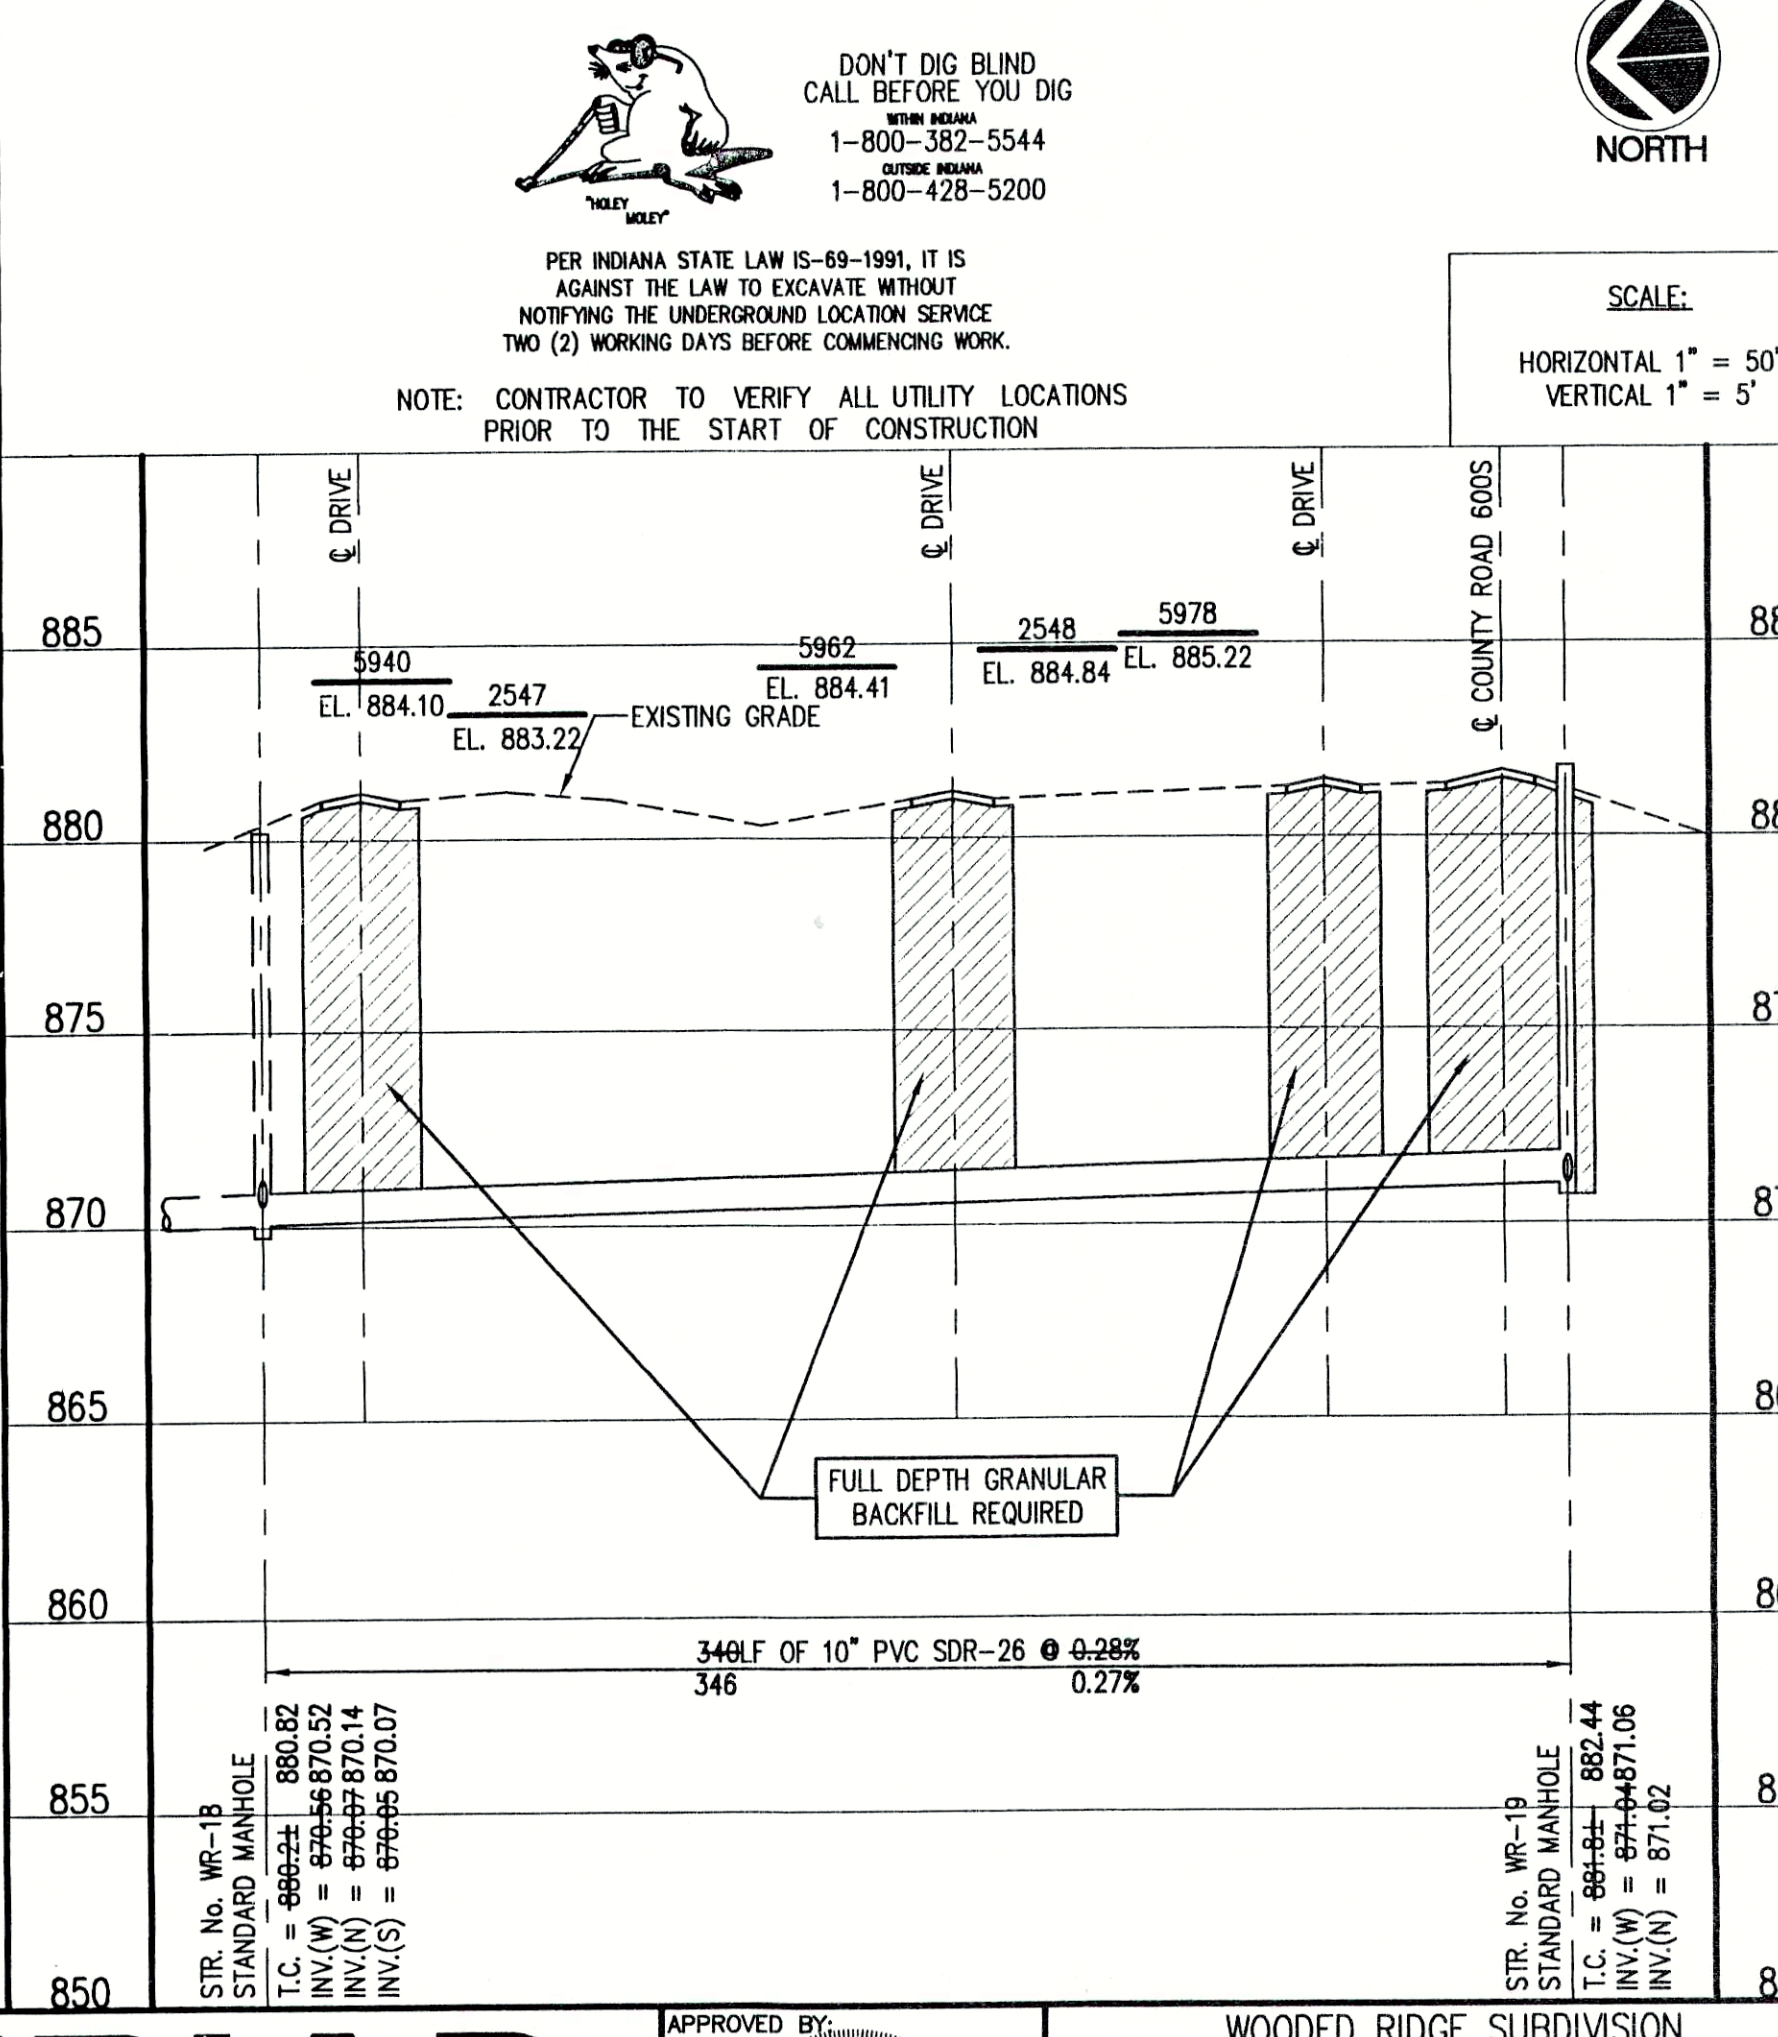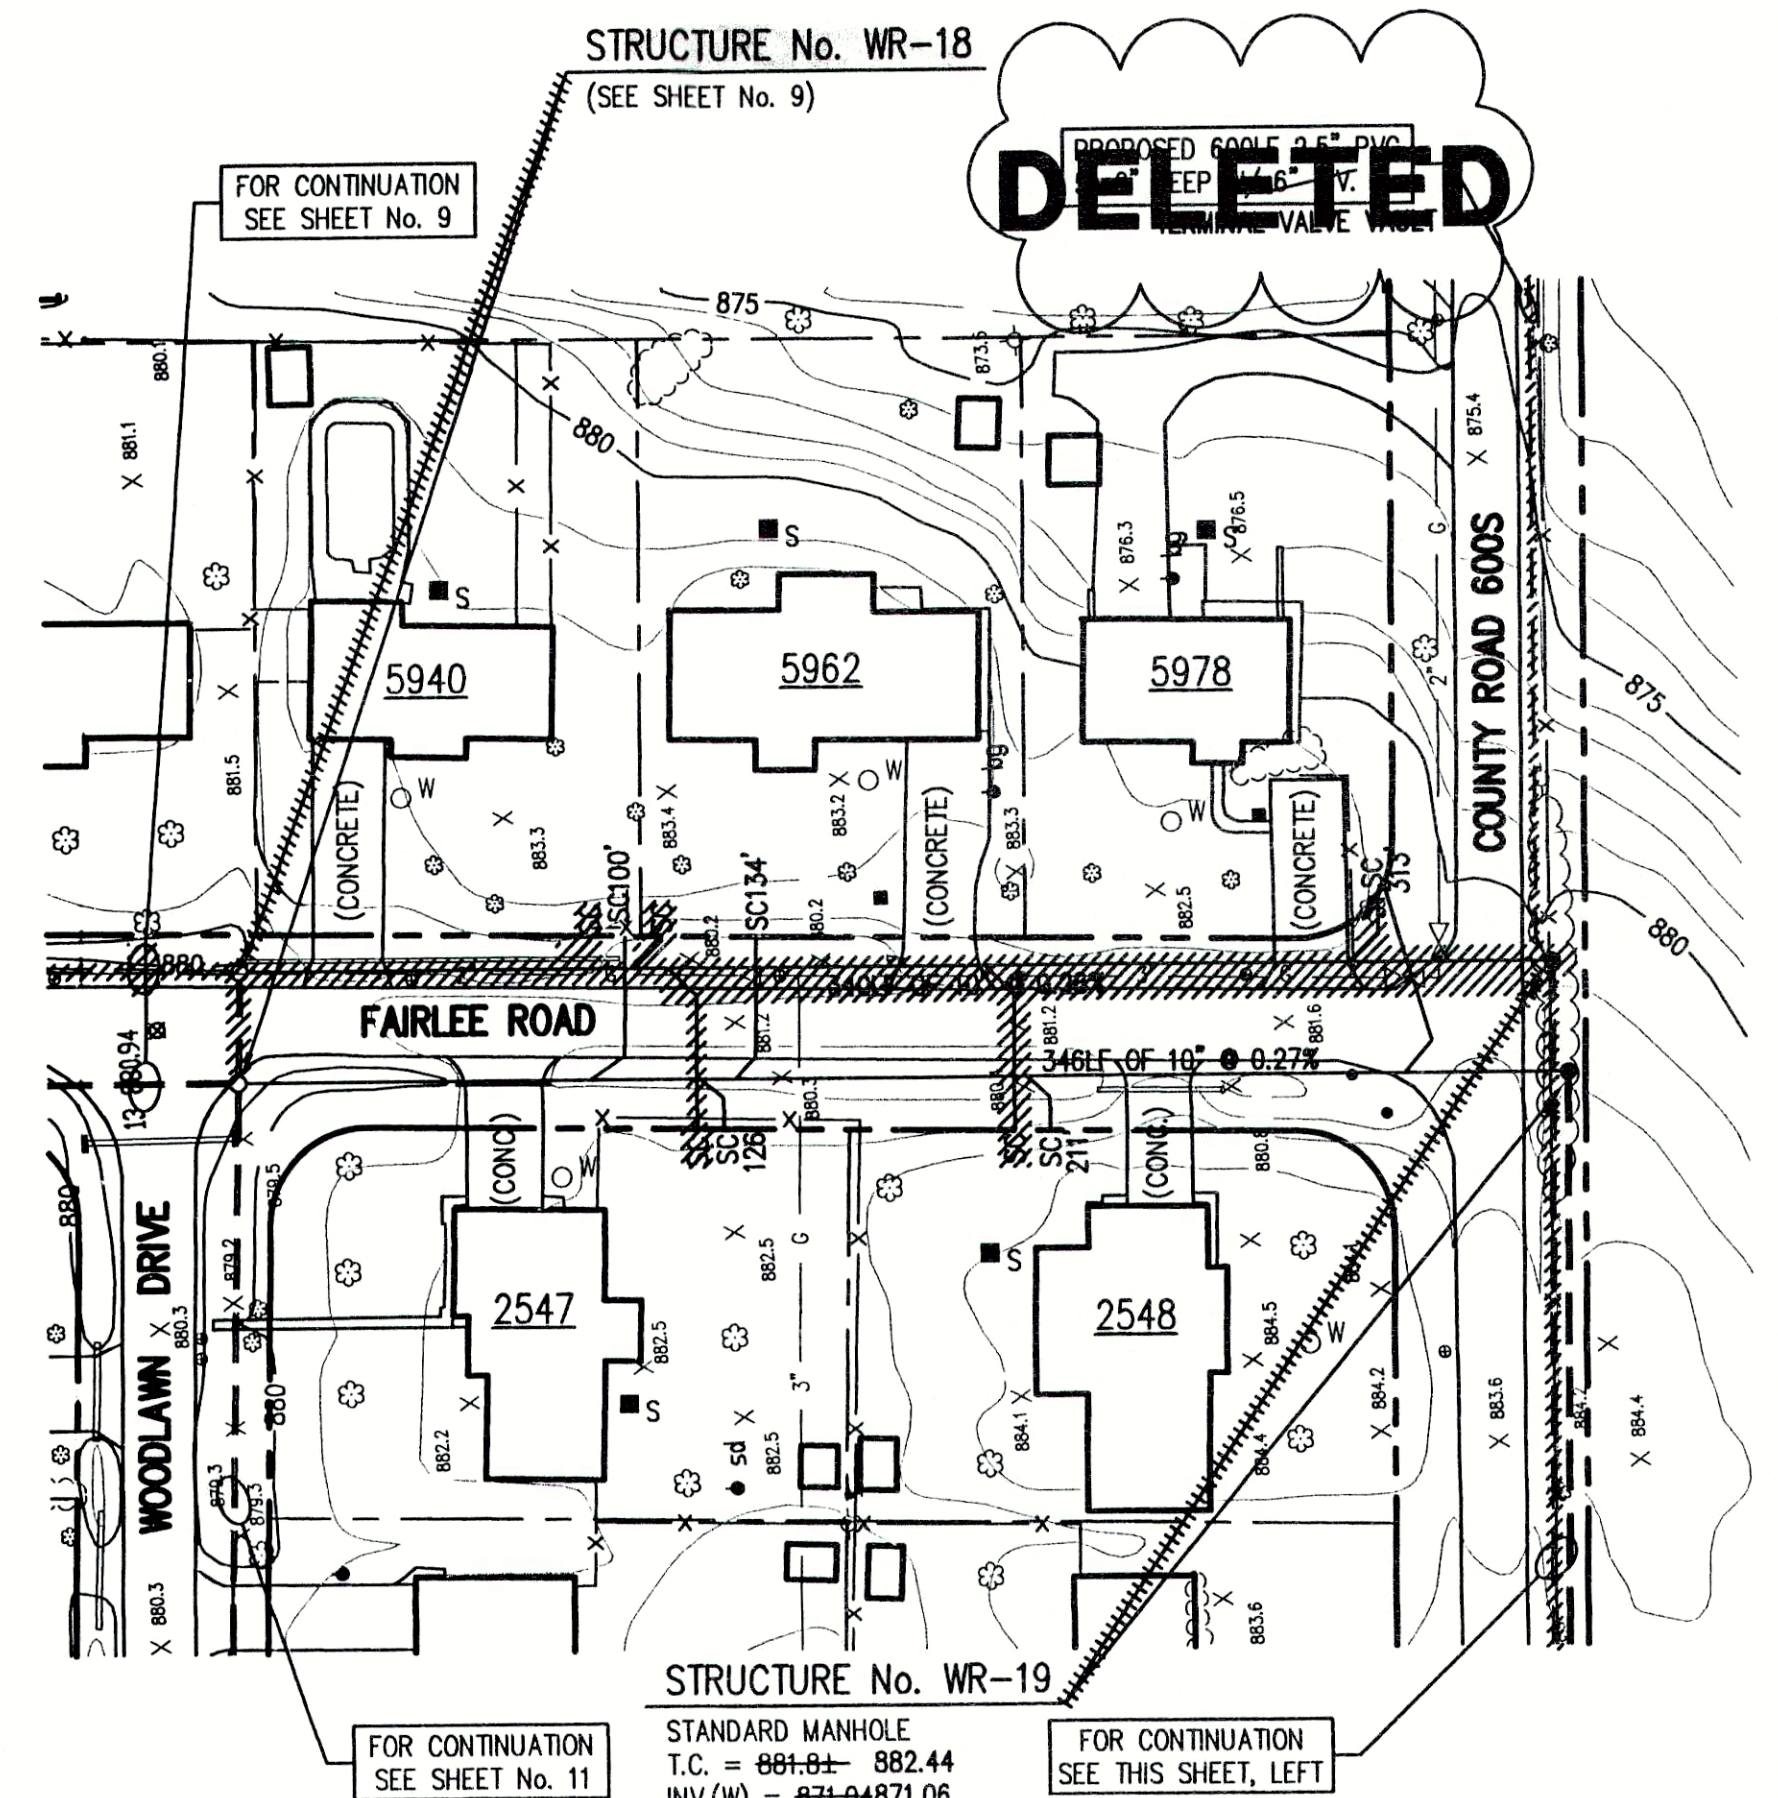

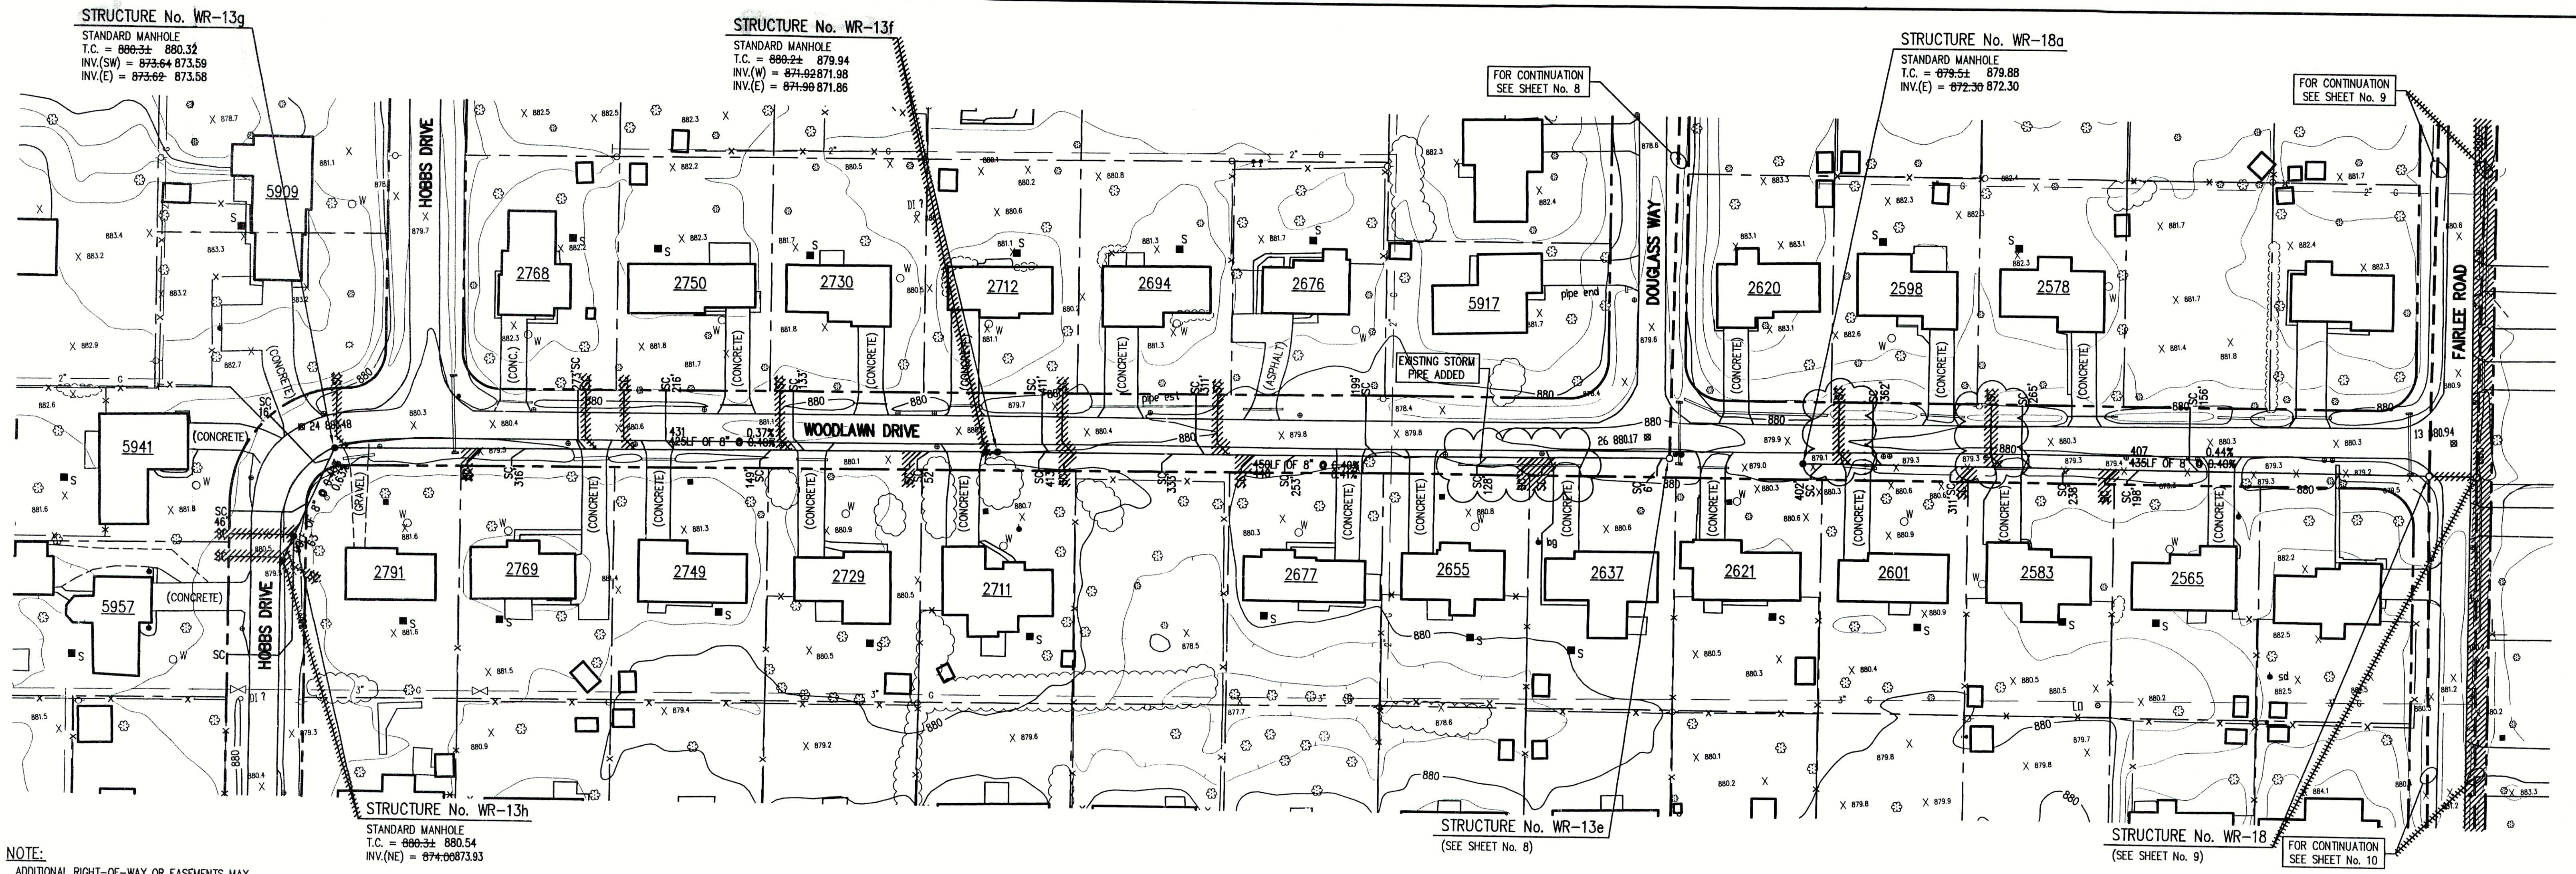

NOTE:
ADDITIONAL RIGHT-OF-WAY OR EASEMENTS MAY
NEED TO BE ACQUIRED FOR INSTALLATION OF SEWER.

**DON'T DIG BLIND
CALL BEFORE YOU DIG**
800-382-5544
800-428-5200

PER INDIANA STATE LAW IS-69-1891, IT IS
AGAINST THE LAW TO EXCAVATE WITHOUT
NOTIFYING THE UNDERGROUND LOCATION SERVICE
TWO (2) WORKING DAYS BEFORE COMMENCING WORK.

NOTE: CONTRACTOR TO VERIFY ALL UTILITY LOCATIONS
PRIOR TO THE START OF CONSTRUCTION

STRUCTURE No. WR-13h
STANDARD MANHOLE
T.C. = 880.34 880.54
INV.(NE) = 874.0873.93

STRUCTURE No. WR-13f
STANDARD MANHOLE
T.C. = 880.24 879.94
INV.(W) = 874.02871.98
INV.(E) = 874.98871.86

STRUCTURE No. WR-18a
STANDARD MANHOLE
T.C. = 879.54 879.88
INV.(E) = 872.30 872.30


GENERAL NOTES:

- ALL UTILITY LOCATIONS ARE APPROXIMATE. THE CONTRACTOR SHALL HAVE ALL UTILITIES FIELD VERIFIED AND MARKED PRIOR TO CONSTRUCTION.
- CONTRACTOR SHALL MAINTAIN A MINIMUM 10'-0" HORIZONTAL AND 18" VERTICAL SEPARATION BETWEEN SEWER AND WATER MAINS.
- ALL PROPOSED TOP OF CASTING ELEVATIONS ARE APPROXIMATE. THE CONTRACTOR SHALL ADJUST FINAL ELEVATIONS AS REQUIRED TO BE FLUSH WITH PAVEMENT.
- ALL SEWER TRENCHES SHALL BE BACKFILLED WITH FULL DEPTH COMPACTED GRANULAR BACKFILL ("B" BORROW) UNDER OR WITHIN 5' OF EDGE OF PAVEMENT.
- THE CONTRACTOR SHALL VISIT THE SITE PRIOR TO BID TO BECOME FAMILIAR WITH ALL SITE CONDITIONS.
- THE CONTRACTOR SHALL PROVIDE THE REQUIRED MEANS FOR MAINTAINING SAFE TRAFFIC AT ALL TIMES.
- CONTRACTOR SHALL RESTORE ALL DISTURBED LAWN AREAS, STREETS, WALKS, DRIVES, ETC. AS SHOWN ON DRAWINGS, IN THE SPECIFICATIONS, OR TO AT LEAST PRE-EXISTING CONDITIONS.
- ALL UTILITY CROSSINGS SHALL BE PROTECTED AND SUPPORTED WITH GRANULAR FILL OR CONCRETE AS REQUIRED PER THE DETAIL SHEET.

- LEGEND:**
- TREE
 - POWER POLE
 - GUY WIRE
 - FIRE HYDRANT
 - MAILBOX
 - FLAGPOLE
 - SPOT SHOT
 - CONTOUR
 - FENCE
 - EXIST. SANITARY SEWER w/ MANHOLE
 - NEW SANITARY SEWER w/ MANHOLE
 - NEW SANITARY SERVICE CONNECTION
 - WATER LINE
 - GAS LINE
 - UNDERGROUND ELECTRIC LINE
 - UNDERGROUND TELEPHONE LINE
 - APPROX. RIGHT-OF-WAY
 - APPROX. CORPORATE LIMITS
 - APPROX. PROPERTY LINE
 - EXISTING WATER WELL
 - EXISTING SEPTIC TANK



SCALE:
HORIZONTAL 1" = 50'
VERTICAL 1" = 5'

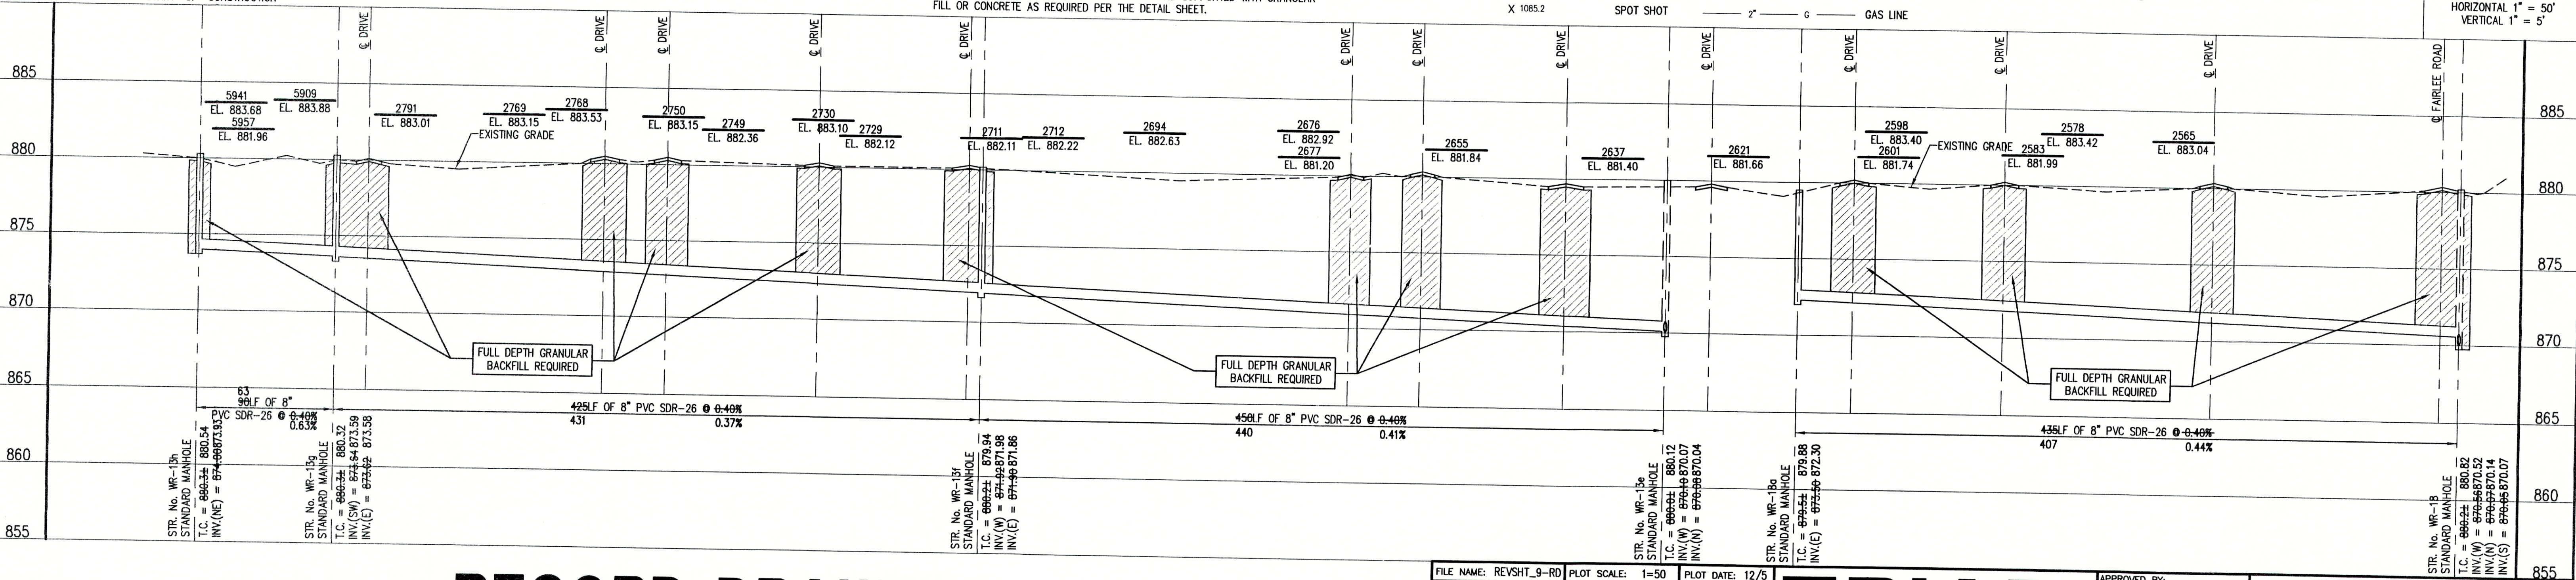

STR. No. WR-13a
STANDARD MANHOLE
T.C. = 880.34 880.54
INV.(NE) = 874.0873.93

STR. No. WR-13g
STANDARD MANHOLE
T.C. = 880.34 880.32
INV.(SW) = 874.64873.59
INV.(E) = 874.62873.58

STR. No. WR-13i
STANDARD MANHOLE
T.C. = 880.24 879.94
INV.(W) = 874.02871.98
INV.(E) = 874.98871.86

STR. No. WR-13e
STANDARD MANHOLE
T.C. = 880.12 880.12
INV.(W) = 874.04870.07
INV.(N) = 874.04870.04

STR. No. WR-18b
STANDARD MANHOLE
T.C. = 879.54 879.88
INV.(E) = 872.30 872.30

STR. No. WR-18
STANDARD MANHOLE
T.C. = 880.24 880.82
INV.(W) = 874.64870.52
INV.(N) = 874.64870.14
INV.(S) = 874.64870.07


RECORD DRAWING

February 15, 2001

NOTE:
THE CONTRACTOR SHALL INCLUDE IN THE COSTS FOR SANITARY PIPE, ALL WATER SERVICE RECONNECTIONS, STORM SEWER RECONNECTION, WATER MAIN RELOCATIONS, CONCRETE RECONSTRUCTION, AND SIDEWALK RECONSTRUCTION AS REQUIRED TO INSTALL NEW WORK AS SHOWN ON THE DRAWINGS.

FILE NAME: REVSHIT_9-RD		PLOT SCALE: 1=50	PLOT DATE: 12/5
NO.	DATE	DESCRIPTION	BY

TRIAD ASSOCIATES INC.
INDIANAPOLIS, INDIANA

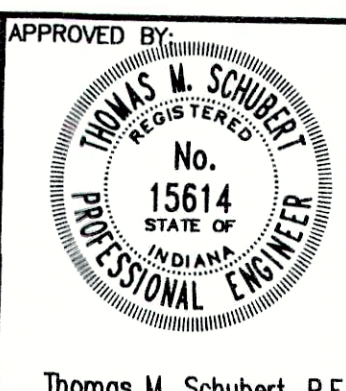

WOODED RIDGE SUBDIVISION
FALL CREEK REGIONAL WASTE DISTRICT



PLAN AND PROFILE

DRAWN BY: DAP
DATE: 04/12/98
SCALE: AS NOTED
PROJECT No. 98008A
SHEET No. 11

DESIGNED BY: D.A. Pauling
CHECKED BY: James W. Frazell, P.E.

18

WOODED RIDGE SUBDIVISION FALL CREEK REGIONAL WASTE DISTRICT				840
PLAN AND PROFILE				
DRAWN BY: DAP	DATE 04/12/98	PROJECT No. 98008A	SHEET No. 12	
DESIGNED BY: D.A. Pauling		18		
CHECKED BY: James W. Frozell, P.E.		OF		

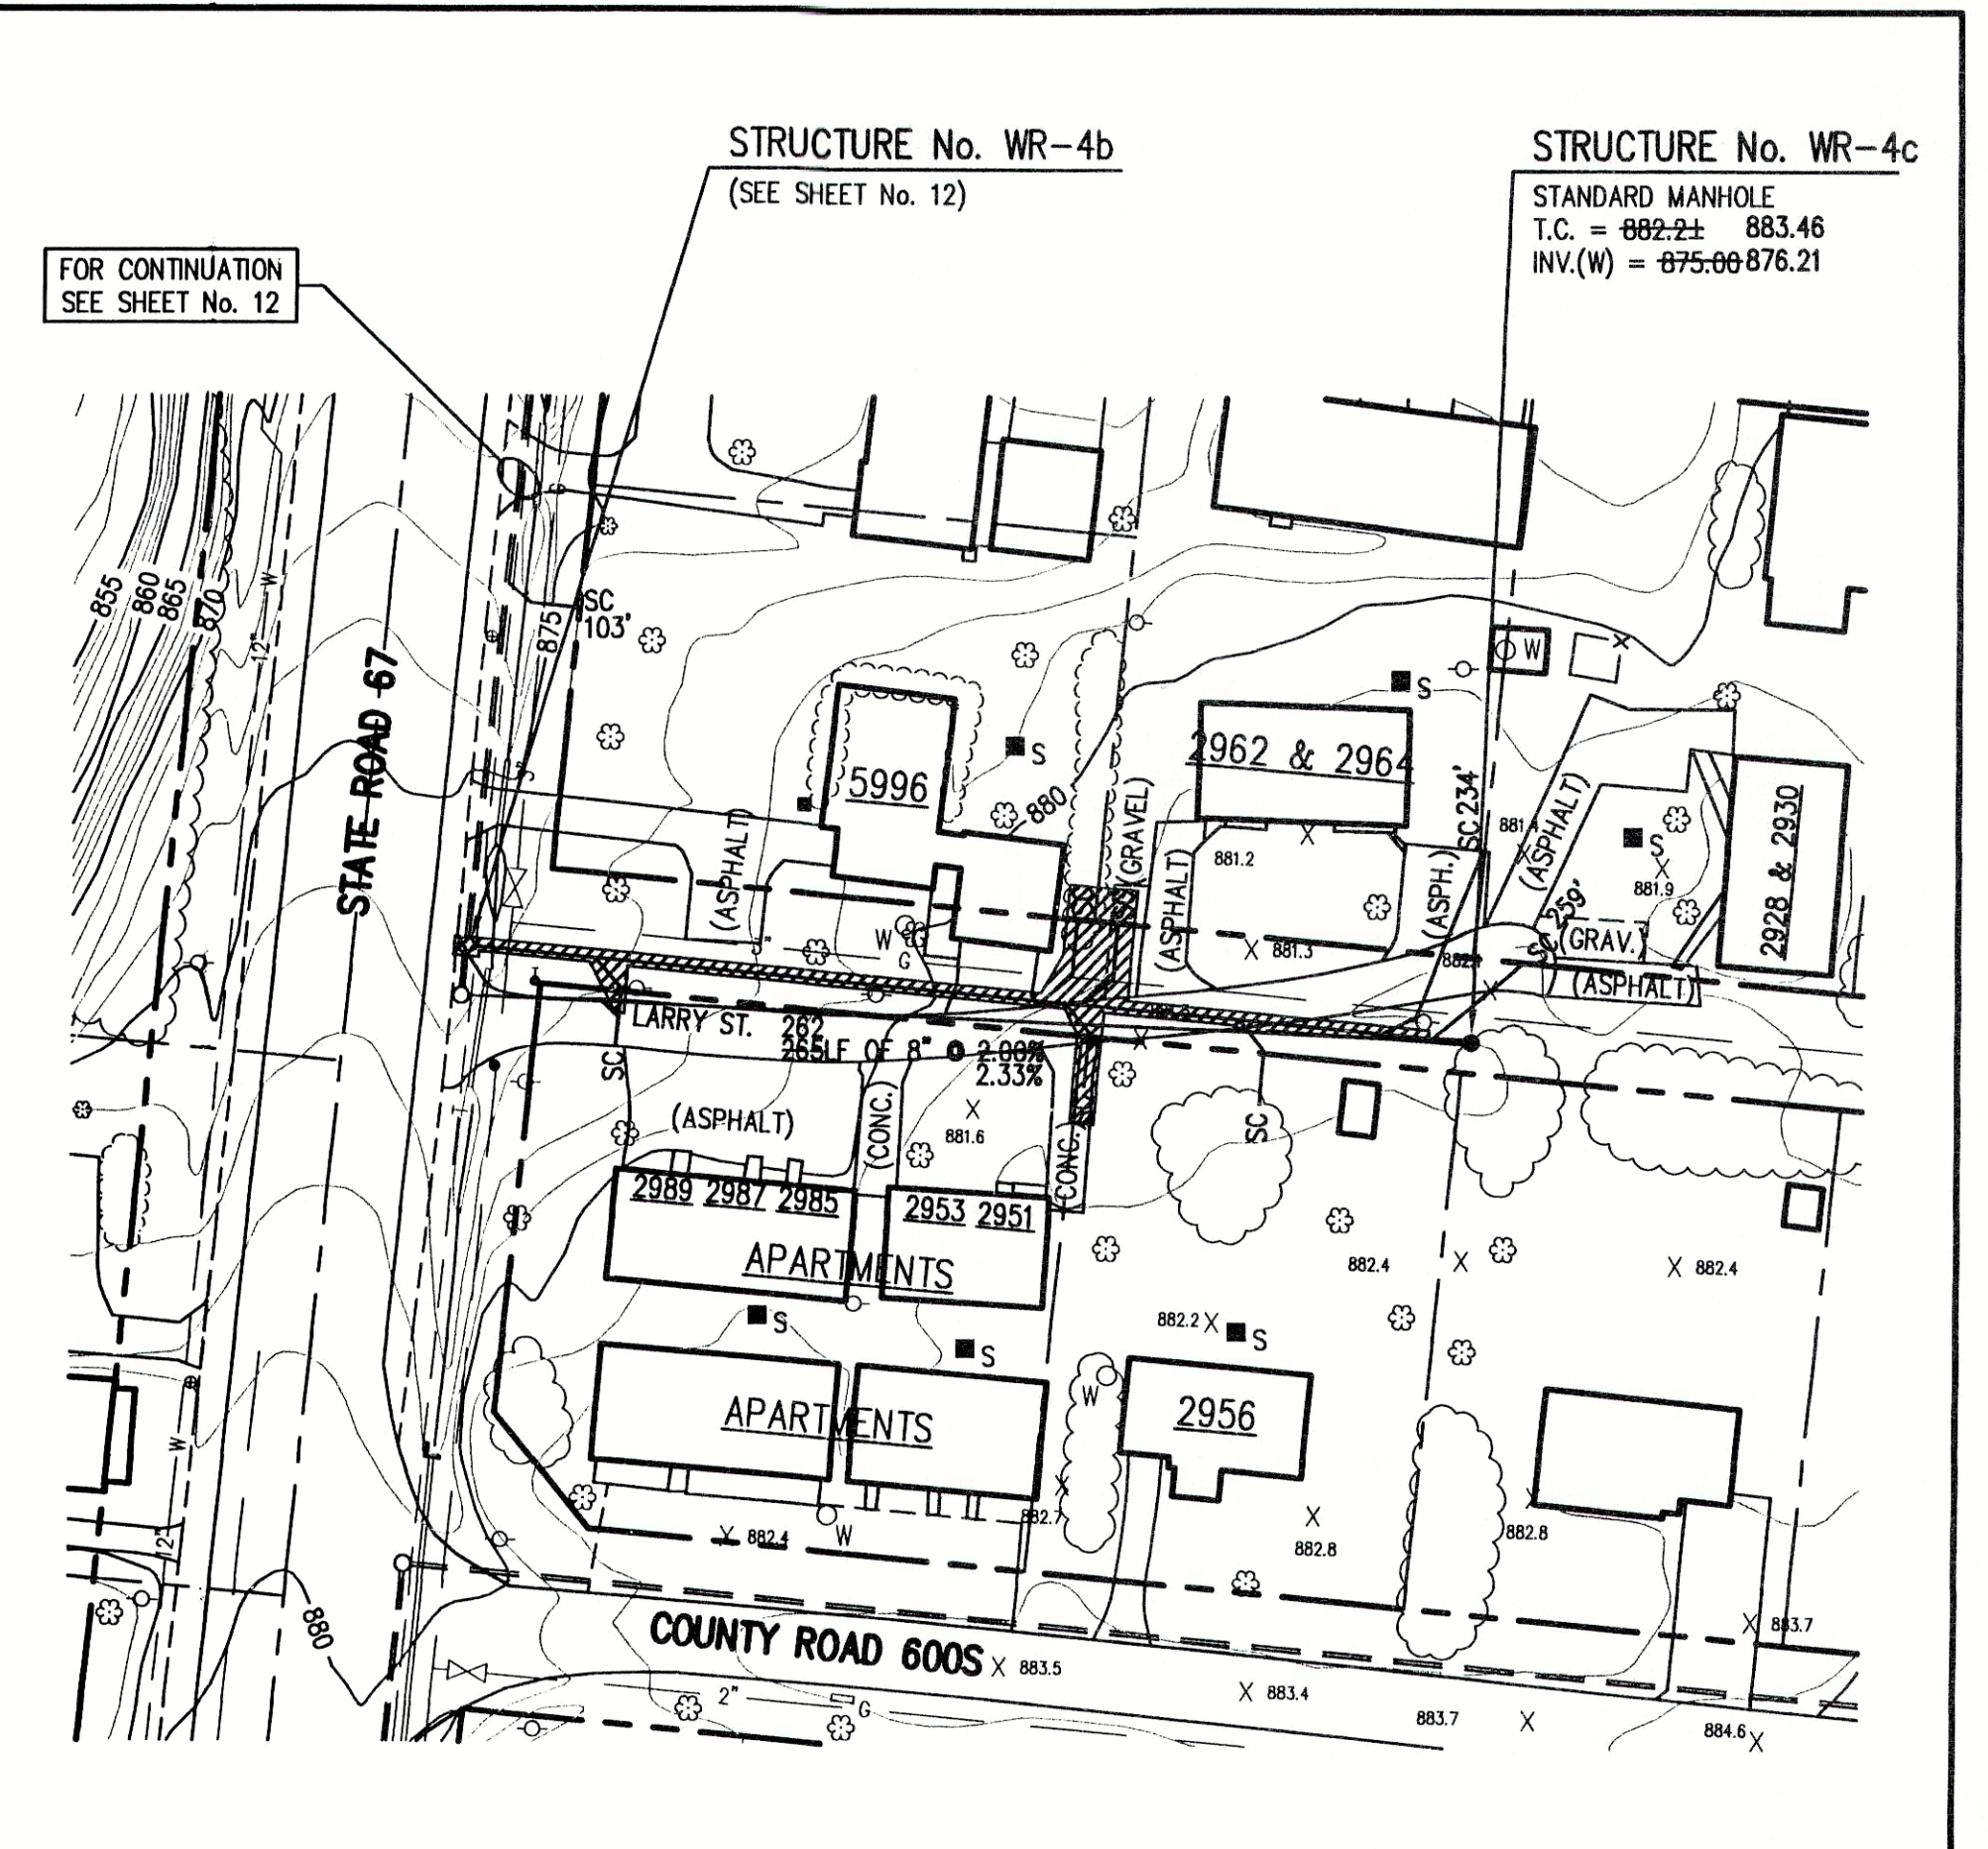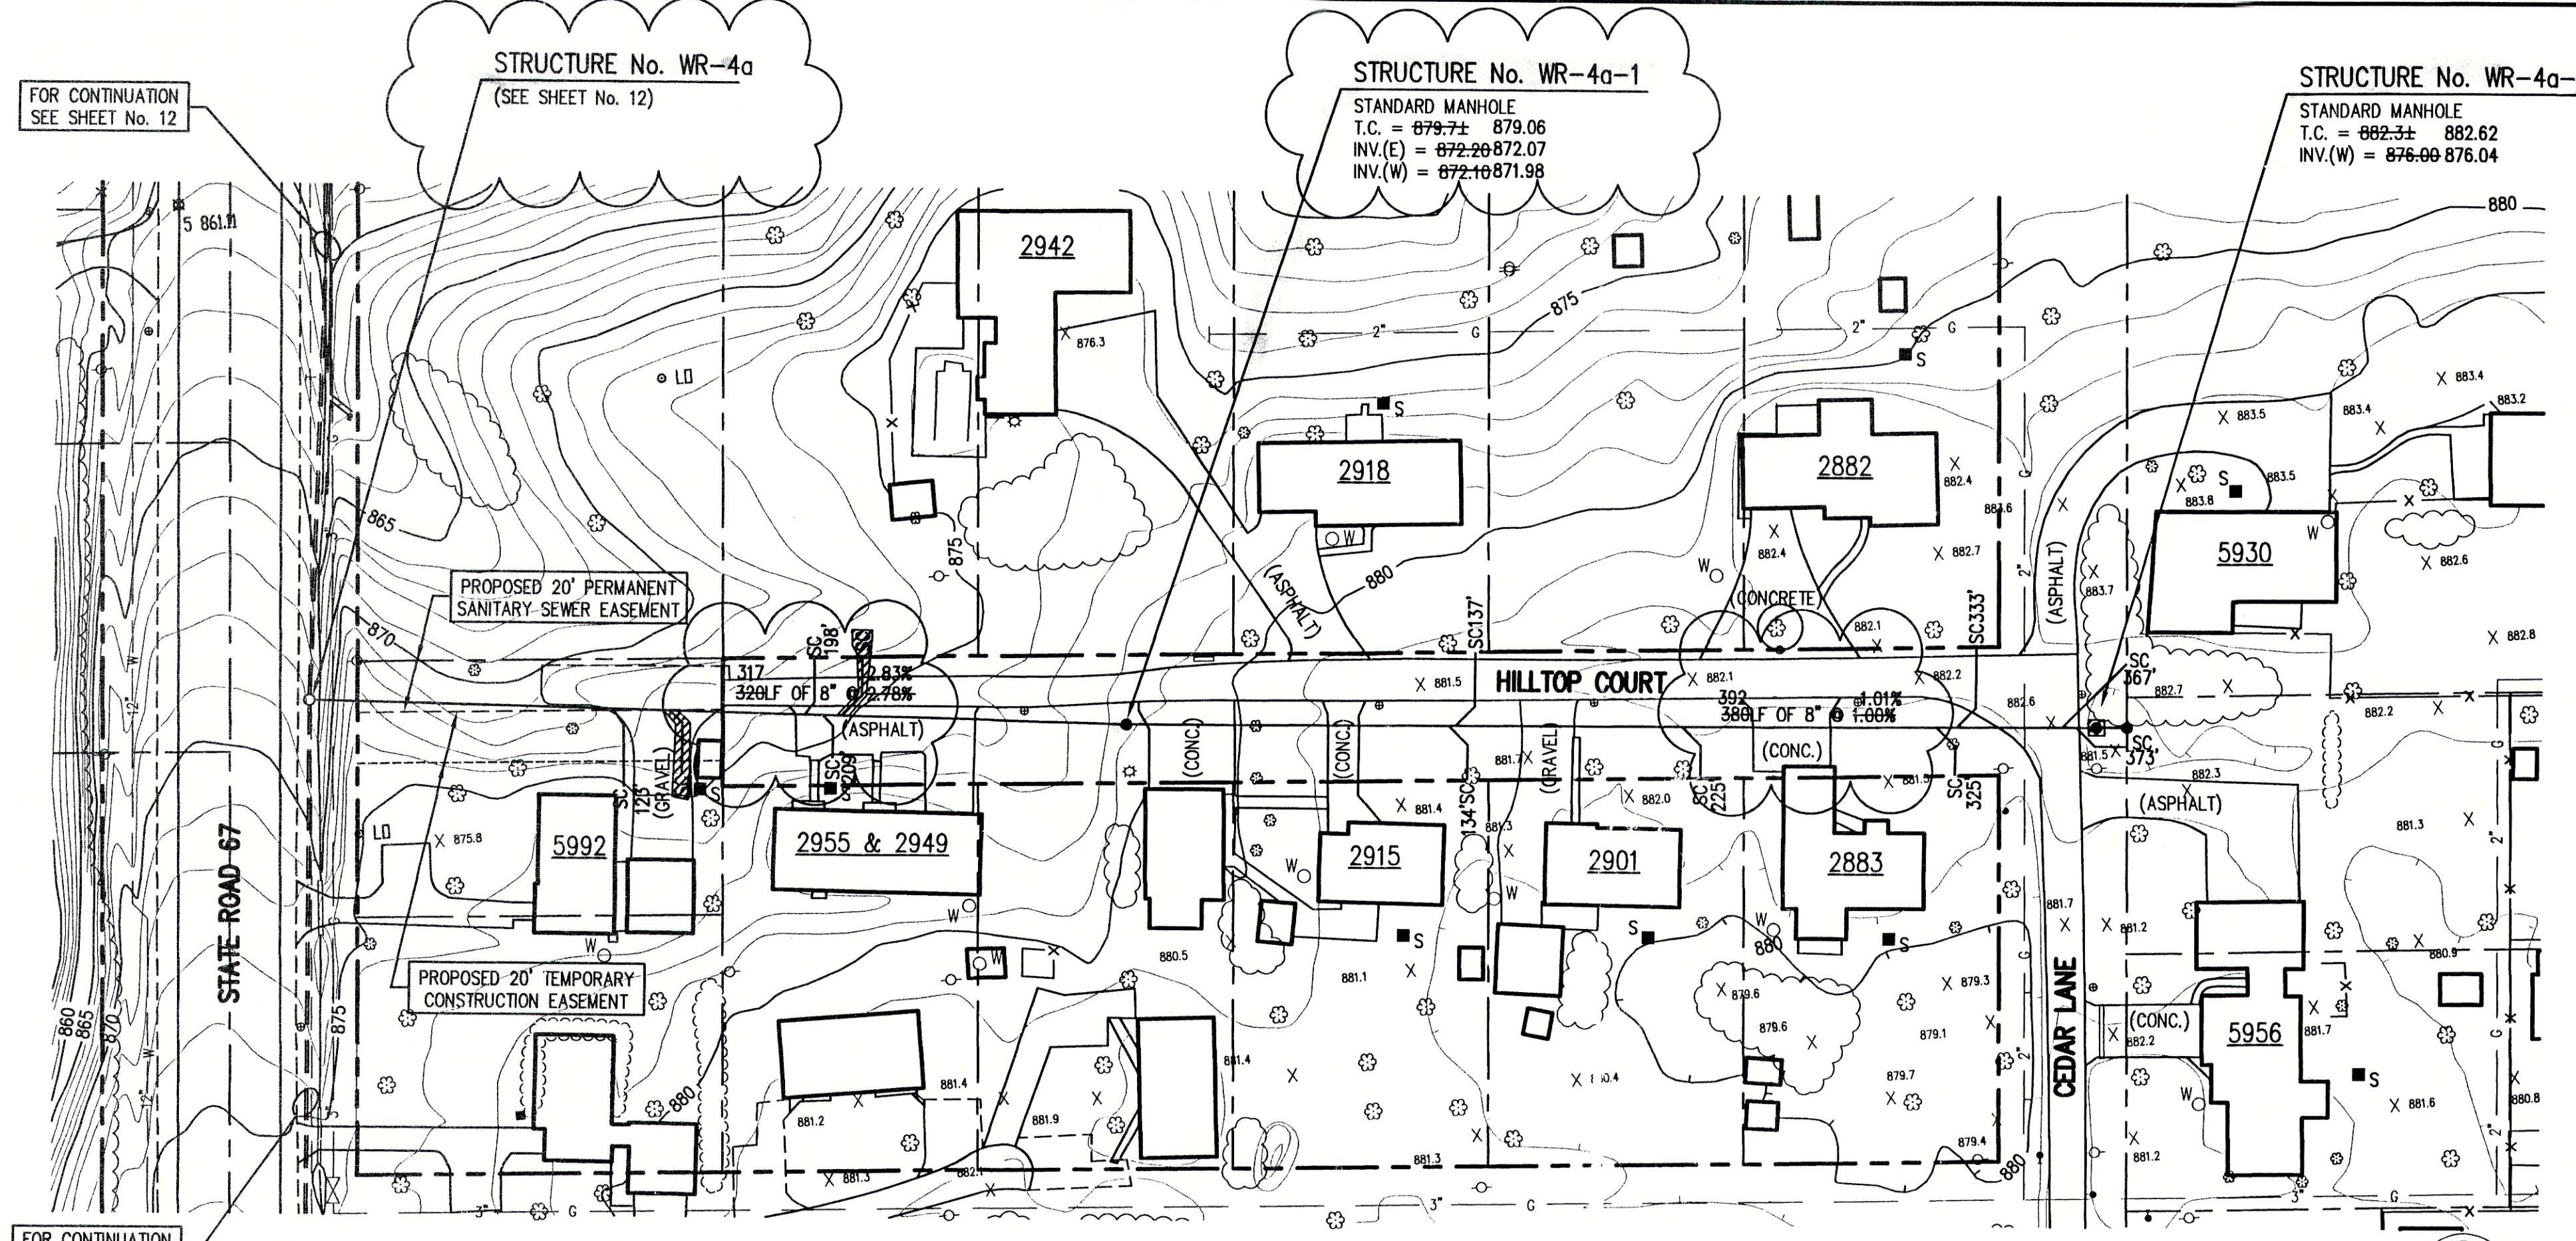



- LEGEND:**
- TREE
 - POWER POLE
 - GUY WIRE
 - FIRE HYDRANT
 - ^{MB} MAILBOX
 - FP_o FLAGPOLE
 - X 1085.2 SPOT SHOT
 - 1085 CONTOUR
 - X—X— FENCE
 - MH— EXIST. SANITARY SEWER w/ MANHOLE
 - SC— NEW SANITARY SEWER w/ MANHOLE
 - SC— NEW SANITARY SERVICE CONNECTION
 - 4"—W— WATER LINE
 - 2"—G— GAS LINE
 - E— UNDERGROUND ELECTRIC LINE
 - T— UNDERGROUND TELEPHONE LINE
 - APPROX. RIGHT-OF-WAY
 - APPROX. CORPORATE LIMITS
 - APPROX. PROPERTY LINE
 - W EXISTING WATER WELL
 - S EXISTING SEPTIC TANK
- GENERAL NOTES:**
- ALL UTILITY LOCATIONS ARE APPROXIMATE. THE CONTRACTOR SHALL HAVE ALL UTILITIES FIELD VERIFIED AND MARKED PRIOR TO CONSTRUCTION.
 - CONTRACTOR SHALL MAINTAIN A MINIMUM 10'-0" HORIZONTAL AND 18" VERTICAL SEPARATION BETWEEN SEWER AND WATER MAINS.
 - ALL PROPOSED TOP OF CASTING ELEVATIONS ARE APPROXIMATE. THE CONTRACTOR SHALL ADJUST FINAL ELEVATIONS AS REQUIRED TO BE FLUSH WITH PAVEMENT.
 - ALL SEWER TRENCHES SHALL BE BACKFILLED WITH FULL DEPTH COMPACTED GRANULAR BACKFILL ("B" BORROW) UNDER OR WITHIN 5' OF EDGE OF PAVEMENT.
 - THE CONTRACTOR SHALL VISIT THE SITE PRIOR TO BID TO BECOME FAMILIAR WITH ALL SITE CONDITIONS.
 - THE CONTRACTOR SHALL PROVIDE THE REQUIRED MEANS FOR MAINTAINING SAFE TRAFFIC AT ALL TIMES.
 - CONTRACTOR SHALL RESTORE ALL DISTURBED LAWN AREAS, STREETS, WALKS, DRIVES, ETC. AS SHOWN ON DRAWINGS, IN THE SPECIFICATIONS, OR TO AT LEAST PRE-EXISTING CONDITIONS.
 - ALL UTILITY CROSSINGS SHALL BE PROTECTED AND SUPPORTED WITH GRANULAR FILL OR CONCRETE AS REQUIRED PER THE DETAIL SHEET.

NOTE:
ADDITIONAL RIGHT-OF-WAY OR EASEMENTS MAY NEED TO BE ACQUIRED FOR INSTALLATION OF SEWER.

**DON'T DIG BLIND
CALL BEFORE YOU DIG**
TOLL FREE
1-800-382-5544
OR
1-800-428-5200

PER INDIANA STATE LAW IS-69-1991, IT IS AGAINST THE LAW TO EXCAVATE WITHOUT NOTIFYING THE UNDERGROUND LOCATION SERVICE TWO (2) WORKING DAYS BEFORE COMMENCING WORK.

NOTE: CONTRACTOR TO VERIFY ALL UTILITY LOCATIONS PRIOR TO THE START OF CONSTRUCTION

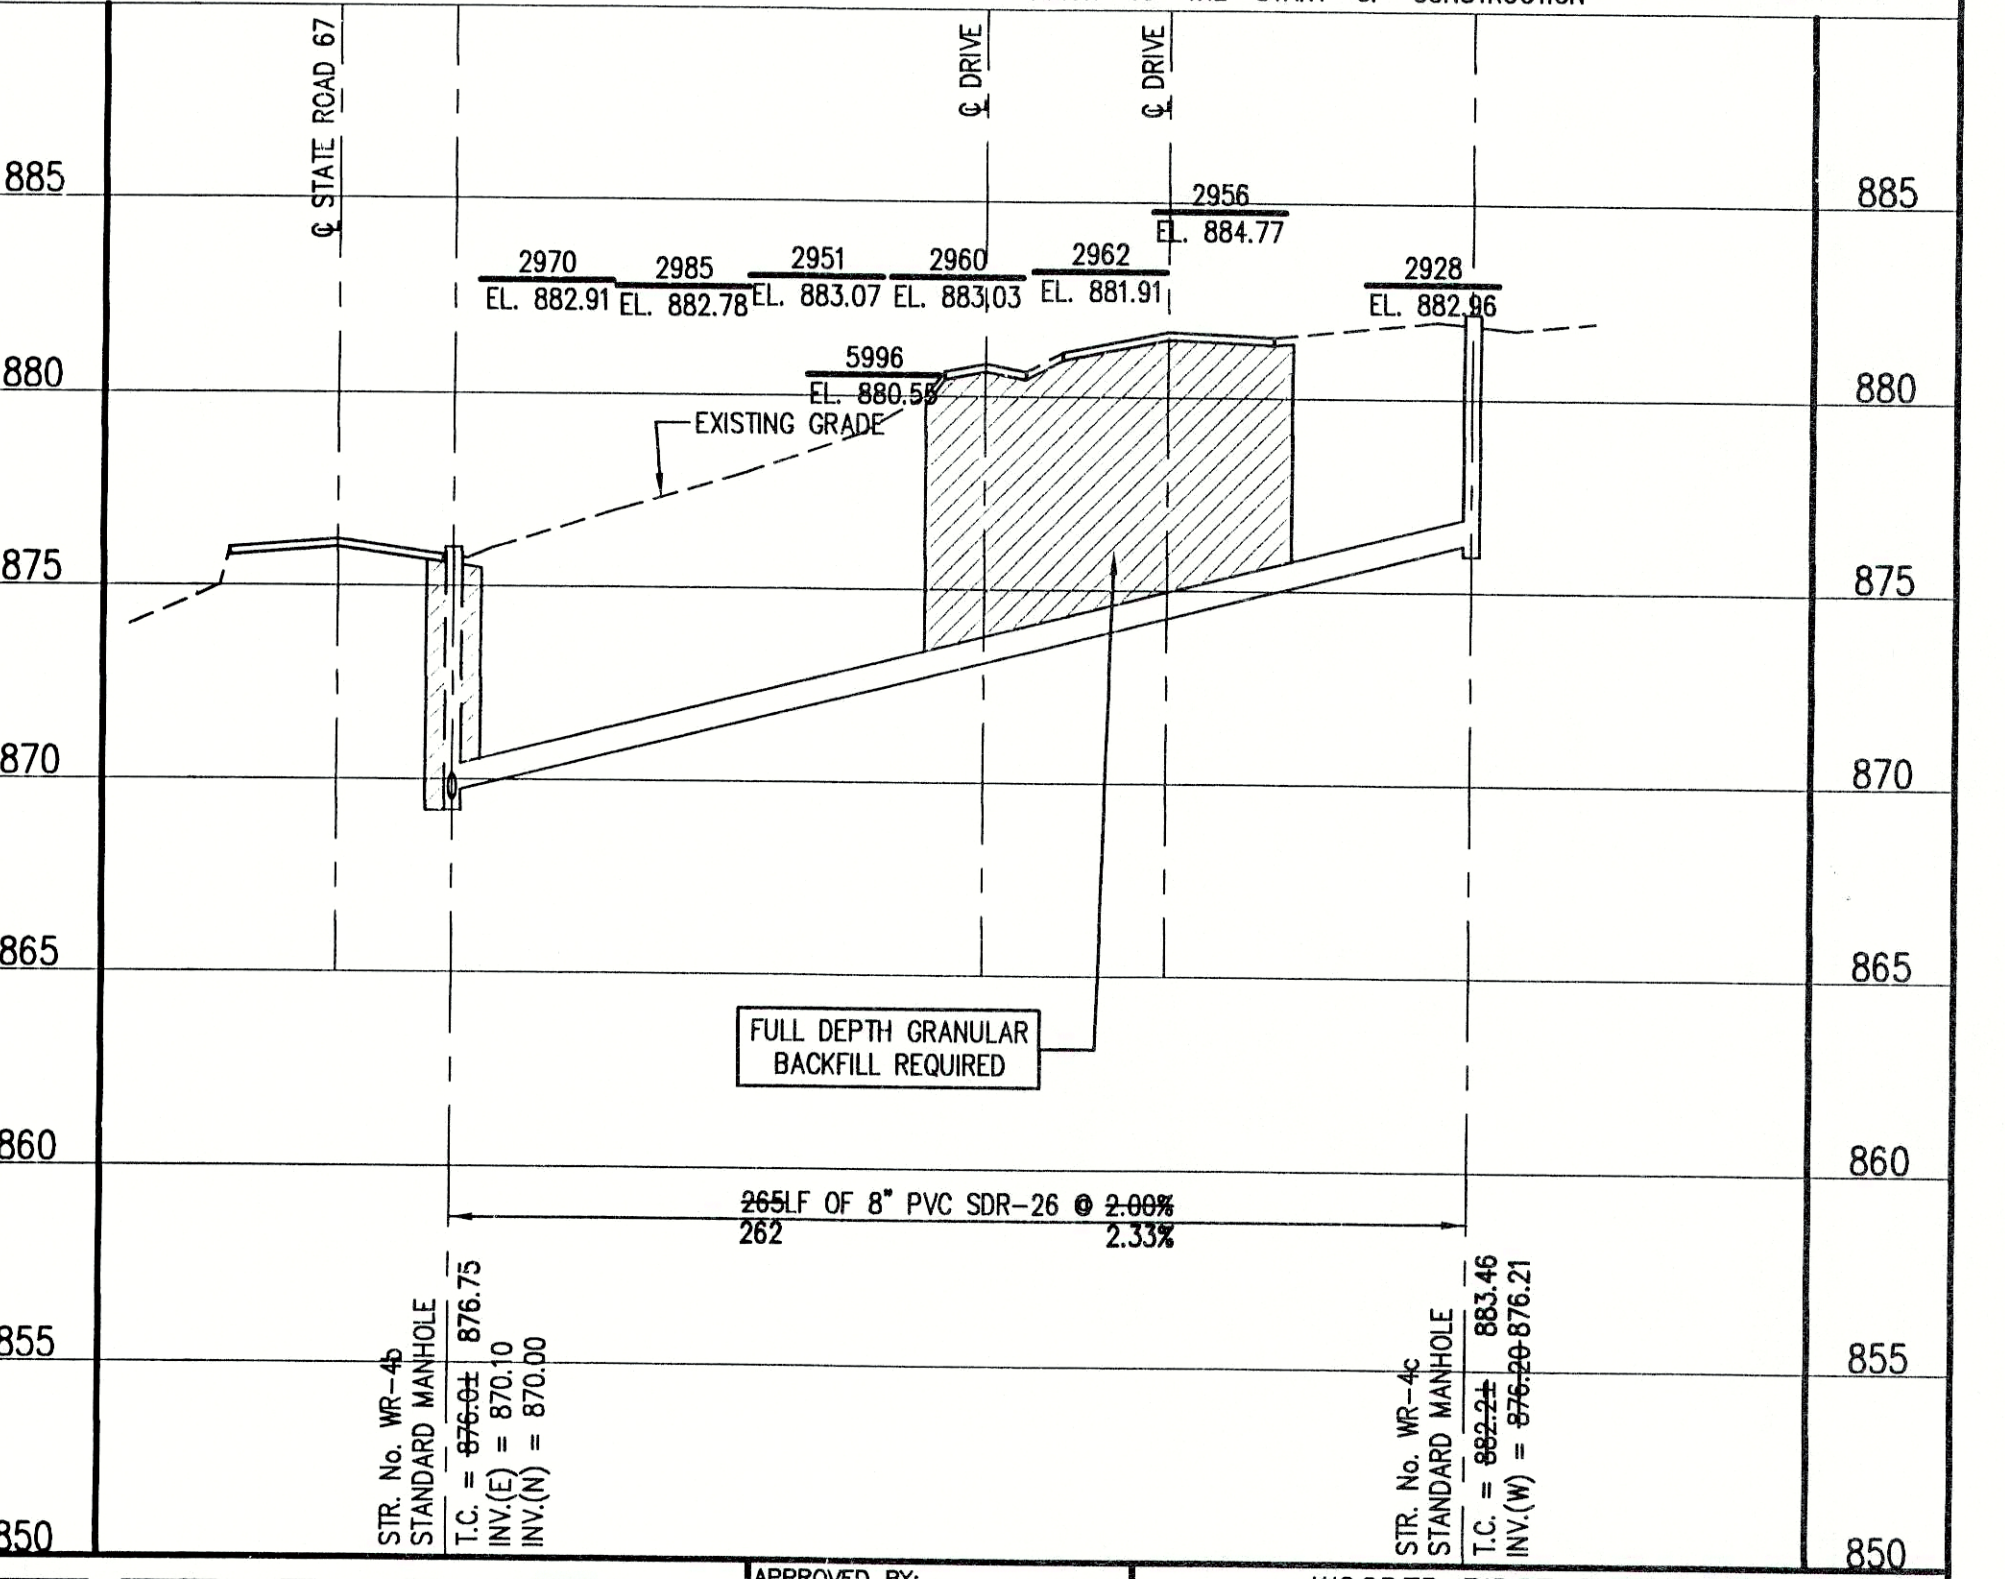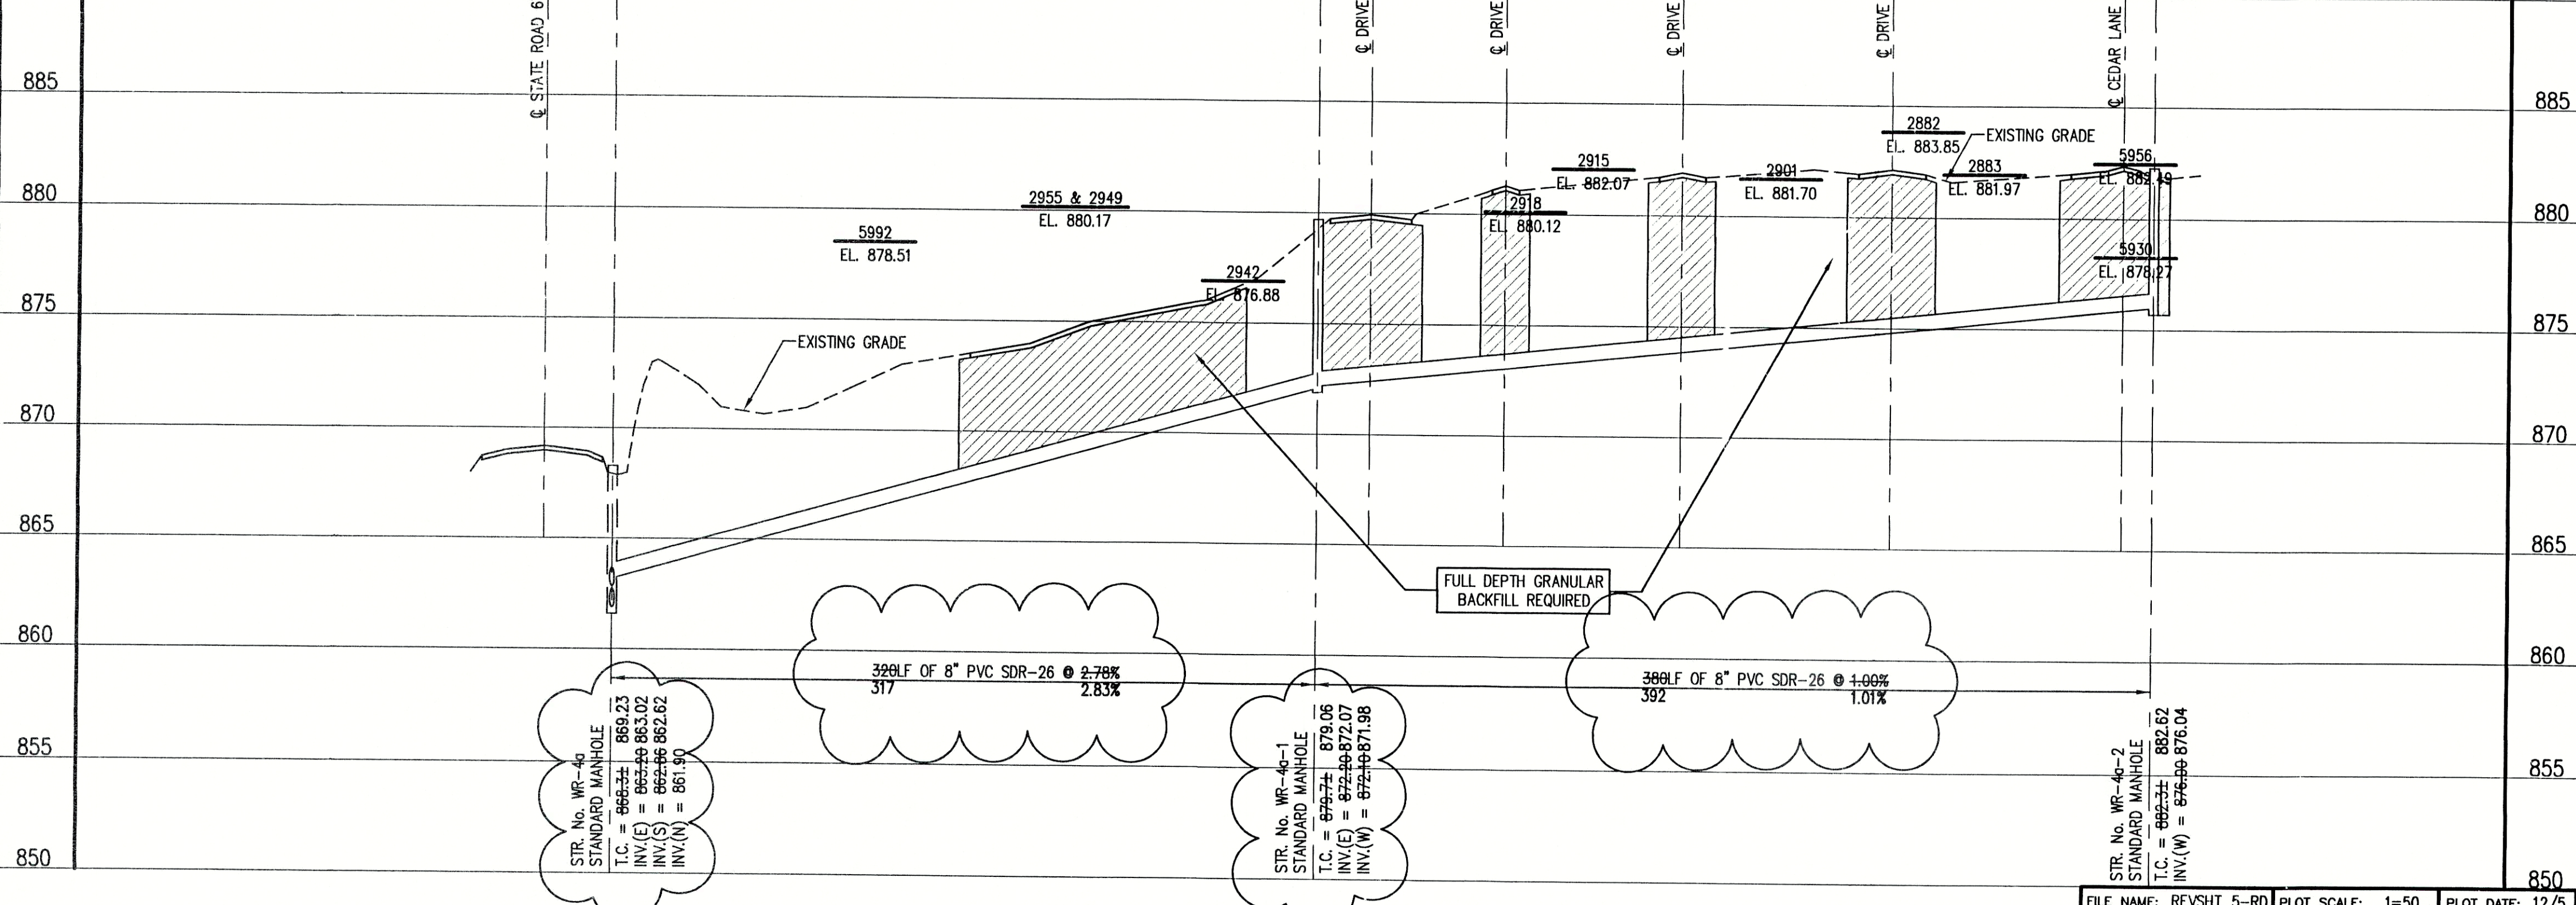

RECORD DRAWING February 15, 2001

NOTE:
THE CONTRACTOR SHALL INCLUDE IN THE COSTS FOR SANITARY PIPE, ALL WATER SERVICE RECONNECTIONS, STORM SEWER RECONNECTION, WATER MAIN RELOCATIONS, CONCRETE RECONSTRUCTION, AND SIDEWALK RECONSTRUCTION AS REQUIRED TO INSTALL NEW WORK AS SHOWN ON THE DRAWINGS.

FILE NAME: REVSH1_5-RD PLOT SCALE: 1=50 PLOT DATE: 12/5			
NO.	DATE	DESCRIPTION	BY

TRIAD ASSOCIATES INC.
INDIANAPOLIS, INDIANA

APPROVED BY:
THOMAS M. SCHUBERT
REGISTERED PROFESSIONAL ENGINEER
No. 15614
STATE OF INDIANA


WOODED RIDGE SUBDIVISION
FALL CREEK REGIONAL WATER DISTRICT

PLAN AND PROFILE

DRAWN BY: DATE 04/12/98 PROJECT No. 98008A SHEET No. 13 OF 18

DESIGNED BY: D.A. Pauling

CHECKED BY: James W. Frazell, P.E.

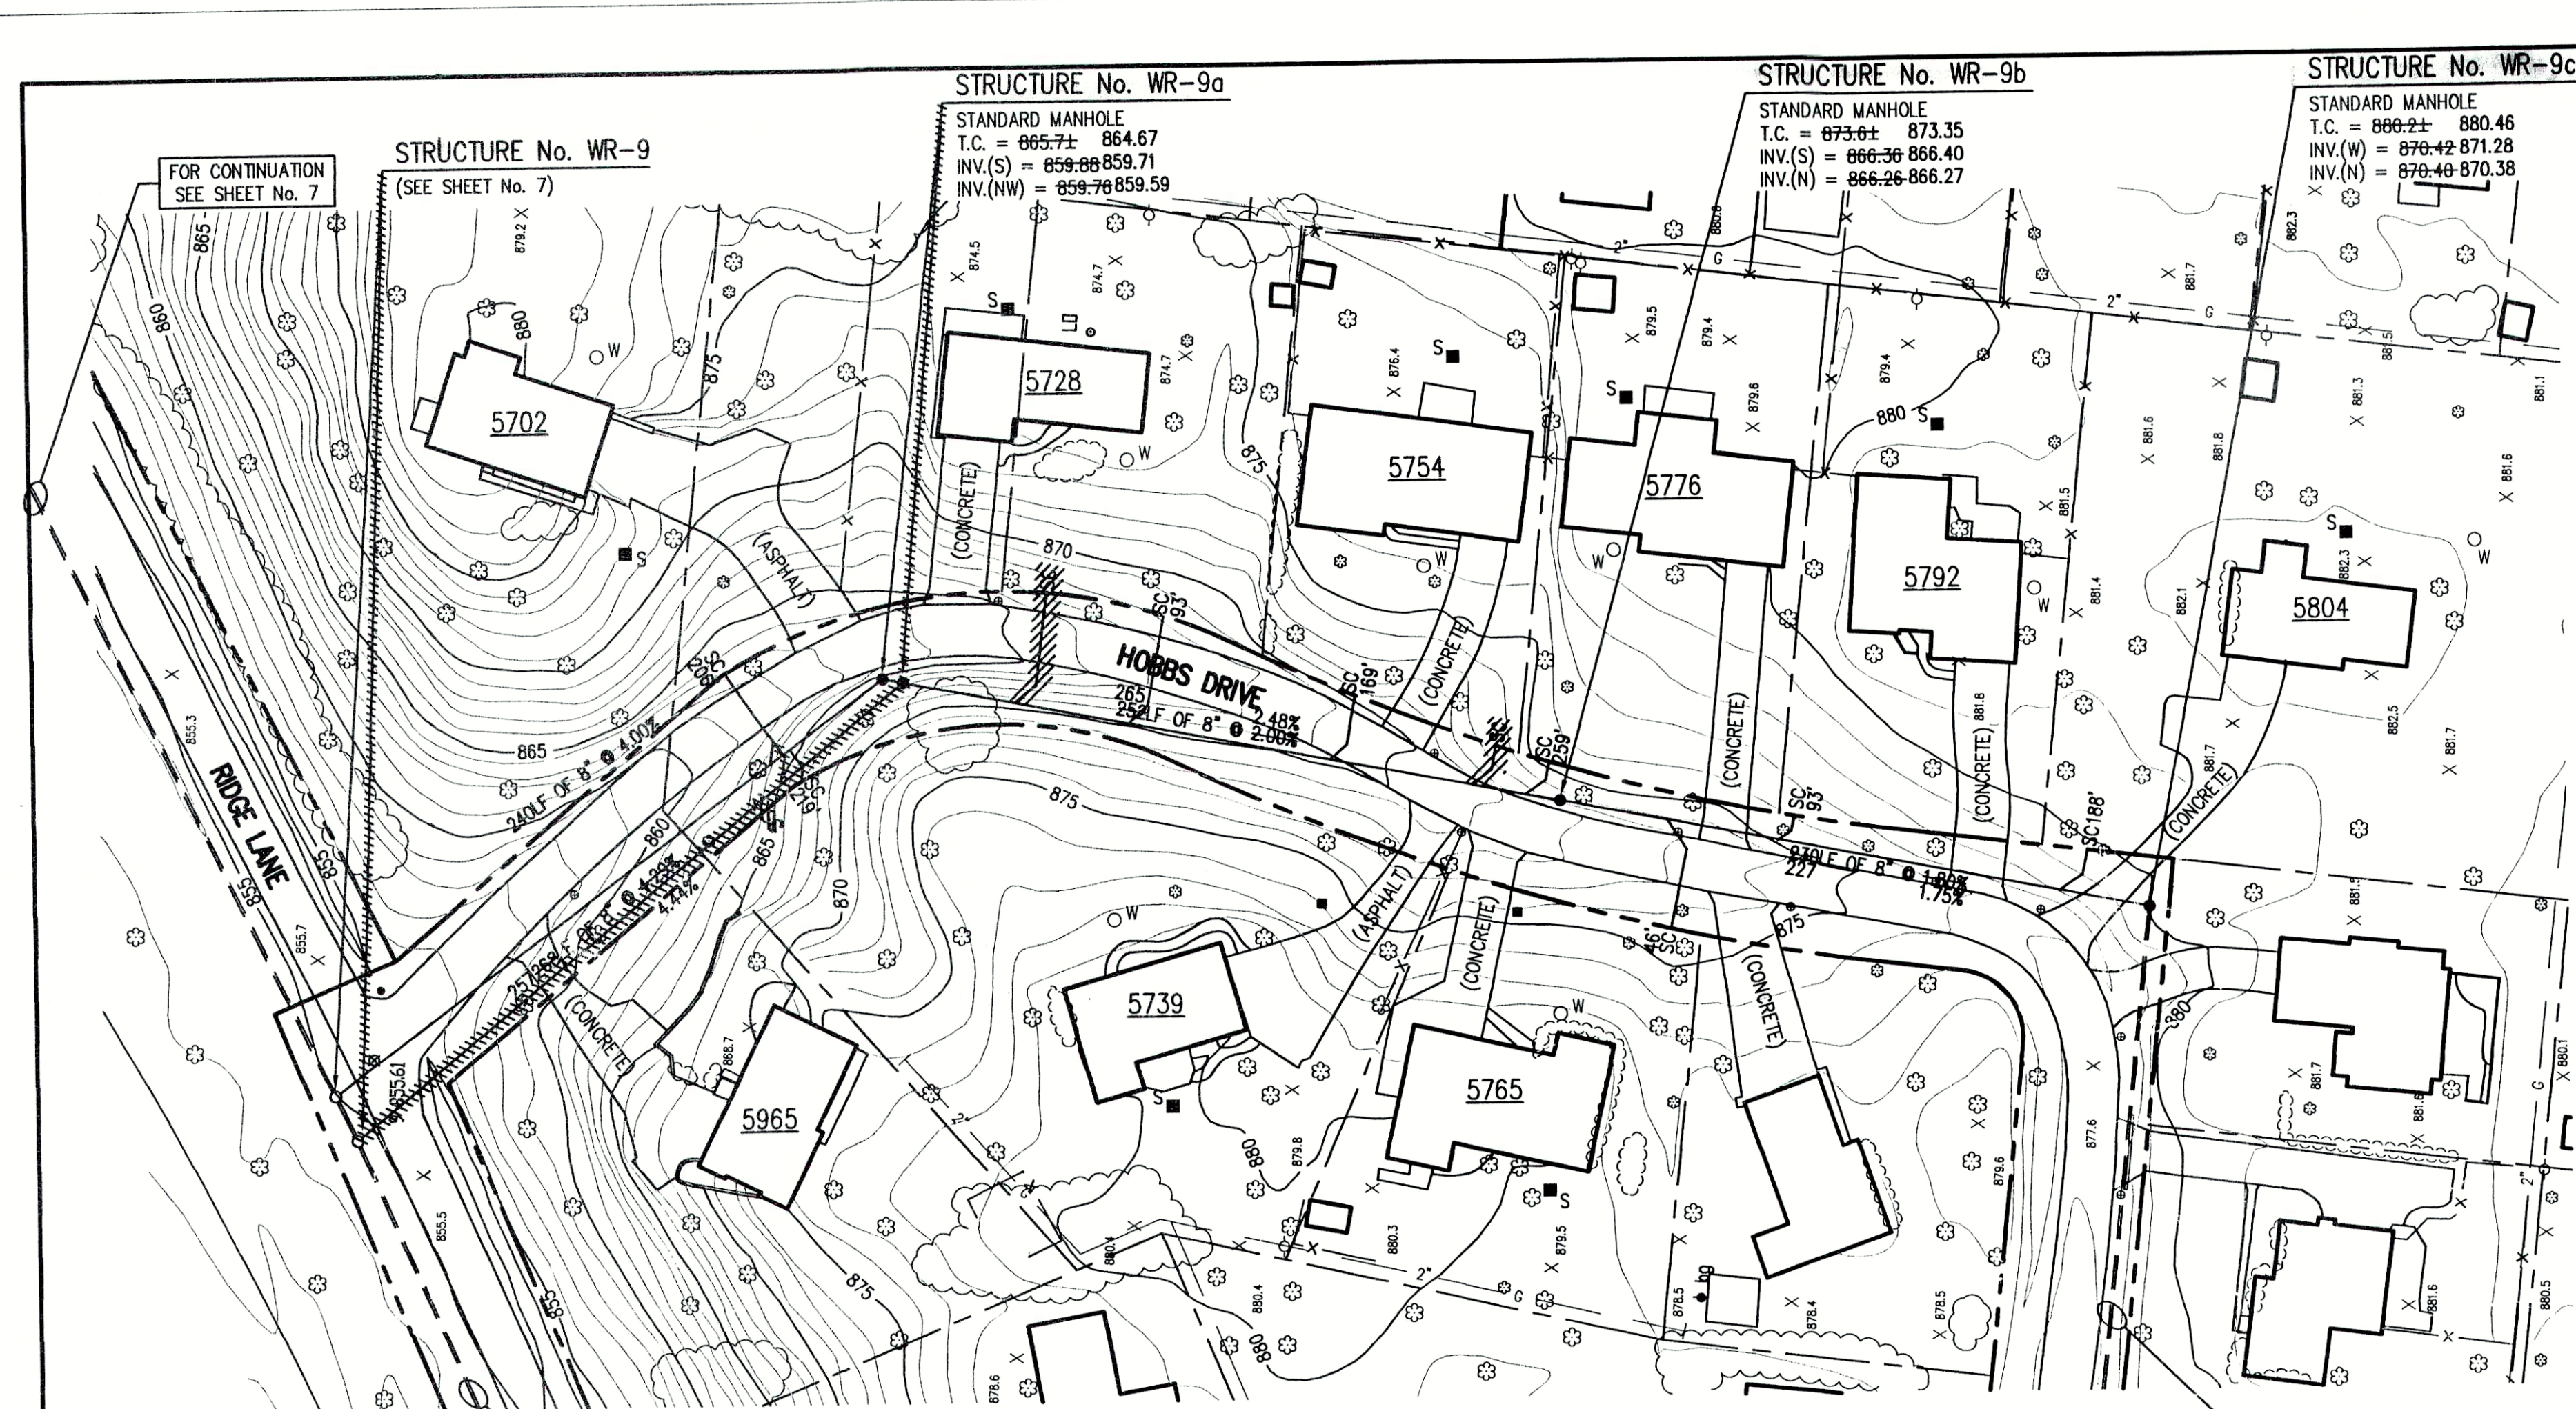

NOTE:
ADDITIONAL RIGHT-OF-WAY OR EASEMENTS MAY
NEED TO BE ACQUIRED FOR INSTALLATION OF SEWER.



DON'T DIG BLIND
CALL BEFORE YOU DIG
1-800-382-5544
1-800-428-5200


PER INDIANA STATE LAW IS-69-189, IT IS
AGAINST THE LAW TO EXCAVATE WITHOUT
NOTIFYING THE UNDERGROUND LOCATION SERVICE
TWO (2) WORKING DAYS BEFORE COMMENCING WORK.

NOTE: CONTRACTOR TO VERIFY ALL UTILITY LOCATIONS
PRIOR TO THE START OF CONSTRUCTION

FOR CONTINUATION
SEE SHEET No. 7

GENERAL NOTES:


- ALL UTILITY LOCATIONS ARE APPROXIMATE. THE CONTRACTOR SHALL HAVE ALL UTILITIES FIELD VERIFIED AND MARKED PRIOR TO CONSTRUCTION.
- CONTRACTOR SHALL MAINTAIN A MINIMUM 10'-0" HORIZONTAL AND 18" VERTICAL SEPARATION BETWEEN SEWER AND WATER MAINS.
- ALL PROPOSED TOP OF CASTING ELEVATIONS ARE APPROXIMATE. THE CONTRACTOR SHALL ADJUST FINAL ELEVATIONS AS REQUIRED TO BE FLUSH WITH PAVEMENT.
- ALL SEWER TRENCHES SHALL BE BACKFILLED WITH FULL DEPTH COMPACTED GRANULAR BACKFILL ("B" BORROW) UNDER OR WITHIN 5' OF EDGE OF PAVEMENT.
- THE CONTRACTOR SHALL VISIT THE SITE PRIOR TO BID TO BECOME FAMILIAR WITH ALL SITE CONDITIONS.
- THE CONTRACTOR SHALL PROVIDE THE REQUIRED MEANS FOR MAINTAINING SAFE TRAFFIC AT ALL TIMES.
- CONTRACTOR SHALL RESTORE ALL DISTURBED LAWN AREAS, STREETS, WALKS, DRIVES, ETC. AS SHOWN ON DRAWINGS, IN THE SPECIFICATIONS, OR TO AT LEAST PRE-EXISTING CONDITIONS.
- ALL UTILITY CROSSINGS SHALL BE PROTECTED AND SUPPORTED WITH GRANULAR FILL OR CONCRETE AS REQUIRED PER THE DETAIL SHEET.

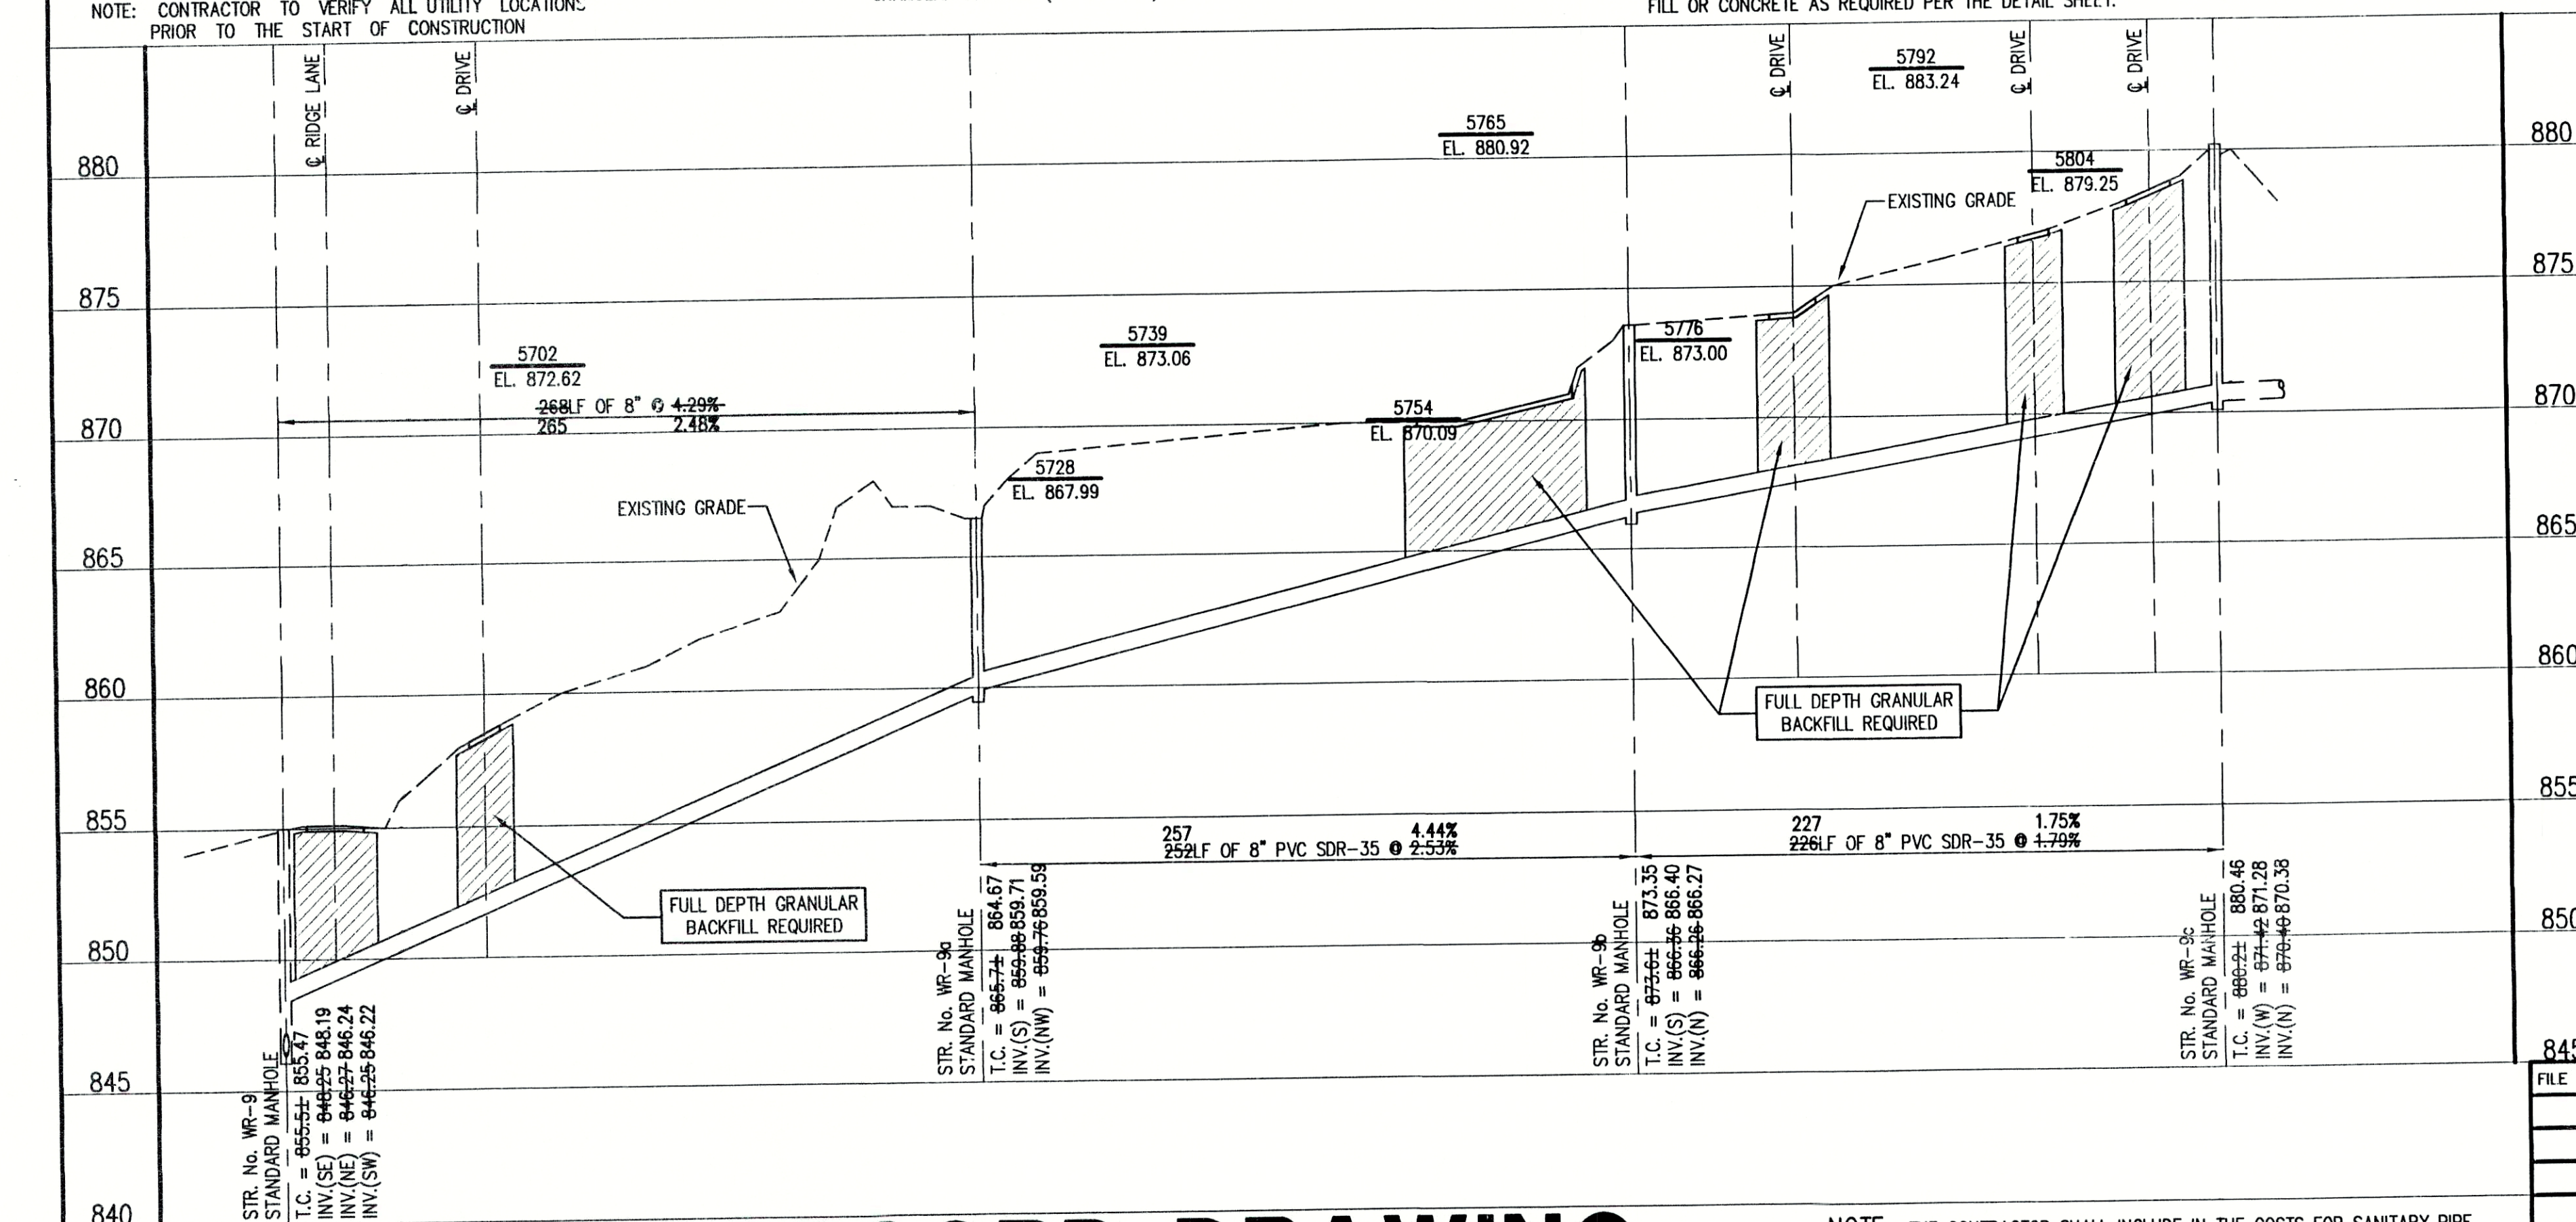

RECORD DRAWING

February 15, 2001

NOTE: THE CONTRACTOR SHALL INCLUDE IN THE COSTS FOR SANITARY PIPE, ALL WATER SERVICE RECONNECTIONS, STORM SEWER RECONNECTION, WATER MAIN RELOCATIONS, CONCRETE RECONSTRUCTION, AND SIDEWALK RECONSTRUCTION AS REQUIRED TO INSTALL NEW WORK AS SHOWN ON THE DRAWINGS.

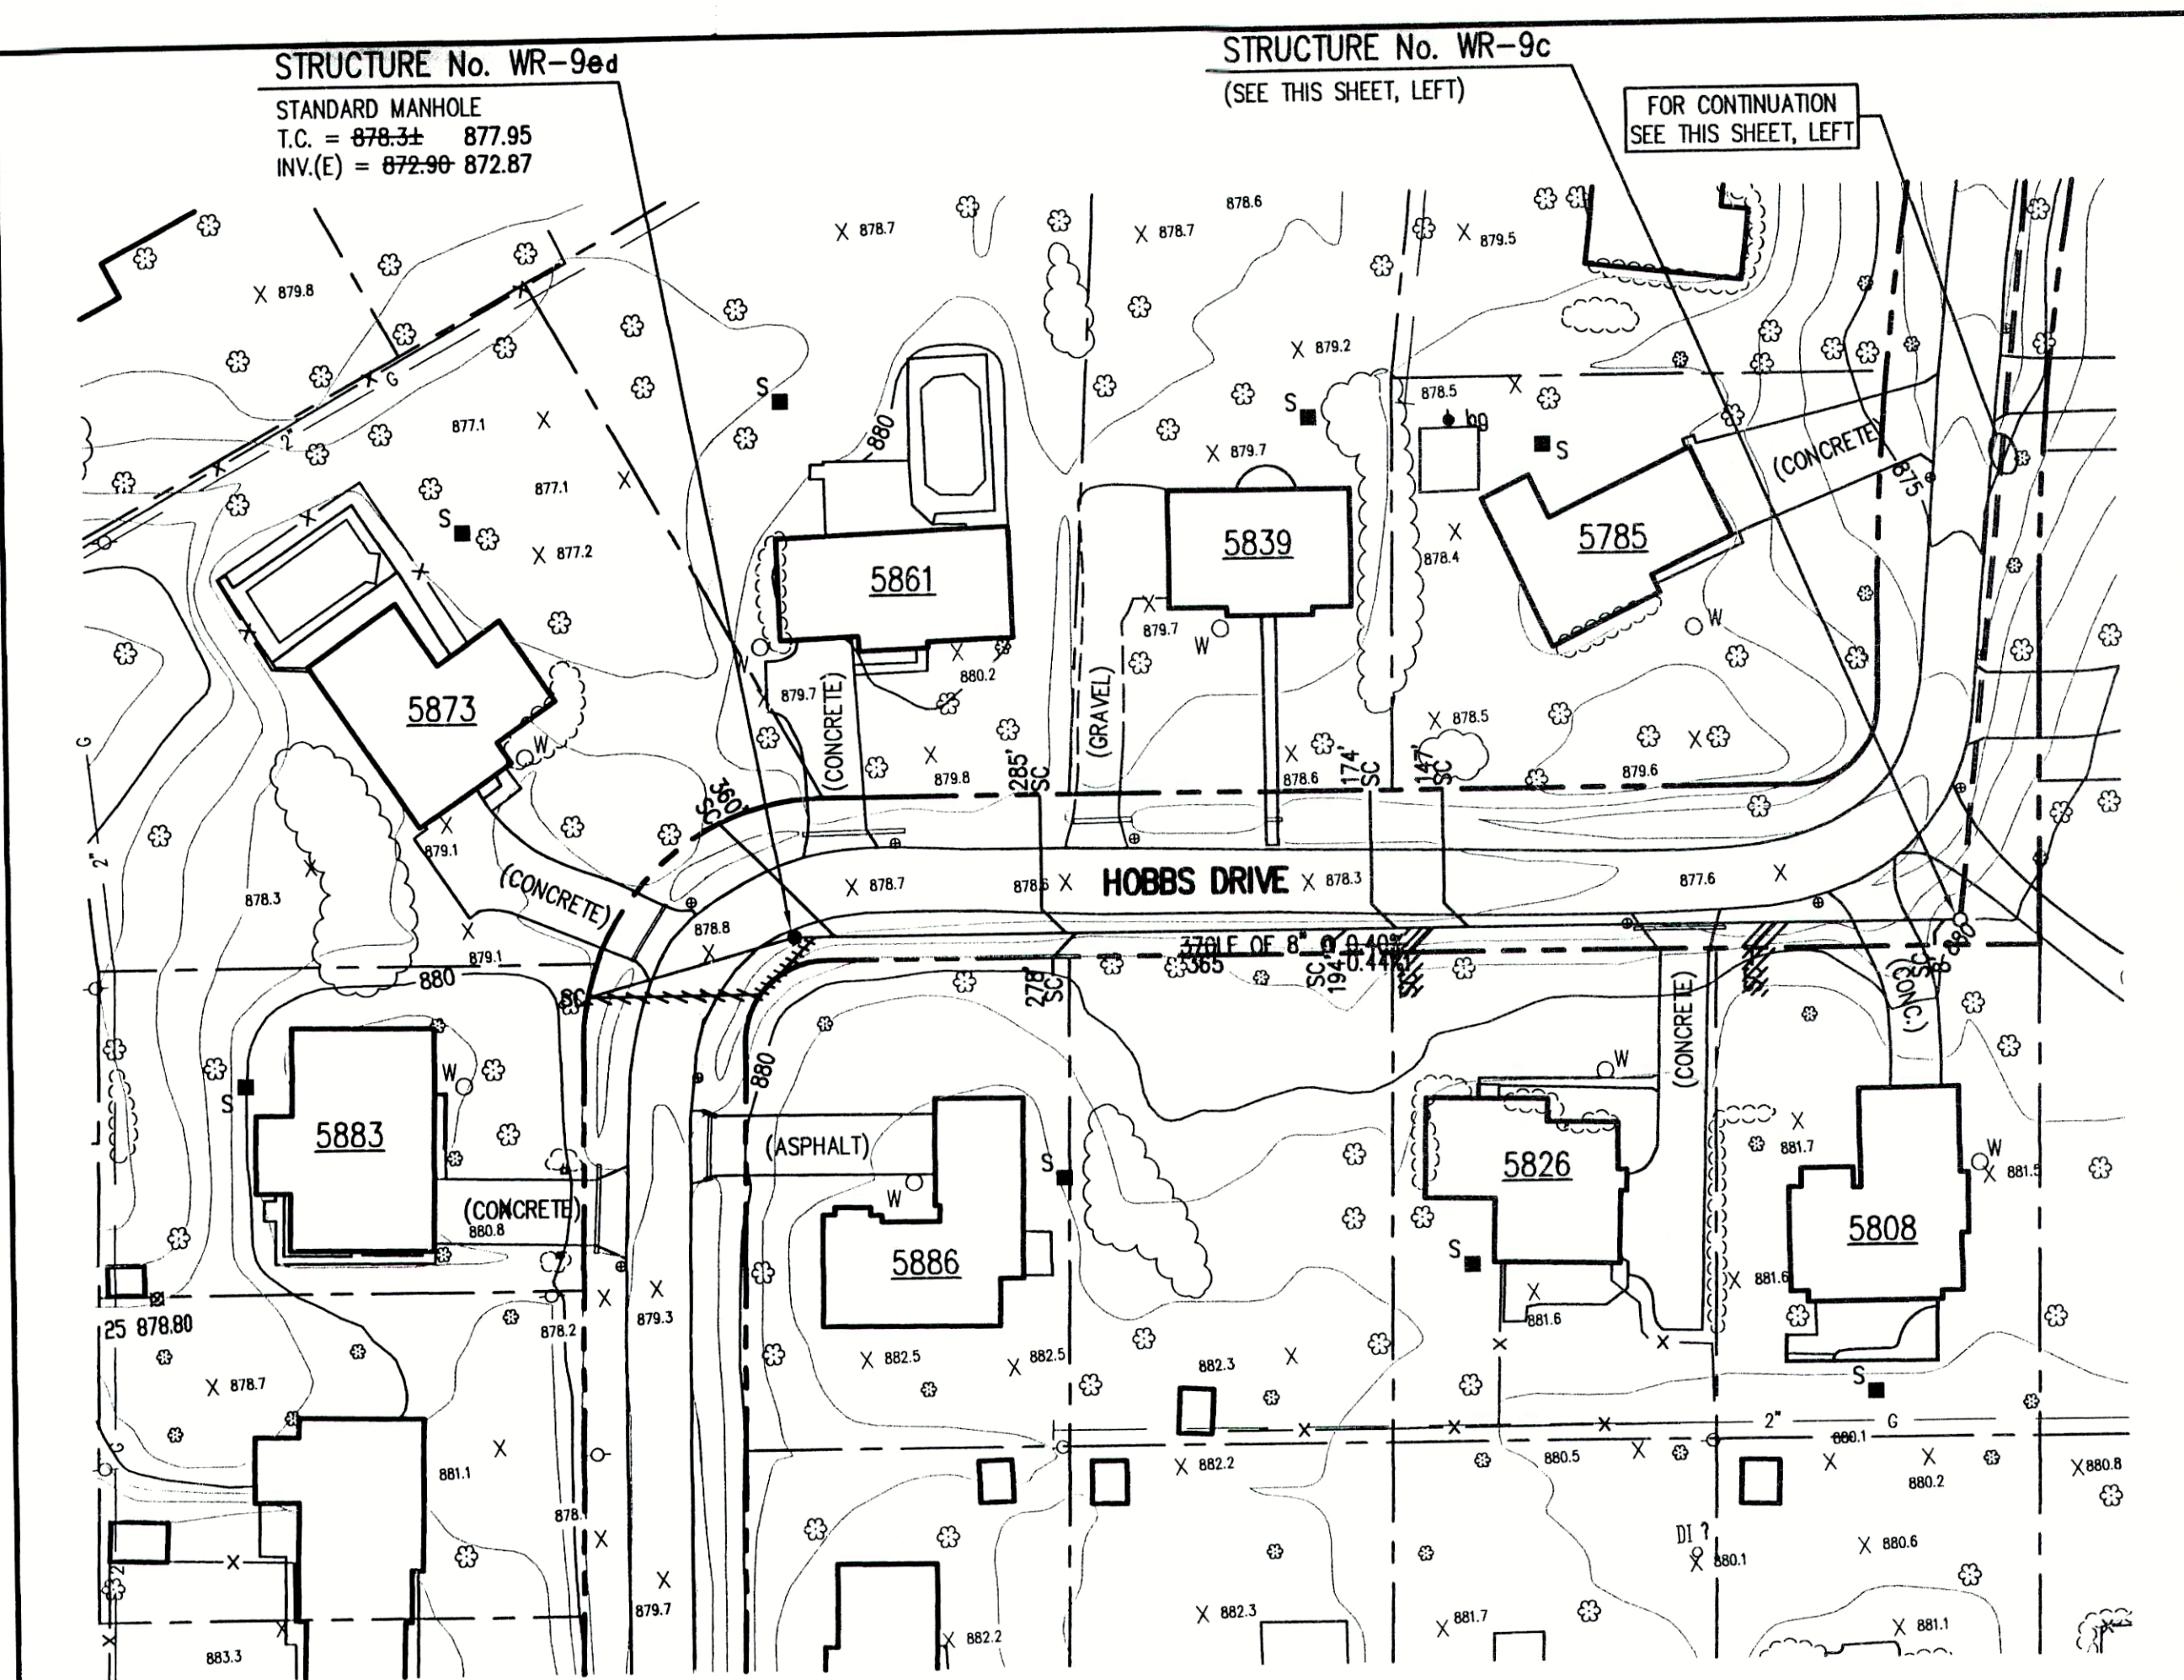


LEGEND:

- TREE
- POWER POLE
- GUY WIRE
- FIRE HYDRANT
- MAILBOX
- FLAGPOLE
- SPOT SHOT
- CONTOUR
- FENCE
- EXIST. SANITARY SEWER w/ MANHOLE
- NEW SANITARY SEWER w/ MANHOLE
- NEW SANITARY SERVICE CONNECTION
- WATER LINE
- GAS LINE
- UNDERGROUND ELECTRIC LINE
- UNDERGROUND TELEPHONE LINE
- APPROX. RIGHT-OF-WAY
- APPROX. CORPORATE LIMITS
- APPROX. PROPERTY LINE
- EXISTING WATER WELL
- EXISTING SEPTIC TANK




SCALE:
HORIZONTAL 1" = 50'
VERTICAL 1" = 5'

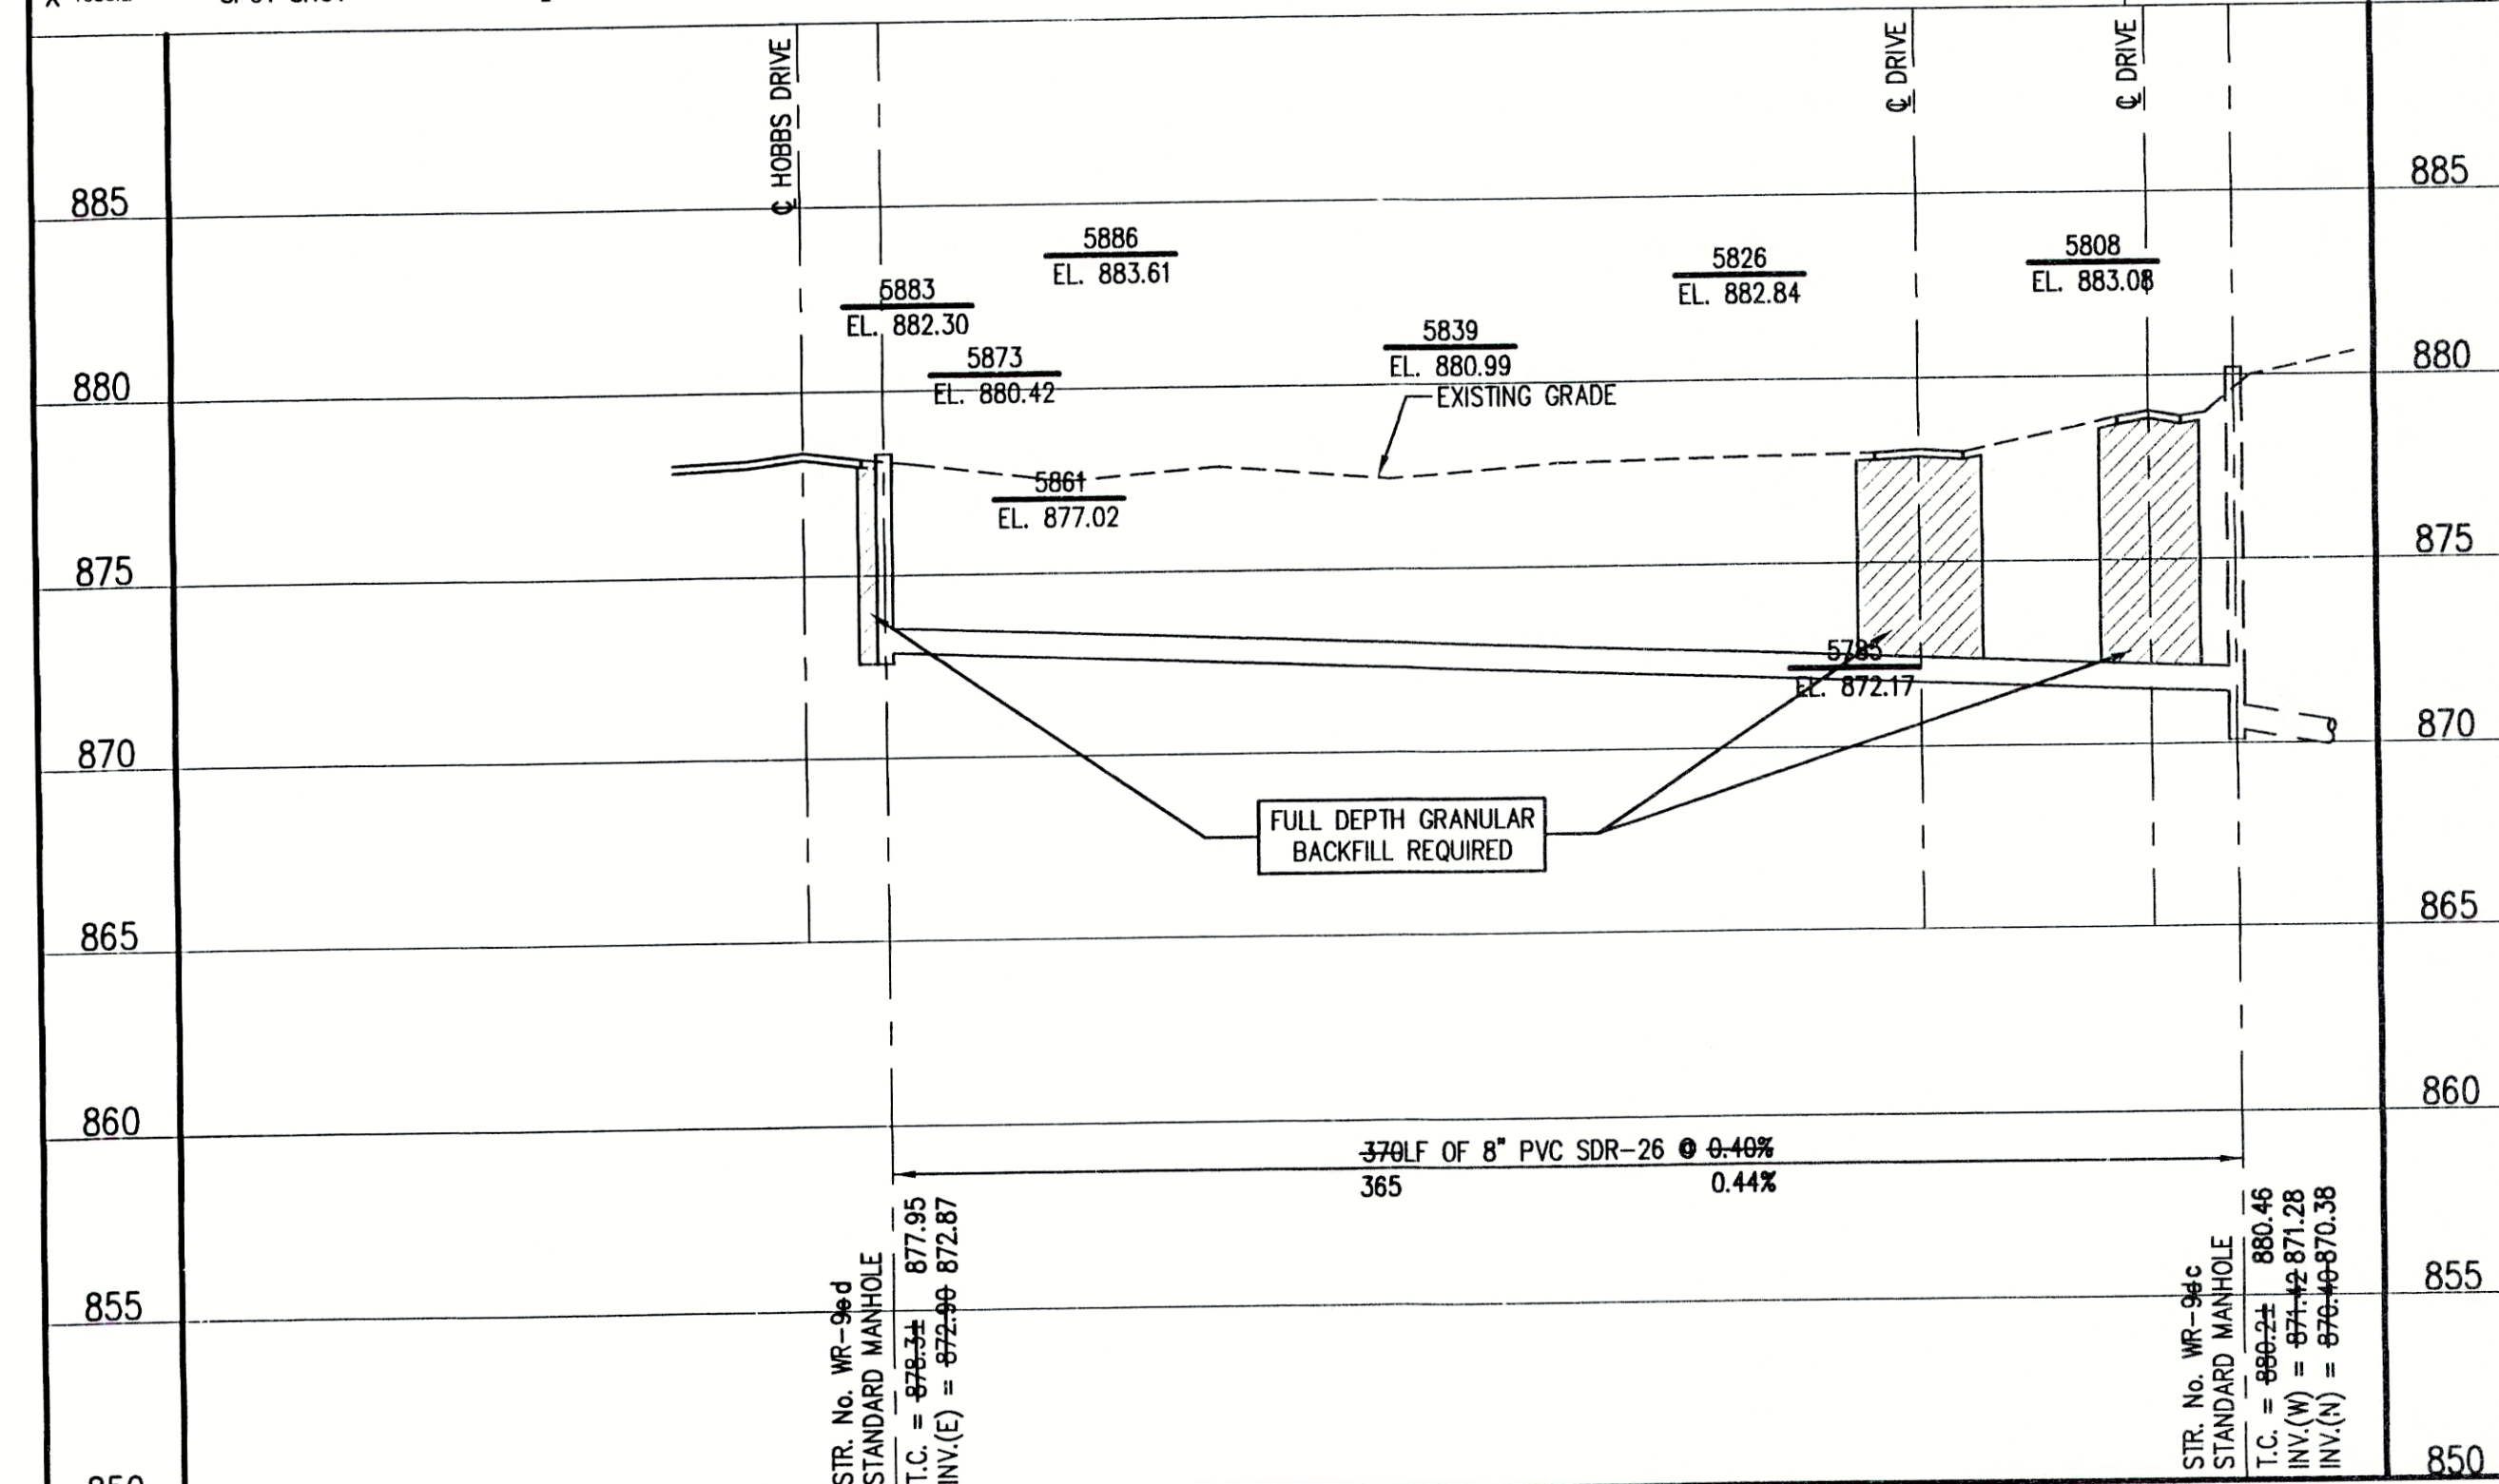

FILE NAME: WDRG_10 PLOT SCALE: 1"=50' PLOT DATE: 12/5




NO.	DATE	DESCRIPTION	BY

TRIAD ASSOCIATES INC.
INDIANAPOLIS, INDIANA

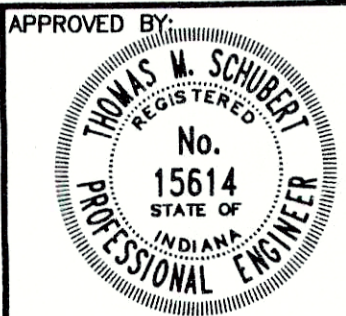




Thomas M. Schubert, P.E.

WOODED RIDGE SUBDIVISION
FALL CREEK REGIONAL WASTE DISTRICT
PLAN AND PROFILE
DRAWN BY: DATE 04/12/98 PROJECT No. 98008A SHEET No. 14
SCALE AS NOTED
DESIGNED BY: D.A. Pauling
CHECKED BY: James W. Frazell, P.E.

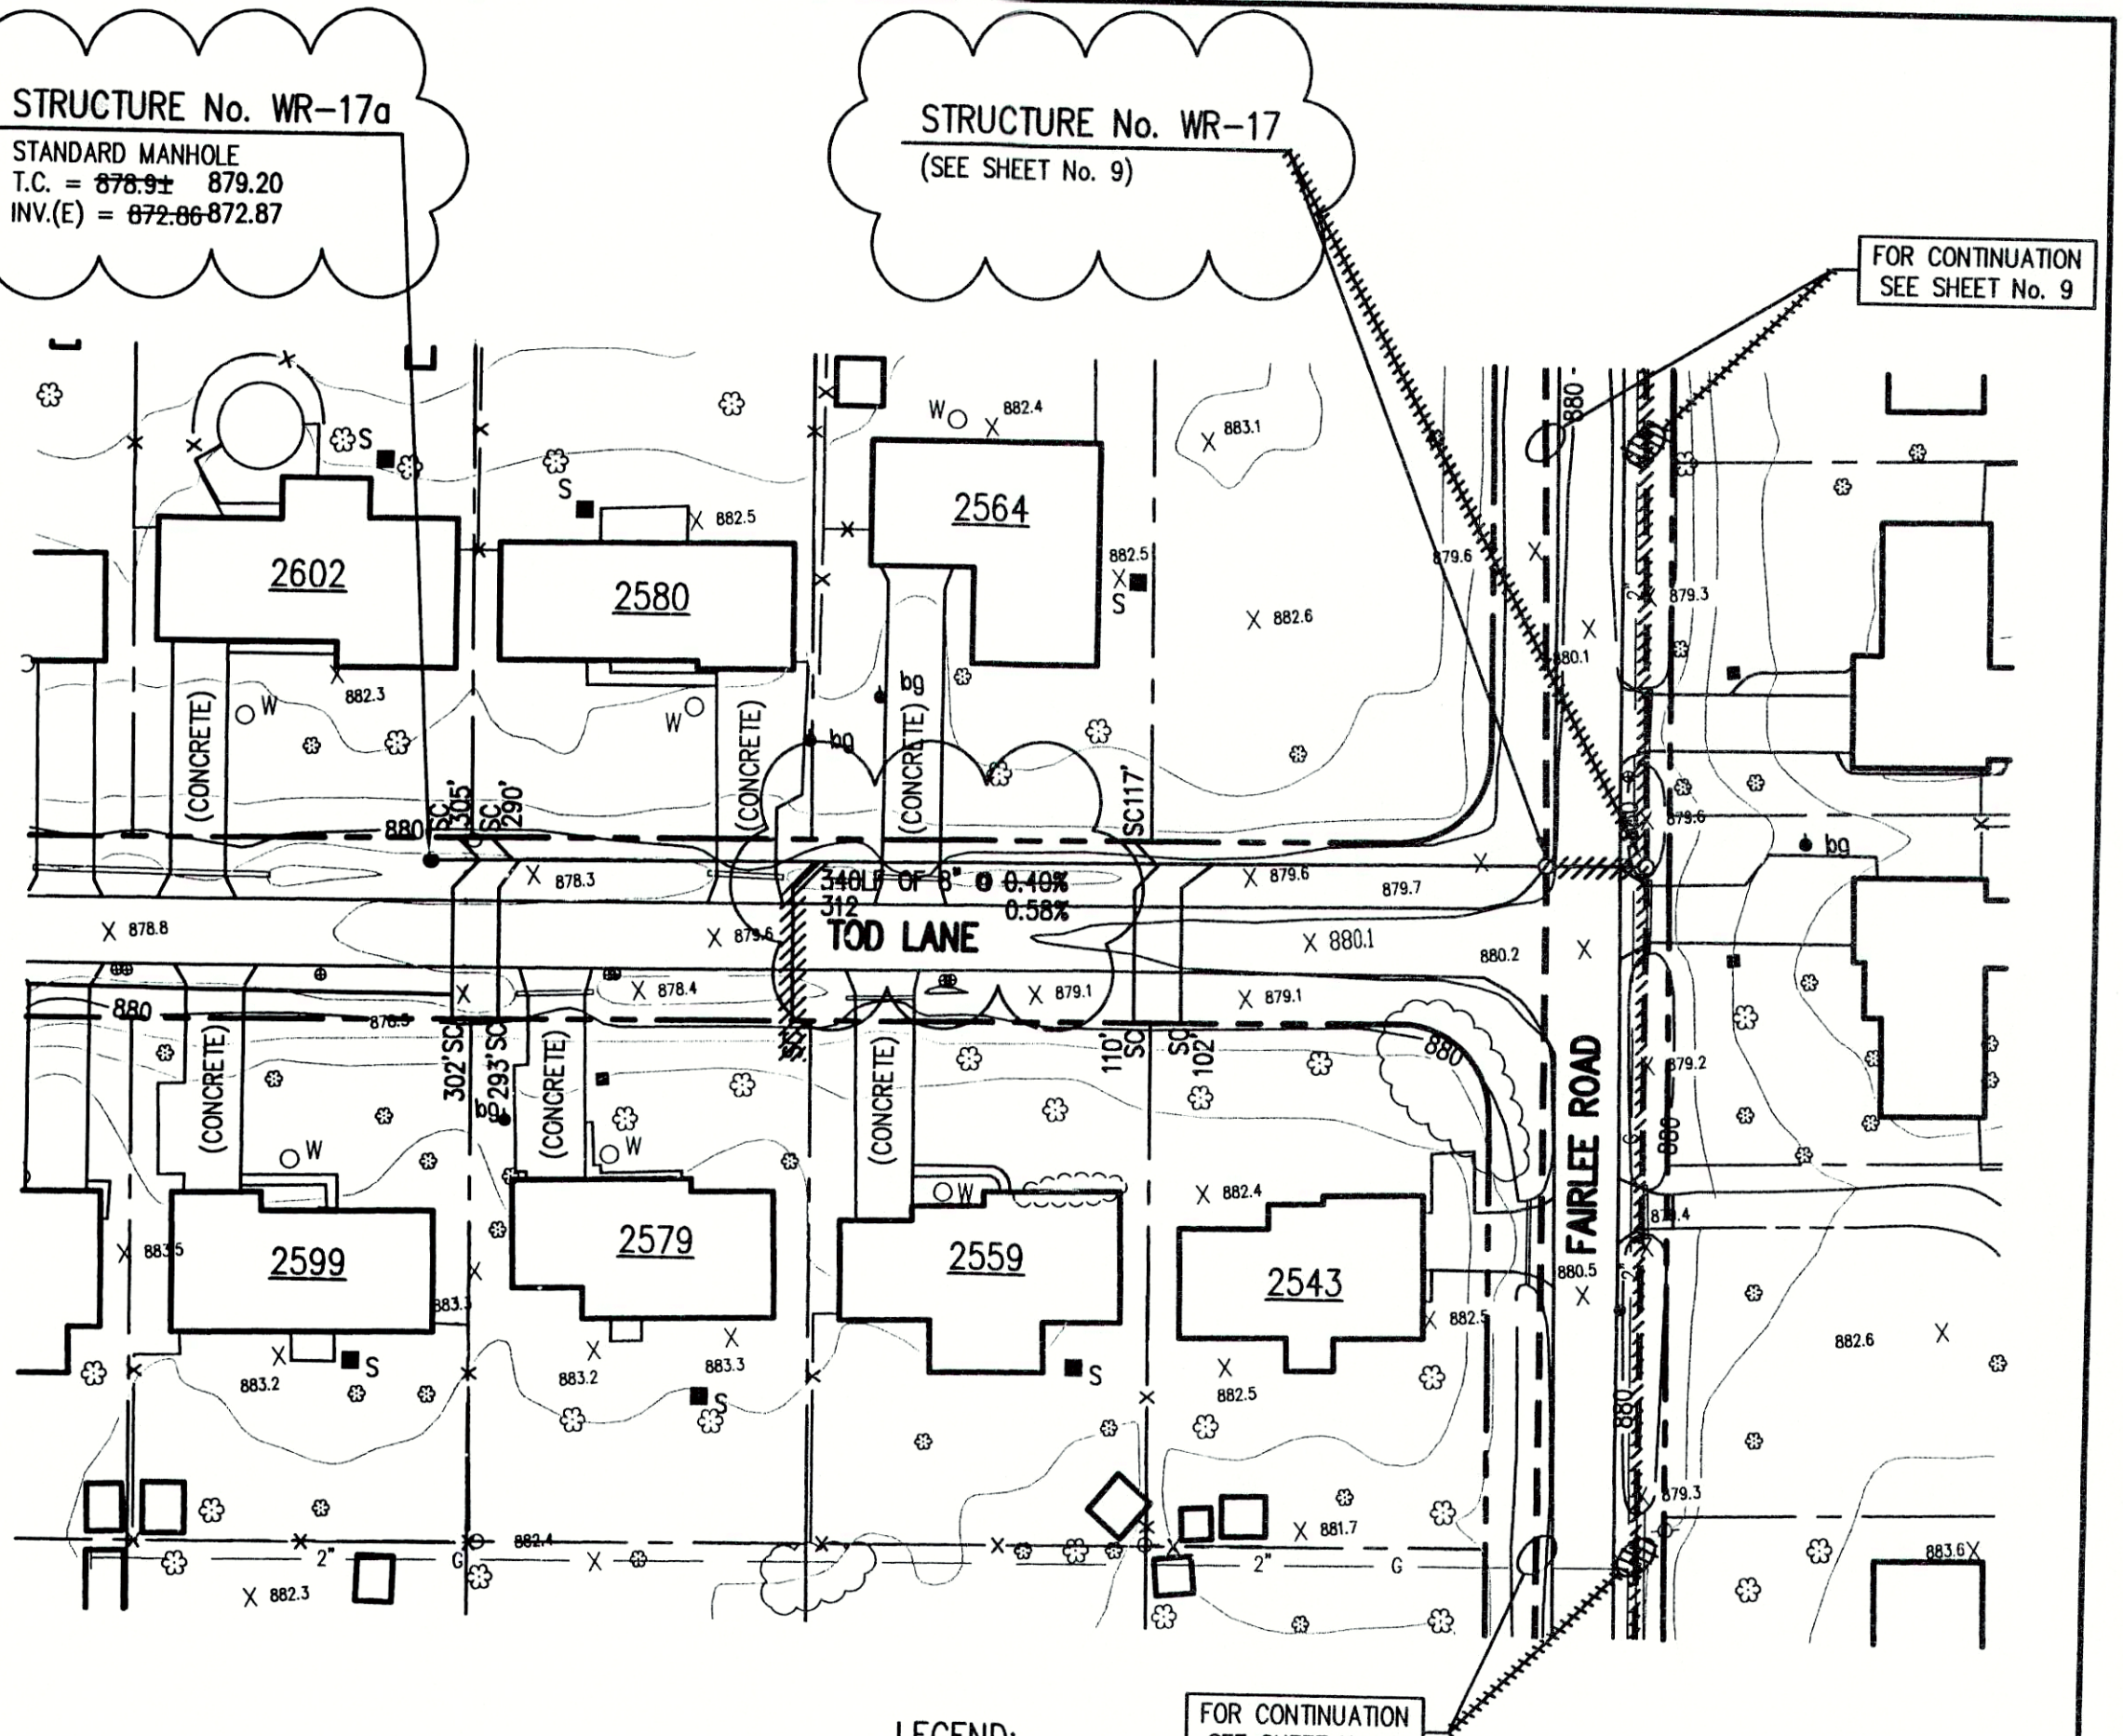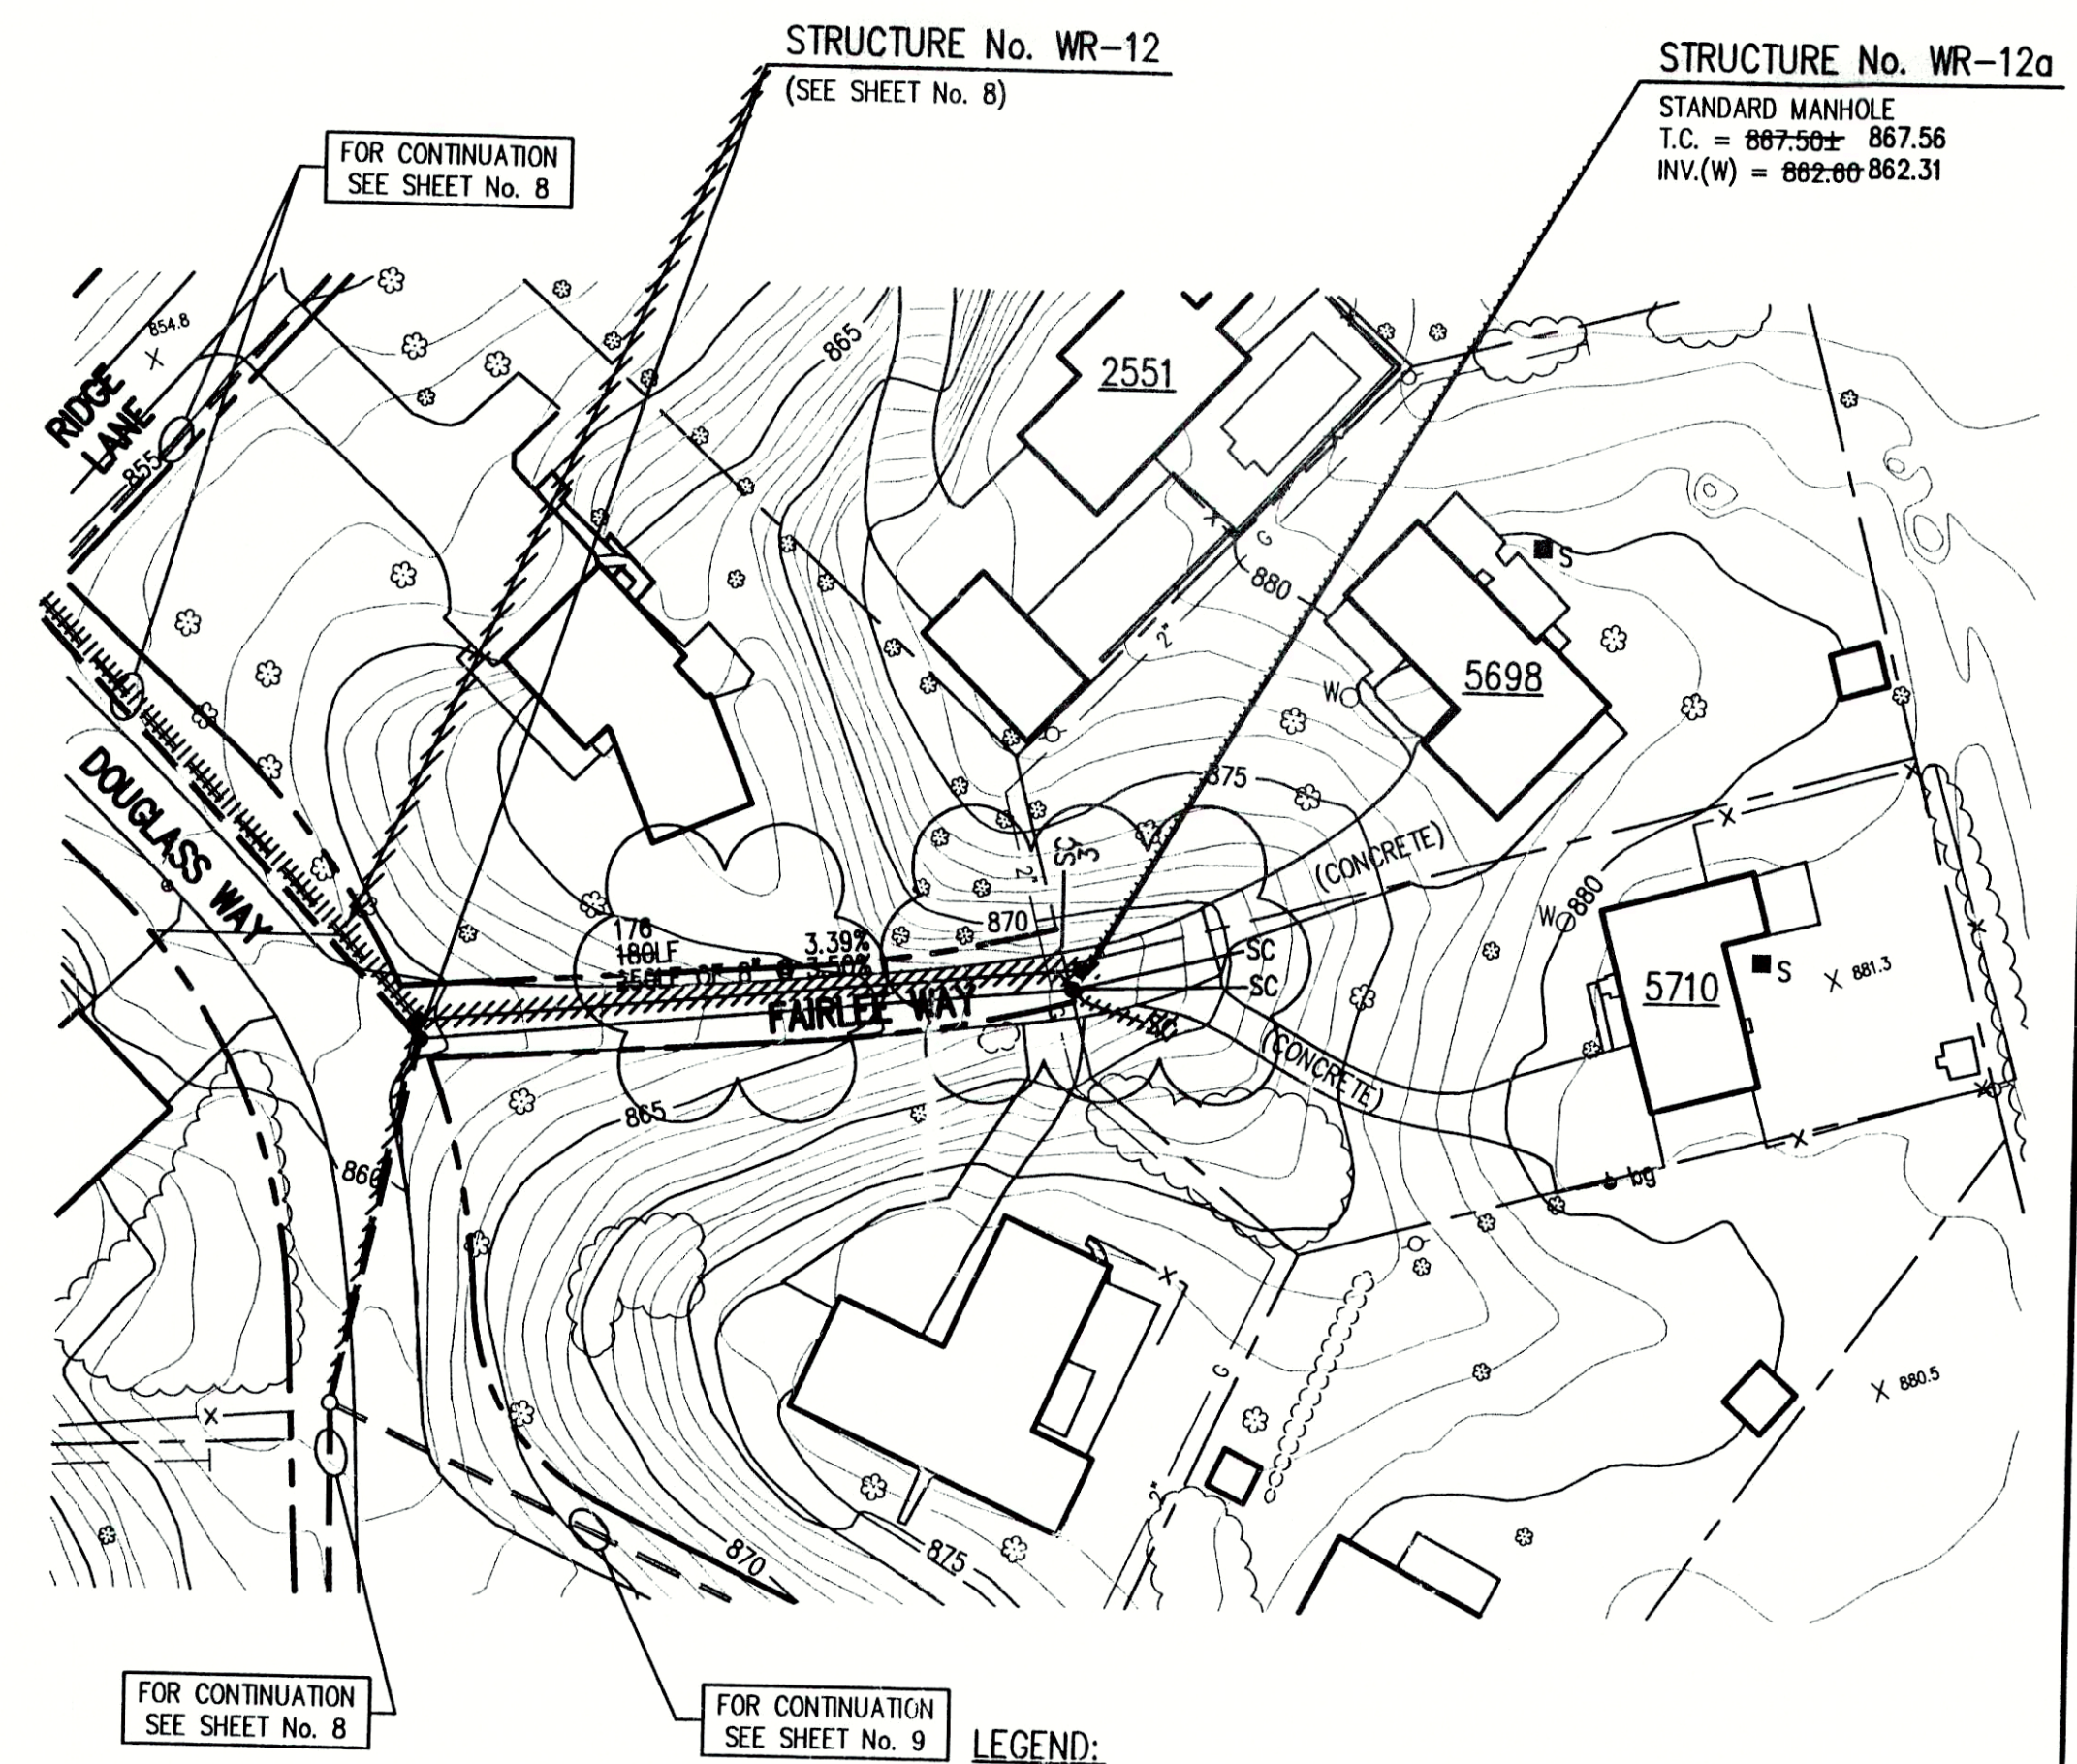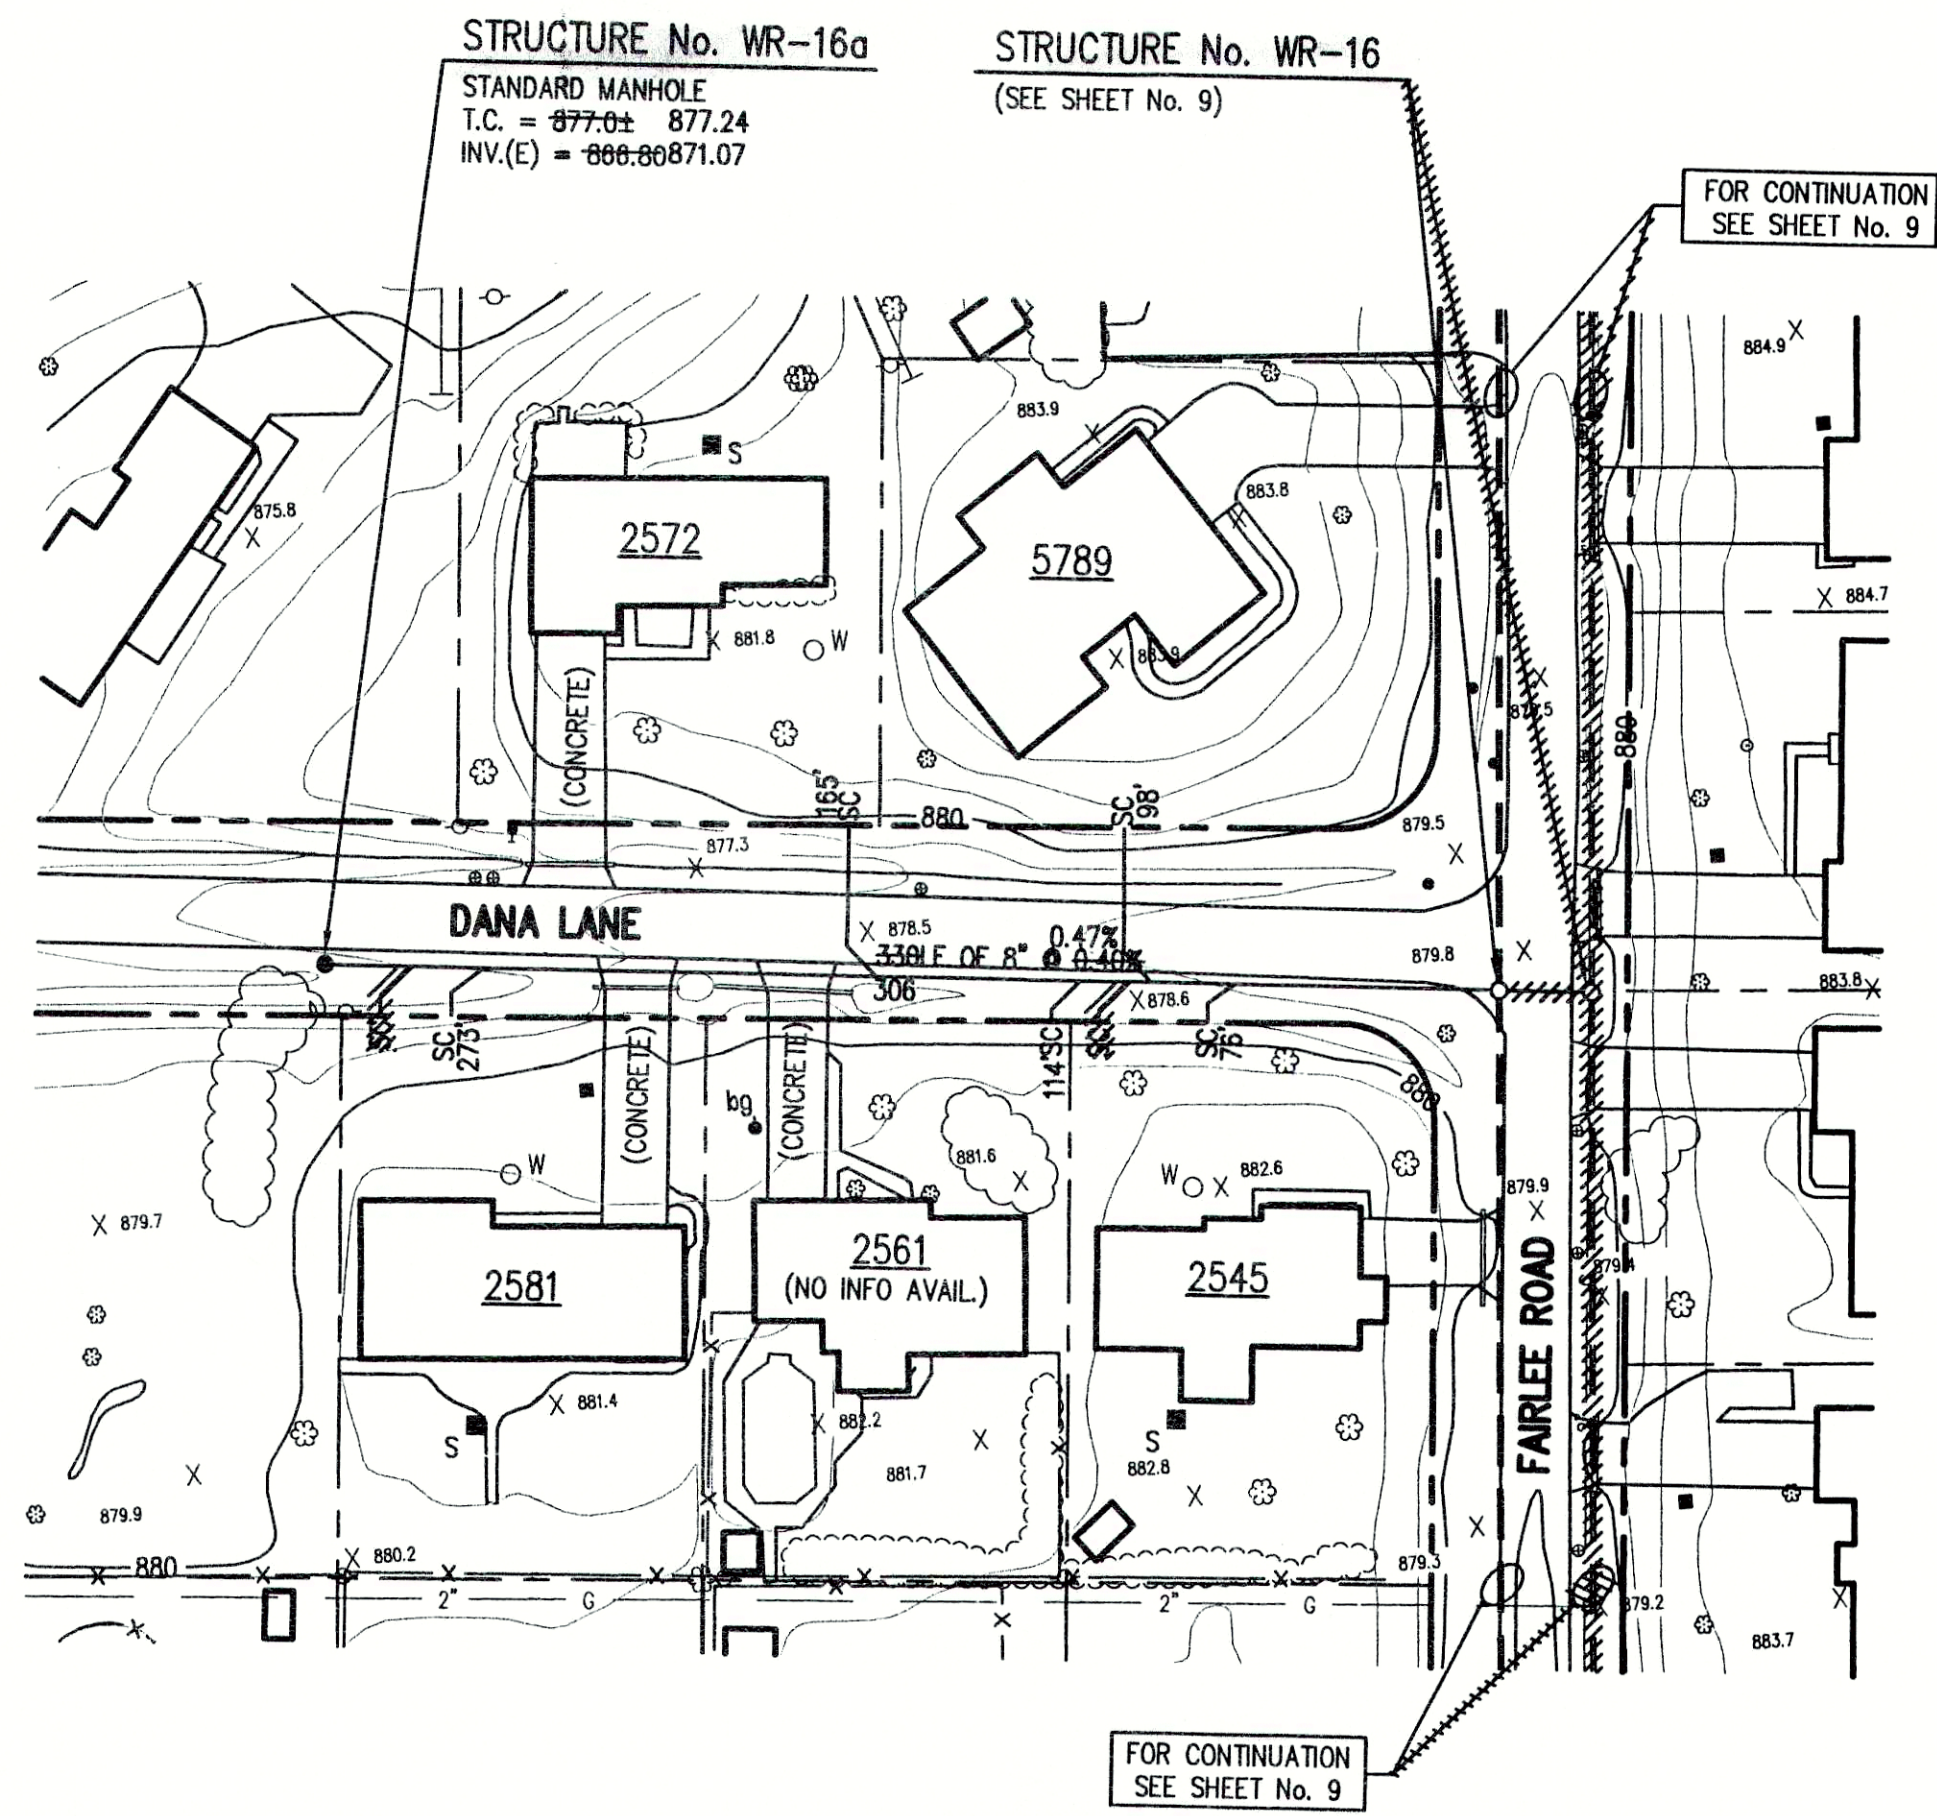

- GENERAL NOTES:**
- ALL UTILITY LOCATIONS ARE APPROXIMATE. THE CONTRACTOR SHALL HAVE ALL UTILITIES FIELD VERIFIED AND MARKED PRIOR TO CONSTRUCTION.
 - CONTRACTOR SHALL MAINTAIN A MINIMUM 10'-0" HORIZONTAL AND 18" VERTICAL SEPARATION BETWEEN SEWER AND WATER MAINS.
 - ALL PROPOSED TOP OF CASTING ELEVATIONS ARE APPROXIMATE. THE CONTRACTOR SHALL ADJUST FINAL ELEVATIONS AS REQUIRED TO BE FLUSH WITH PAVEMENT.
 - ALL SEWER TRENCHES SHALL BE BACKFILLED WITH FULL DEPTH COMPACTED GRANULAR BACKFILL ("B" BORROW) UNDER OR WITHIN 5' OF EDGE OF PAVEMENT.
 - THE CONTRACTOR SHALL VISIT THE SITE PRIOR TO BID TO BECOME FAMILIAR WITH ALL SITE CONDITIONS.
 - THE CONTRACTOR SHALL PROVIDE THE REQUIRED MEANS FOR MAINTAINING SAFE TRAFFIC AT ALL TIMES.
 - CONTRACTOR SHALL RESTORE ALL DISTURBED LAWN AREAS, STREETS, WALKS, DRIVES, ETC. AS SHOWN ON DRAWINGS, IN THE SPECIFICATIONS, OR TO AT LEAST PRE-EXISTING CONDITIONS.
 - ALL UTILITY CROSSINGS SHALL BE PROTECTED AND SUPPORTED WITH GRANULAR FILL OR CONCRETE AS REQUIRED PER THE DETAIL SHEET.

- LEGEND:**
- TREE
 - POWER POLE
 - GUY WIRE
 - FIRE HYDRANT
 - MAILBOX
 - FLAGPOLE
 - SPOT SHOT
 - CONTOUR
 - FENCE
 - EXIST. SANITARY SEWER w/ MANHOLE
 - NEW SANITARY SEWER w/ MANHOLE
 - NEW SANITARY SERVICE CONNECTION
 - WATER LINE
 - GAS LINE
 - UNDERGROUND ELECTRIC LINE
 - UNDERGROUND TELEPHONE LINE
 - APPROX. RIGHT-OF-WAY
 - APPROX. CORPORATE LIMITS
 - APPROX. PROPERTY LINE
 - EXISTING WATER WELL
 - EXISTING SEPTIC TANK

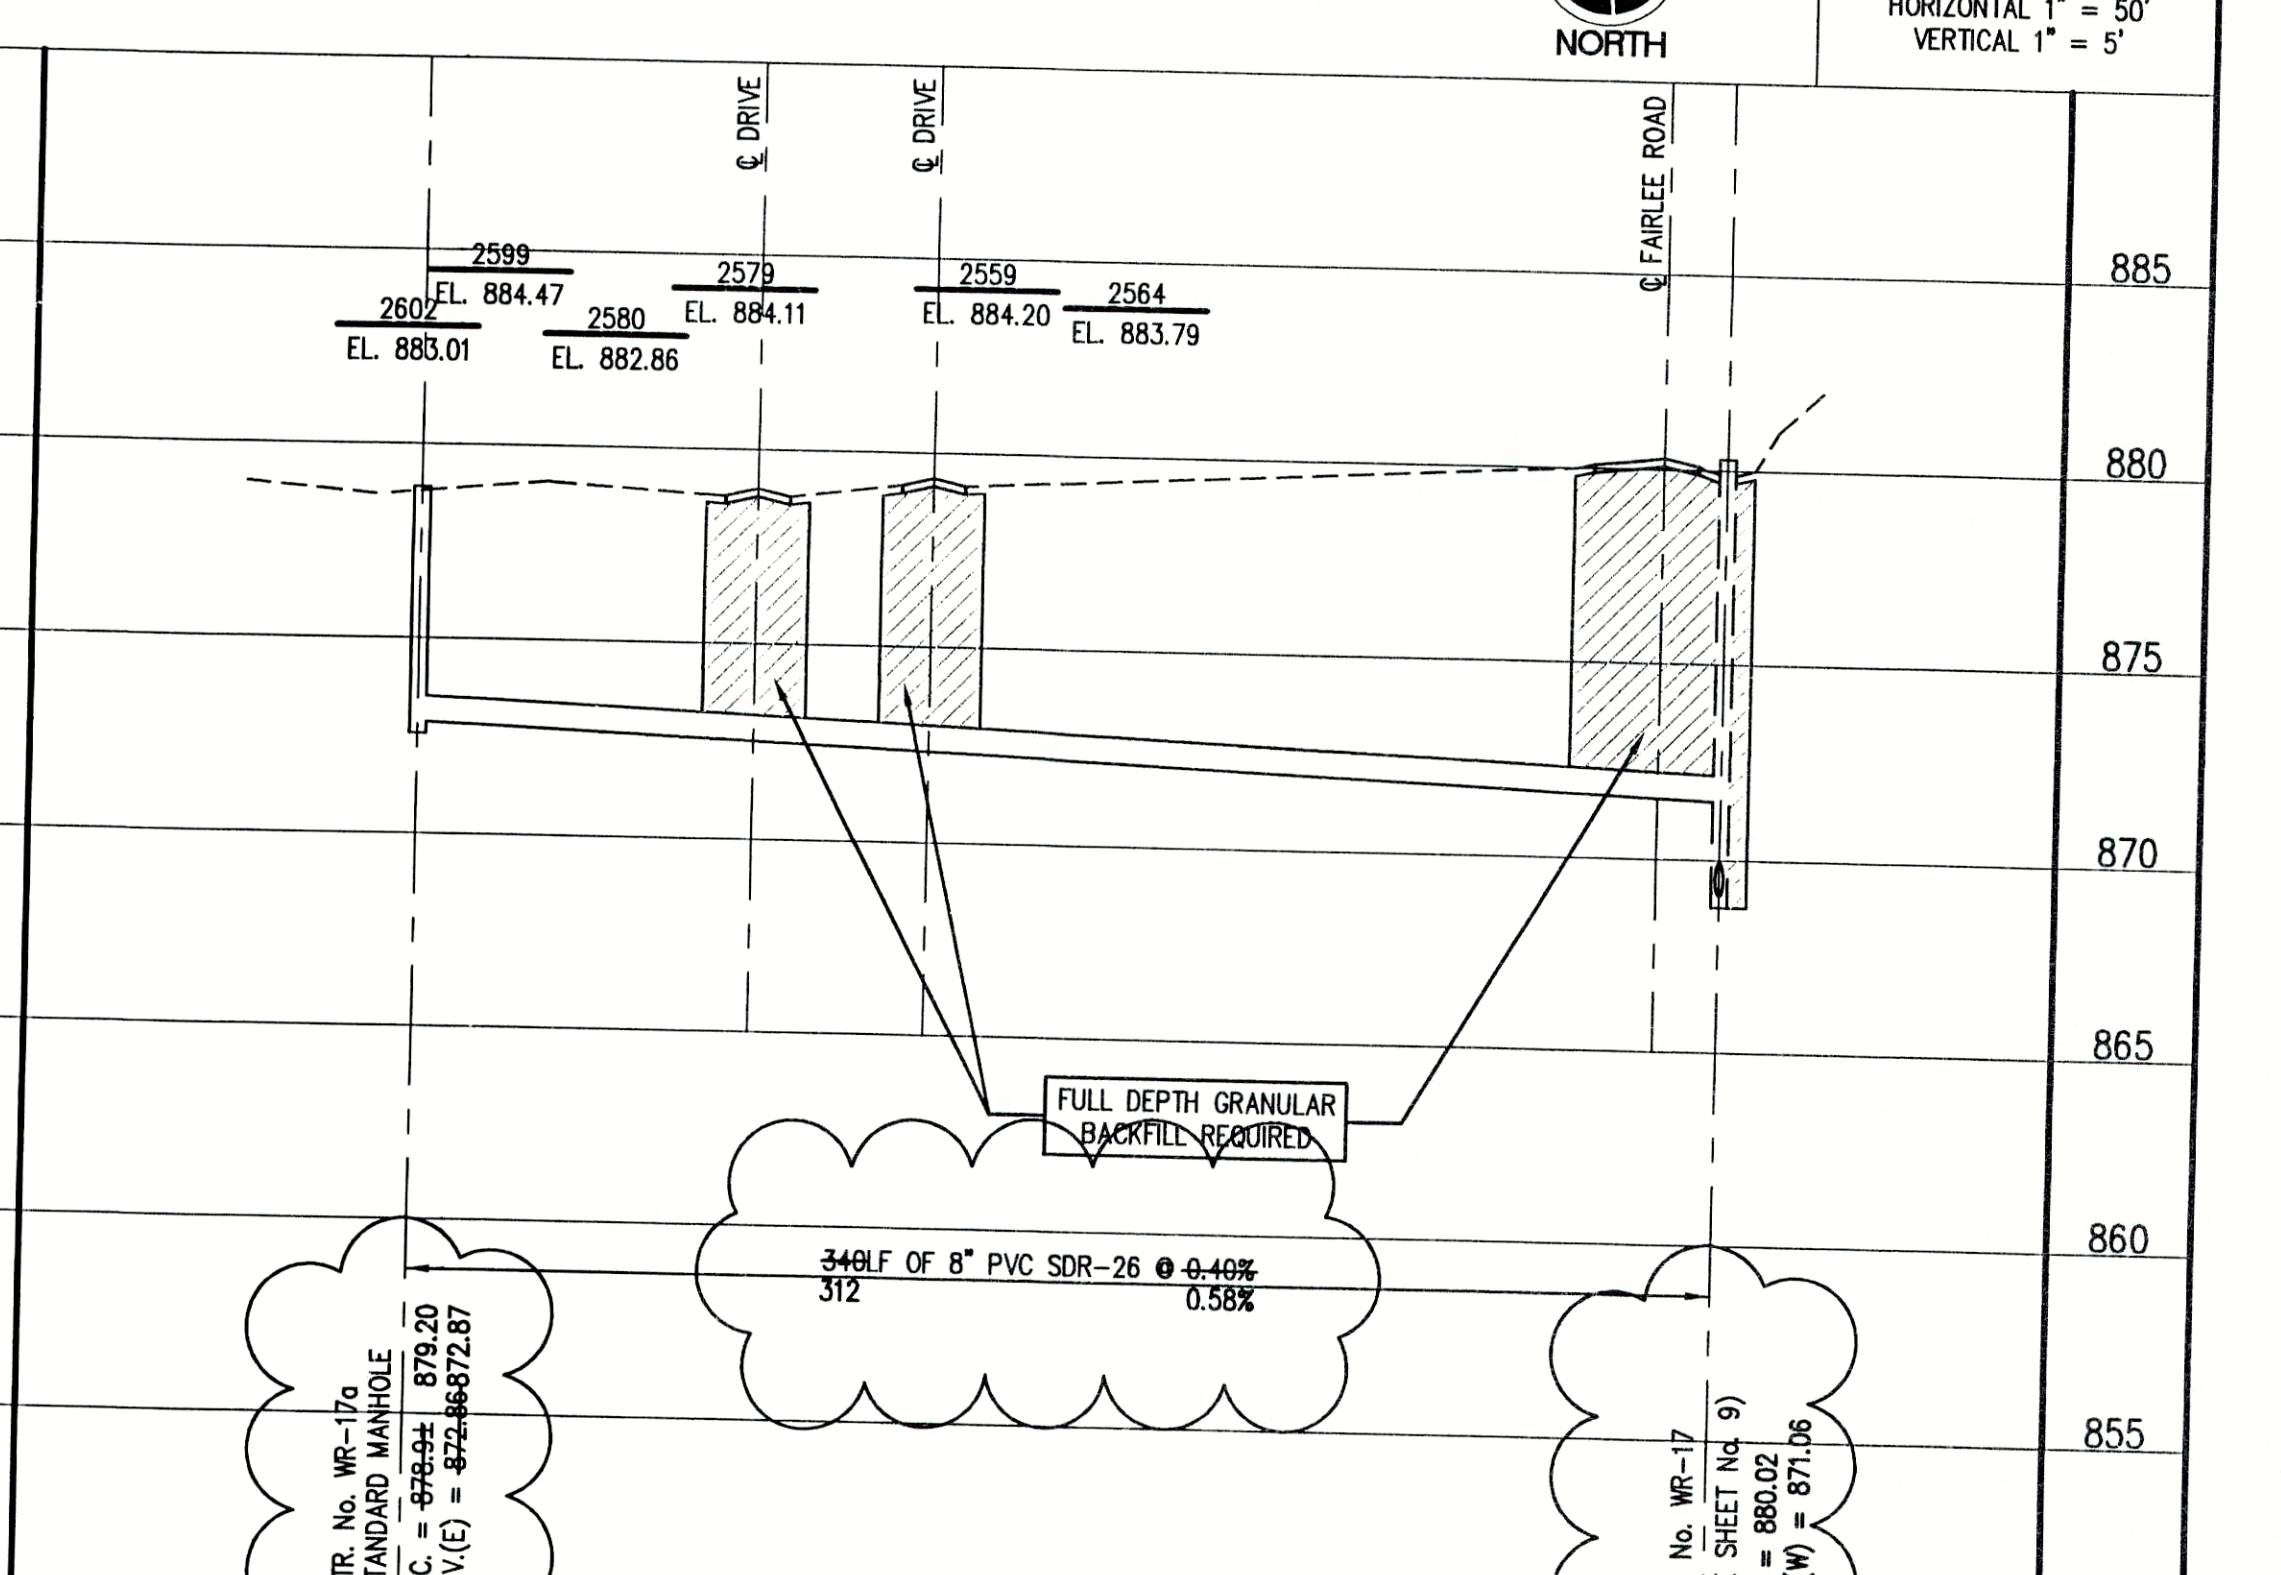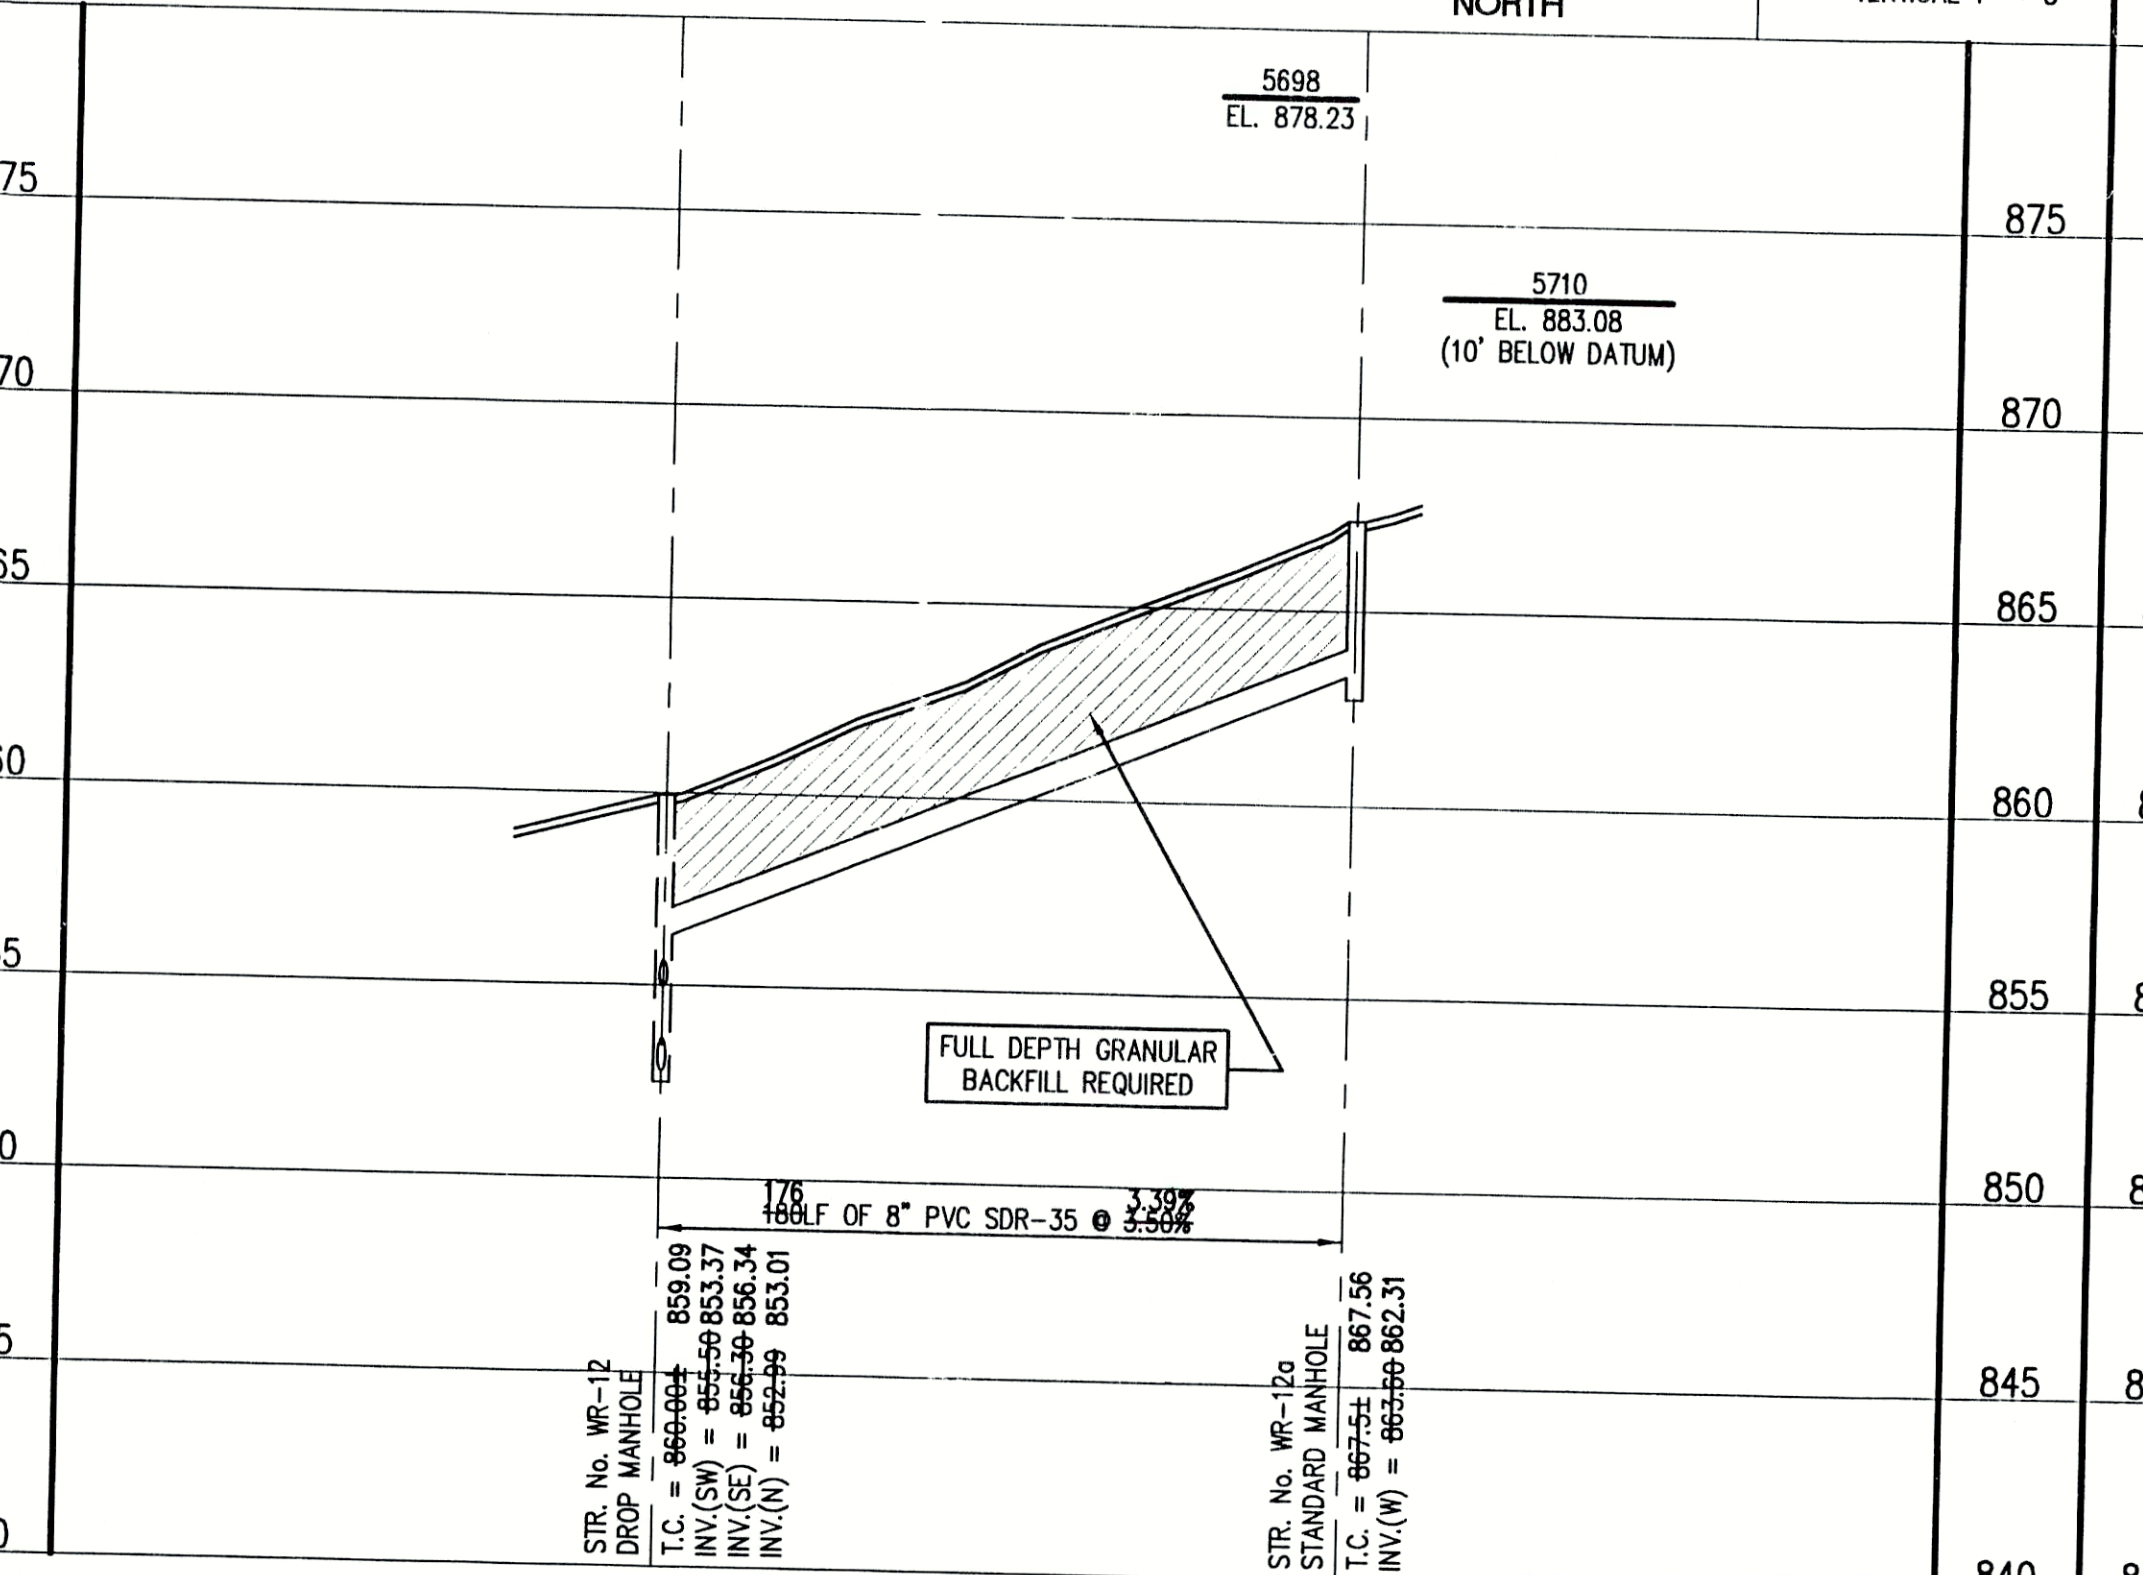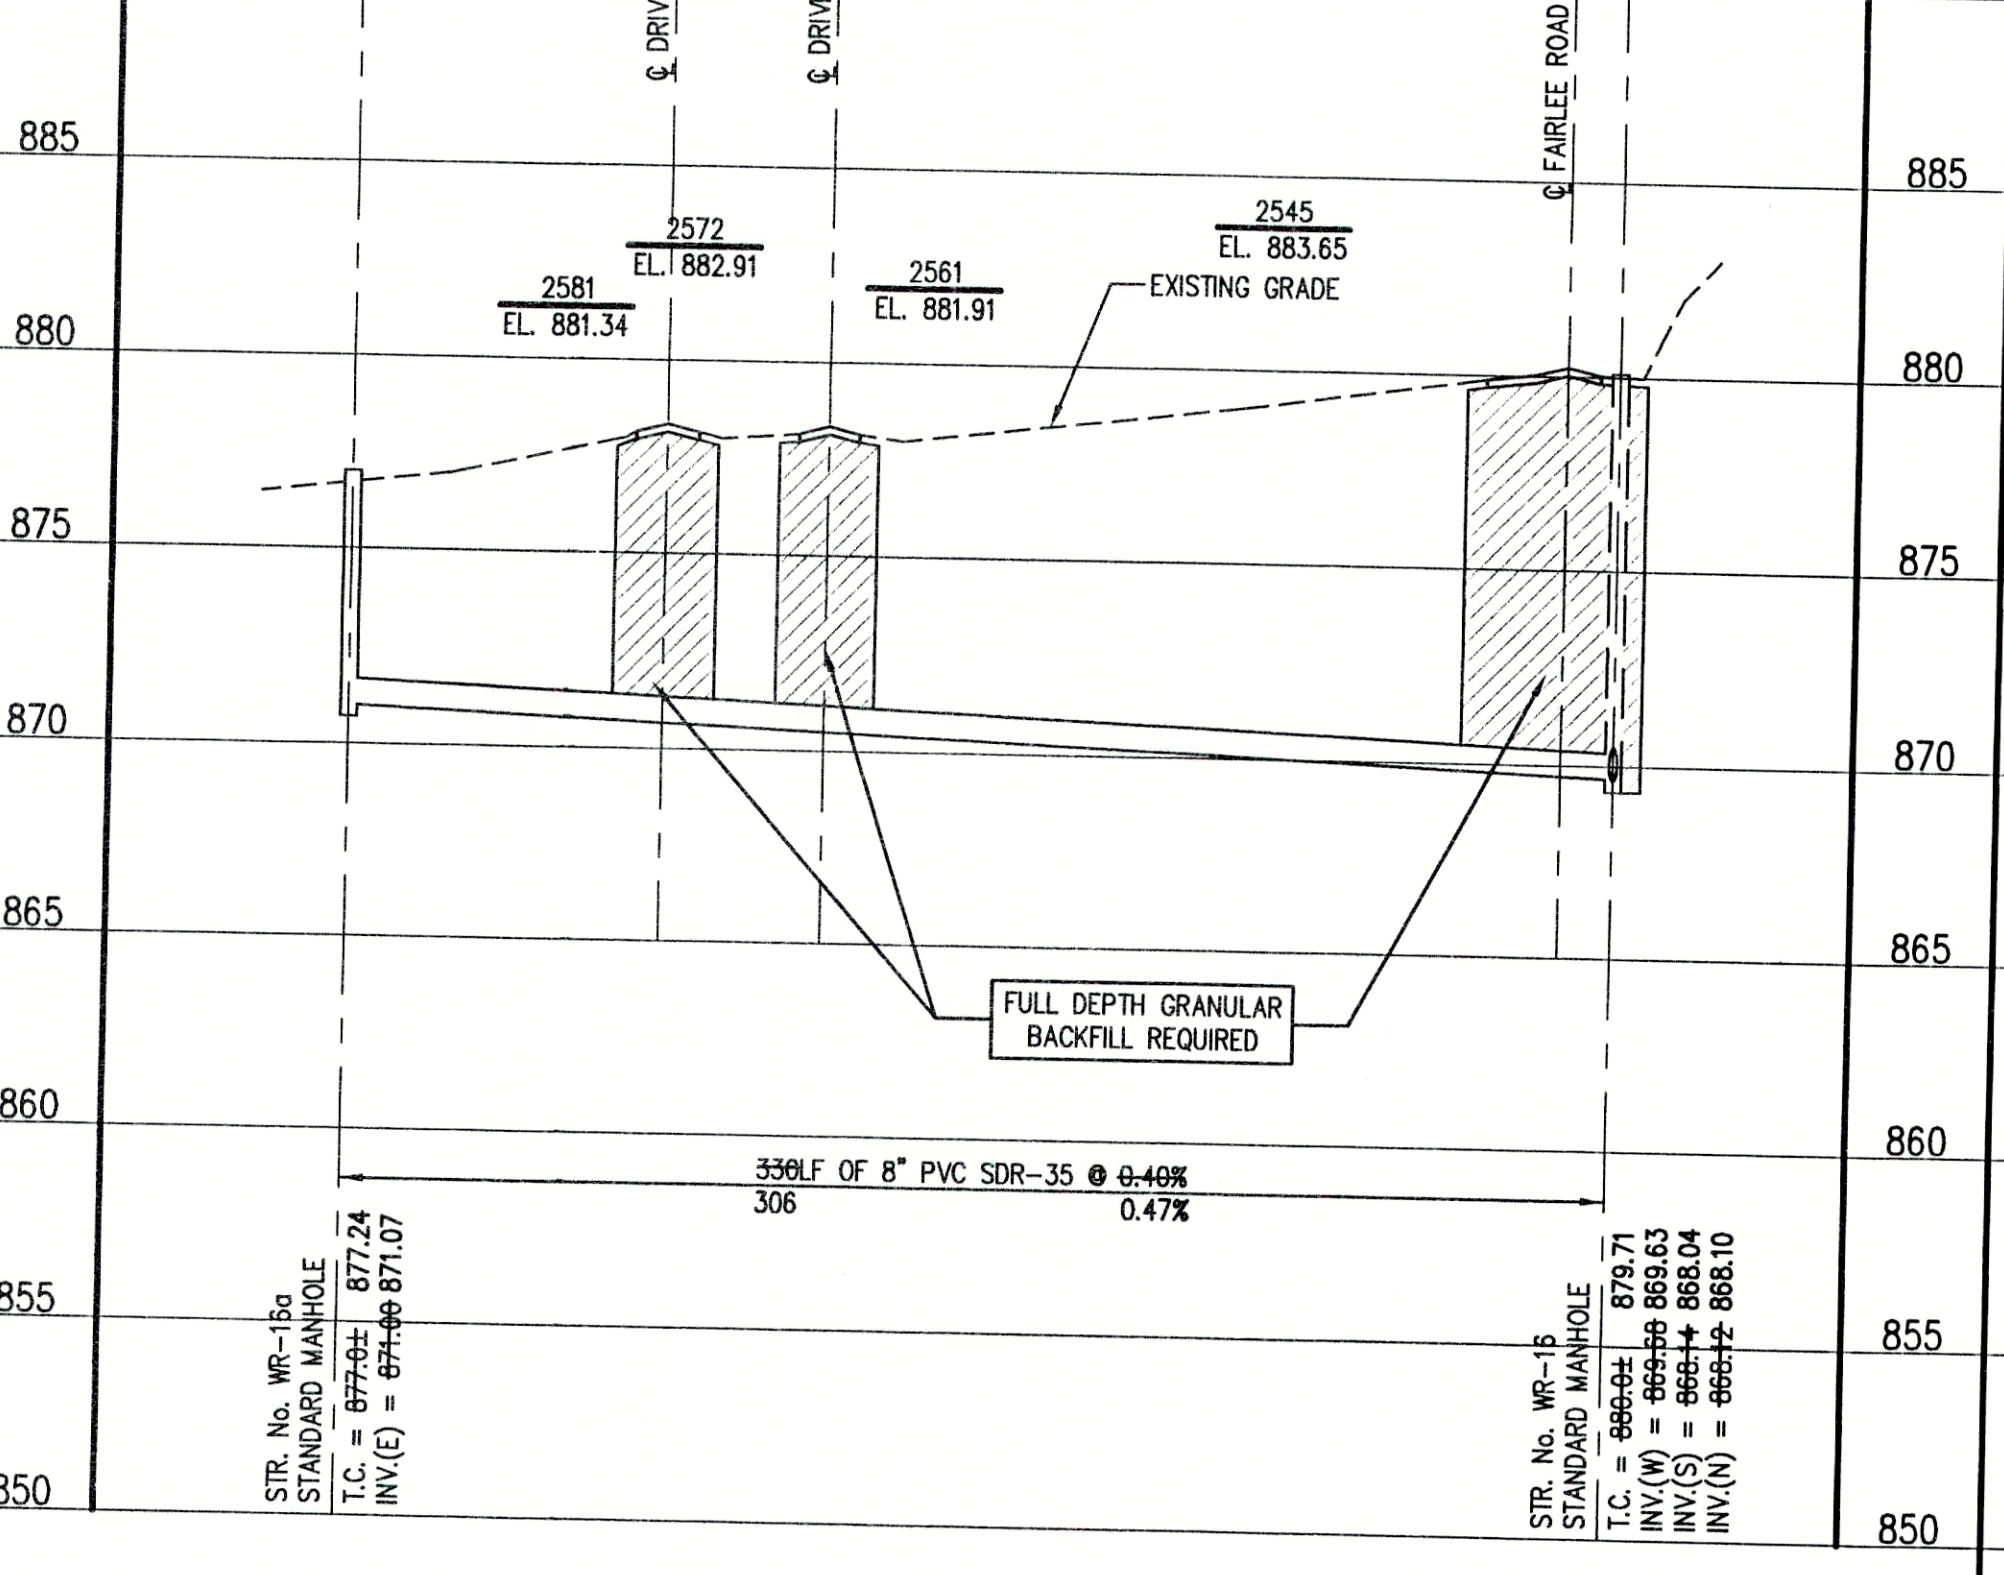

RECORD DRAWING
February 15, 2001



NOTE:
THE CONTRACTOR SHALL INCLUDE IN THE COSTS FOR SANITARY PIPE, ALL WATER SERVICE RECONNECTIONS, STORM SEWER RECONNECTION, WATER MAIN RELOCATIONS, CONCRETE RECONSTRUCTION, AND SIDEWALK RECONSTRUCTION AS REQUIRED TO INSTALL NEW WORK AS SHOWN ON THE DRAWINGS.

FILE NAME: REVSHIT_7-RD		PLOT SCALE: 1=50	PLOT DATE: 12/5
NO.	DATE	DESCRIPTION	BY

TRIAD ASSOCIATES INC.
INDIANAPOLIS, INDIANA

APPROVED BY:
THOMAS M. SCHUBERT
No. 15614
STATE OF INDIANA
REGISTERED PROFESSIONAL ENGINEER
Thomas M. Schubert, P.E.




WOODBROOK SUBDIVISION
FALL CREEK REGIONAL WASTE DISTRICT
PLAN AND PROFILE
DRAWN BY: DAP
DATE: 04/12/98
SCALE: AS NOTED
PROJECT No. 98008A
SHEET No. 15
DESIGNED BY: D.A. Pauling
CHECKED BY: James W. Frazell, P.E.

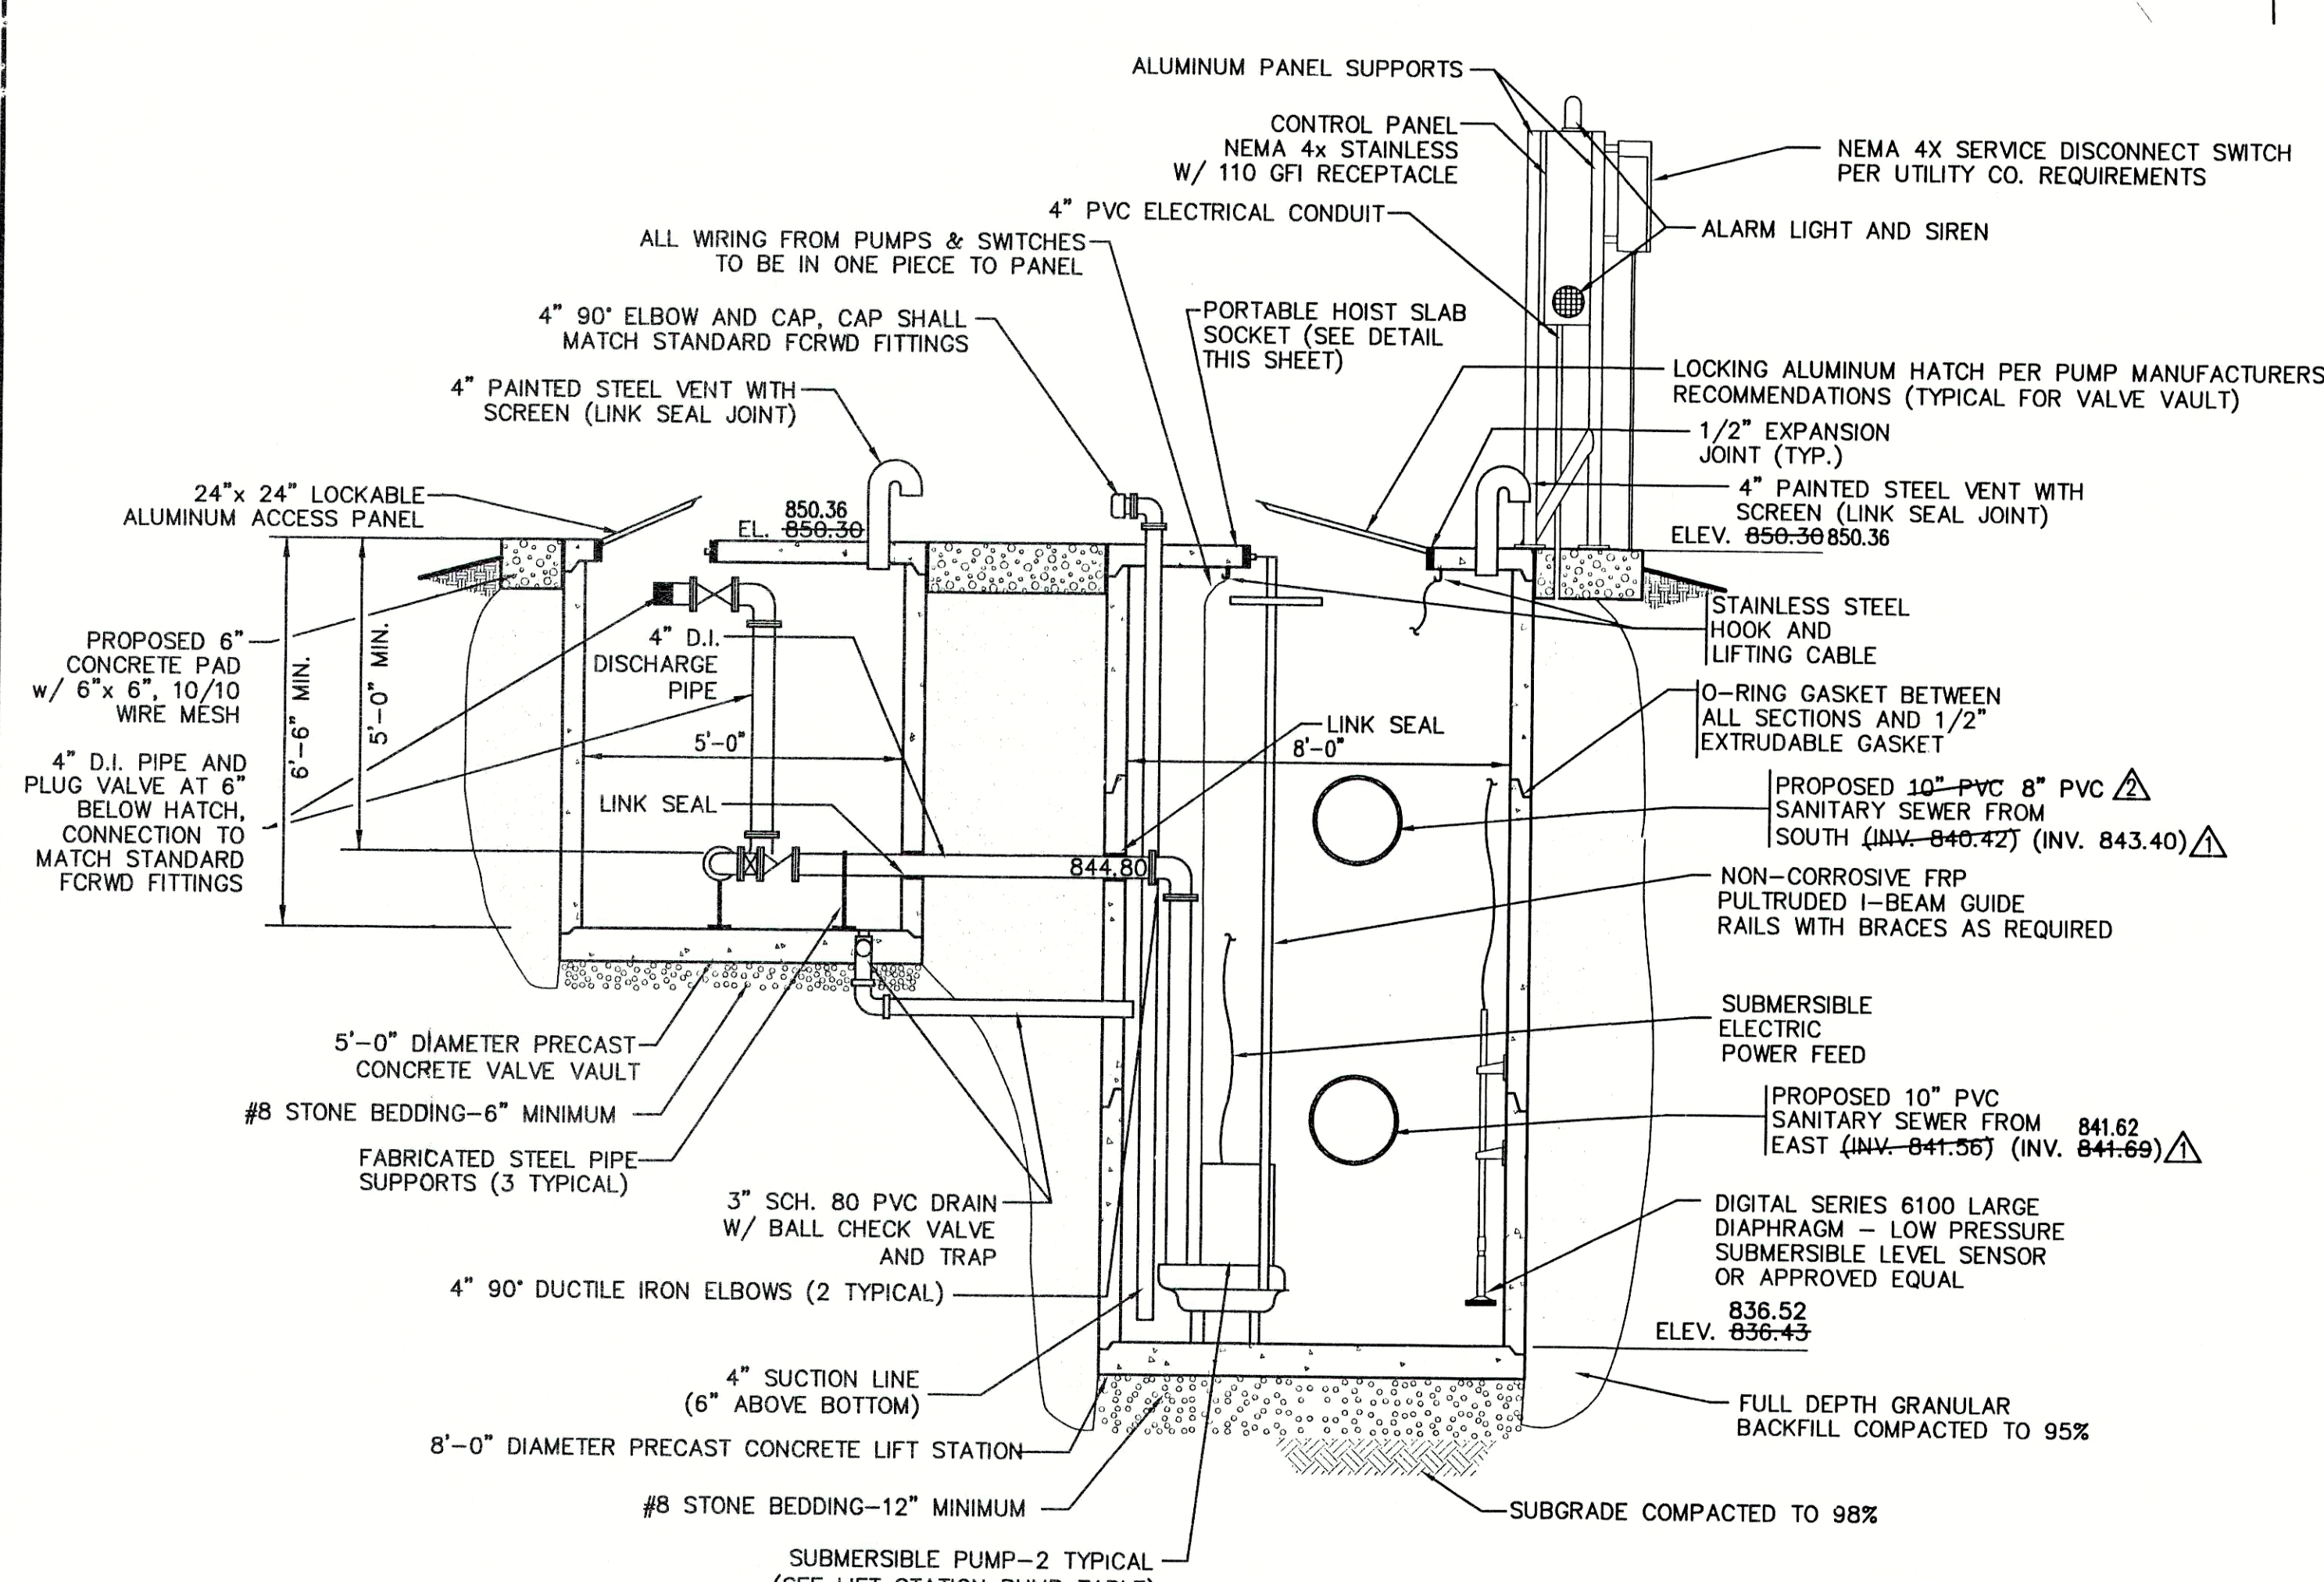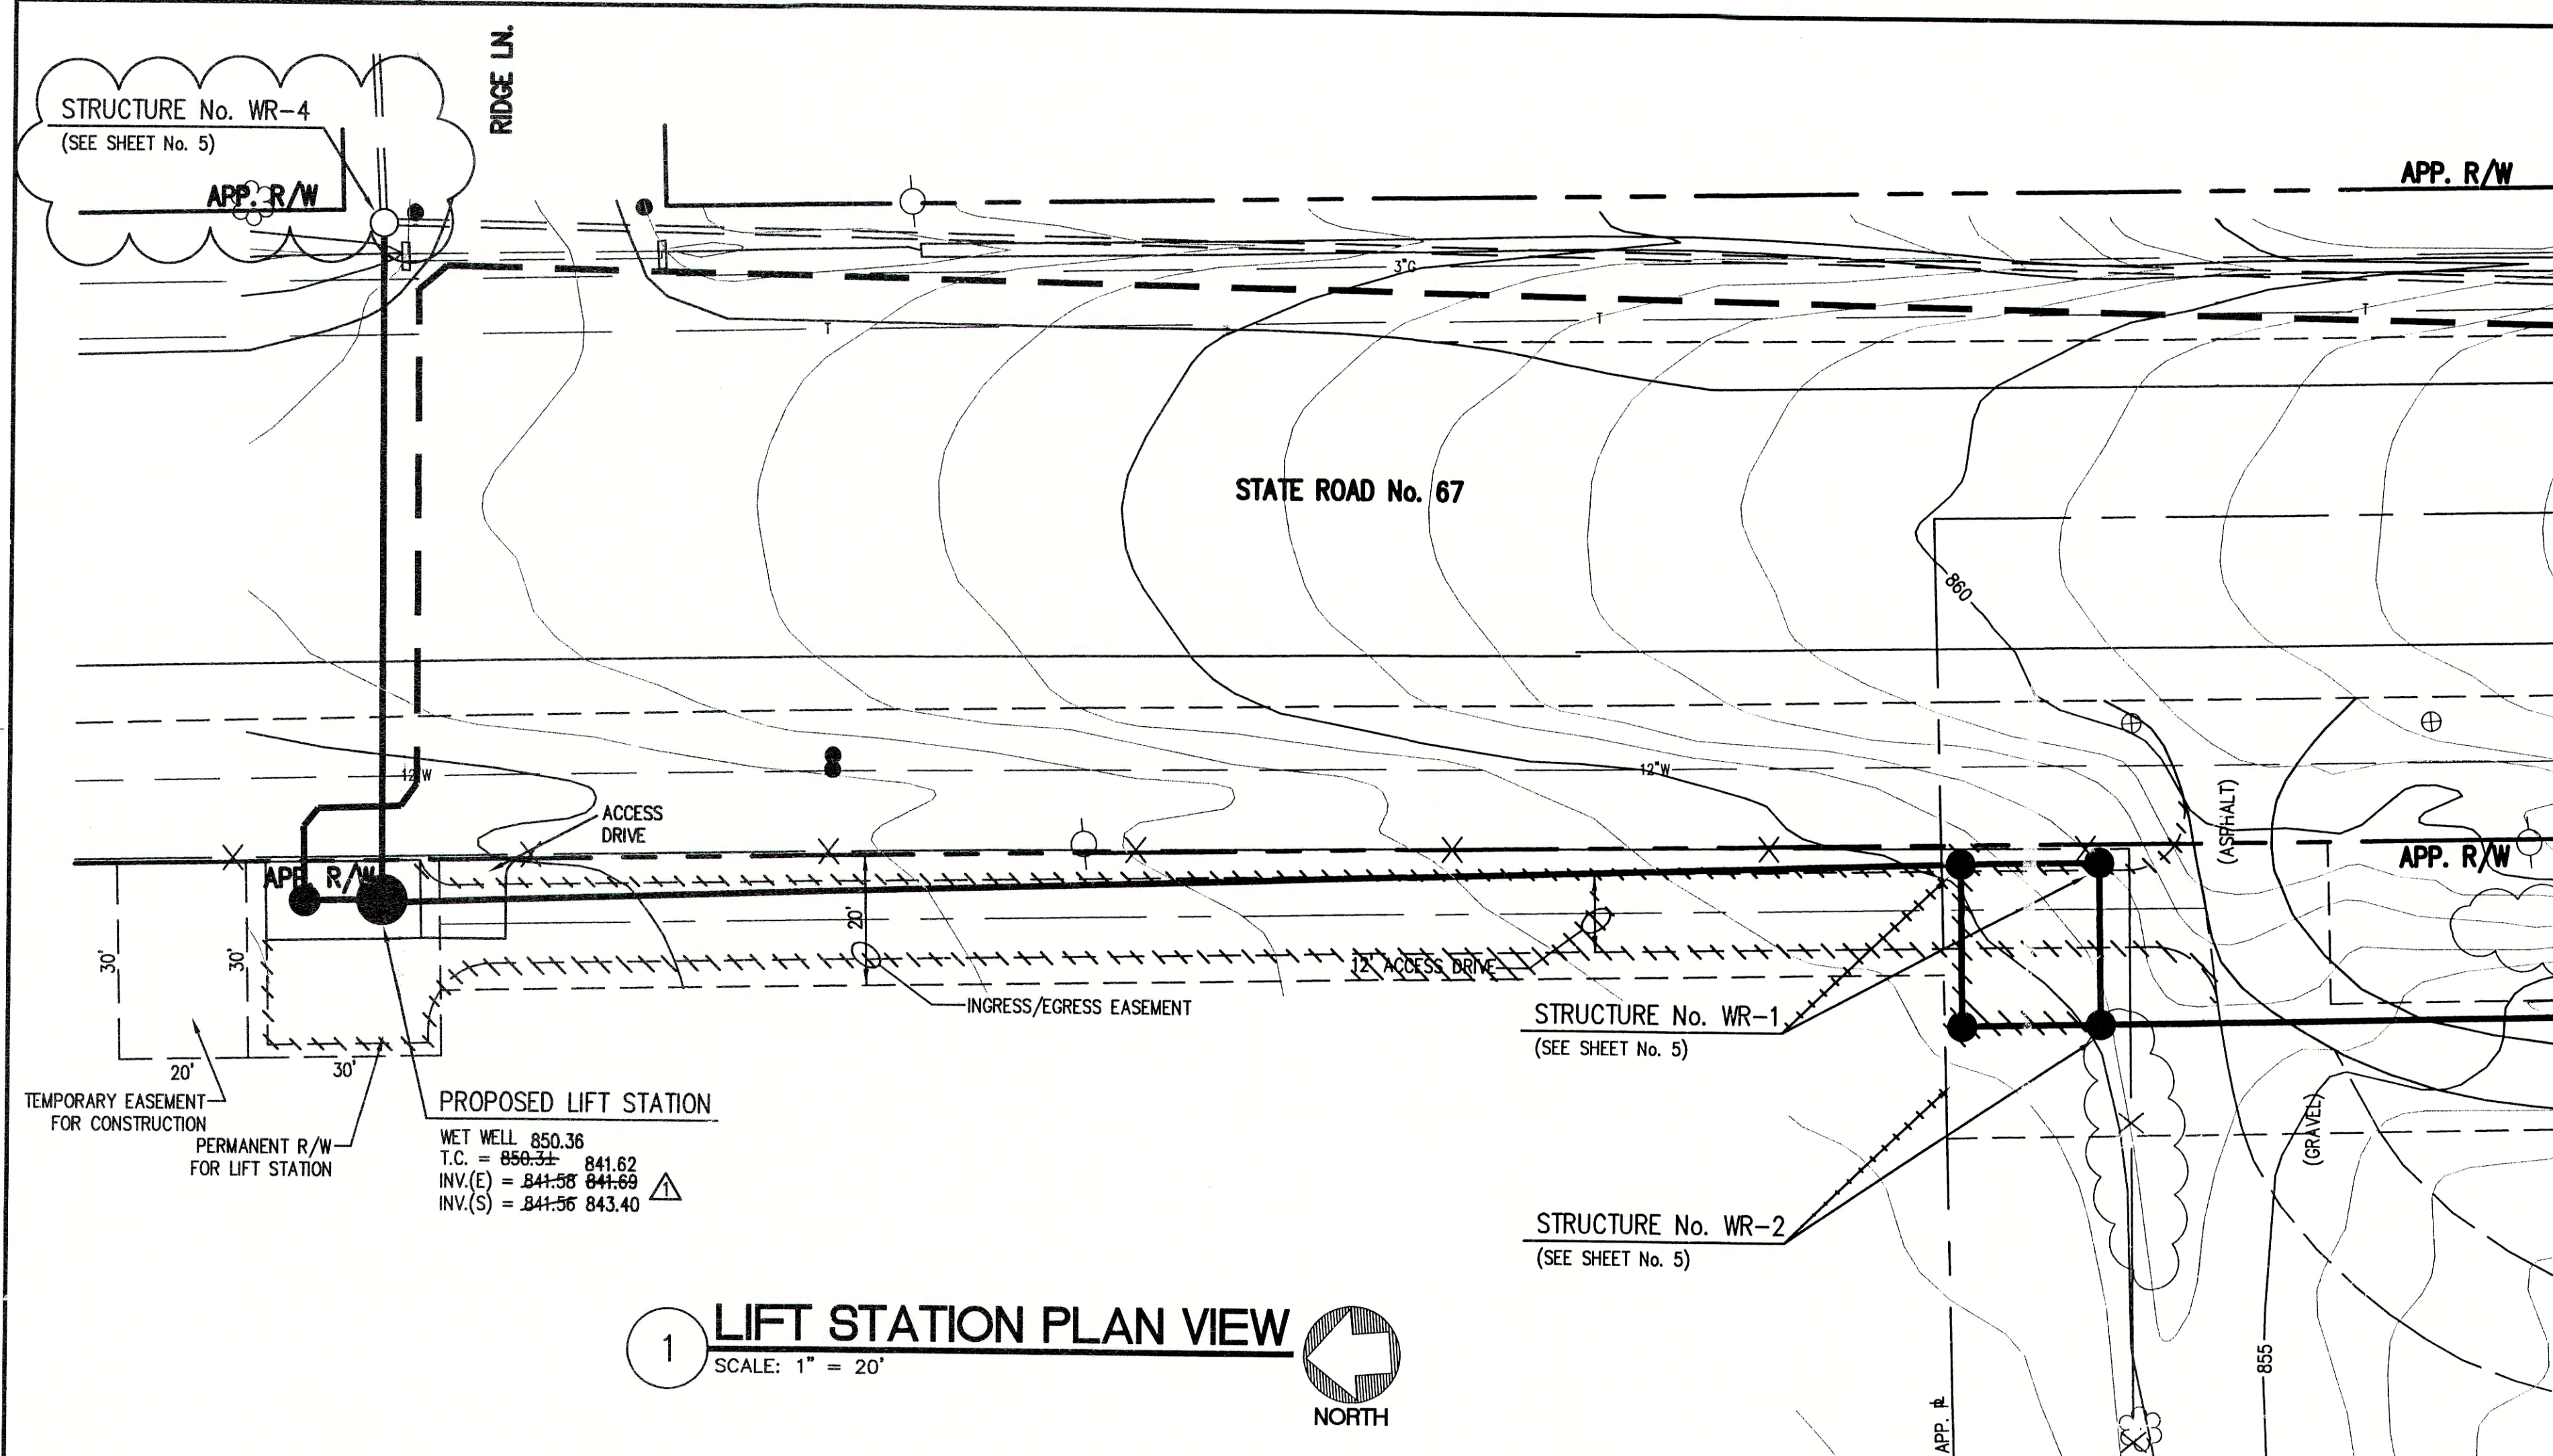

0 LIFT STATION SECTION
SCALE: N.T.S.

RECORD DRAWING February 15, 2001



- GENERAL NOTES:**
- CONTRACTOR TO VERIFY AVAILABLE POWER SOURCE PRIOR TO EQUIPMENT ORDER AND COORDINATE WORK WITH ELECTRIC UTILITY COMPANY.
 - PIPE PENETRATIONS TO UTILIZE FLEXIBLE BOOTS, CONNECTORS, CAST IN PLACE GASKETS, ETC. APPROVED BY ENGINEER PRIOR TO CONSTRUCTION.
 - CONTRACTOR TO INSTALL ALL EQUIPMENT IN COMPLETE ACCORDANCE WITH ALL MANUFACTURER'S RECOMMENDATIONS.
 - ALL FASTENERS, SUPPORTS, ETC. TO BE STAINLESS STEEL.
 - REFER TO SPECIFICATIONS FOR FURTHER INFORMATION.
 - ALL CONCRETE TO BE MINIMUM F_c = 4000 PSI. ALL REINFORCING STEEL TO BE MINIMUM F_y = 60,000 PSI.
 - ALL FERROUS METAL SURFACES TO BE PREPARED AND PAINTED.
 - CONTRACTOR TO COORDINATE WITH ALL OTHER APPLICABLE PLAN SHEETS AND SPECIFICATIONS.
 - CONTRACTOR TO TEST ALL EQUIPMENT, PIPING, STRUCTURES, ETC. IN ACCORDANCE WITH THE SPECIFICATIONS, PRIOR TO PLACING THE STATION INTO SERVICE IN THE PRESENCE OF ENGINEERS AND MANUFACTURERS REPRESENTATIVES.
 - CONCRETE STRUCTURE BELOW GRADE SHALL BE COATED WITH A BITUMINOUS COATING PER SPECIFICATIONS.

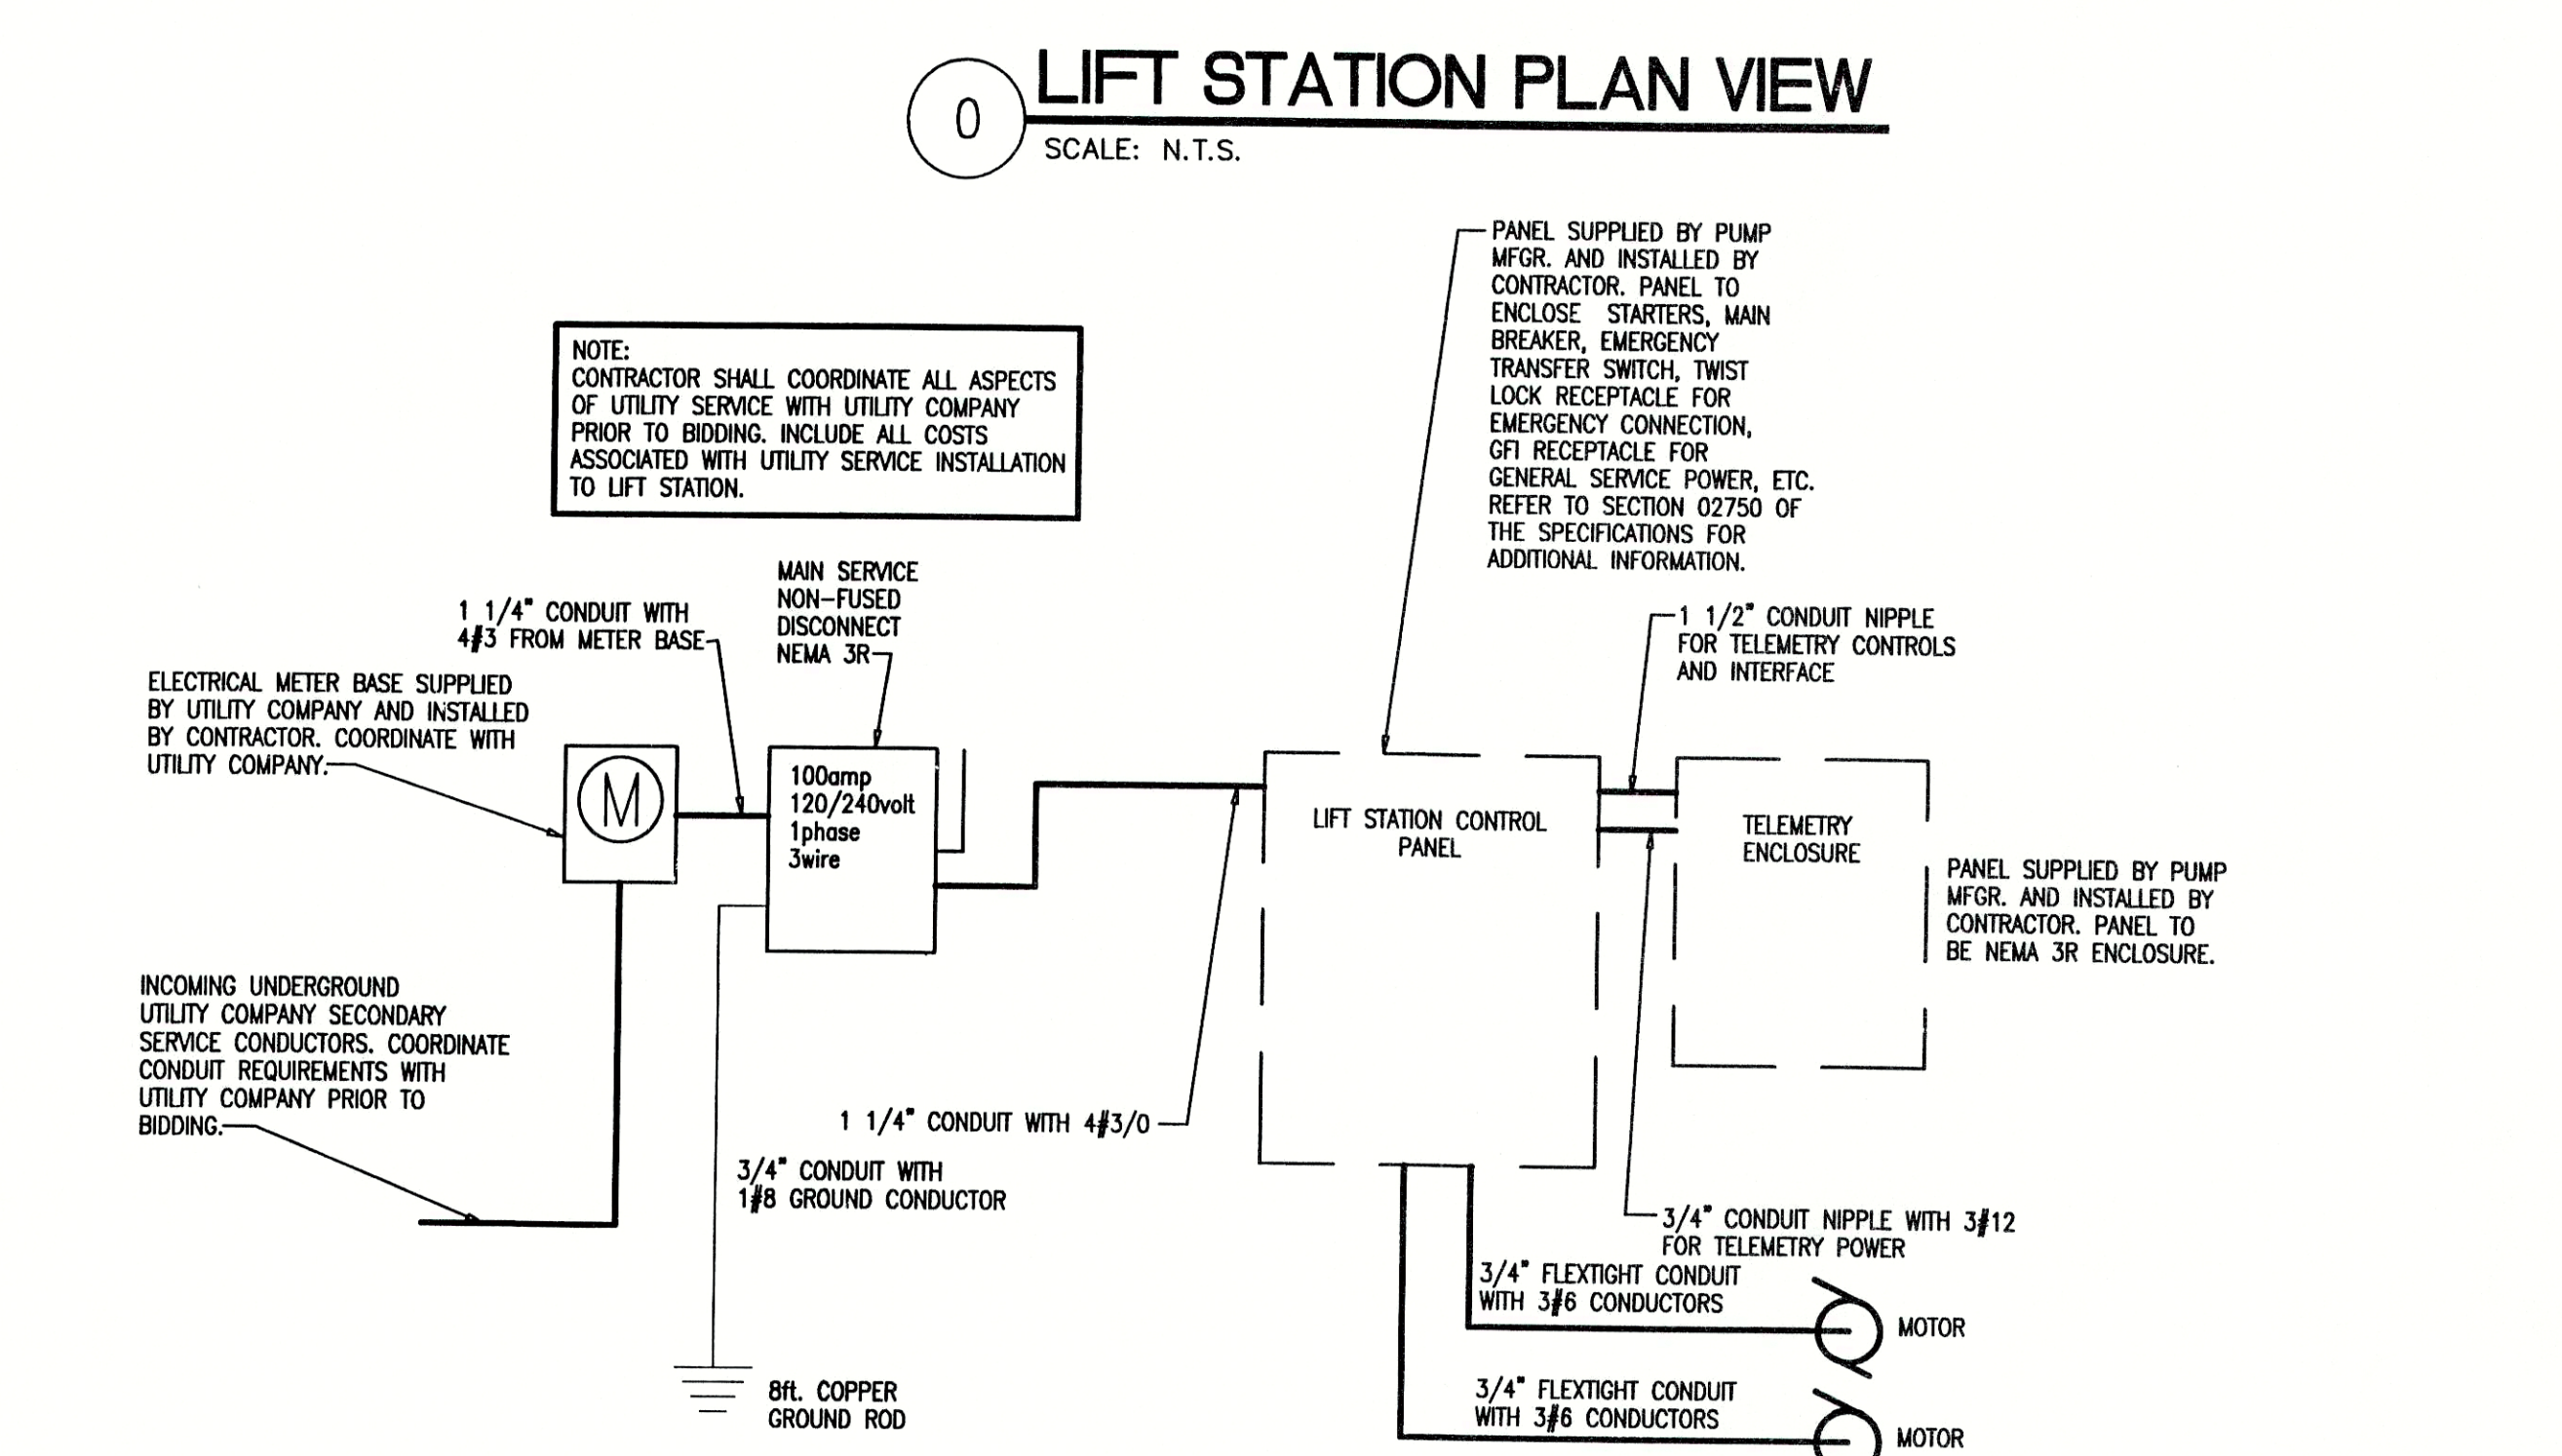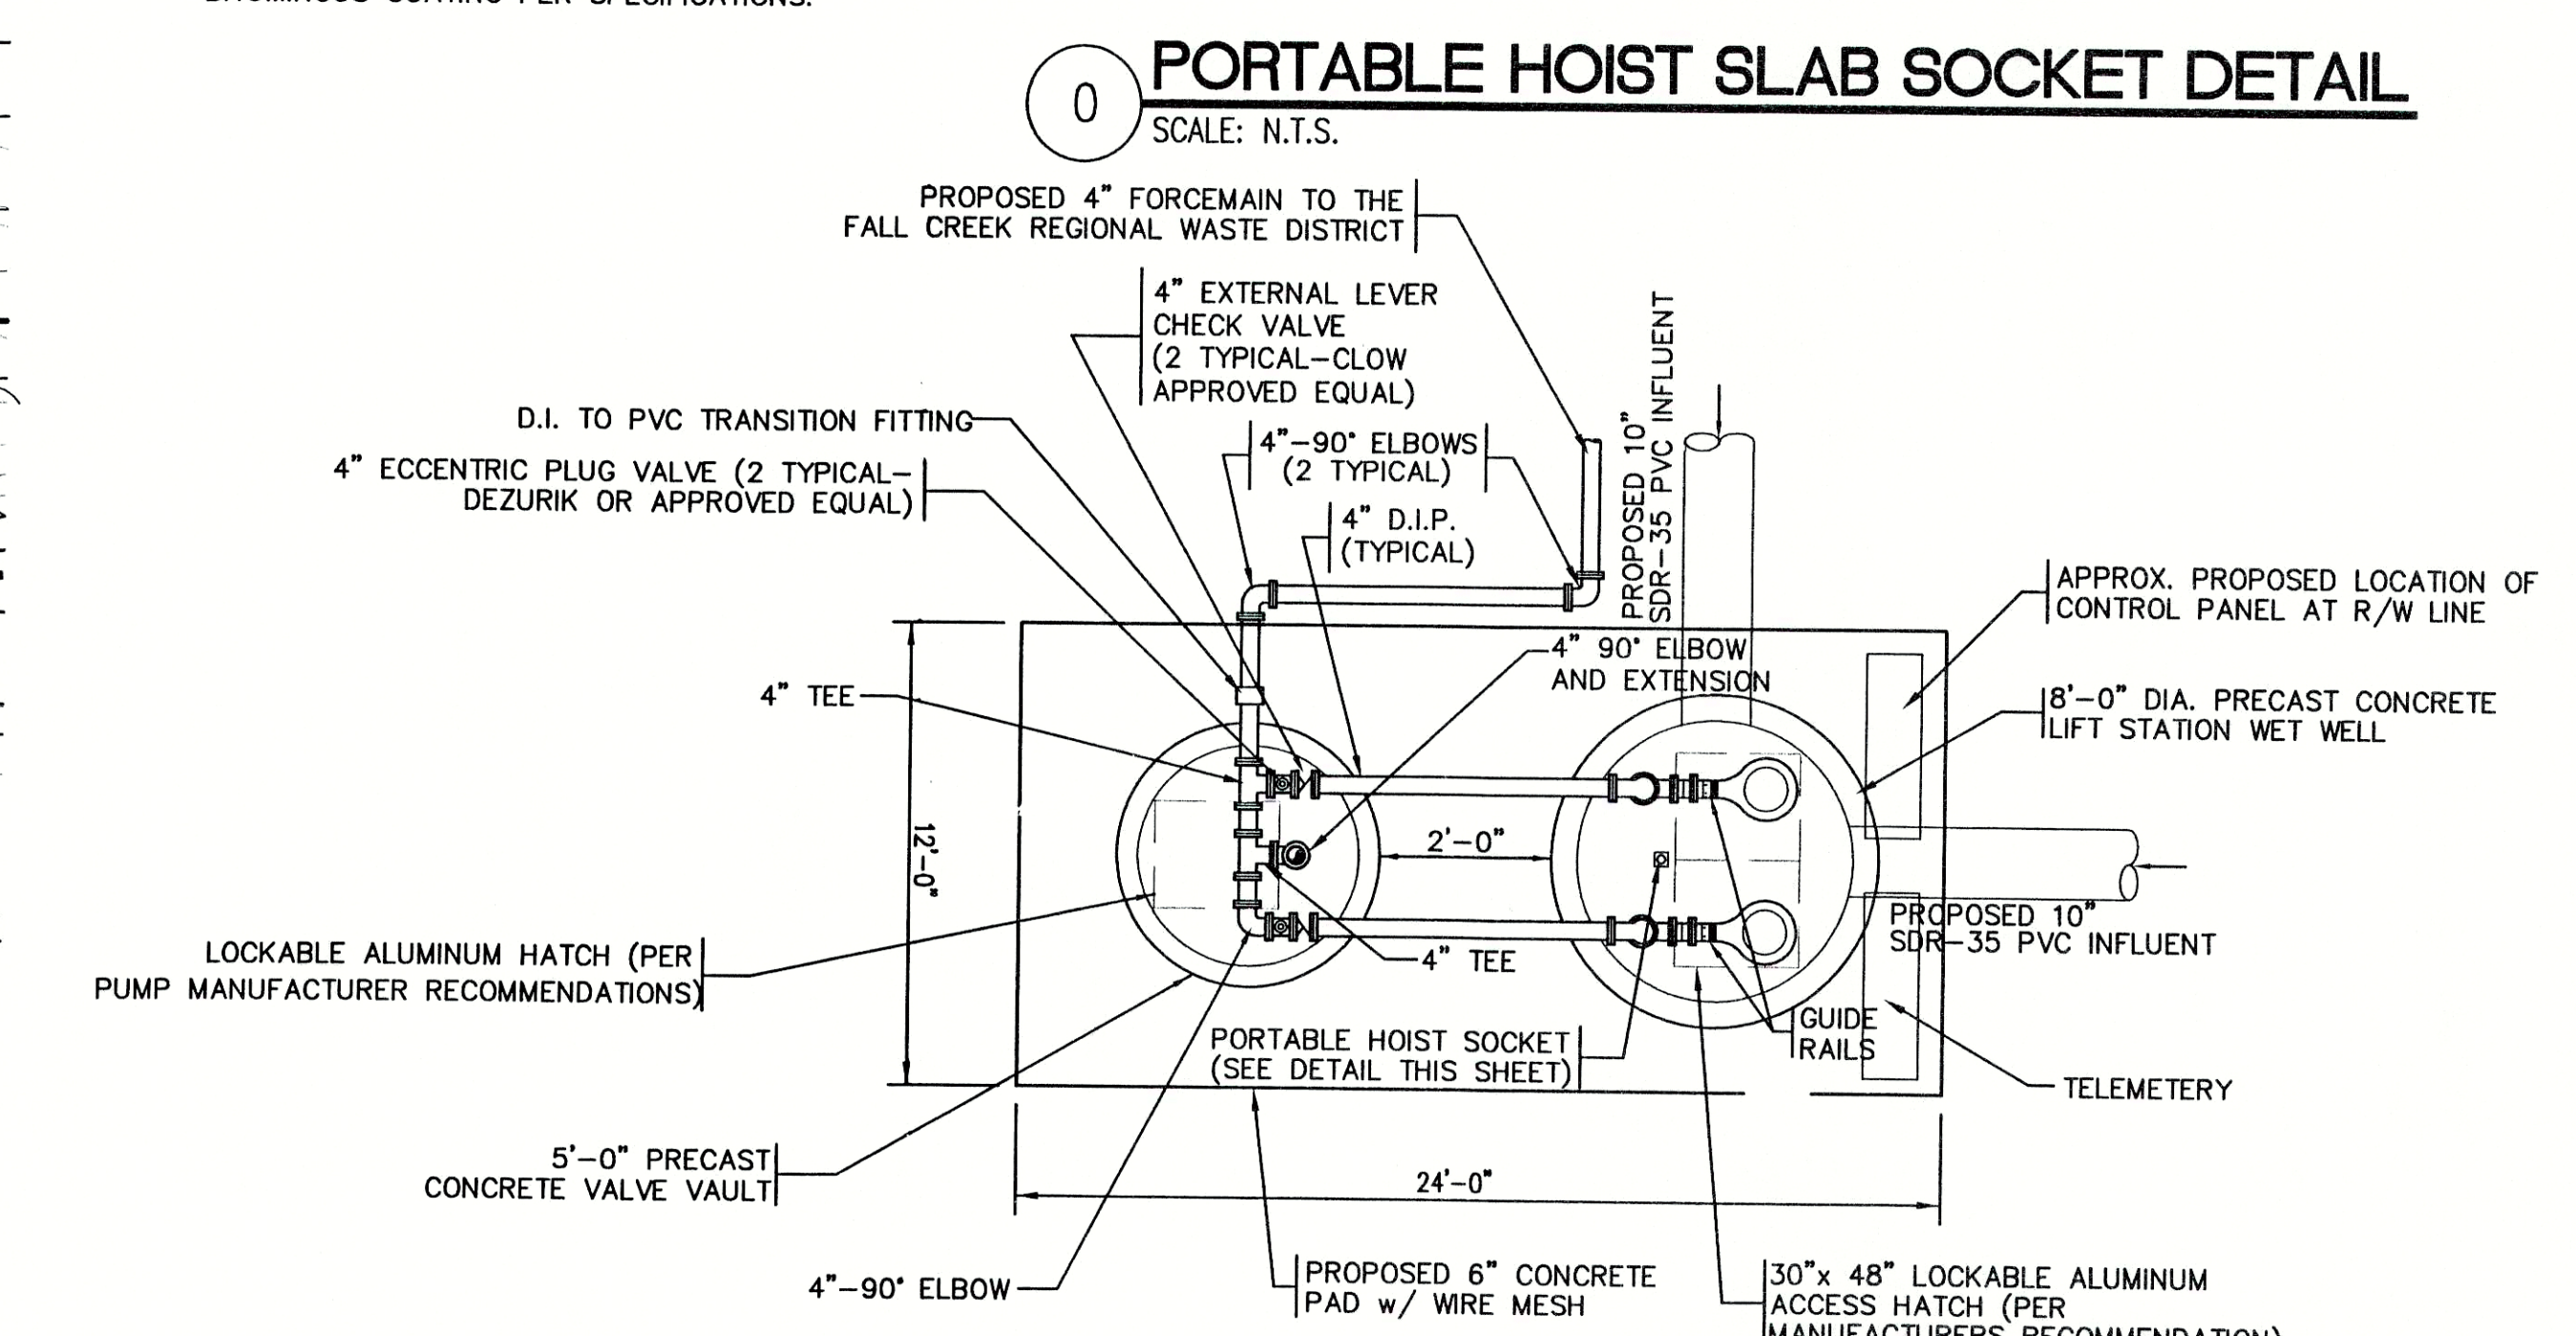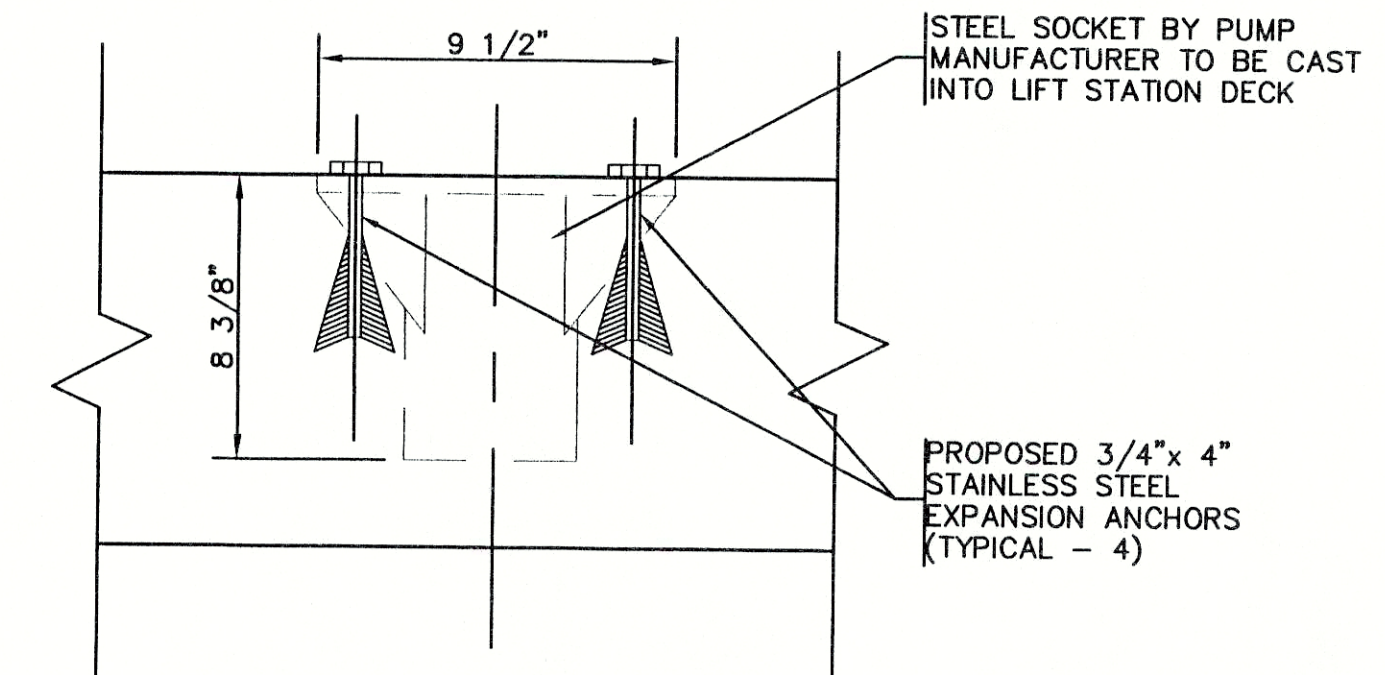

FILE NAME: REVSHIT_4-RD	PLOT SCALE: 1"=1	PLOT DATE: 12/5	TRIAD ASSOCIATES INC. INDIANAPOLIS, INDIANA	APPROVED BY: Thomas M. Schubert, P.E.	WOODED RIDGE SUBDIVISION FALL CREEK REGIONAL WASTE DISTRICT	
03/16/00 ELEVATION CHANGE	D.A.P.	LIFT STATION DETAIL				
03/16/00 PIPE SIZE CHANGE	D.A.P.	DRAWN BY: DAP DATE: 4/12/98 PROJECT No. 98008A SHEET No. 16 OF 18				
DESIGNED BY: D.A. Pauling			CHECKED BY: James W. Frazell, P.E.			



18

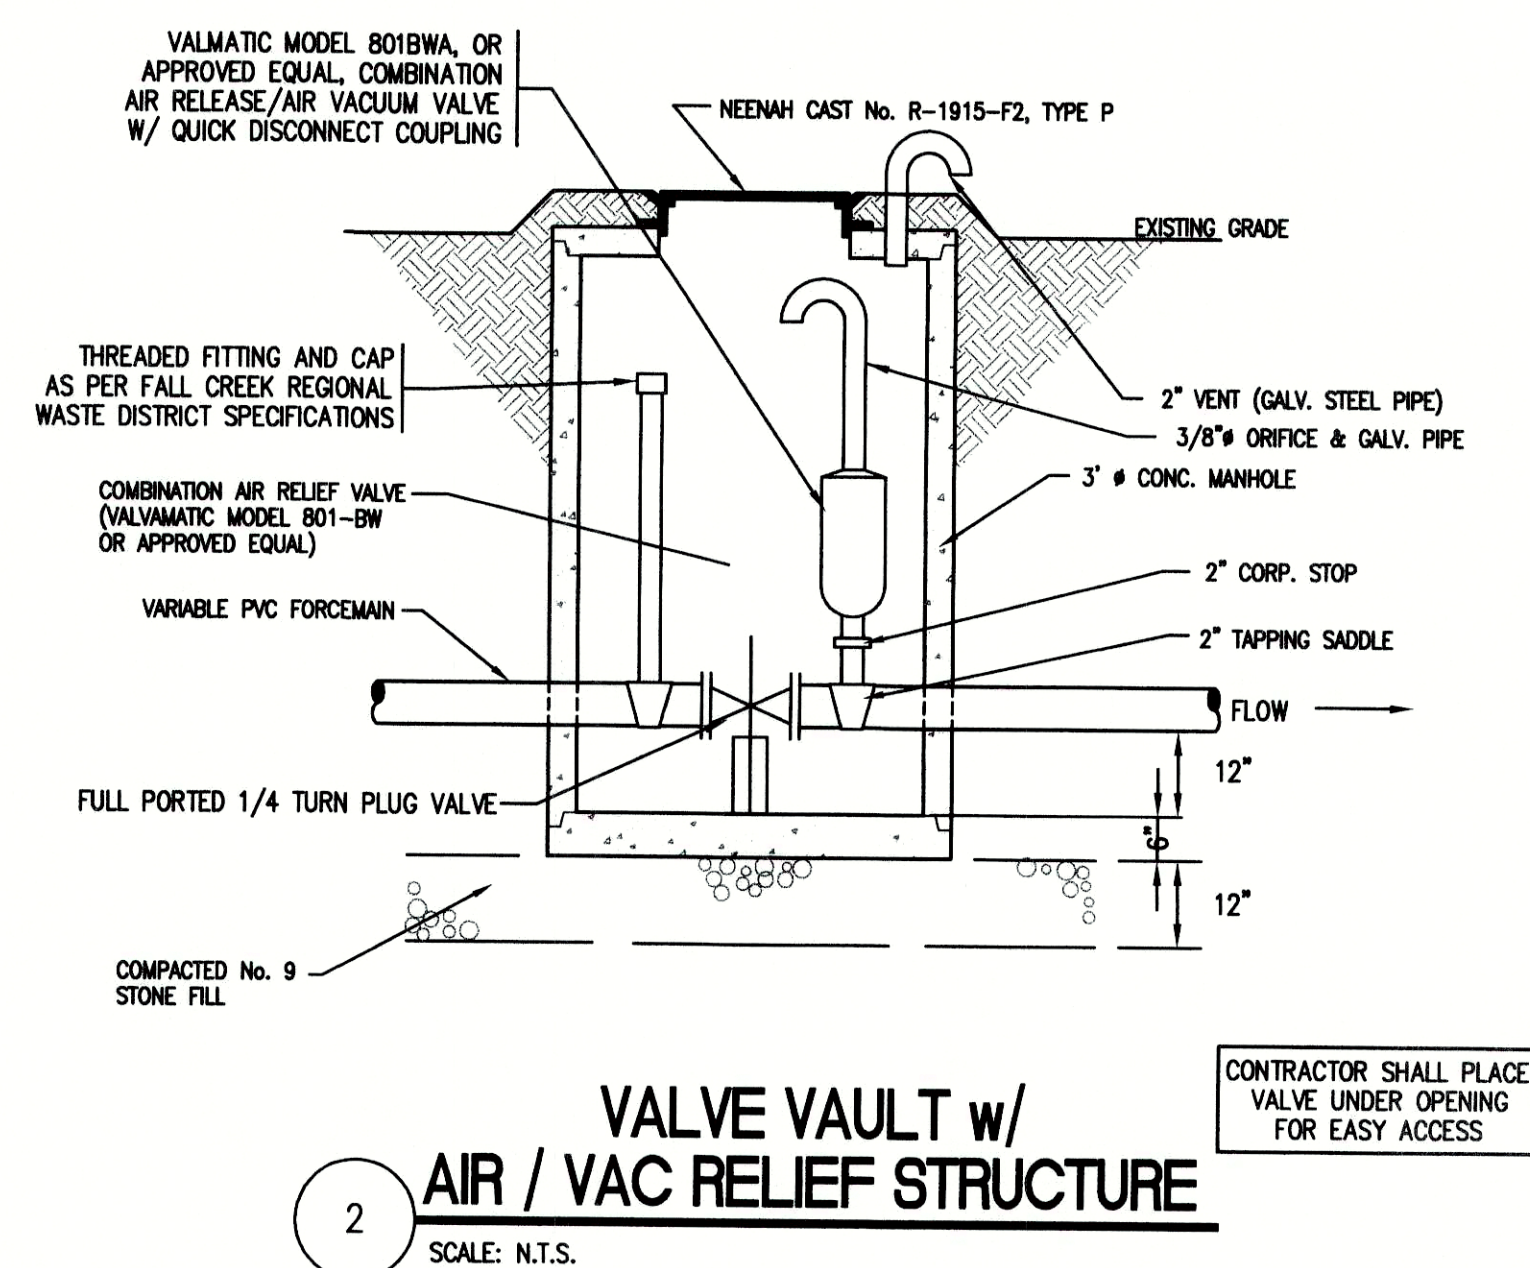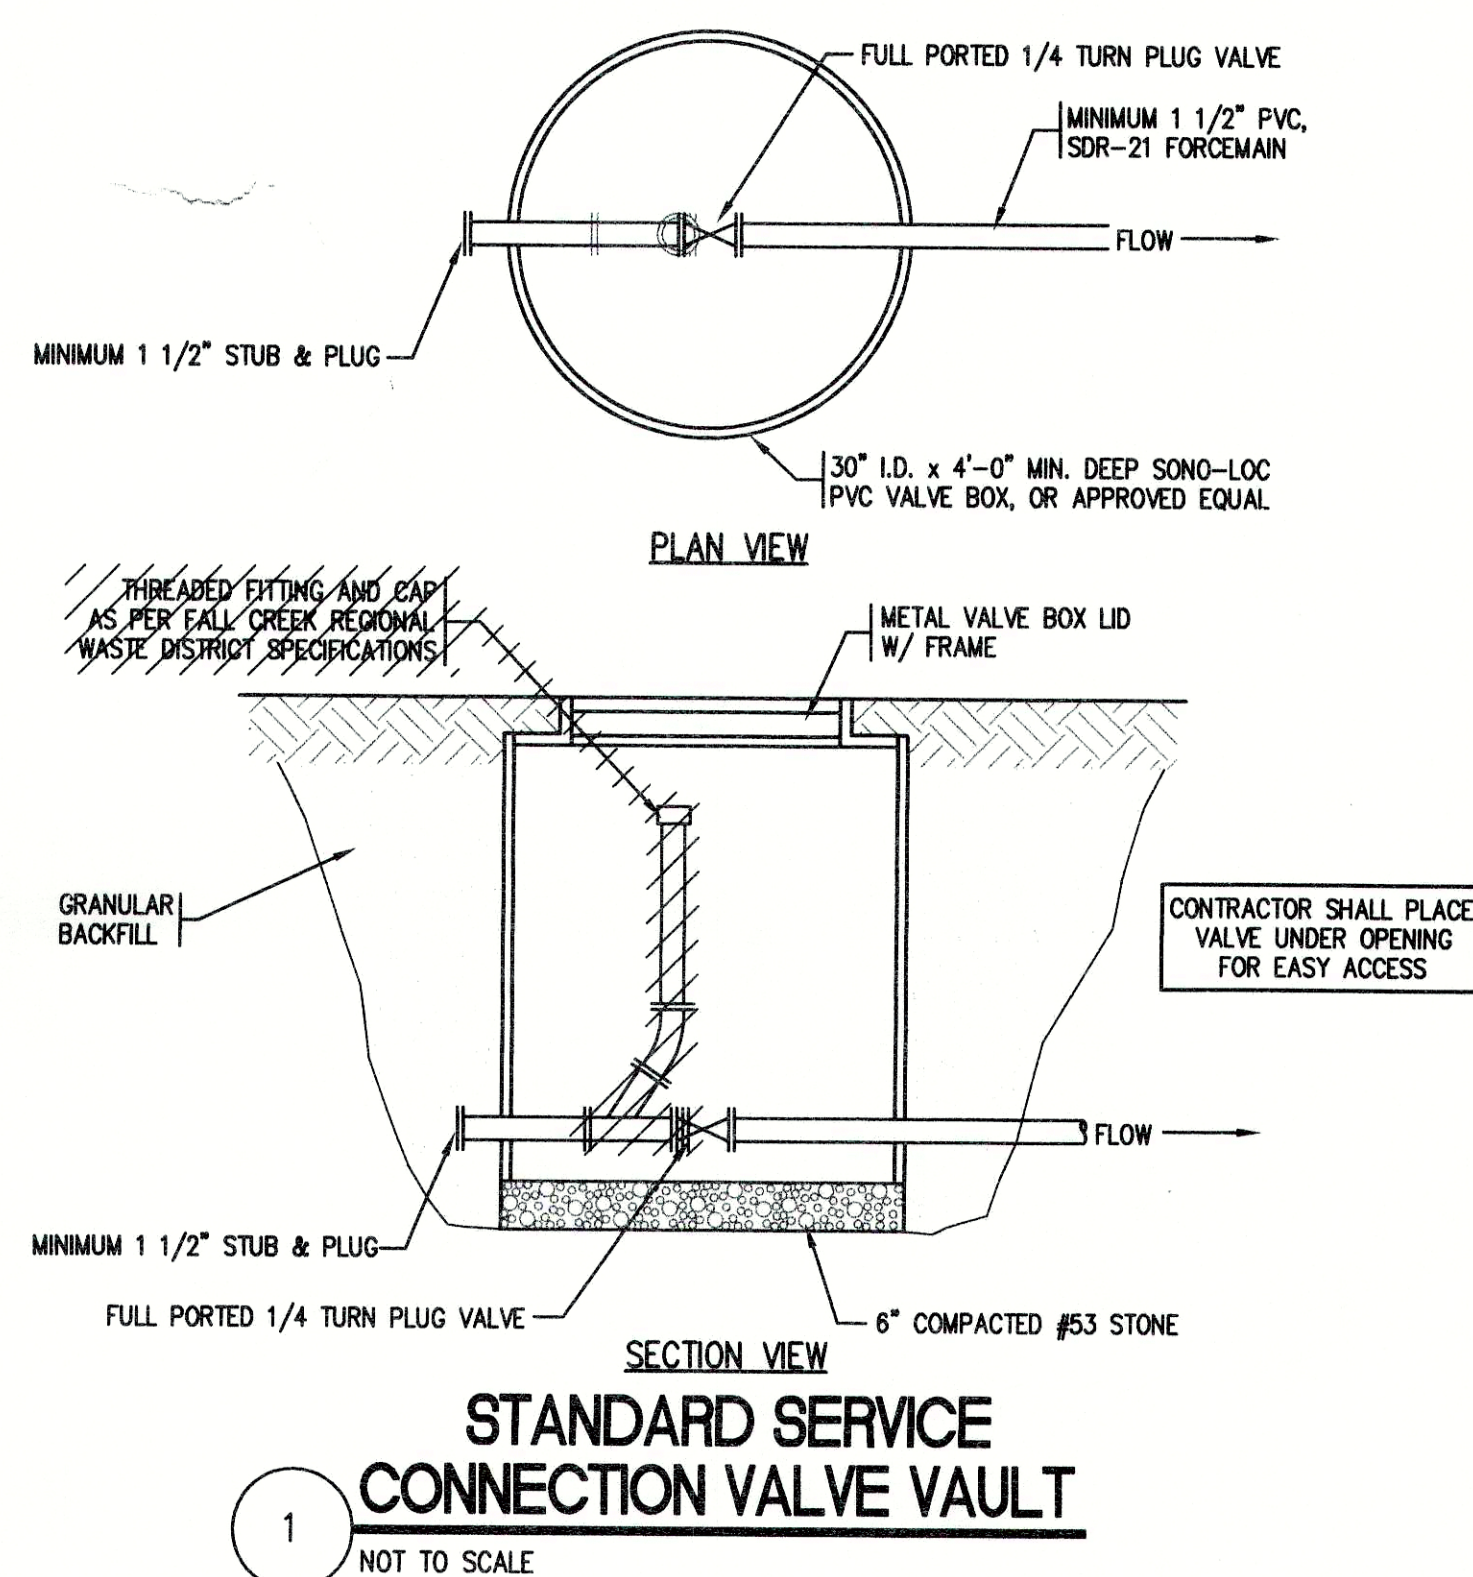

RECORD DRAWING
February 15, 2001

FILE NAME: WORDG_D2-RD		PLOT SCALE: 1=1	PLOT DATE: 12/6
NO.	DATE	DESCRIPTION	BY

TRIAD ASSOCIATES INC.
INDIANAPOLIS, INDIANA

APPROVED BY:
THOMAS M. SCHUBERT
No. 15614
STATE OF INDIANA
REGISTERED PROFESSIONAL ENGINEER

WOODED RIDGE SUBDIVISION
FALL CREEK REGIONAL WASTE DISTRICT
STANDARD SANITARY SEWER DETAILS

DRAWN BY: DAP	DATE: 04/12/98	PROJECT No. 98008A	SHEET No. 18
DESIGNED BY: D.A. Pauling	SCALE: AS NOTED	CHECKED BY: James W. Frazell, P.E.	18 OF 18